



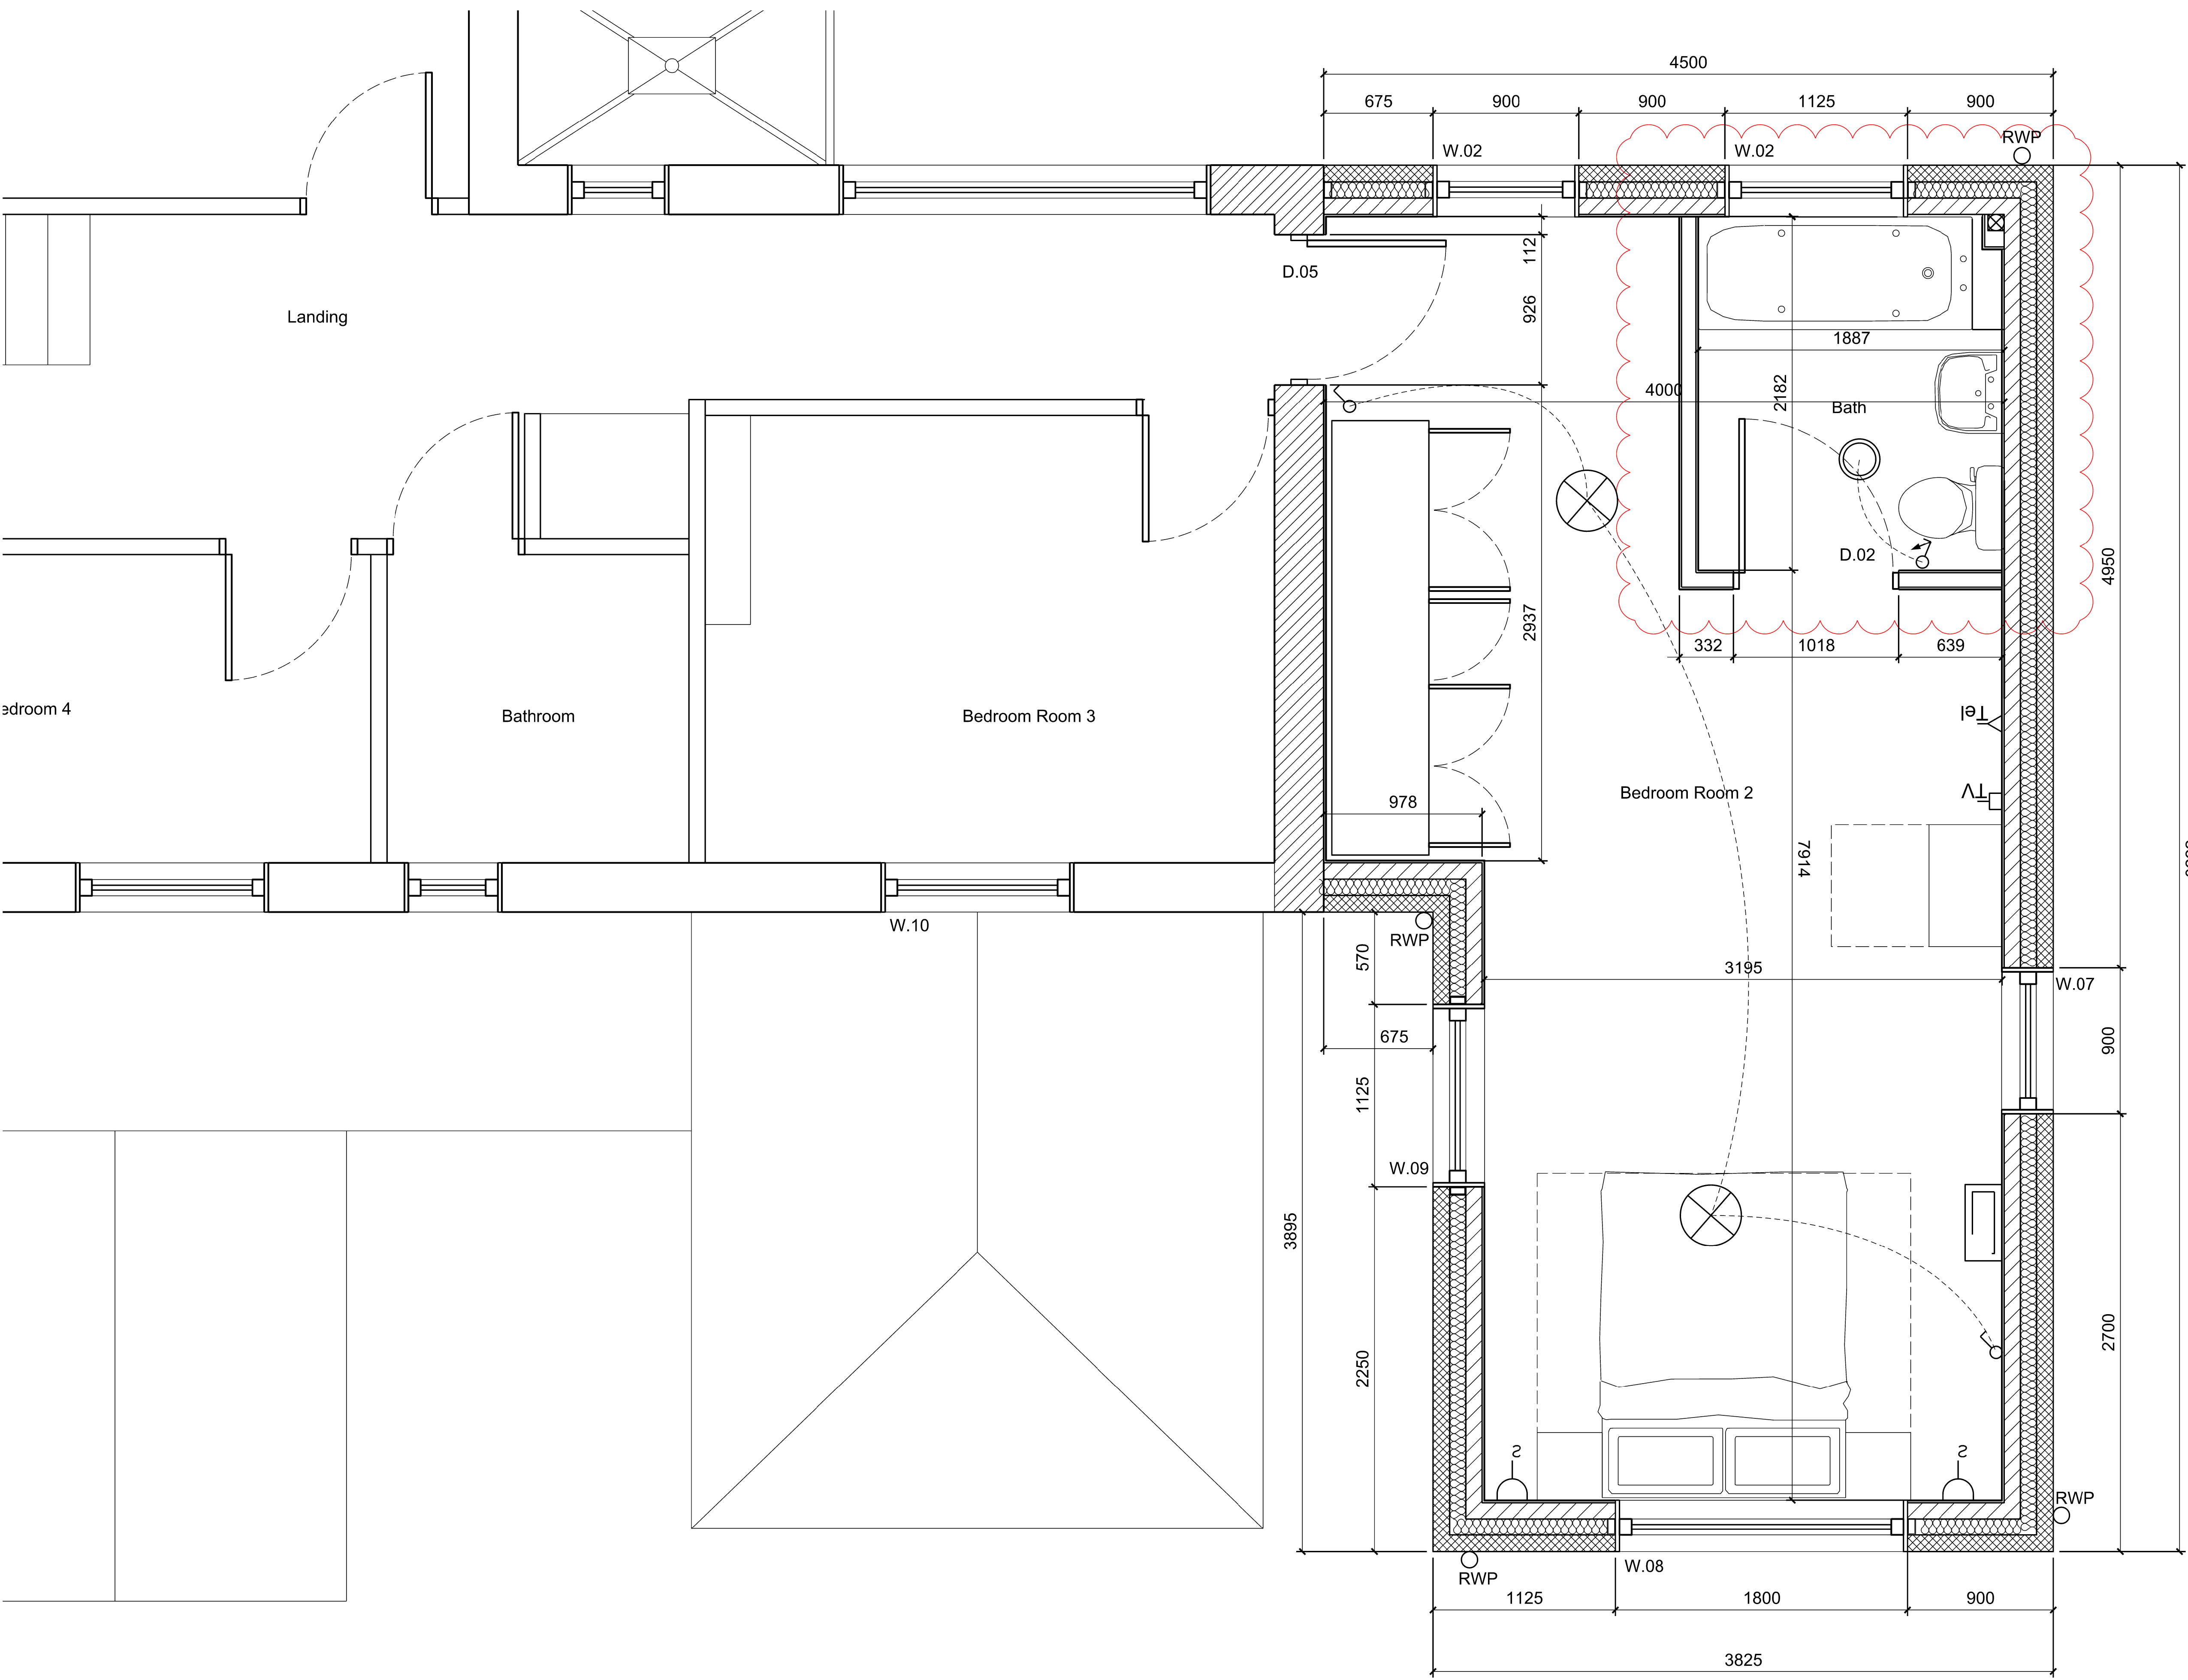

KEY:	
	Twin 13A switched socket
	13A unswitched socket
	Mechanical extract fan
	45A DP switched cooker panel
	13A switch to control an unswitched socket
	Switch Single Pole 1-way
	Pull switch Single Pole 1-way
	Television aerial socket
	Telephone socket
	Low Energy Ceiling rose with short pendant light fitting
	Low Energy WC/Bathroom ceiling light fitting (sealed unit)
	Modern radiator.
	Masonry in fill or making good and re plastering
	Mains Powered Smoke Detector
	Mains Powered Heat detector

Notes
Do not scale from drawing use figured dimenions only

Date	DWN	Description
19/03/2015	K.M	A. Construction Issue
18/07/2015	K.M	B. Electrical details added.
20/03/2016	K.M	C. Ensuite bathroom added to first floor

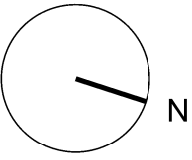

CLIENT
Mr & Mrs Paterson

ARCHITECT
Kenneth Mwaniki
e-mail: kenmwaniki@hotmail.co.uk
Tel: +44 7809575090

JOB		
8 Peterborough Road : WD 012 FF		
Setting Out Plan		
TENDER		
Scale(s)	Date	Drawn
1:50 @ A1	25/05/2014	K.M
Job No	Drawing No	Revision
003	013	C