

Notes:

Responsibility is not accepted for errors made by others in scaling from this drawing. All construction information should be taken from figured dimensions only.


Contractors must check all dimensions from site.

This drawing should be read in conjunction with all relevant consultant and specialist sub-contractor, supply chain drawings and specifications.


Any discrepancies found between this drawing and other drawings given elsewhere to be reported to client.

All works to be carried out in accordance with the latest British Standards / Codes of Practice.

KEY:	
	Proposed foul water sewer
	Proposed surface water sewer
	Indicates direction of fall
	Indicates rainwater downpipe locations (110Ø RWPs with roddable bottle gullies below)
	Indicates 16 No. Polypipe Polystorm Soakaway Crates – PSM1A 2000mm (L) x 2000mm (W) x 800mm (D)
	Indicates stub stack + air admittance valve
	Indicates soil pipe
	Existing foul water sewer
	Indicates site boundary

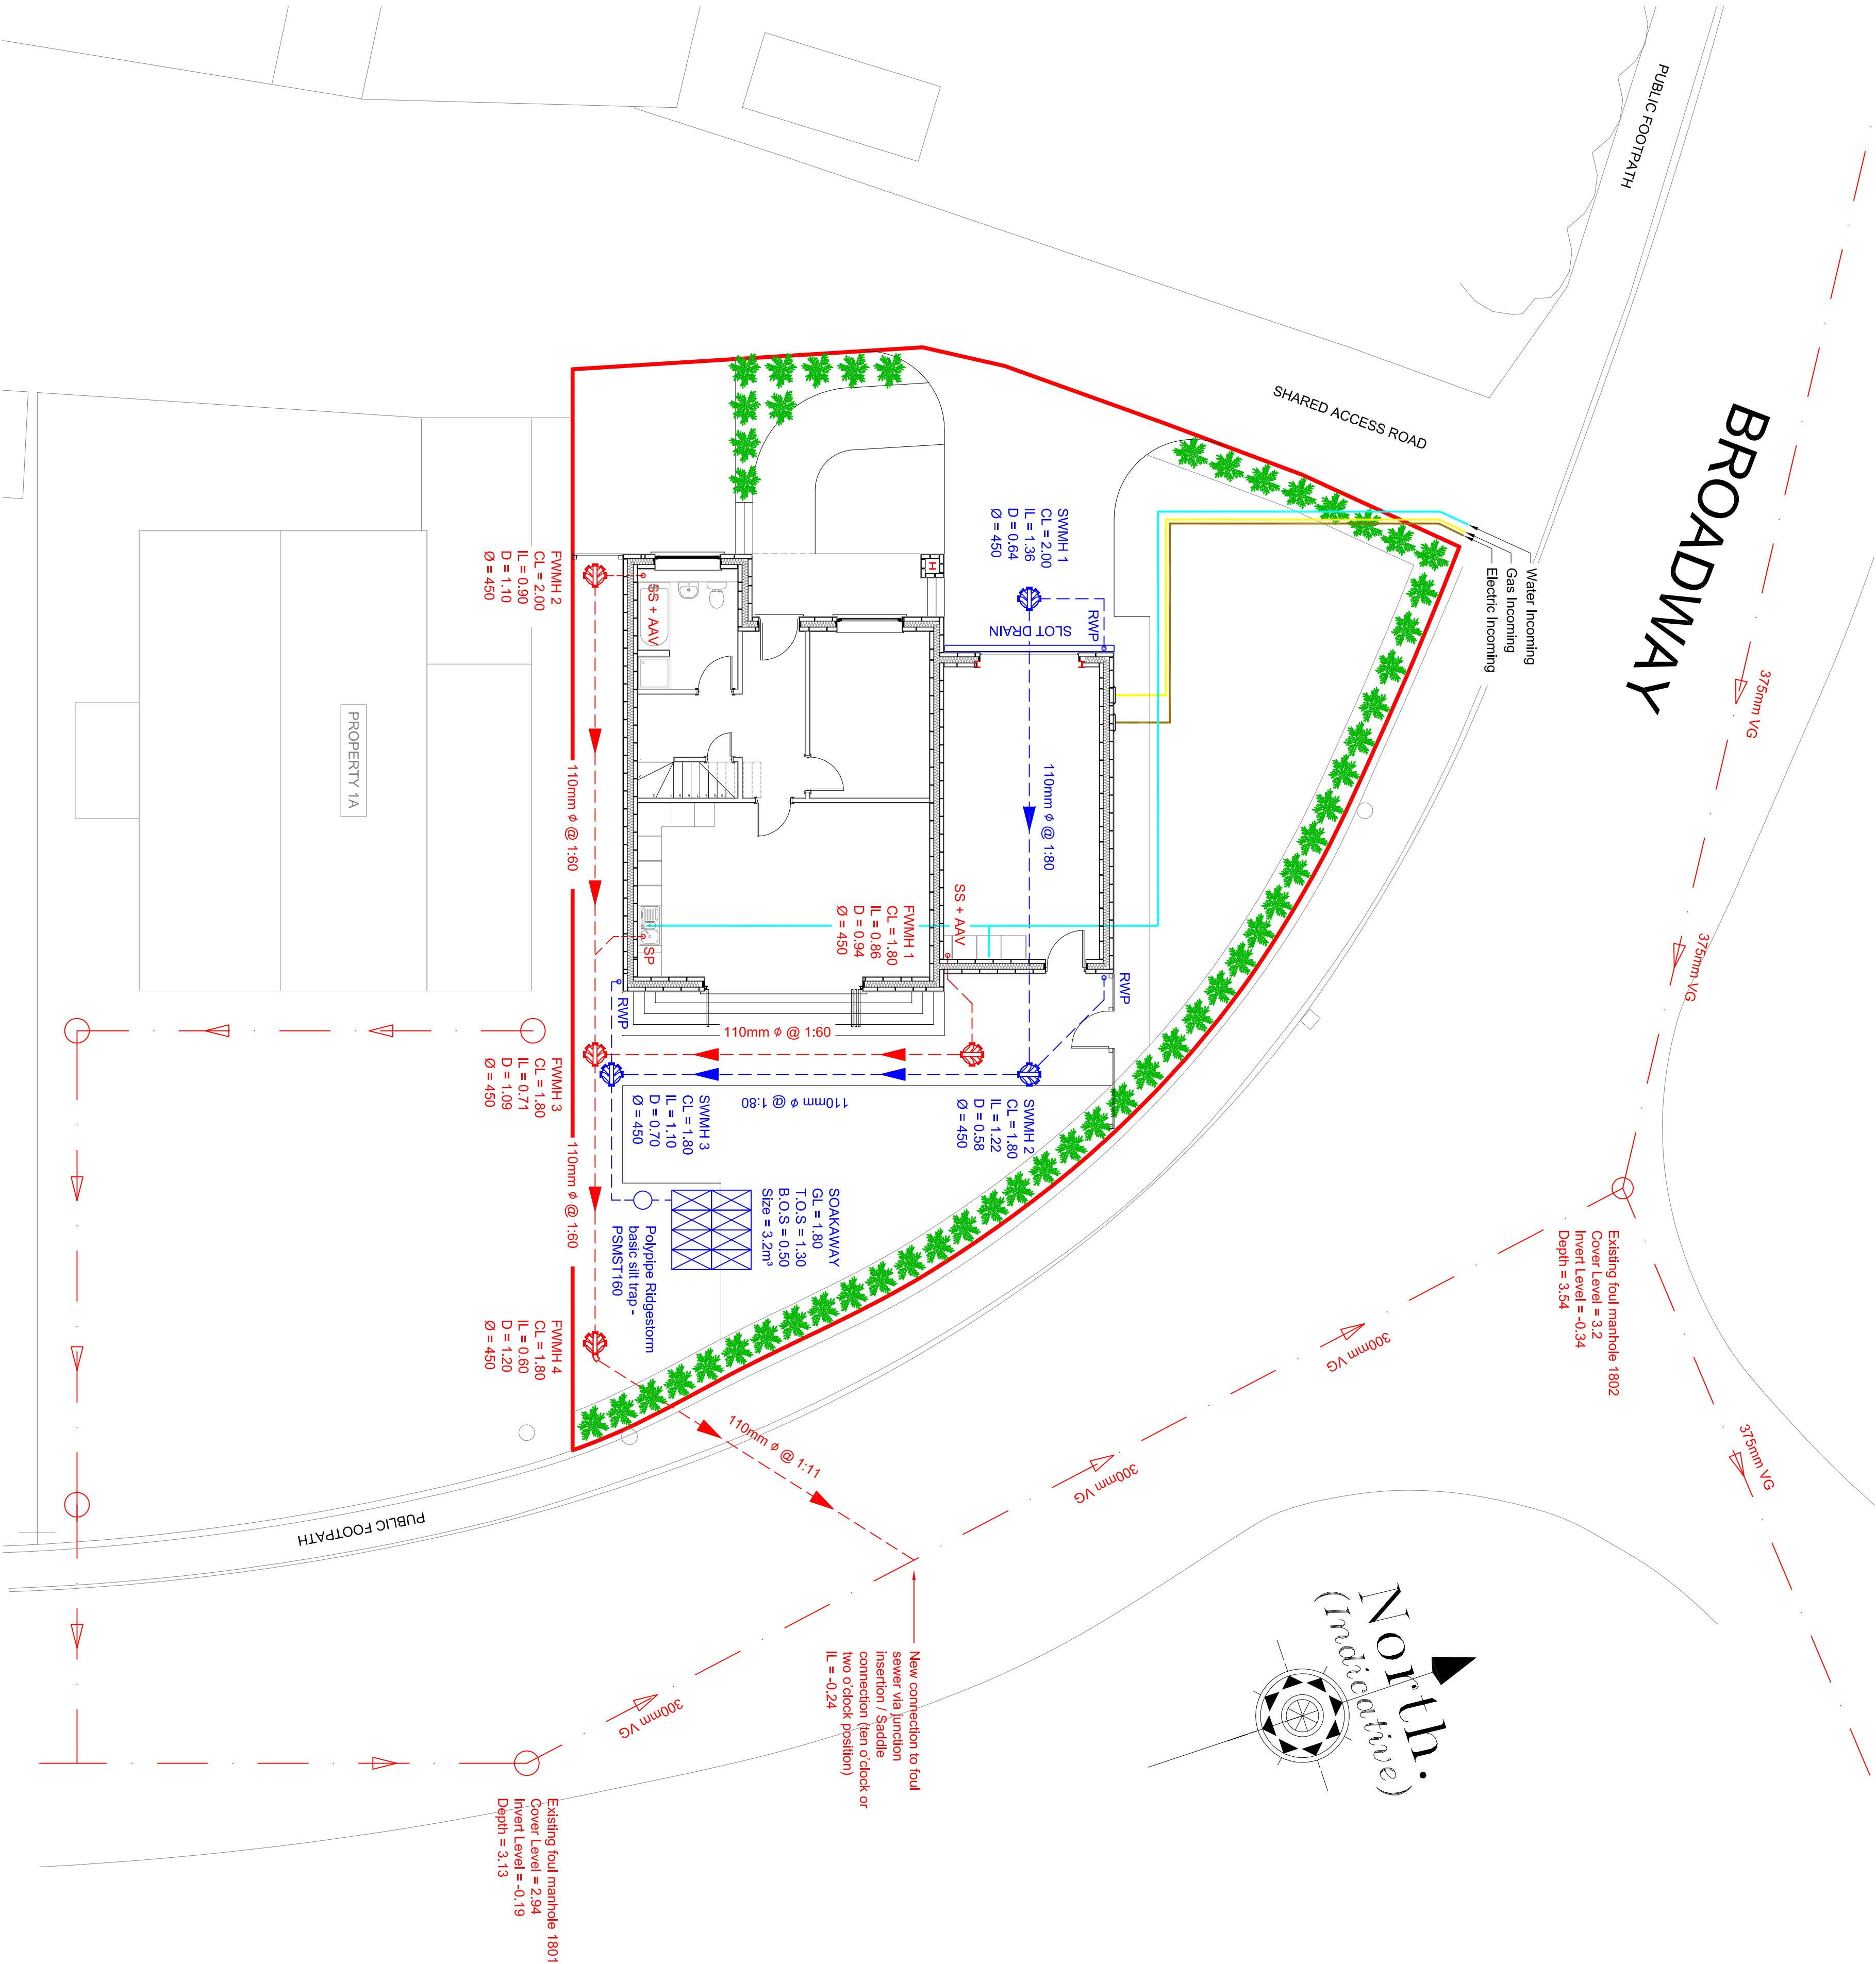

1:100 SCALE BAR (m)

 

Rev	Amendments	Date
Address		
LAND AT JUNCTION OF BROADWAY / PETERBOROUGH ROAD, CROWLAND, Lincs		
Proposal		
PROPOSED NEW DWELLING		

Title			
PROPOSED DRAINAGE LAYOUT			
Drawing No.	Rev	Scale	Date
SL/05	-	1:100 @ A1	18.09.20