


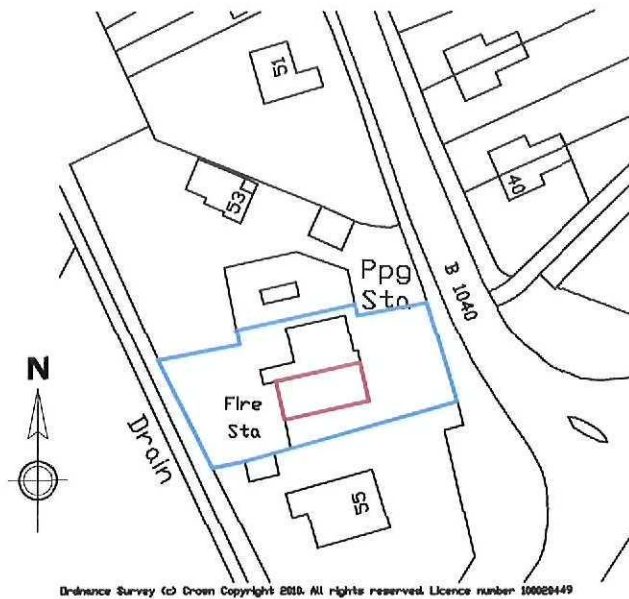

Ordnance Survey (c) Crown Copyright 2010. All rights reserved. Licence number 100029449



Scale 1:1250
0m 20m 50m 100m


Title: Site Plan
Dwg No: L-FRE-004Z-10-05 Revision: 1st
Scale: 1:1250 @ A4 Date: Nov 2010

Project: Proposed installation of PV Solar Panels

Location: Crowland Fire Station
Thorney Road, Crowland, PE6 0AL

Client: LCC Fire & Rescue

Crowland Fire Station

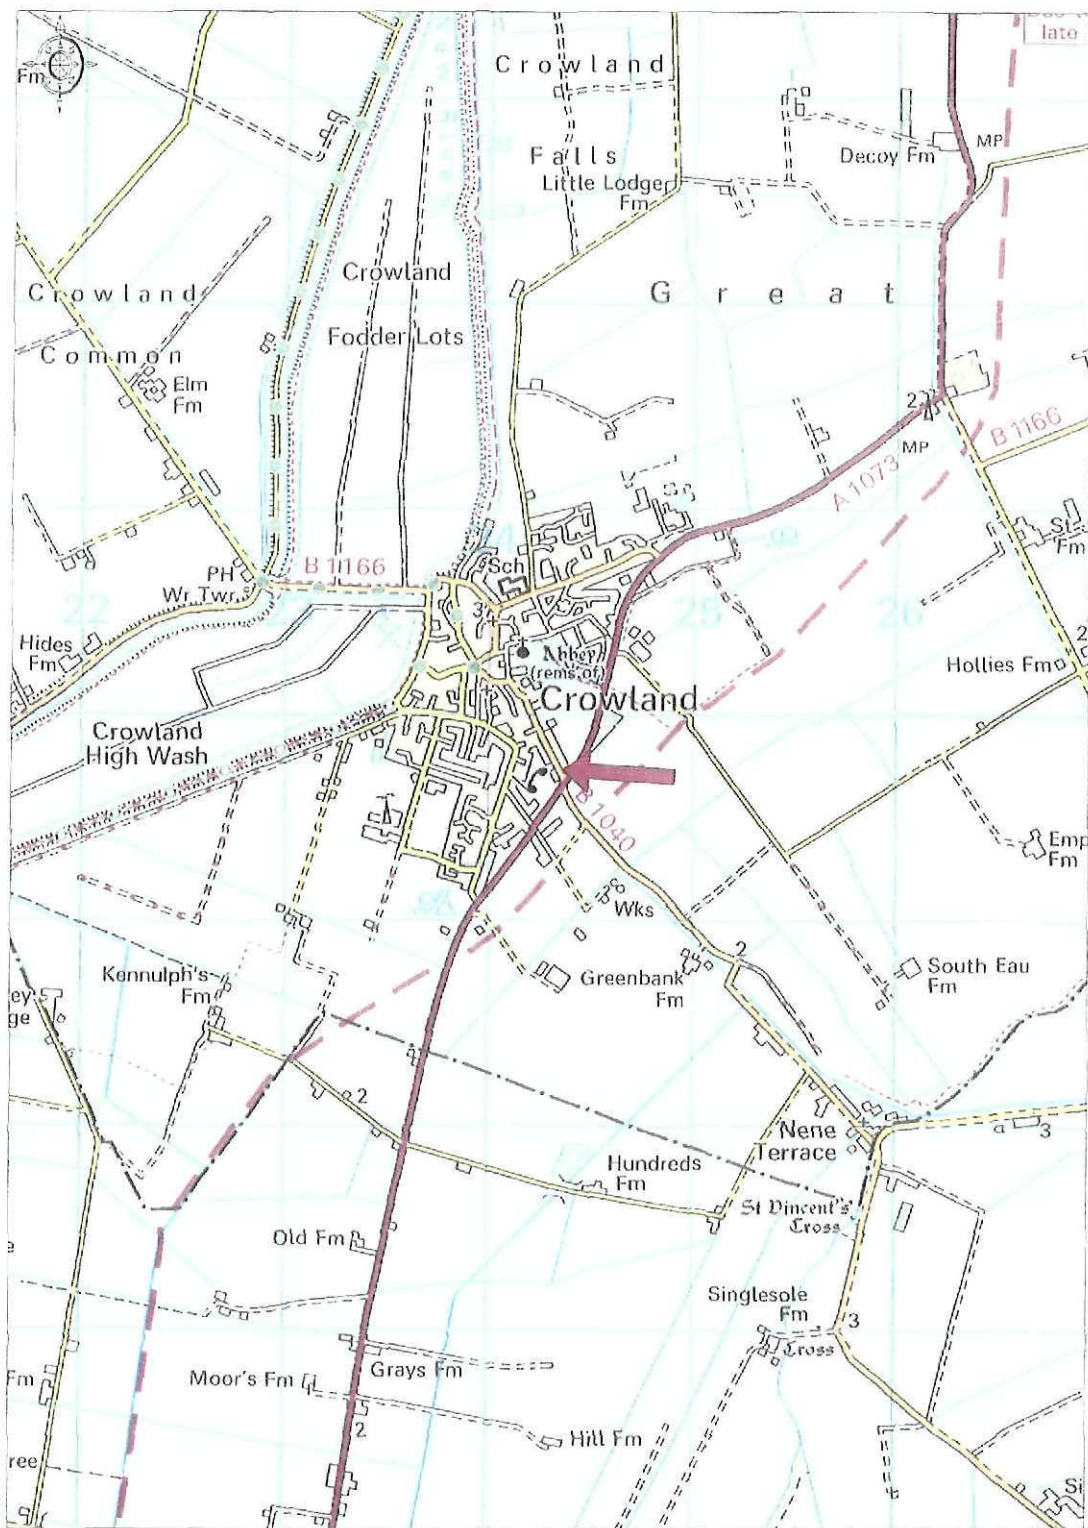


Ordnance Survey © Crown Copyright 2010. All rights reserved.
License number 100020446.11001 Scale 1:35000

Location Plan, 1:35000 @ A4


SHDC
Planning & Development

18 NOV 2010

Ref: 0957-10

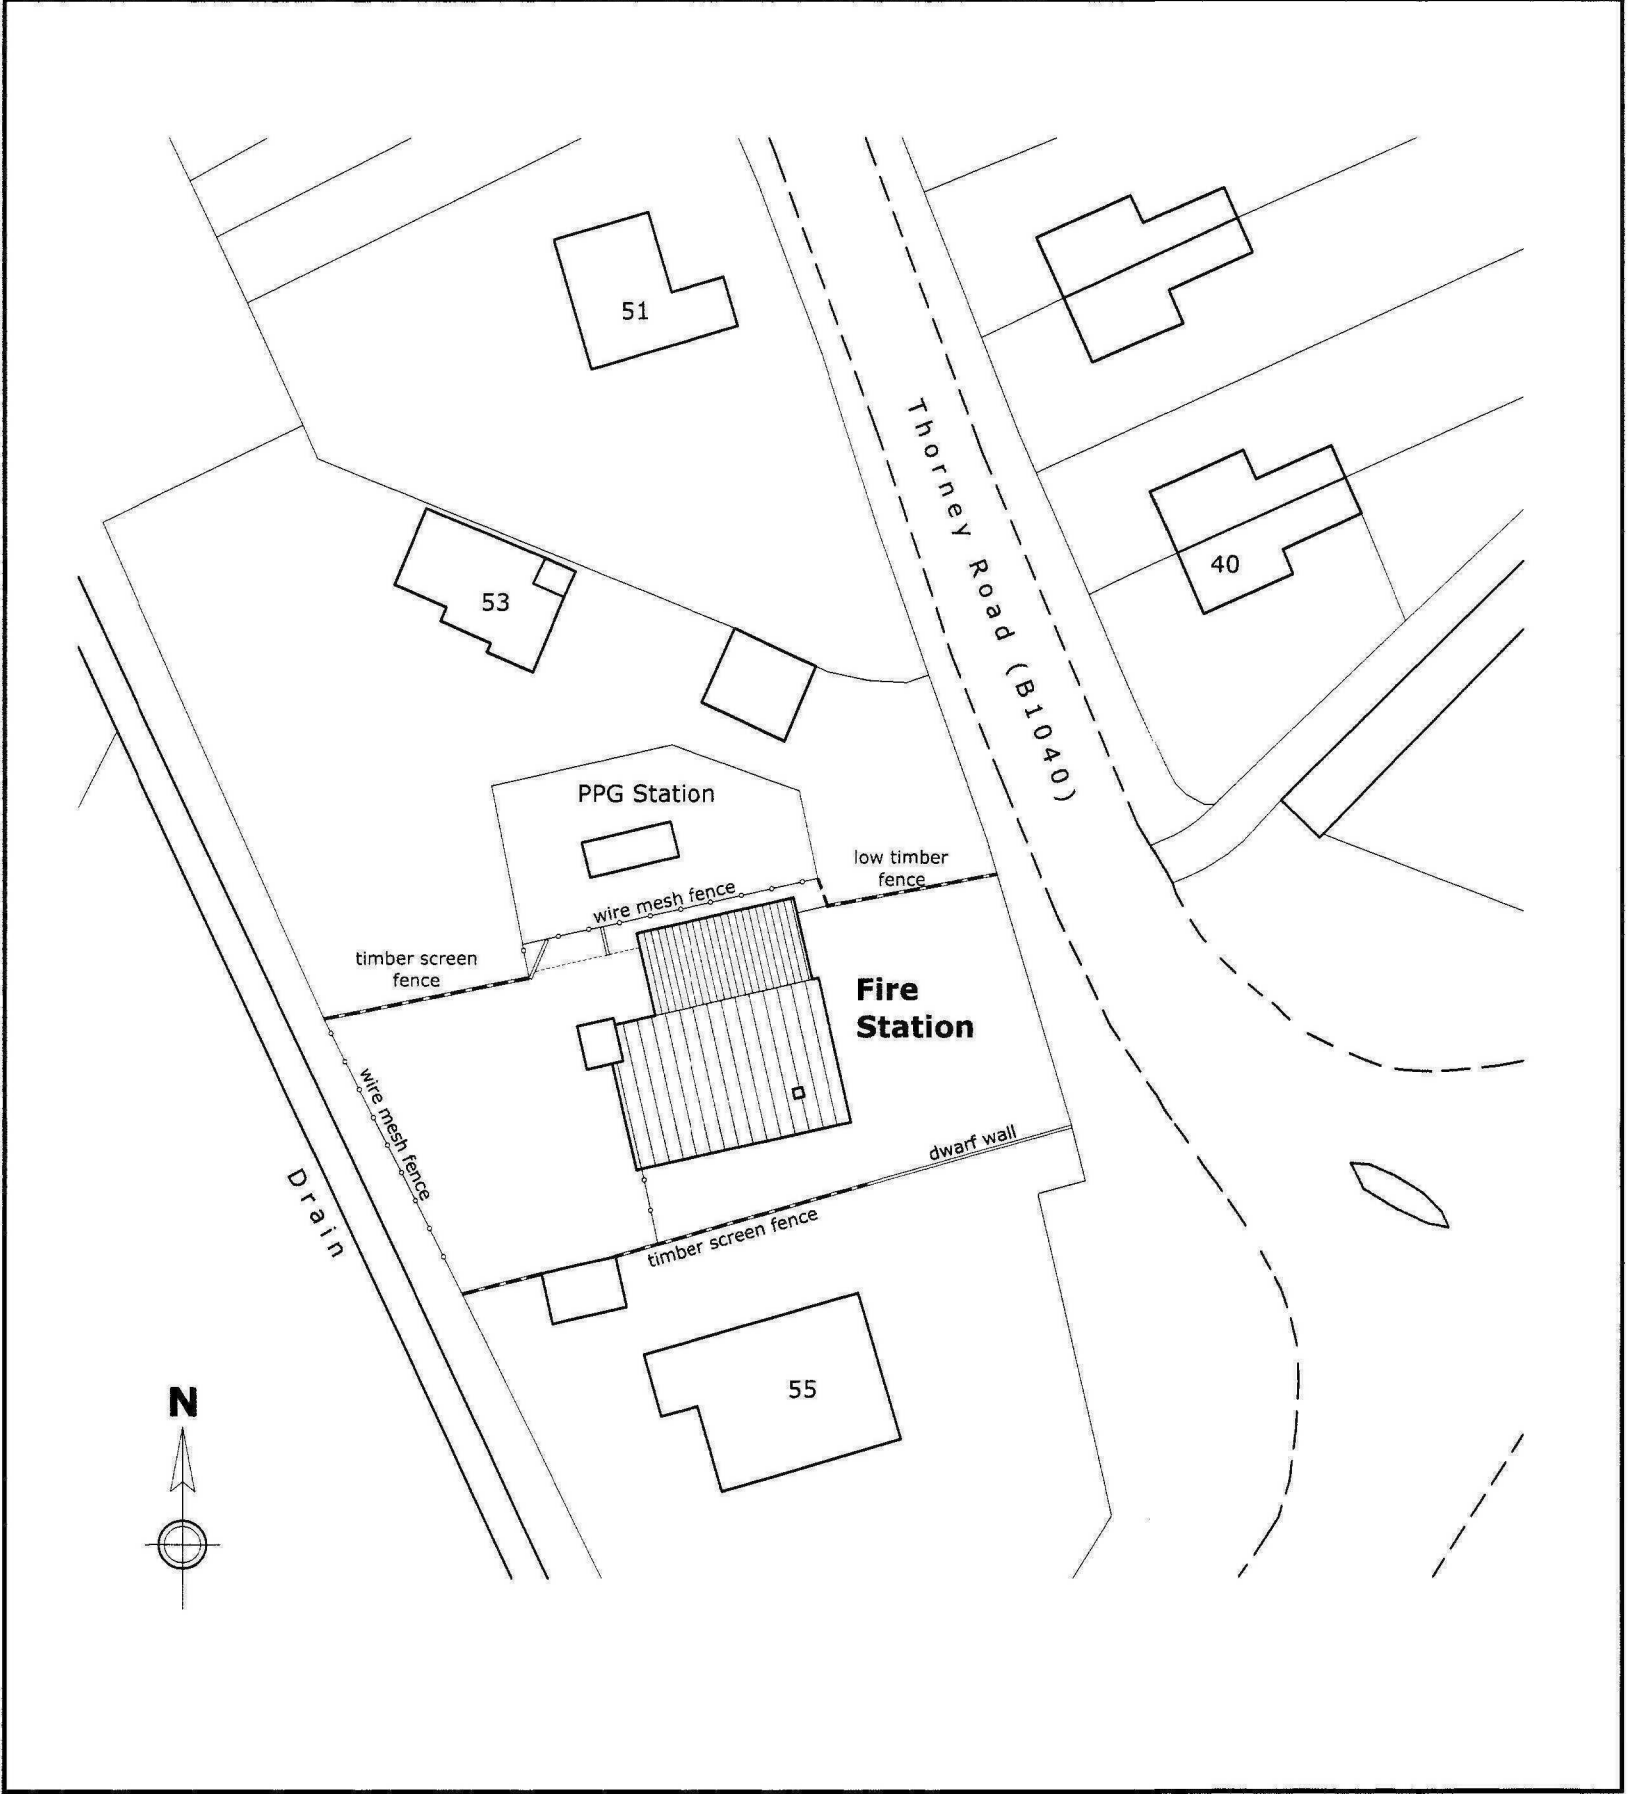

Existing Scale 1:500

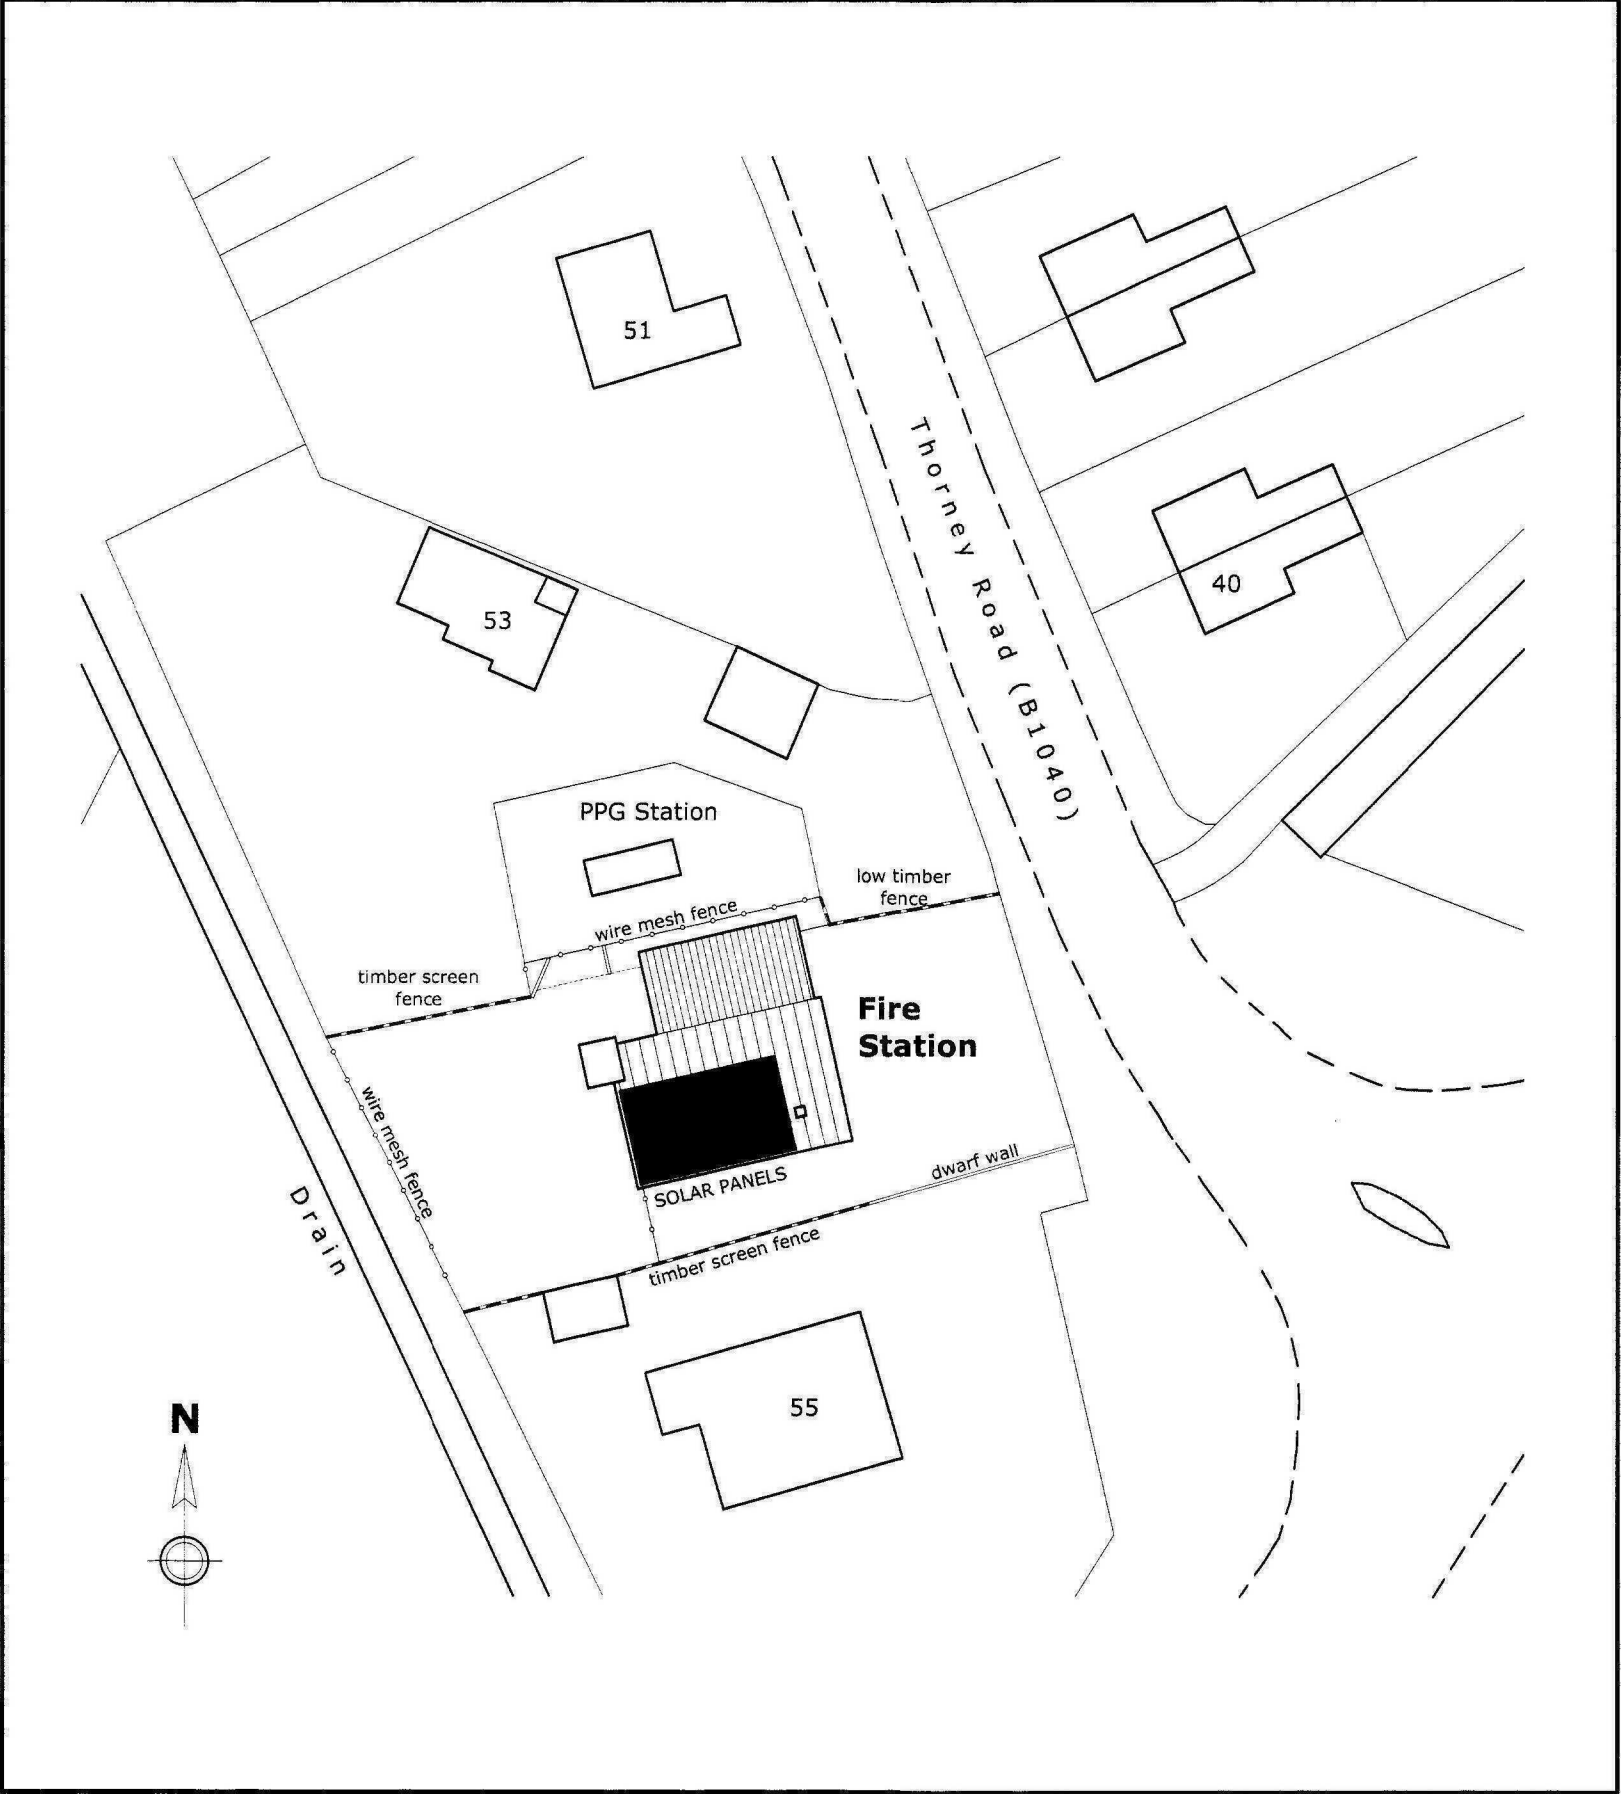

Proposed Scale 1:500


Scale 1:500
0m 5m 10m 15m 20m 25m 50m

NOTE: This drawing is created for the purpose of seeking planning and building regulations approval only and should not be used as working drawings in relation to construction. Do not scale from this drawing.

SHDC
Planning & Development
18 NOV 2010
Ref: 0957-10

TITLE: BLOCK PLANS
Dwg No: L-FRE-004Z-10-03 Revision: 1st
Scale: 1:500 @ A2 Date: Oct 2010

Project: Proposed installation of PV Solar Panels
Location: Crowland Fire Station
Thorney Road, Crowland, PE6 0AL
Client: LCC Fire & Rescue

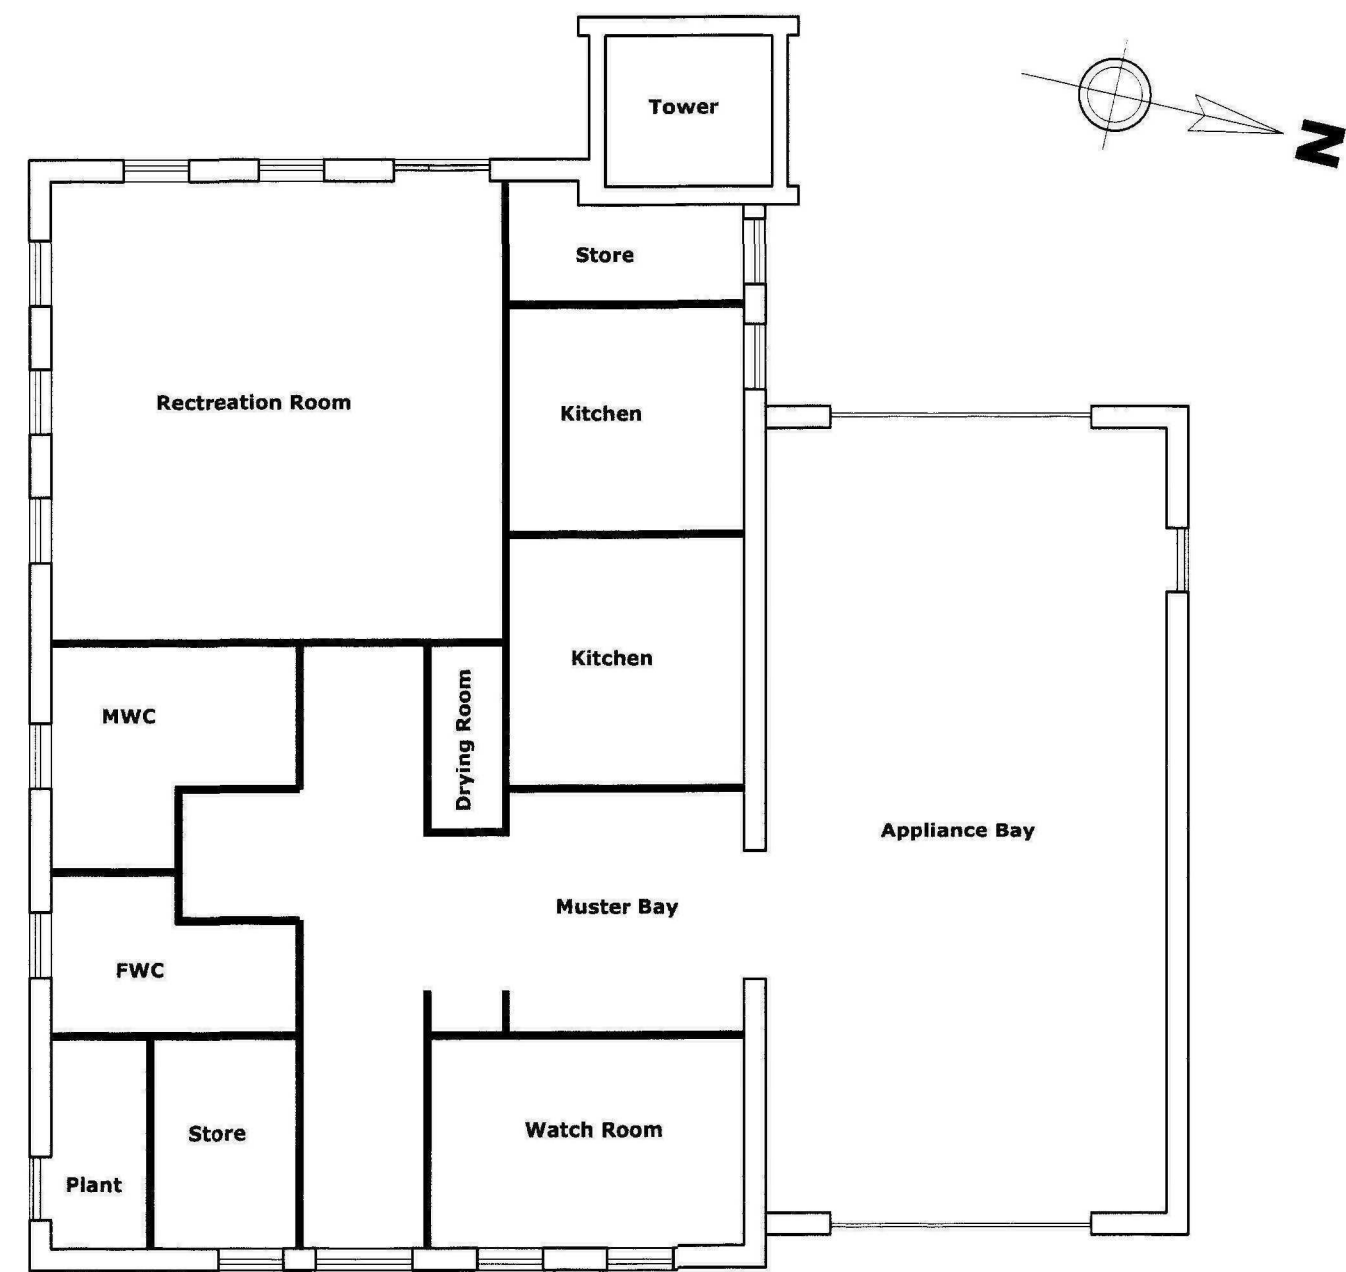

Scale 1:100
0m 2m 3m 4m 5m 10m

NOTE: This drawing is created for the purpose of seeking planning and building regulations approval only and should not be used as working drawings in relation to construction. Do not scale from this drawing.

SHDC
Planning & Development
18 NOV 2010
Ref: 0957-10


Title: Floor Plan - EXISTING
Draw No: L-FRE-004Z-10-02 Revision: 1st
Scale: 1:100 @ A2 Date: Nov 2010

Project: Proposed installation of PV Solar Panels


Location: Crowland Fire Station
Thorney Road, Crowland, PE6 0AL

Client: LCC Fire & Rescue


PV SOLAR PANELS

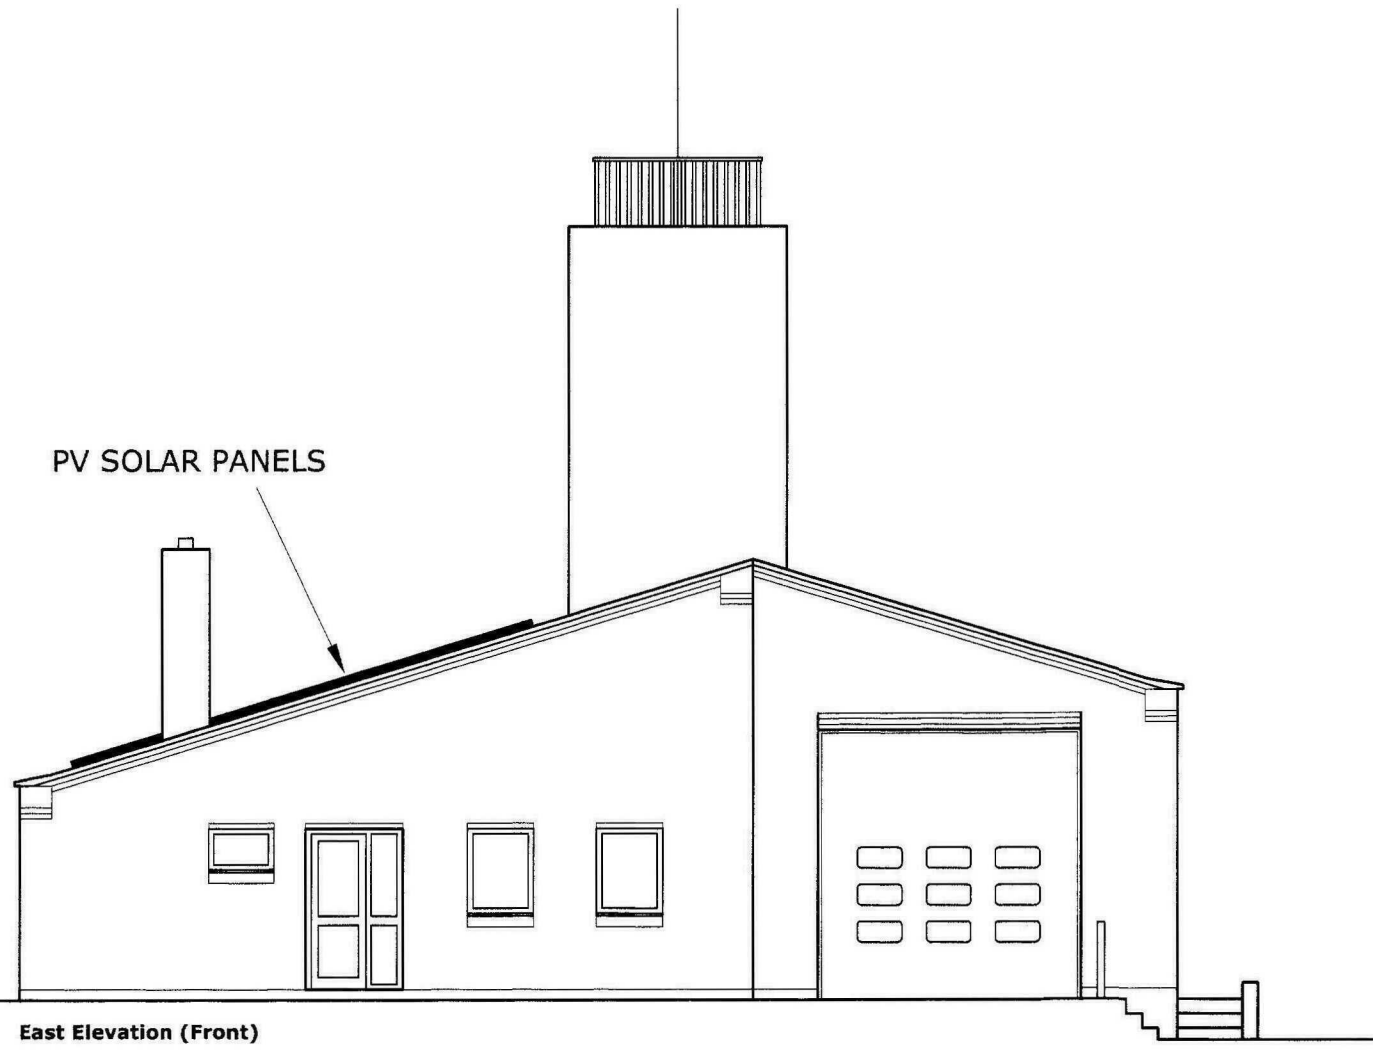


North Elevation (Side)

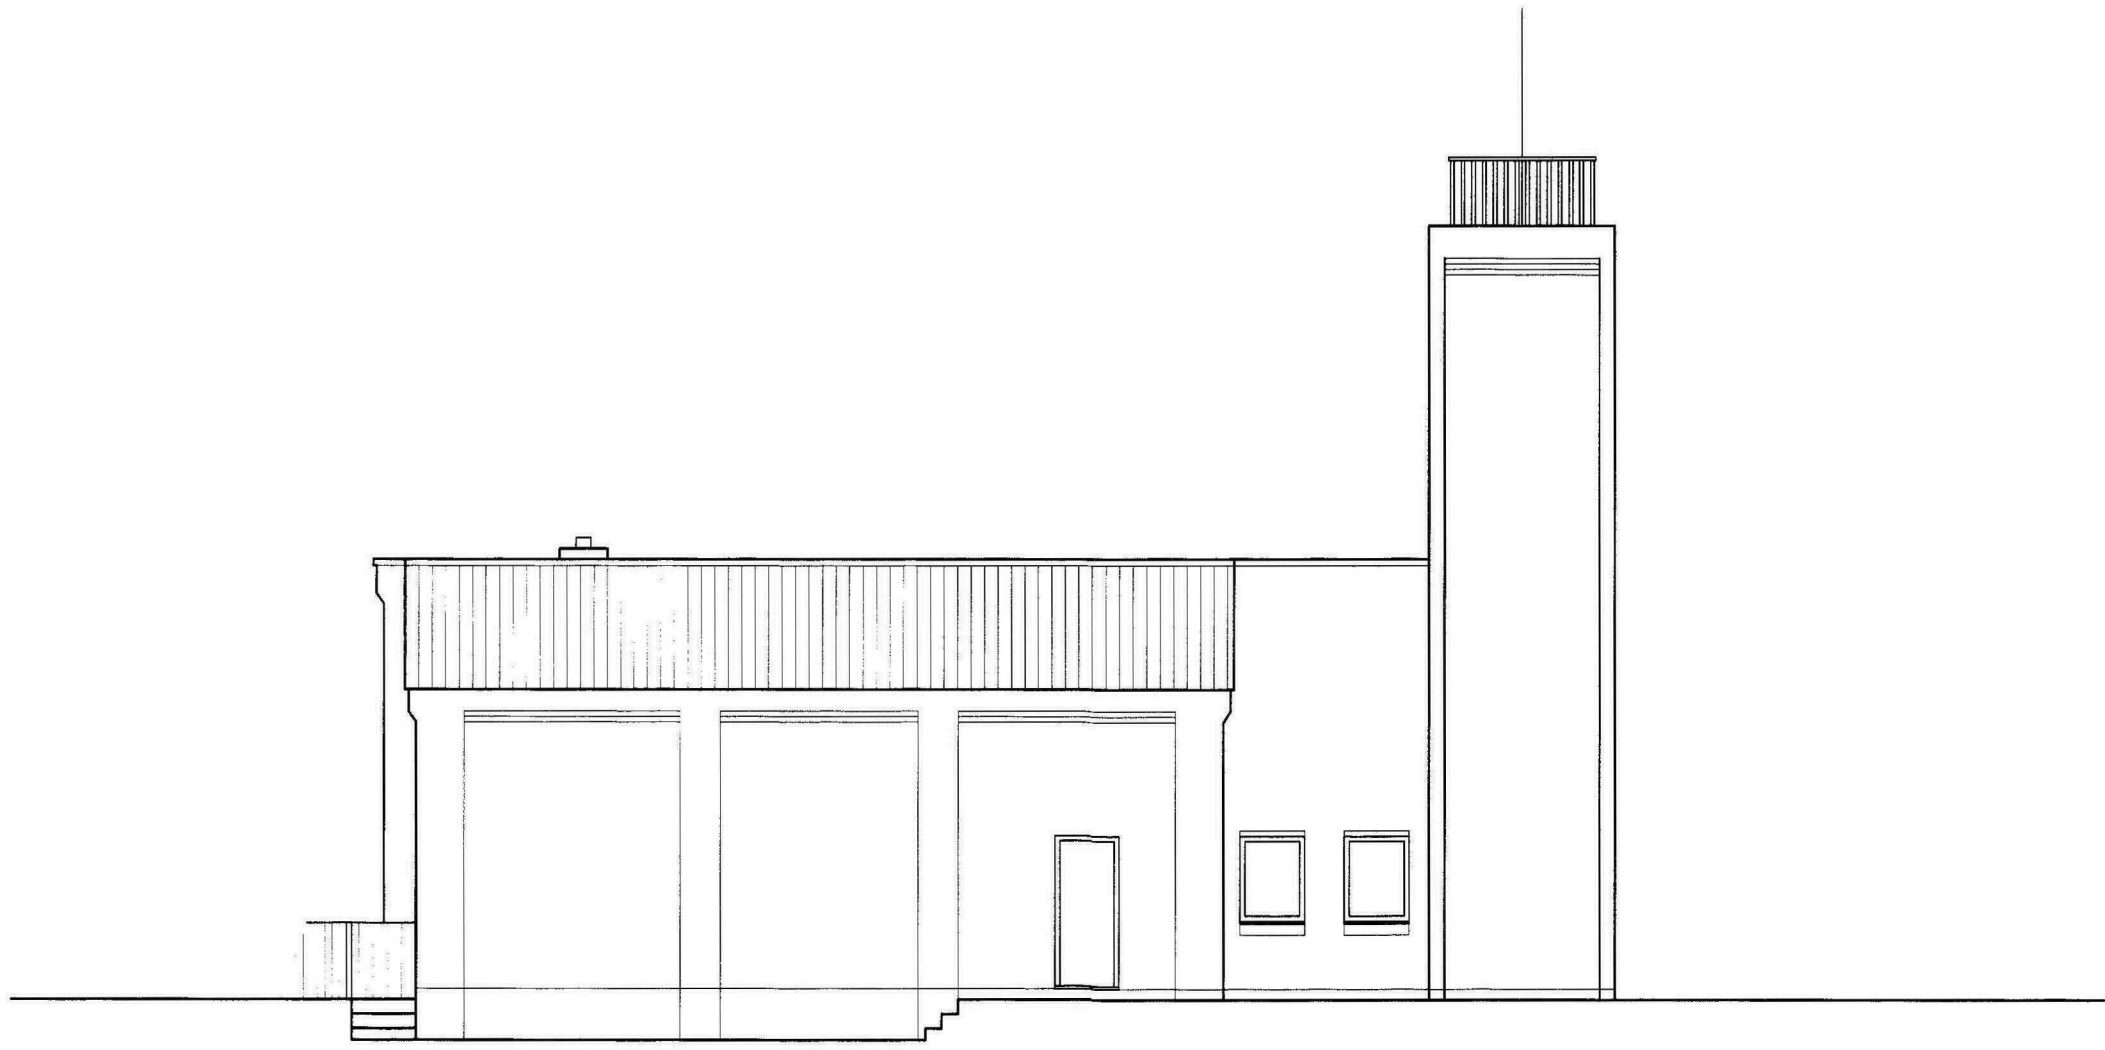


SPECIFICATION:
44no. 1m x 1.675m Conergy PowerPlus 225P

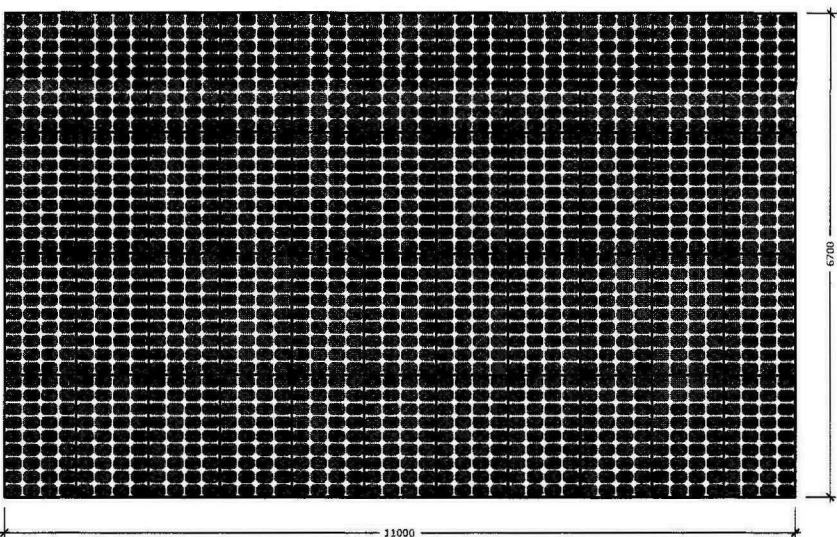

PV SOLAR PANELS

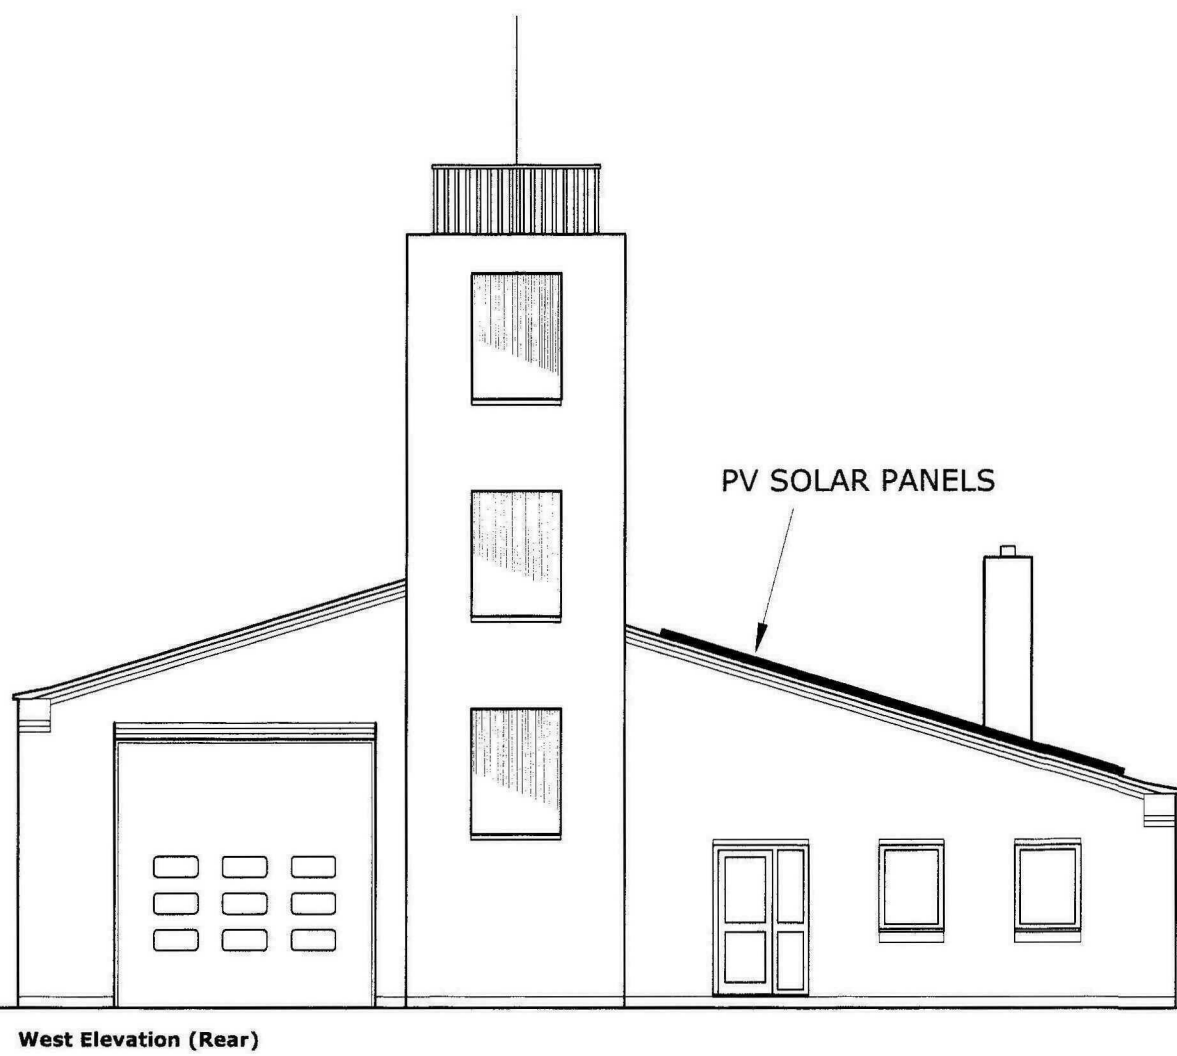

PV SOLAR PANELS

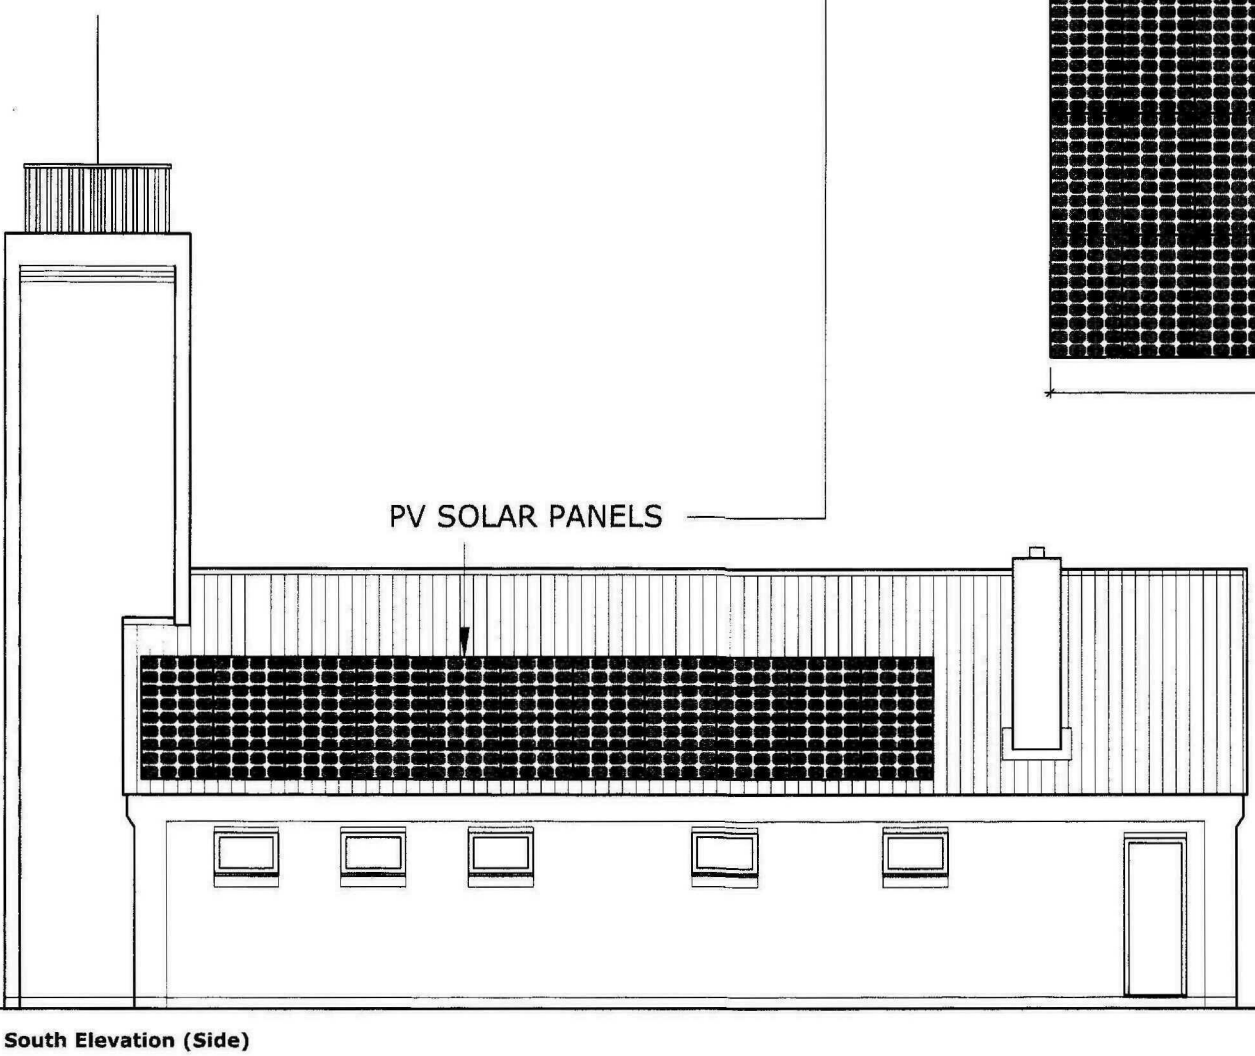

SHDC
Planning & Development
18 NOV 2010
Ref: 0957-10

Scale 1:100
0m 1m 2m 3m 4m 5m 10m





NOTE: This drawing is created for the purpose of seeking planning and building regulations approval only and should not be used as working drawings in relation to construction. Do not scale from this drawing.

Drawn: Elevations - PROPOSED
L-FRE-004Z-10-04
1:100 @ A2
1st
Nov 2010

Project: Proposed installation of PV Solar Panels

Location: Crowland Fire Station
Thorney Road, Crowland, PE6 0AL

Client: LCC Fire & Rescue

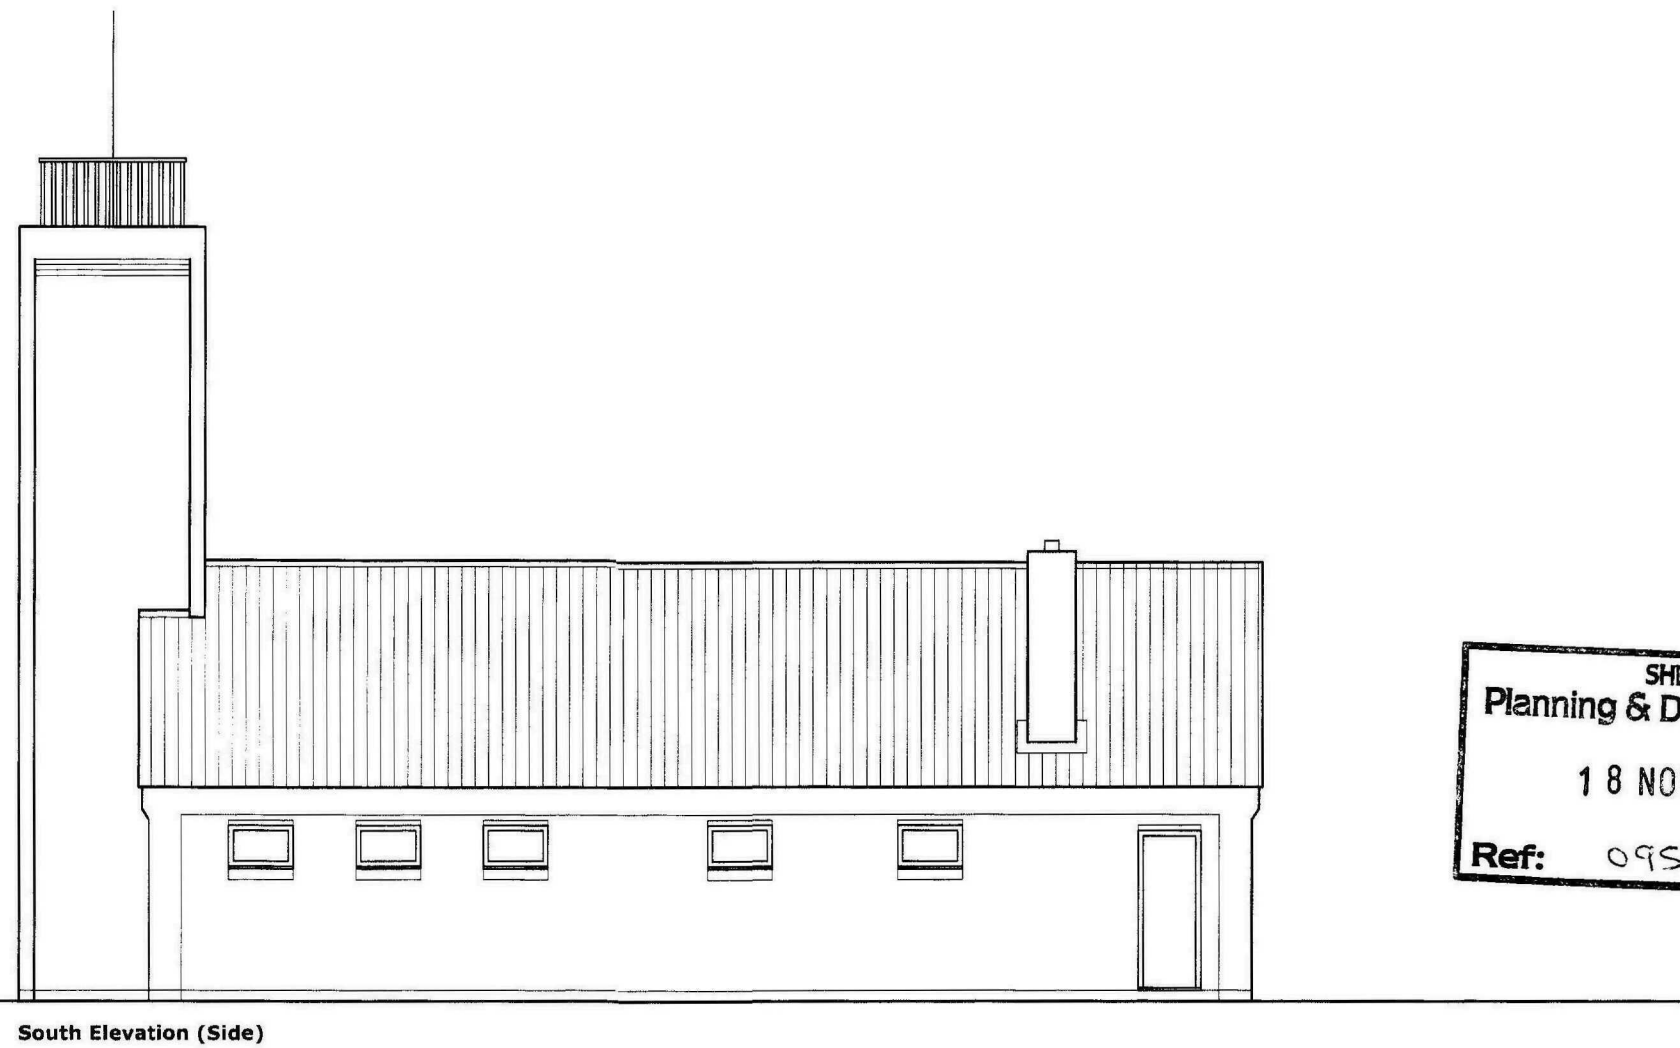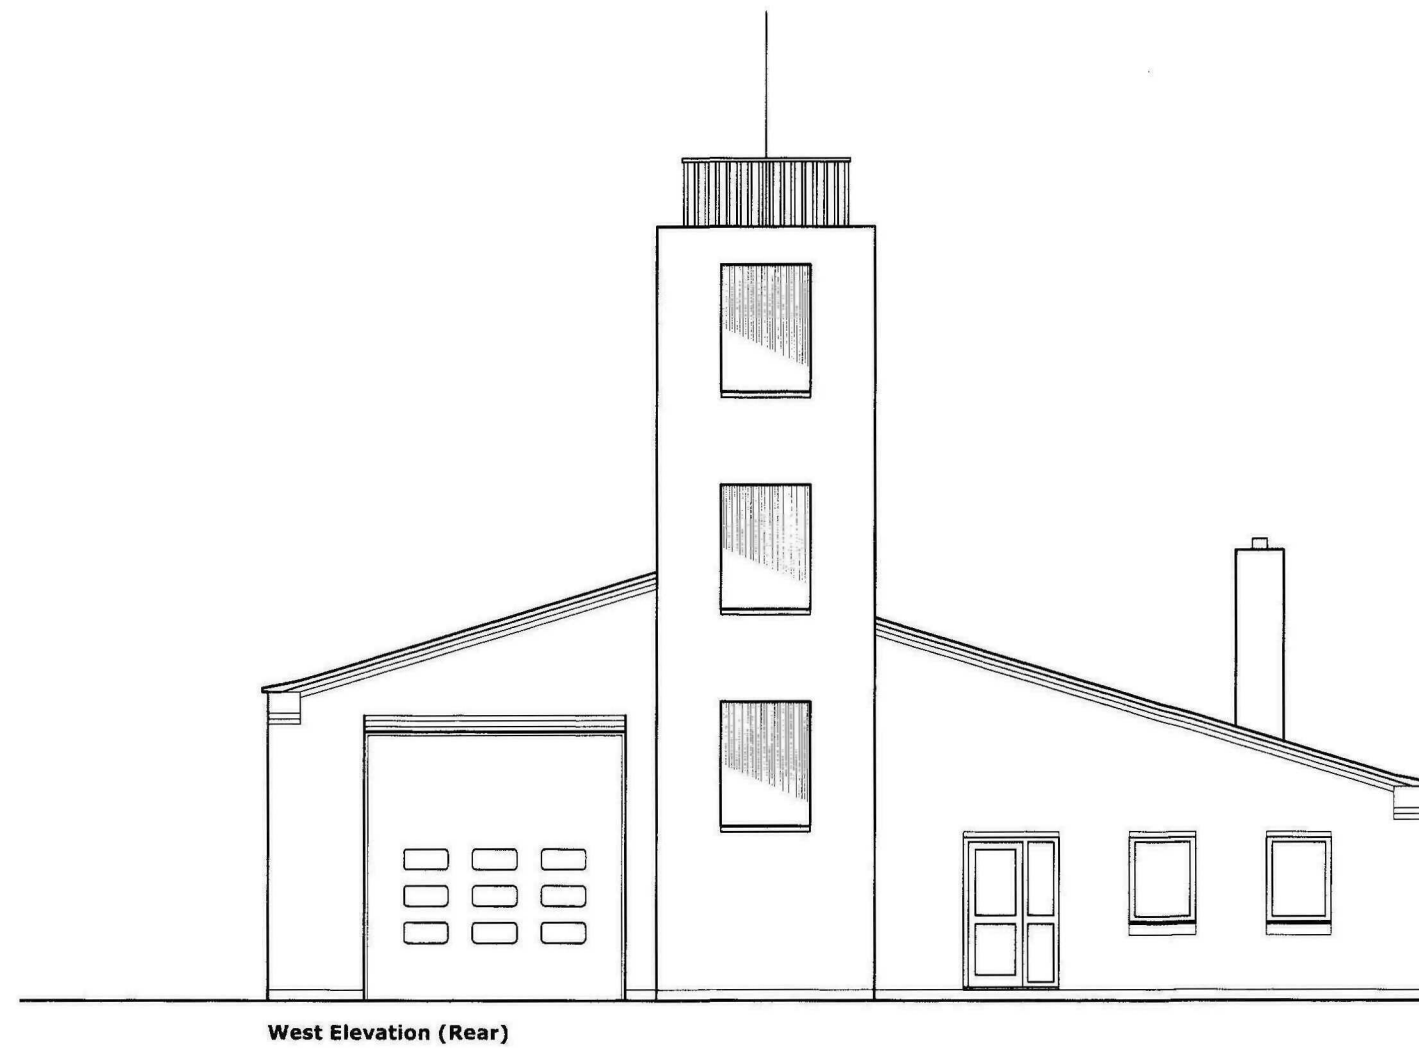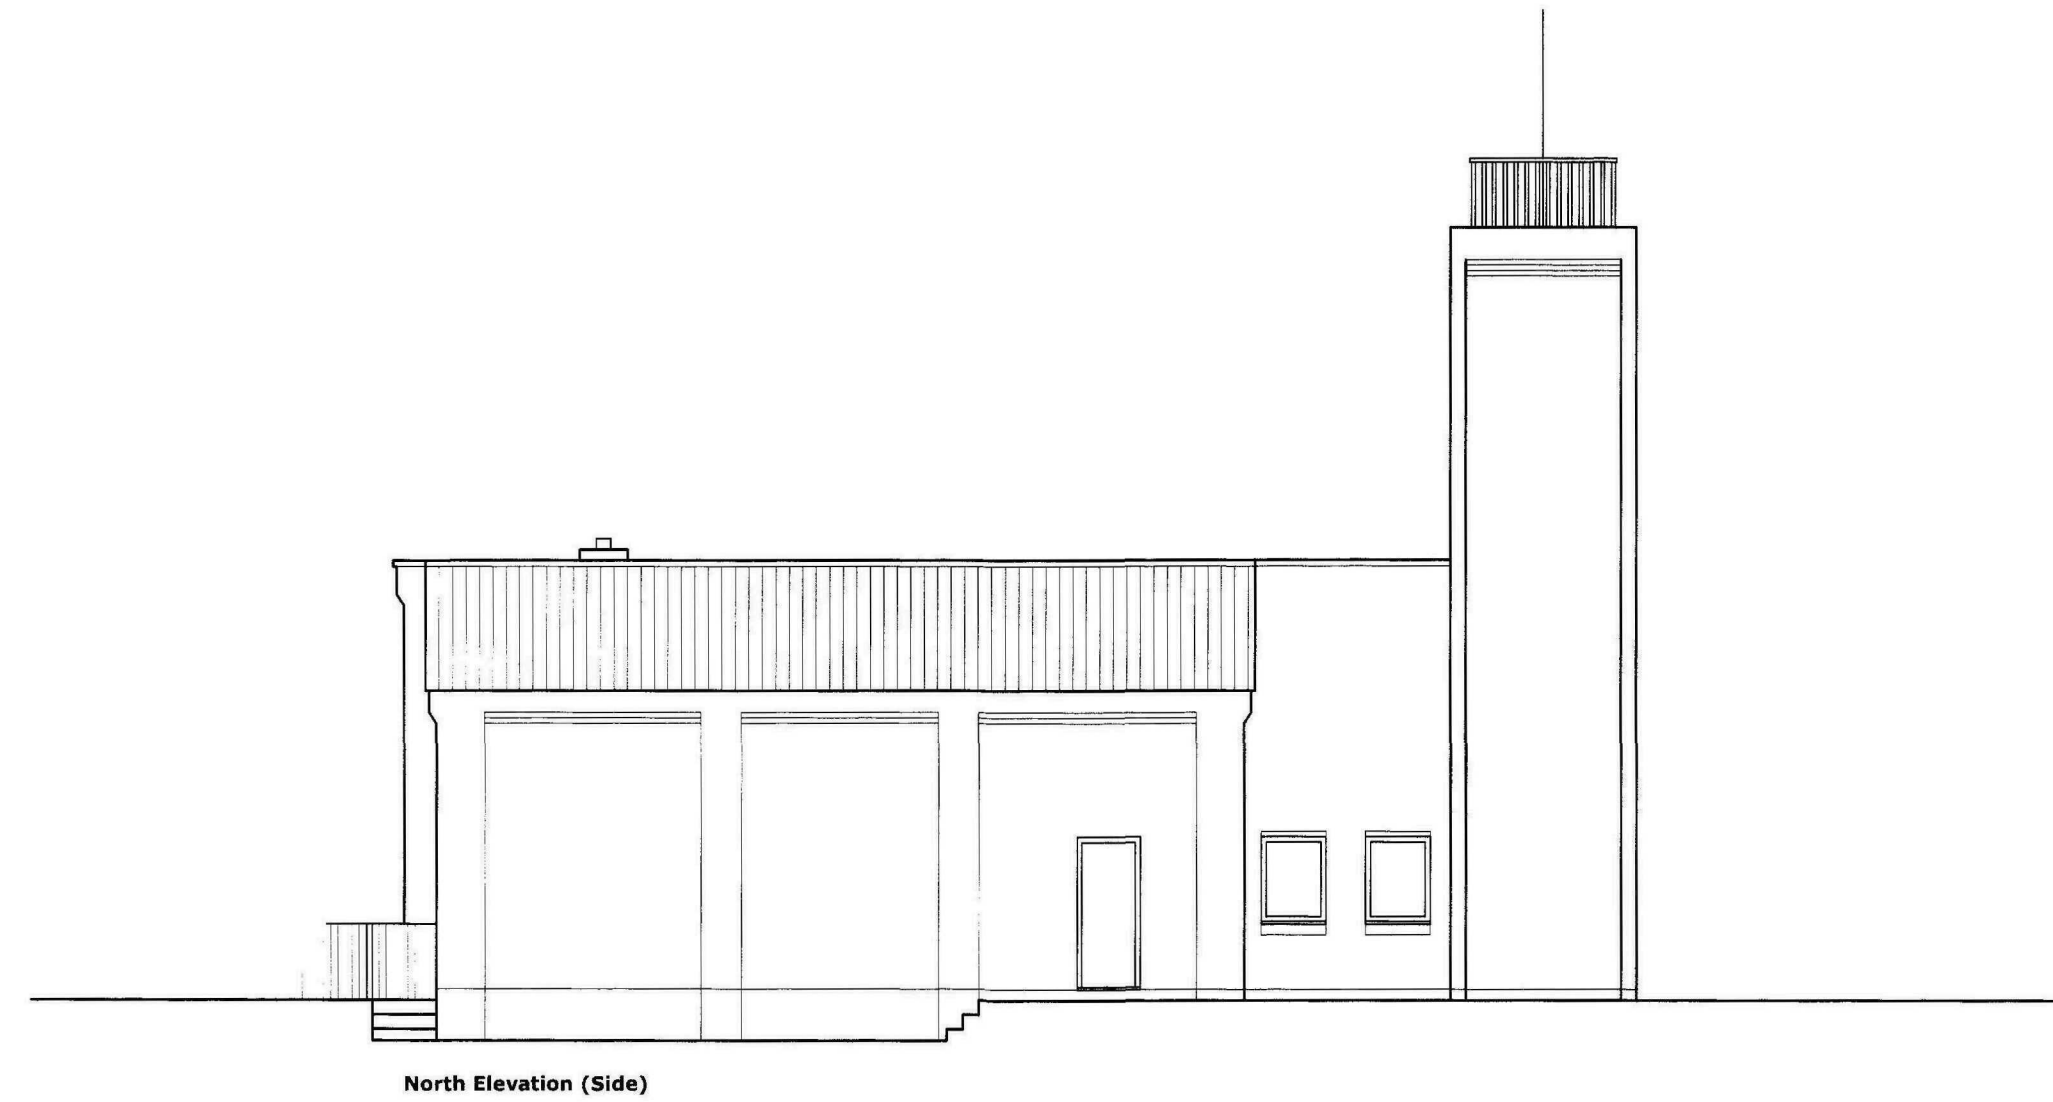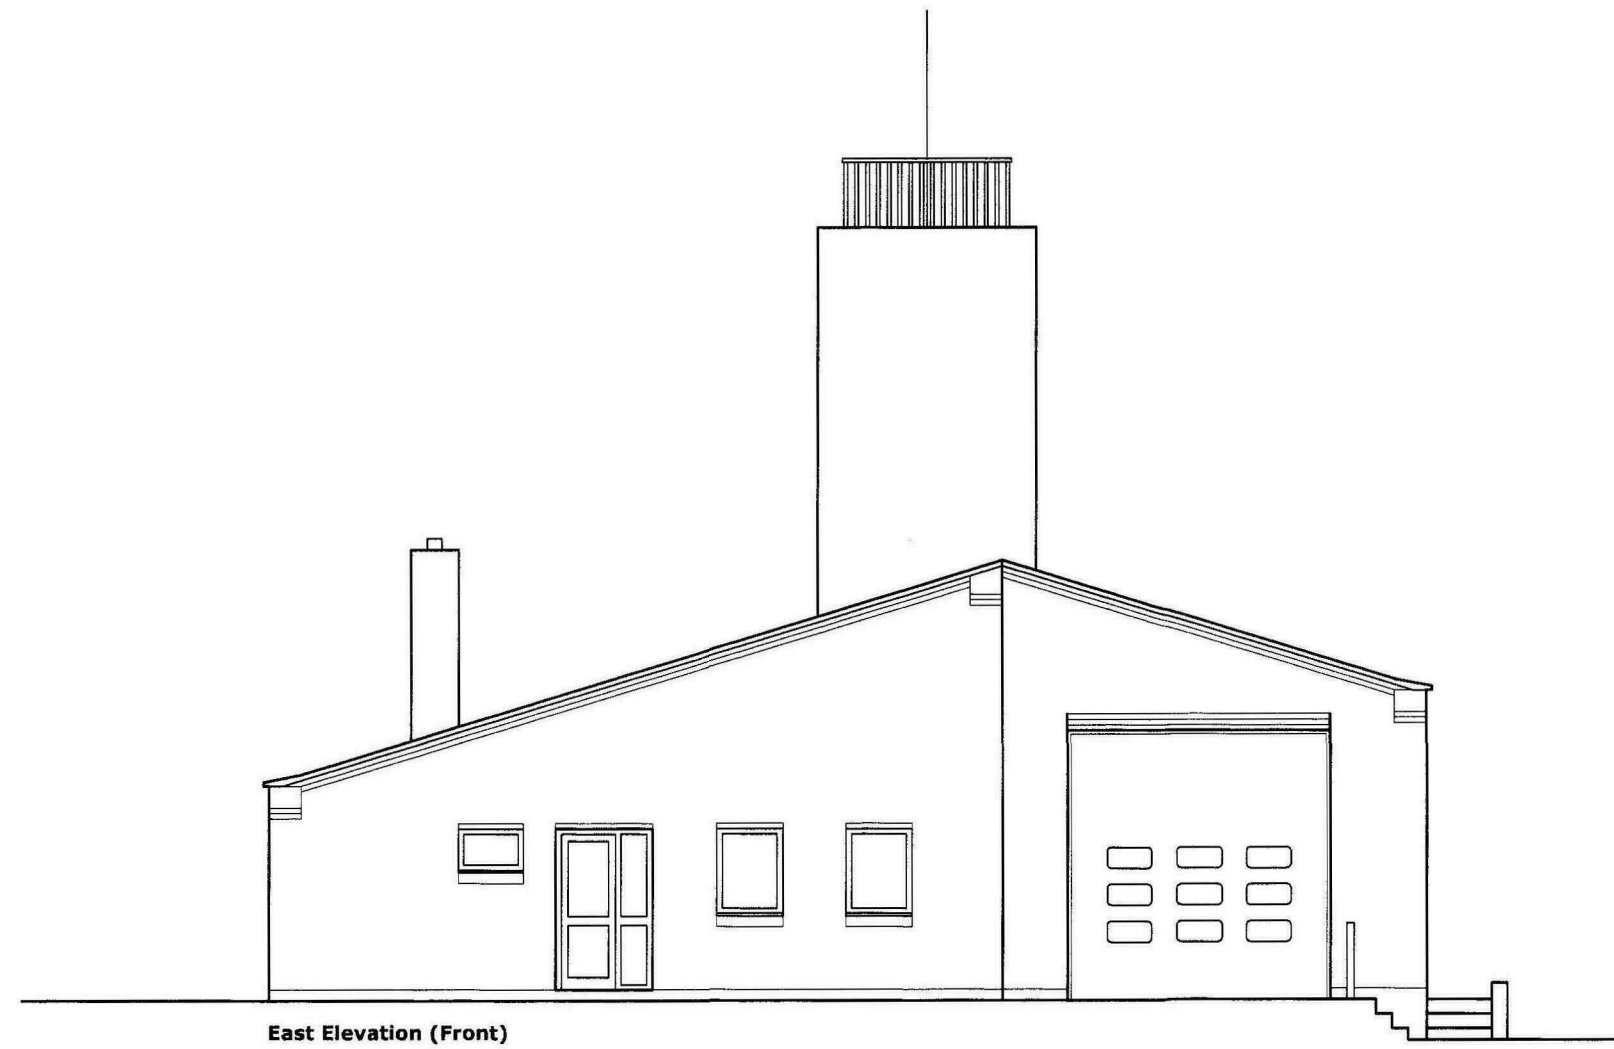

SHDC
Planning & Development
18 NOV 2010
Ref: 0957-10

Scale 1:100
0m 1m 2m 3m 4m 5m 10m

NOTE: This drawing is created for the purpose of seeking planning and building regulations approval only and should not be used as working drawings in relation to construction. Do not scale from this drawing.

Title: Elevations - EXISTING
Doc No: L-FRE-004Z-10-01 Revision: 1st
Scale: 1:100 @ A2 Date: Nov 2010
Project: Proposed installation of PV Solar Panels
Location: Crowland Fire Station
Thorney Road, Crowland, PE6 0AL
Client: LCC Fire & Rescue