


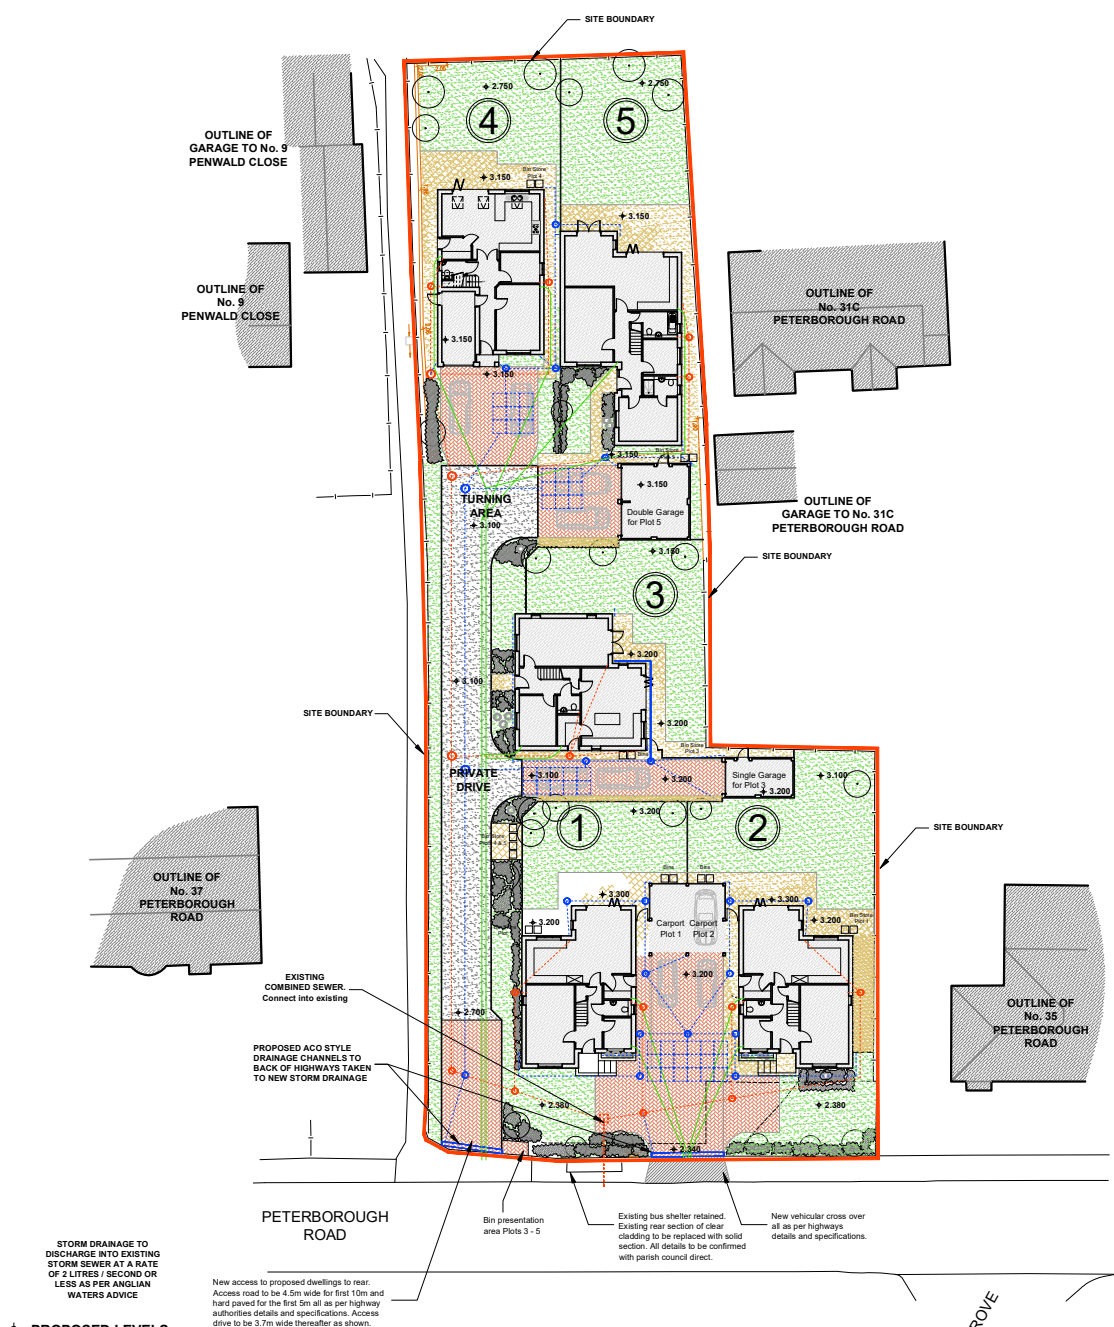

STORM DRAINAGE TO DISCHARGE INTO EXISTING STORM SEWER AT A RATE OF 2 LITRES / SECOND OR LESS AS PER ANGLIAN WATERS ADVICE

PROPOSED LEVELS

Refer to topographical survey for existing levels

SITE PLAN
1:200

- KEY**
- STORM ATTENUATION STORAGE (50m3 in total)
 - STORM DRAIN RUN / INSPECTION CHAMBER
 - FOUL DRAIN RUN / INSPECTION CHAMBER
 - PROPOSED SERVICES Gas / Water / Elec / BT
 - CONTAMINATION VAPOR MEMBRANE LOCATION

PROPOSED FFL LEVELS

Dwelling 1 -	3.350
Dwelling 2 -	3.350
Dwelling 3 -	3.350
Dwelling 4 -	3.100
Dwelling 5 -	3.100

Refer to Topographical Survey for existing site levels.

REV B: Notes re storm water added following Anglian Waters comments. Bin presentation area added. 24/05/2021.

REV A: Drainage / levels amended following contractors / planning officers comments. 14/01/2021.

Drainage / Proposed Levels Plan
As Proposed


Archi-tec
Architectural Design

0772 565 8850 Telephone
www.Archi-tec.co.uk Website
Simon@Archi-tec.co.uk Email
8 Brabham Close, Silverstone, Northants, NN12 8UL Address

PROPOSED 5NO. NEW DWELLINGS ON LAND ADJACENT 35 PETERBOROUGH ROAD, CROWLAND, PETERBOROUGH, PE6 0BB.

Client
Date June 2018
Scale As Noted @ A1
Drawing No C36 - 1005B

ALL DIMENSIONS TO BE CHECKED ON SITE. ANY DISCREPANCIES TO BE DISCUSSED AND AGREED PRIOR TO PROCEEDING. ALL WORKS TO BE CARRIED OUT IN ACCORDANCE WITH CURRENT BUILDING REGULATIONS AND RELEVANT CODES OF PRACTICE. THIS DRAWING IS THE PROPERTY OF ARCHI-TEC ARCHITECTURAL DESIGN AND MUST NOT BE COPIED OR REPRODUCED WITHOUT PRIOR WRITTEN CONSENT. STRUCTURAL INFORMATION (BROWN INDICATIVE ONLY) - REFER TO STRUCTURAL ENGINEERS DRAWINGS AND CALCULATIONS AS NECESSARY.

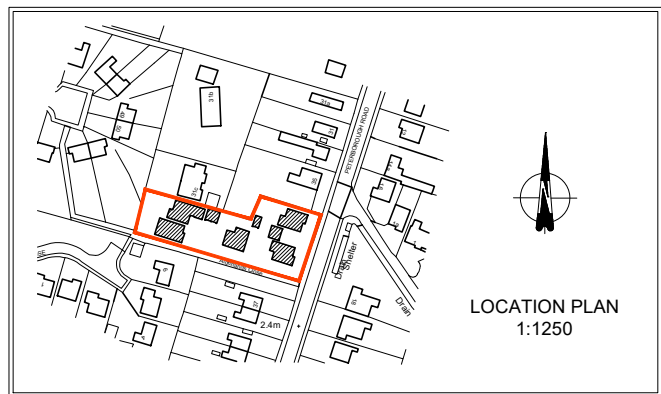

LOCATION PLAN
1:1250