


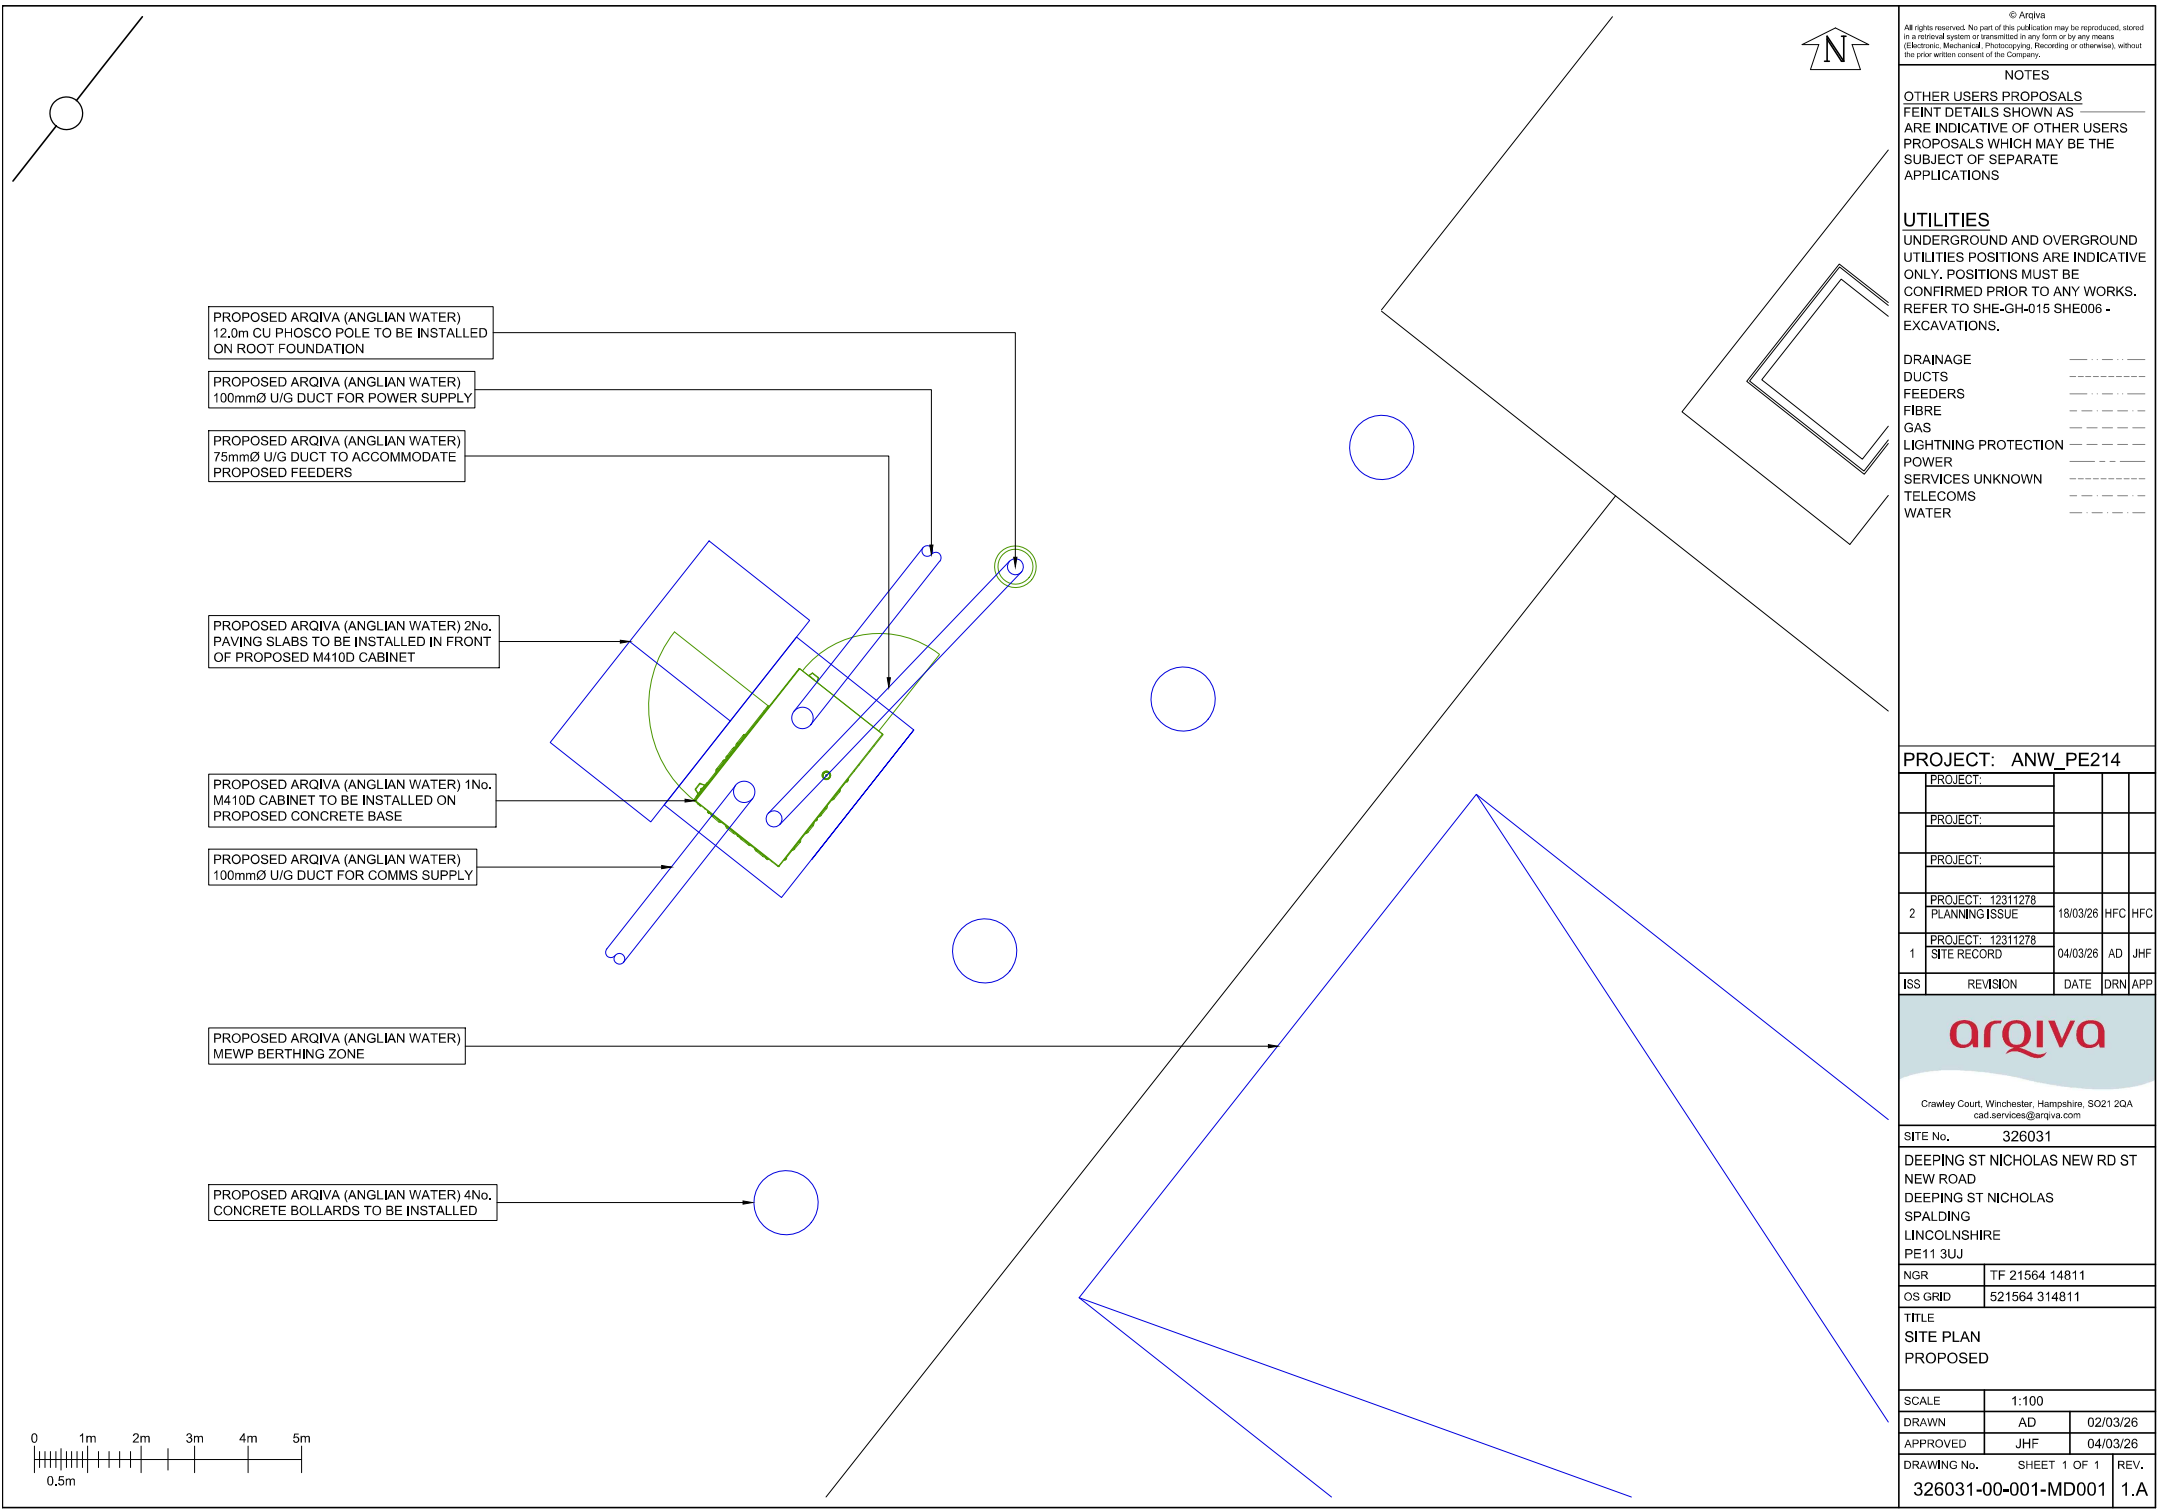

PROPOSED ARQIVA (ANGLIAN WATER)
12,0m CU PHOSCO POLE TO BE INSTALLED
ON ROOT FOUNDATION

PROPOSED ARQIVA (ANGLIAN WATER)
100mmØ U/G DUCT FOR POWER SUPPLY

PROPOSED ARQIVA (ANGLIAN WATER)
75mmØ U/G DUCT TO ACCOMMODATE
PROPOSED FEEDERS

 
PROPOSED ARQIVA (ANGLIAN WATER) 2No.
PAVING SLABS TO BE INSTALLED IN FRONT
OF PROPOSED M410D CABINET

PROPOSED ARQIVA (ANGLIAN WATER) 1No.
M410D CABINET TO BE INSTALLED ON
PROPOSED CONCRETE BASE

PROPOSED ARQIVA (ANGLIAN WATER)
100mmØ U/G DUCT FOR COMMS SUPPLY

PROPOSED ARQIVA (ANGLIAN WATER)
MEWP BERTHING ZONE

PROPOSED ARQIVA (ANGLIAN WATER) 4No.
CONCRETE BOLLARDS TO BE INSTALLED



© Arqiva
All rights reserved. No part of this publication may be reproduced, stored
in a retrieval system or transmitted in any form or by any means
(Electronic, Mechanical, Photocopying, Recording or otherwise), without
the prior written consent of the Company.

NOTES
OTHER USERS PROPOSALS
FEINT DETAILS SHOWN AS _____
ARE INDICATIVE OF OTHER USERS
PROPOSALS WHICH MAY BE THE
SUBJECT OF SEPARATE
APPLICATIONS

UTILITIES
UNDERGROUND AND OVERGROUND
UTILITIES POSITIONS ARE INDICATIVE
ONLY. POSITIONS MUST BE
CONFIRMED PRIOR TO ANY WORKS.
REFER TO SHE-GH-015 SHE006 -
EXCAVATIONS.

DRAINAGE
DUCTS
FEEDERS
FIBRE
GAS
LIGHTNING PROTECTION
POWER
SERVICES UNKNOWN
TELECOMS
WATER

PROJECT: ANW_PE214

PROJECT:			
PROJECT:			
PROJECT:			
PROJECT: 12311278			
2 PLANNING ISSUE	18/03/26	HFC	HFC
PROJECT: 12311278			
1 SITE RECORD	04/03/26	AD	JHF
ISS	REVISION	DATE	DRN APP

arqiva

Crawley Court, Winchester, Hampshire, SO21 2QA
cad.services@arqiva.com

SITE No. 326031
DEEPING ST NICHOLAS NEW RD ST
NEW ROAD
DEEPING ST NICHOLAS
SPALDING
LINCOLNSHIRE
PE11 3UJ

NGR TF 21564 14811
OS GRID 521564 314811

TITLE
SITE PLAN
PROPOSED

SCALE 1:100
DRAWN AD 02/03/26
APPROVED JHF 04/03/26

DRAWING No. 326031-00-001-MD001 SHEET 1 OF 1 REV. 1.A