
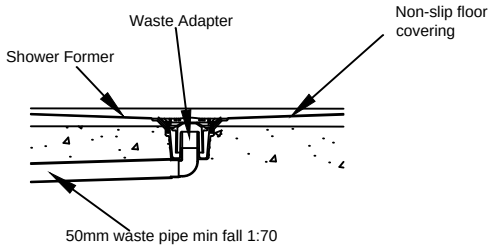


Do Not Scale From This Drawing

This drawing is copyright and may not be altered , traced, photographed or copied without prior written consent from South Holland Building Consultancy.

The contractor should check all dimensions on site prior to commencement and report any discrepancies to the Draftsperon.

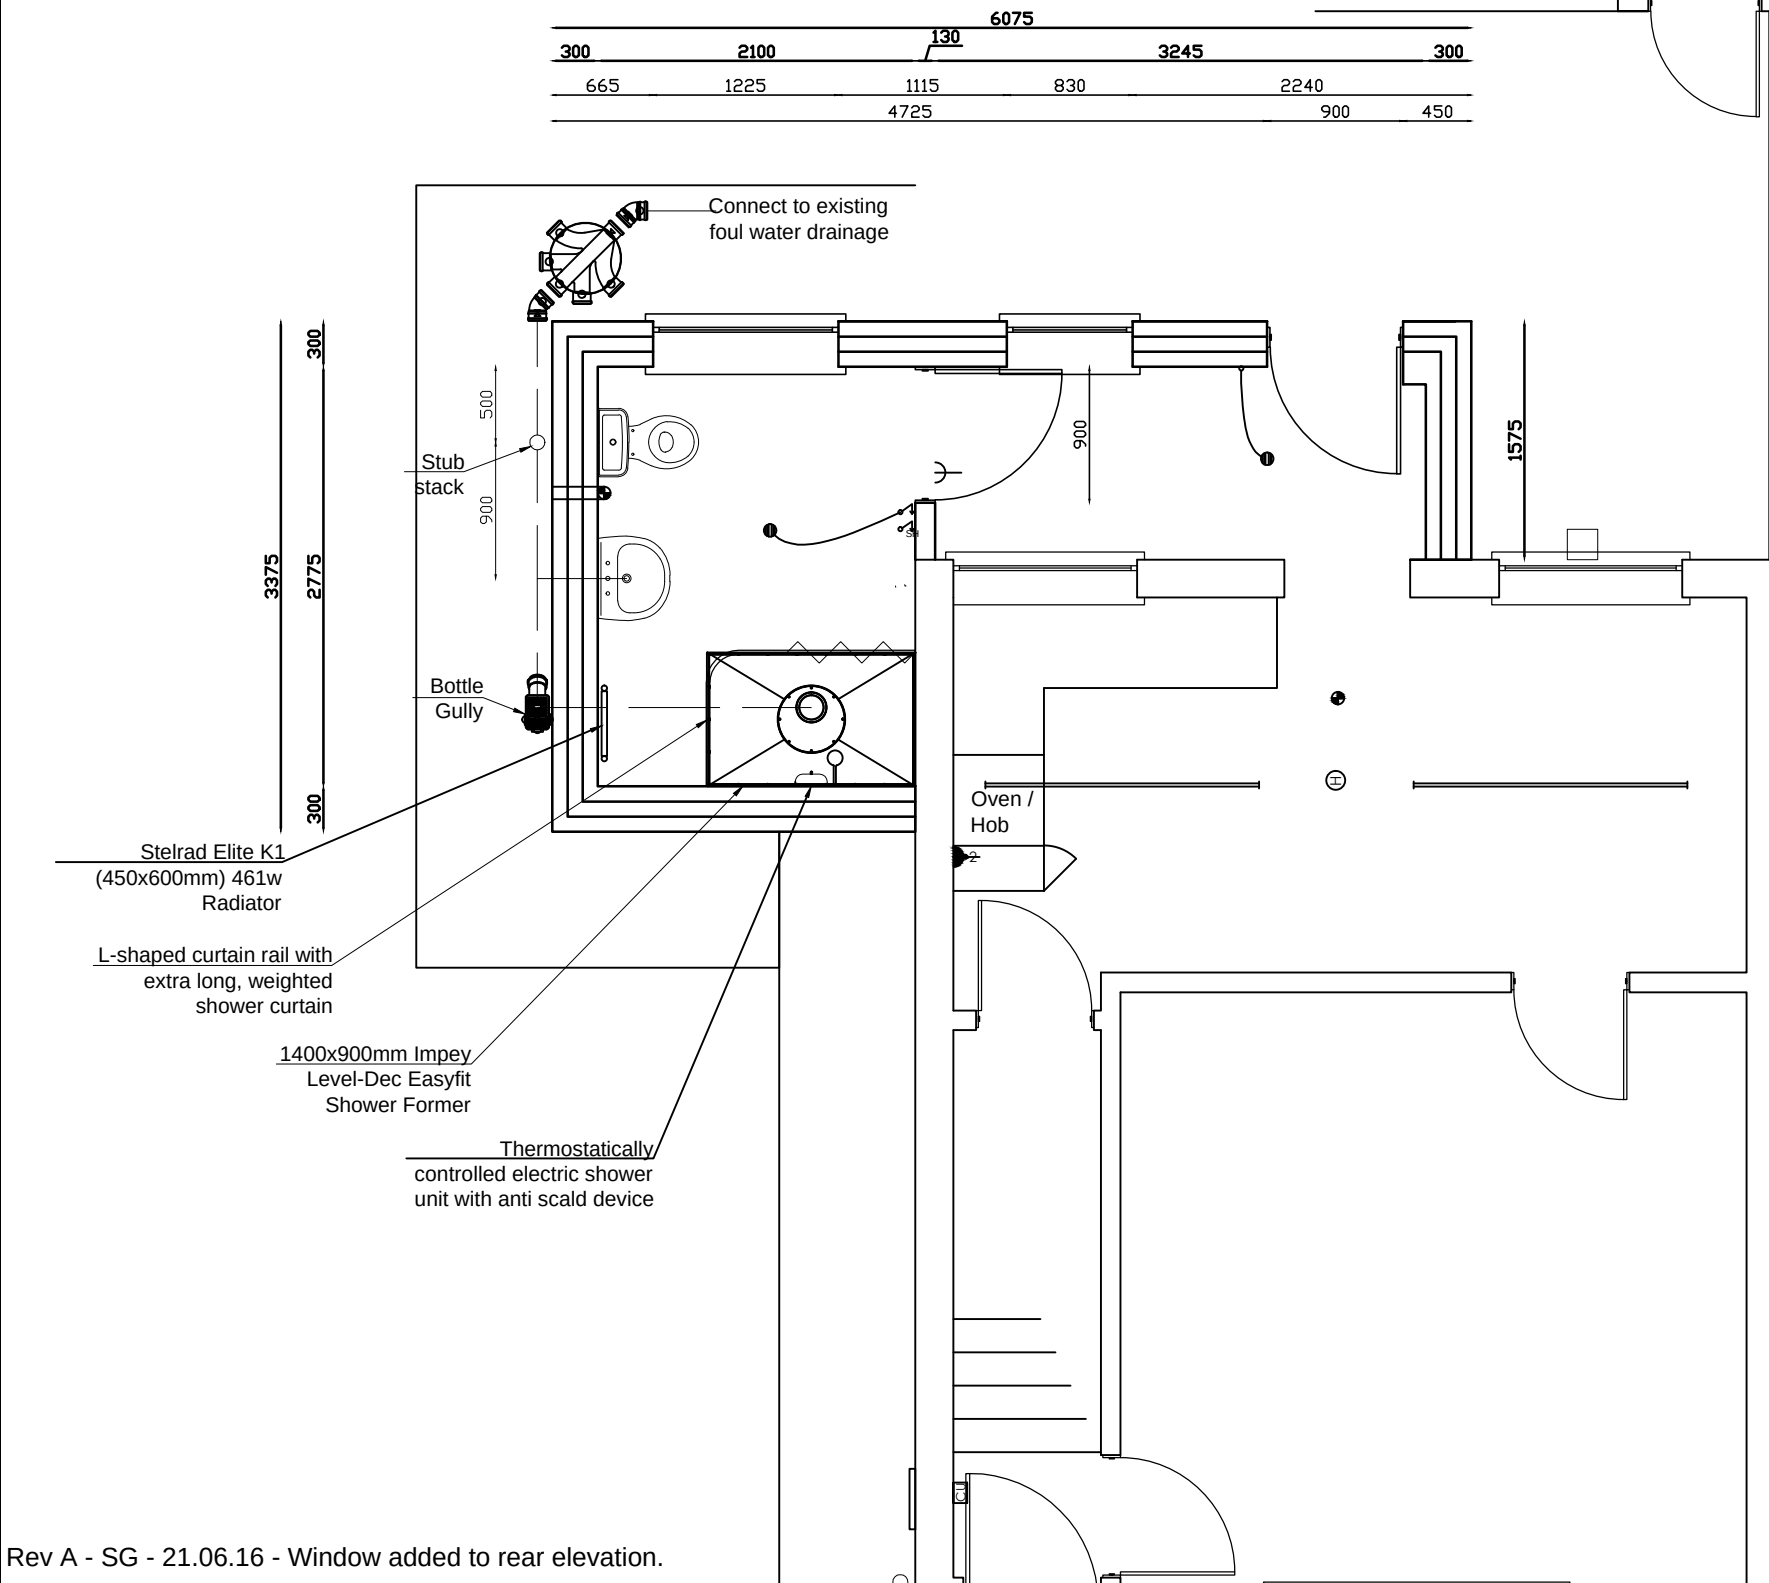

Scale 1:20

ELECTRICAL SYMBOLS KEY

- CONSUMER UNIT
- SINGLE SWITCHED FUSE SPUR AT HIGH LEVEL FOR EXTRACT FAN
- COMBINED HEAT DETECTOR AND FIRE ALARM SOUNDER
- MECHANICAL EXTRACT FAN

- DOUBLE SWITCHED WALL SOCKET 1200MM ABOVE FLOOR LEVEL
- INTERNAL LIGHT - BULKHEAD TYPE
- 1 GANG PULL CORD LIGHT SWITCH
- SHOWER ISOLATOR PULL CORD SWITCH
- 1 GANG LIGHT SWITCH



South Holland Building Consultancy
Council Offices
Priory Road
Spalding
Lincs
PE11 2XE
01775 764447

Project : Extension to Create Level Access Shower,
Address 13 Coronation Avenue, Deeping St Nicholas
Client : Mrs C Guest
Scale : 1 : 50
Date : 7th April 2016
Title: Proposed Ground Floor Plan
Dwg No : 714/Grant/02 A Drawn : SG