


Donington Fire Station

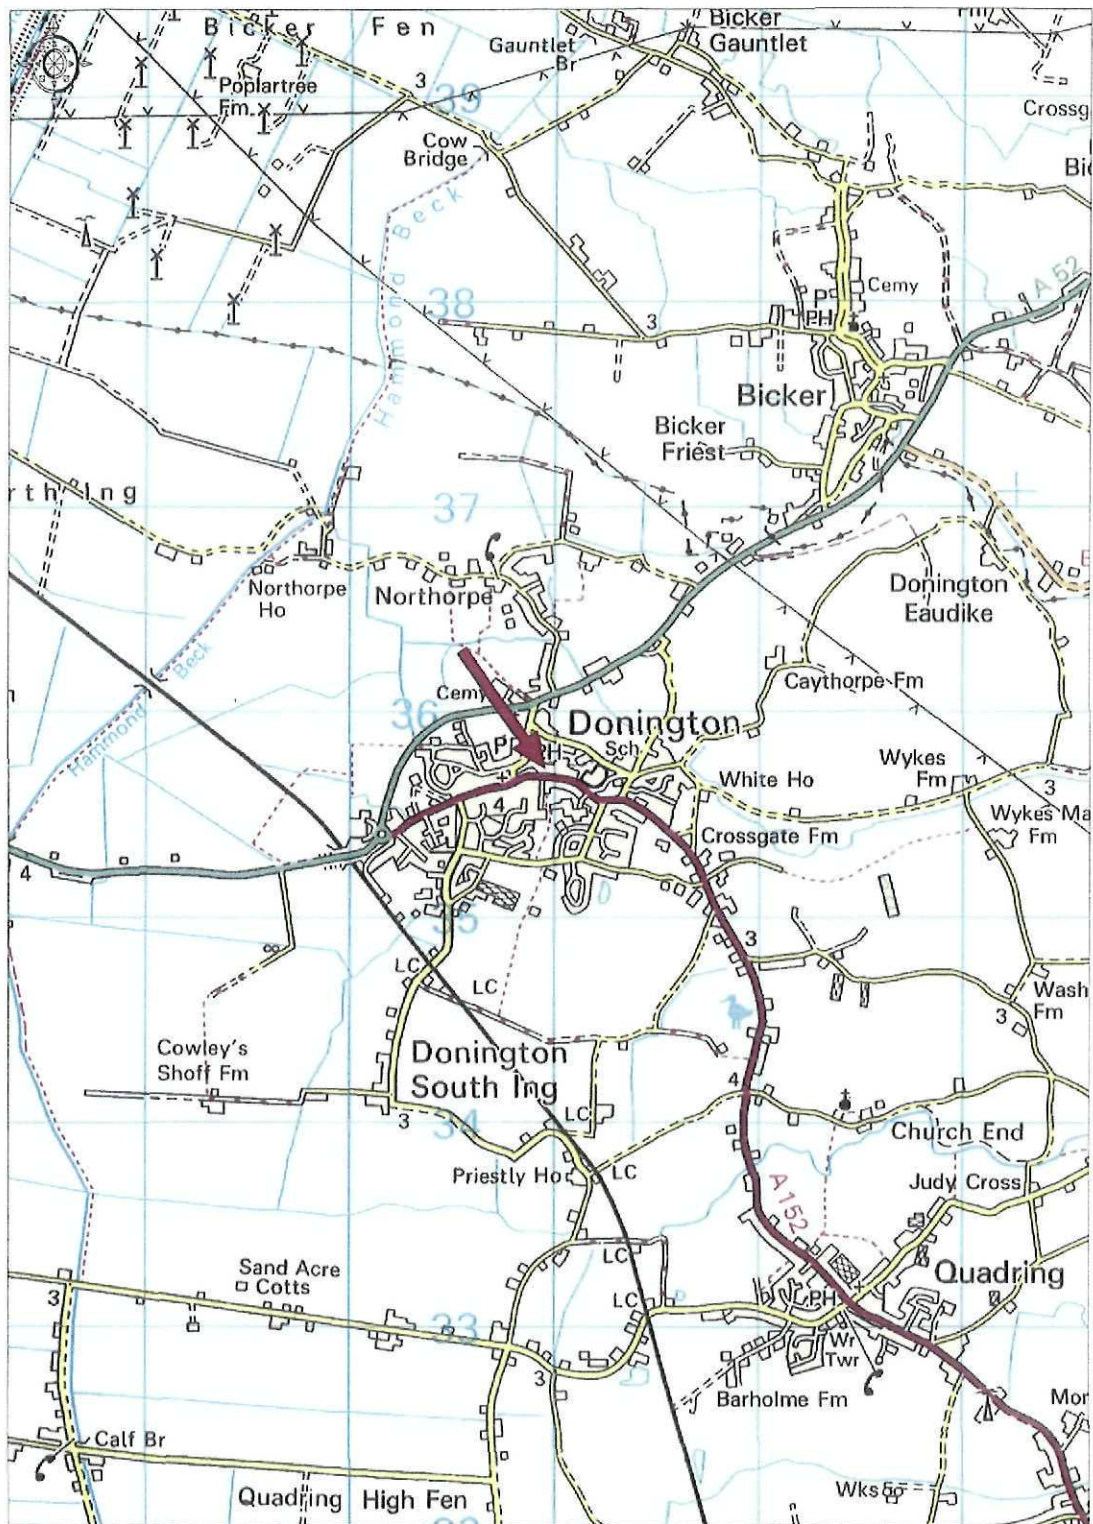

Promap

Ordnance Survey © Crown Copyright 2011. All rights reserved.
License number 100020442. Plotting Scale: 1:35000



Location Plan 1:35000 @ A4

SHDC
Planning & Development

18 FEB 2011

Ref: 0117-11

In collaboration with J H Walter, Lincoln

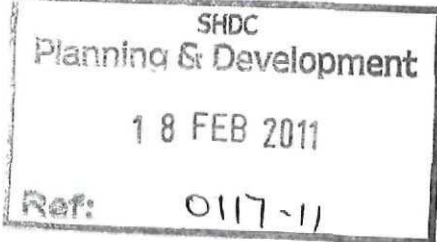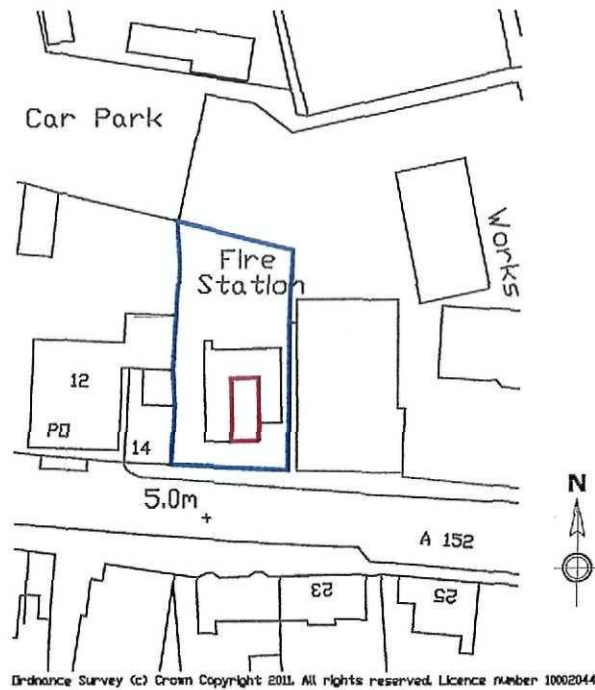

Scale 1:1250
0m 20m 50m 100m

Title: Site Plan

Dwg No: L-FRE-004Z-12-04

Revision: 1st

Scale: 1:1250 @ A4

Date: Feb 2011

Project: Proposed installation of PV Solar Panels

Location: Donington Fire Station
High Street, Donington, PE11 4TA

Client: LCC Fire & Rescue