


CELL NAME - FRUITEX

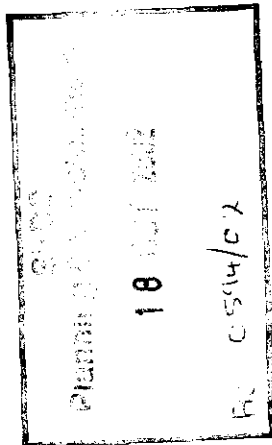


Airwaves antennae c/1 16.3m AGL

GPS antenna 15.7m AGL

Top of tower 15m AGL


Dish c/1 10.0m AGL

Height of building approx 8.0m AGL

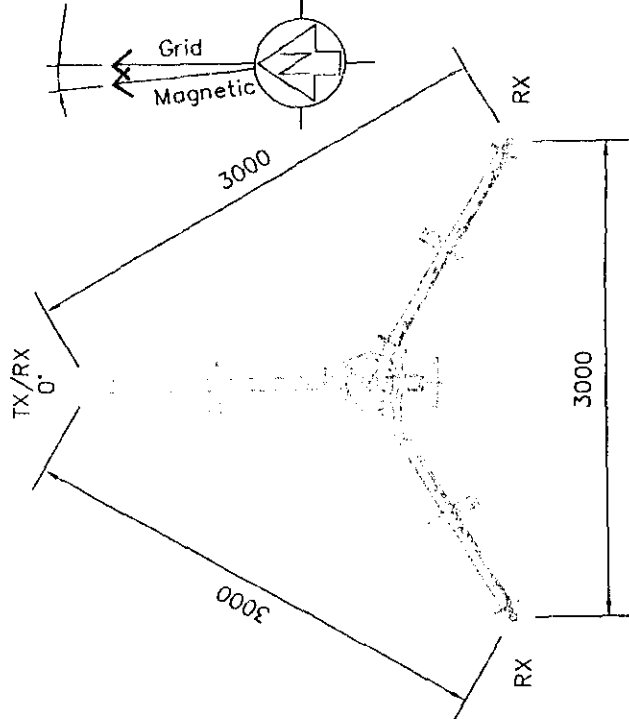

PLAN ON TOWER AT 15M
ANTENNA CONFIGURATION 11

(SCALE 1:50)

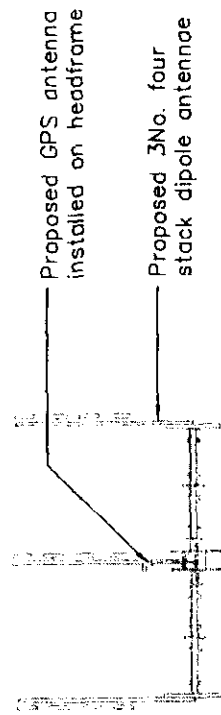

Proposed GPS antenna installed on headframe

Proposed 3No. four stack dipole antennae

Proposed equipment cabin. For cabin generics refer to GEN 214 - 217. For base generics refer to GEN/427

Proposed 600mmØ microwave dish

Proposed 2.1m high palisade fencing. For generic refer to GEN/419

Existing redundant HGV trailer


Mound

Lorry flatbed to be removed by site provider prior to construction

Proposed meter cabinet within fence line. For generic refer to GEN 420 & 419

PROPOSED SOUTH EAST ELEVATION

 (SCALE 1:100)



ALL DIMENSIONS IN MILLIMETRES

ORIGINAL SCALE AT A3 - 1:100

NOTE: ORIGINAL DRAWING SIZE A3

NOTES

- Do Not Scale
- This drawing to be read in conjunction with Galliford drawing No.s LIND08/11,12,14,15,16 and Standard B.T. drawings.
- All dimensions are in mm unless otherwise noted.

Antenna Support Structure	
Type	Alifab monopole
Height	15m
Manufacturer	Alifab

BT-PSRCP Antenna / Dish Schedule	
Antenna Configuration 11	
Duplexer Required Y / N	

Antenna Tilt 6°						
Antenna/ Dish Ref.	Antenna Type	Size (mm)	Height AGL (m)	Antenna Bearing	Cable Type	Cable Length(m)
JB7546396	Tx/RX	2800	16.3m	OMNI	LDFS-50	22
JB7546396	RX	2800	16.3m	OMNI	LDFS-50	22
JB7546396	RX	2800	16.3m	OMNI	LDFS-50	22
DISH		600	10.0m	DIR@240°	TBC	17

Rev	Date	Amendments	Drawn By	Approved By
B	10.10.02	Dish relocated at 10m	TM	MG
A	03.07.02	Issued for construction	TM	MG



Galliford

Galliford Communications

Wolvey, Hinckley
Leicestershire. LE10 3JF

Tel: 01455 222777 Fax: 01455 222758

Client

O2

Alfreya mtd Ltd
5 Langwell Road
Stoddley Park
East Leake
Lincolnshire
LN11 1TT

Job Title

FRUITEX STORAGE & DISTRIBUTION
STATION YARD, DONNINGTON
SPALDING, Lincs, PE11 4HQ

Drawing Title

CIVILS/STRUCTURAL DETAIL DESIGN
SOUTH EAST ELEVATION

Scale	AS SHOWN	DO NOT SCALE THIS DRAWING	County Ref	LINK08
Drawn by	TM	Checked by	RP	Approved by
Date Drawn	03.07.02	Date Checked	03.07.02	Date Approved
Consultant Ref	MMD1752	Sits Code	GF_LIN001	Rev.
			13	B

NOTE: ORIGINAL DRAWING SIZE AS

NOTES NOTES

1. Do Not Scale
2. This drawing to be read in conjunction with Galliford drawing No.s LN008/11,12,14,15,16 and Standard B.T. drawings.
3. All dimensions are in mm unless otherwise noted.

Antenna Support Structure						
Type	Height	Alifab. monopole				
	15m					
Manufacturer	Alifab					
BT-PSRCP Antenna / Dish Schedule						
Antenna Configuration 11						
Duplexer Required Y / N						
Antenna Tilt 6°						
Antenna / Dish Ref.	Antenna Type	Size (mm)	Height (m)	Antenna Bearing	Coaxial Type	Coaxial Length(m)
4875548.396	TX/RX	2600	16.3m	OMNI	UFG-50	22
4875548.396	RX	2600	16.3m	OMNI	UFG-50	22
4875548.396	RX	2600	16.3m	OMNI	UFG-50	22
DISH		800	10.0m	DIREC40°	TBC	17


			B	03.07.02	Dish relocated at 10m	T/M	M/G				
			A	03.07.02	Issued for construction	T/M	M/G	Clean Up By By			


Galliford
Galliford Communications
Wolvey, Hinckley
Leicestershire, LE10 3JF
Tel: 01455 222777 Fax: 01455 222758

 O_2

Job Title: FRUITEX STORAGE & DISTRIBUTION STATION YARD, DONNINGTON SPALDING, Lincs, PE11 4HQ
Drawing Title: CIVILS/STRUCTURAL DETAIL DESIGN SOUTH EAST ELEVATION

Scale	AS SHOWN	DO NOT SCALE THIS DRAWING	County Ref	LJN008
Drawn by	TM	Checked by	Approved by	
Date Drawn	03.07.02	Date Checked	Date Approved	
		LM	03.07.02	
Consultant's Ref	Site Code	Drawing No.	Rev.	
MMD1752	GF_LJN001	13	B	

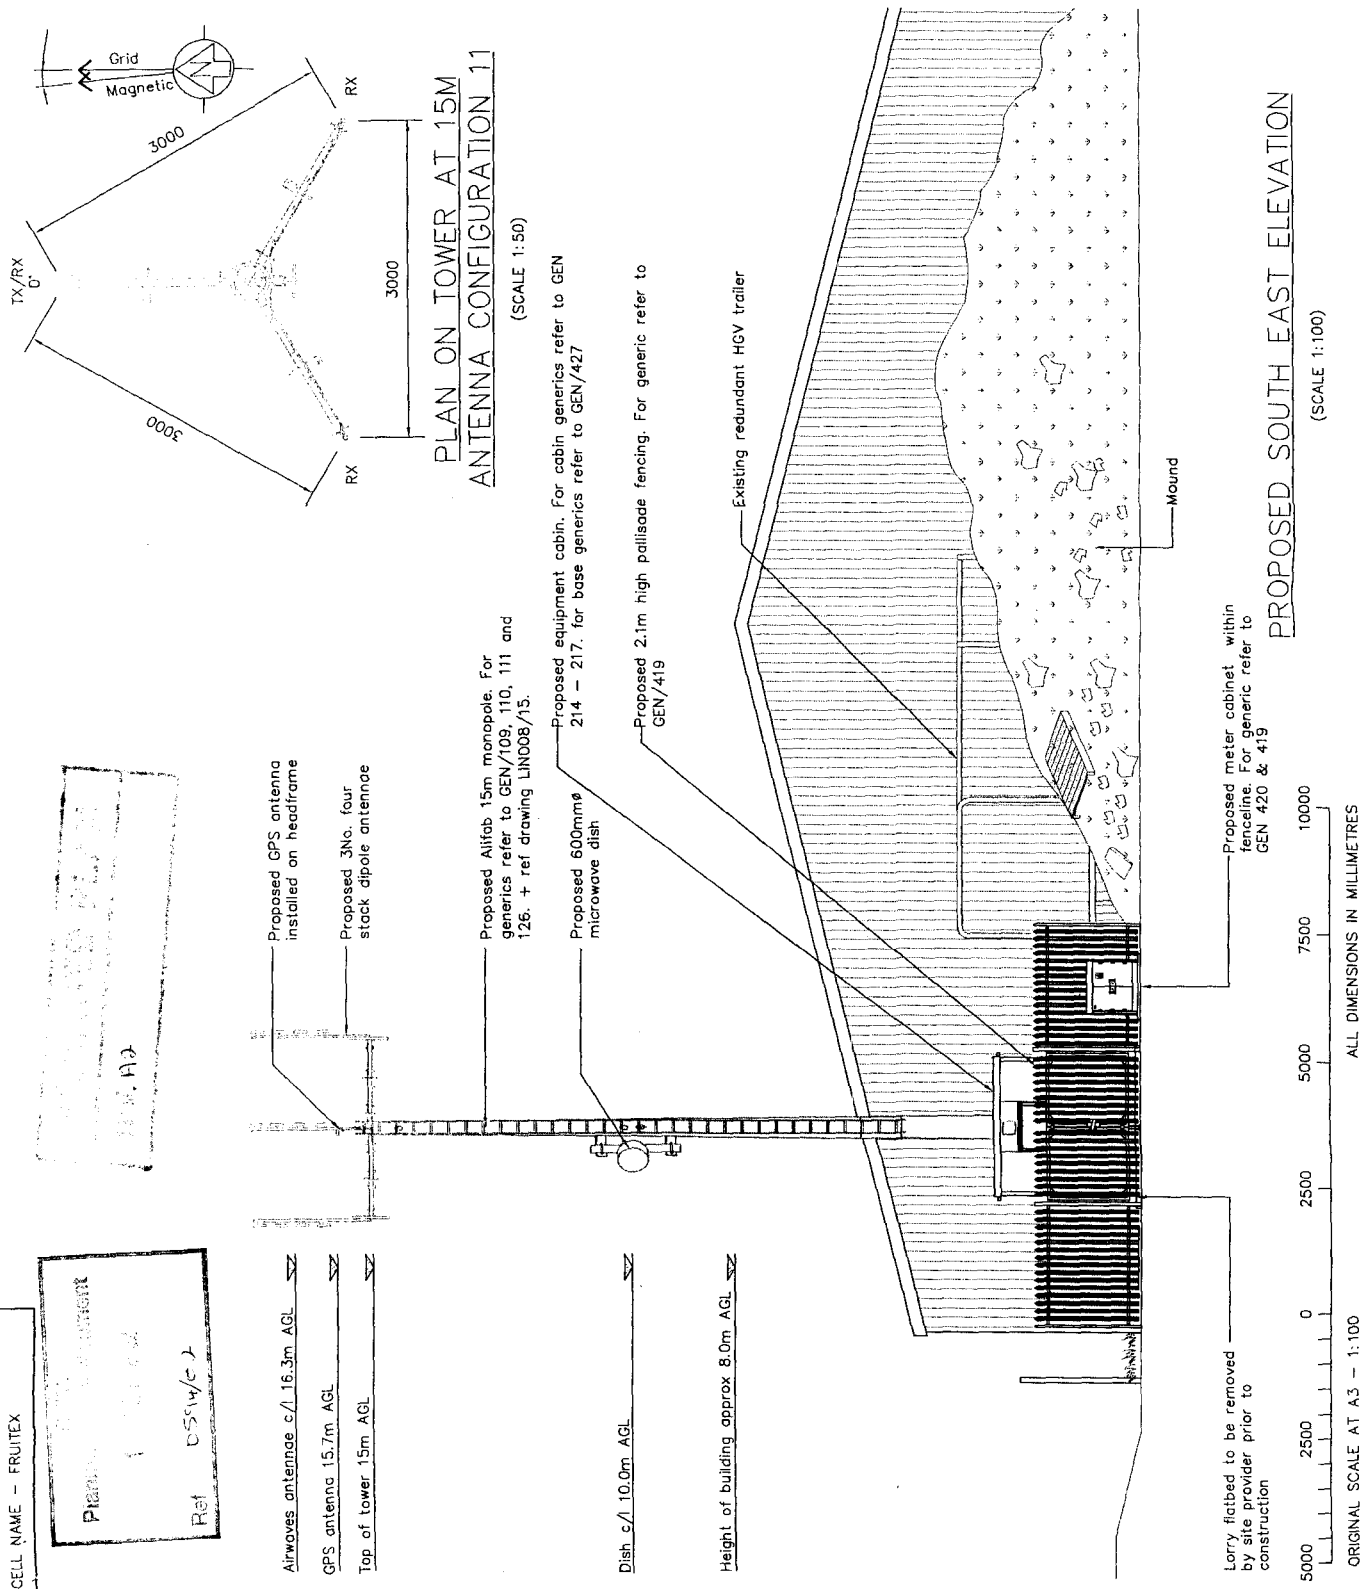

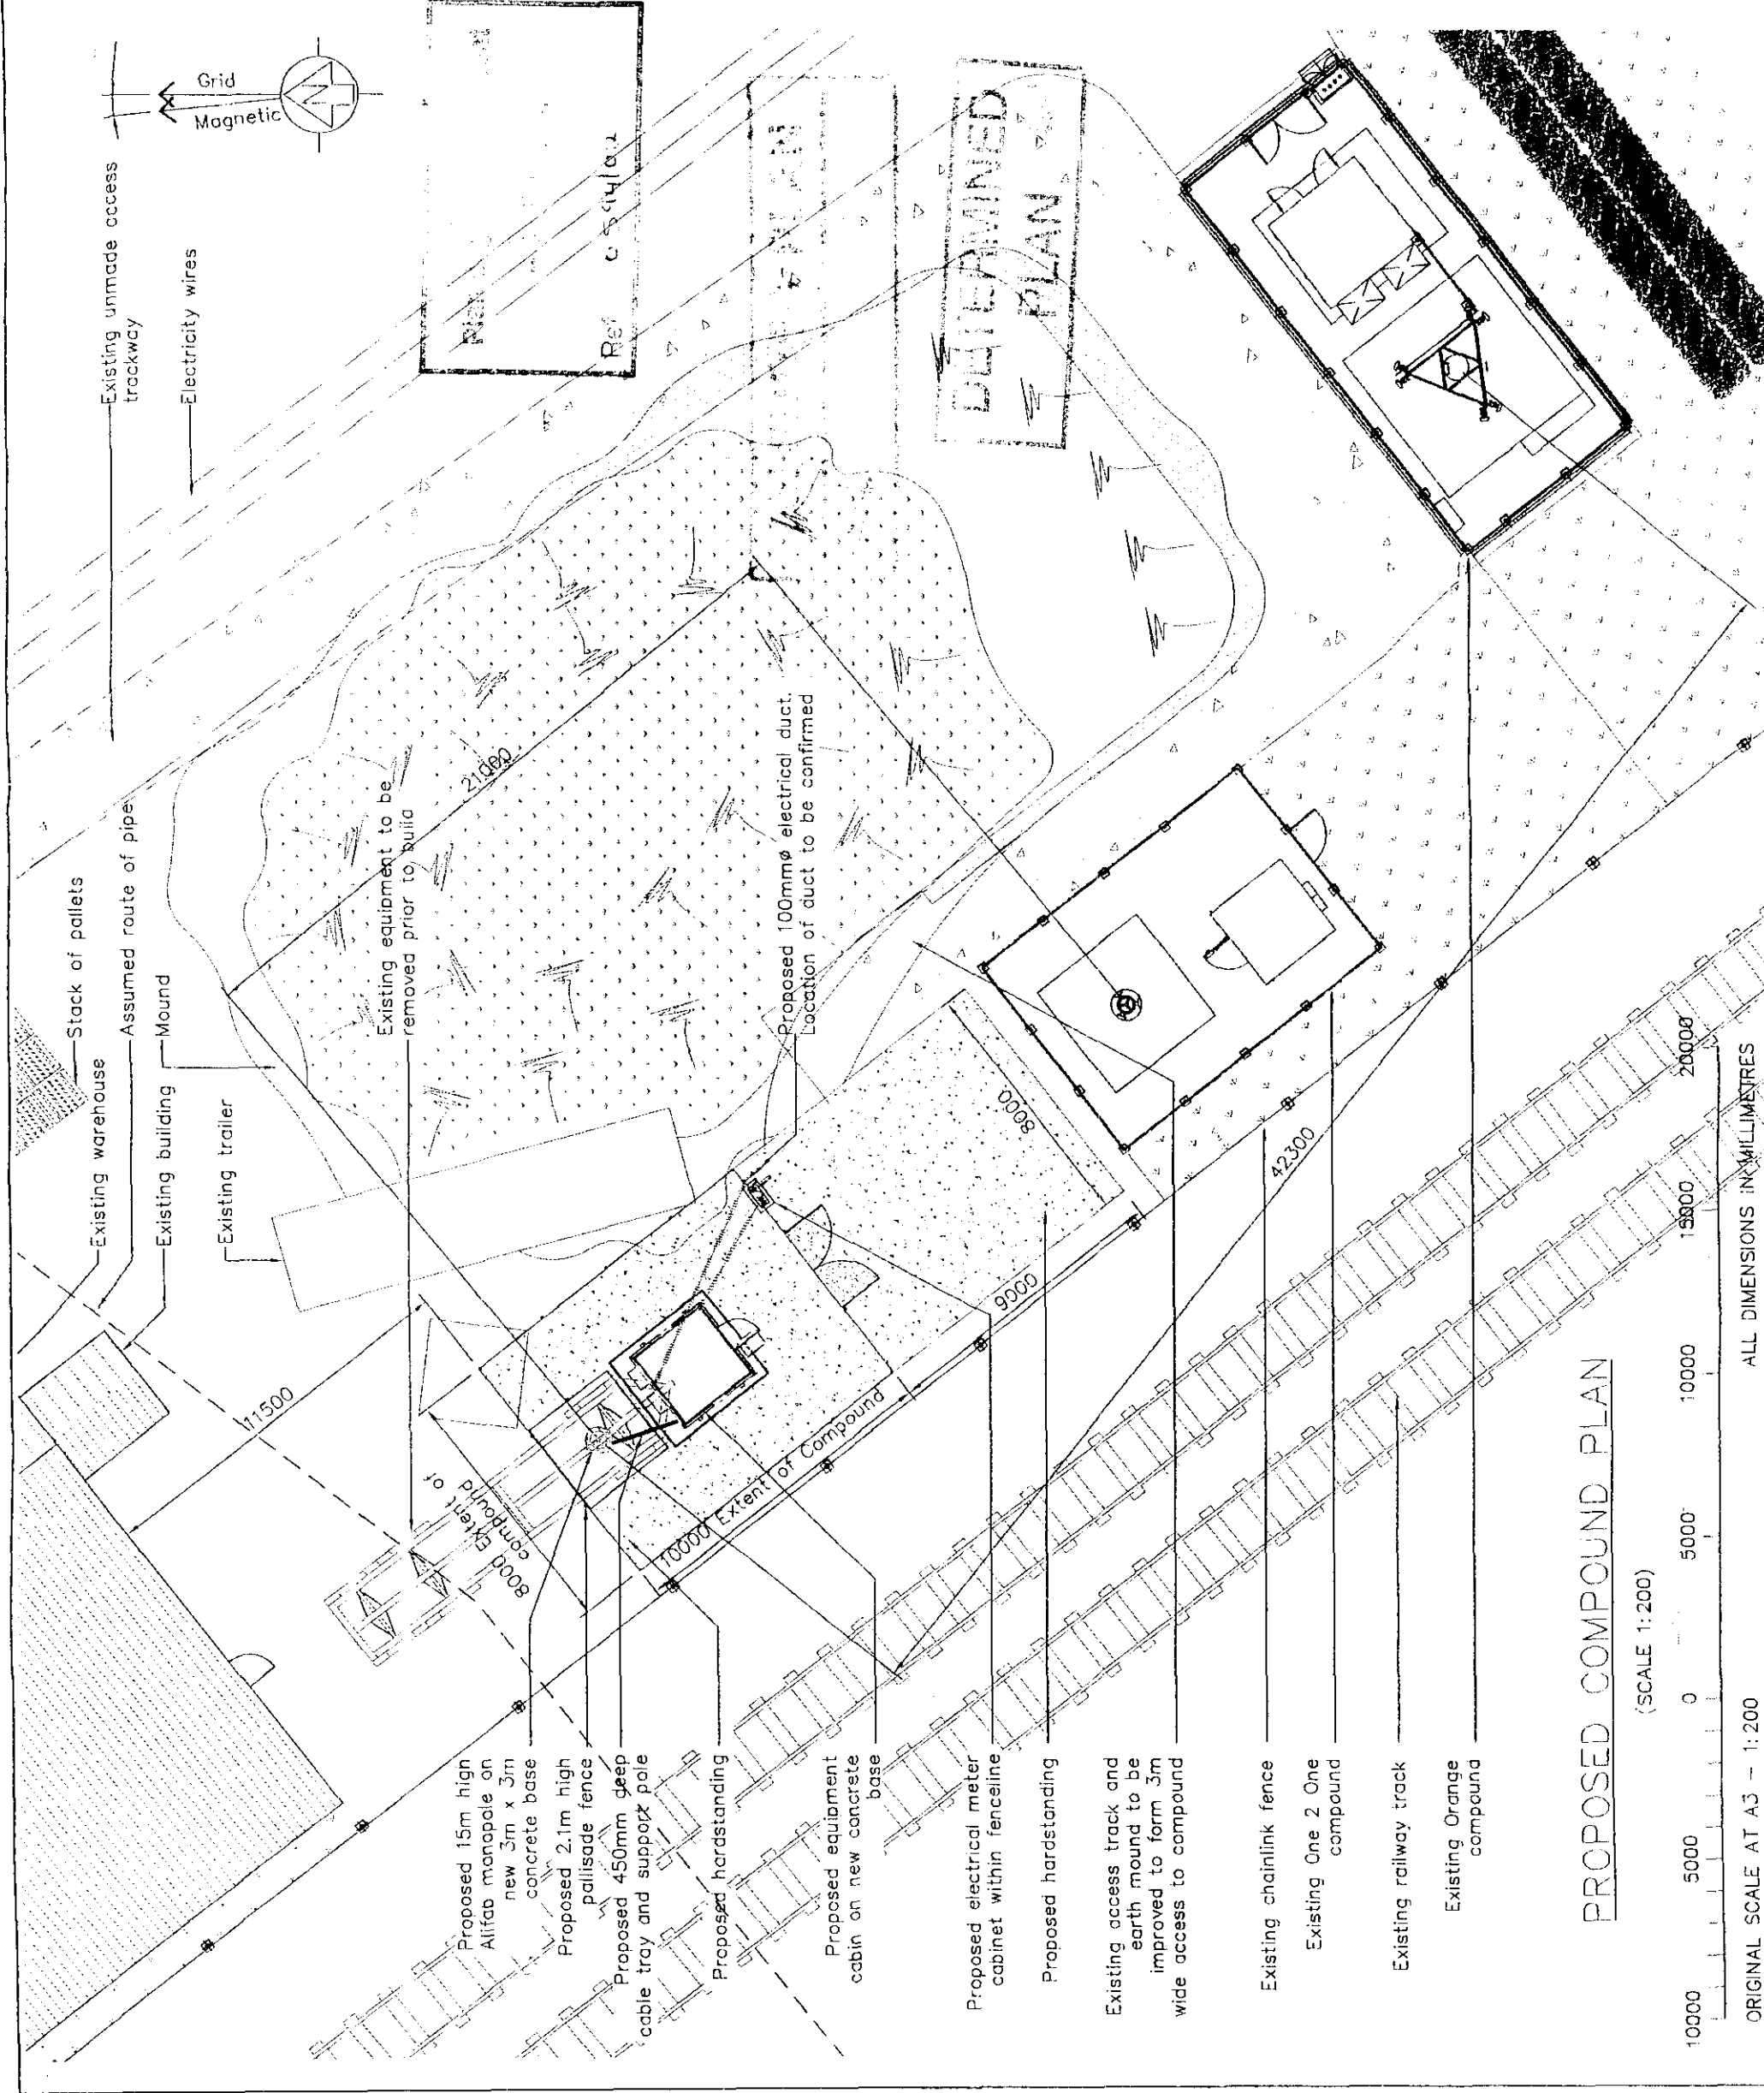

NOTE: ORIGINAL DRAWING SIZE A3			
NOTES			
1. Do Not Scale			
2. This drawing to be read in conjunction with Galliford drawing No.s LIN008/01,03 and Standard B.T. drawings.			
3. All dimensions are in mm unless otherwise noted.			
BT-PSRCP Power Supply			
REC Power Supply Required		Y / N	
BT-PSRCP Cabin Schedule			
Manf.	Elliot	Colour Ref	10A05
Type	Medium	Gland Pos. A/B/C	A
Dimension (mm)	2744 x 2744 x 2786	Door hinge L/R	L
Material	Galvanised steel welded construction	Pre assembled	X
BT-PSRCP Meter Cabinet Schedule		Flatpack	
Manf.	APW	Colour Ref	10A05
Type	Standard	Material	Galvanised steel welded construction
Dimension (mm)	1000 x 1000 x 450		
BT-PSRCP Generator Schedule			
Autonomy	6 HR	Voltage	Not required
Type	Not required	Phase	Not required
Location	Not required		
Rev	Date	Amendments	Drawn/Approved By
D	28.05.02	Compound relocated	JW MC
E	27.05.02	42300 Dimension added	TT JW
F	19.04.02	Issued for planning	LD WH
A	27.03.02	Issued for comments and approval	LD AP

**Galliford**

Galliford Communications
Wolvey, Hinckley
Leicestershire. LE10 3JF
Tel: 01455 222777 Fax: 01455 222758



Client
Airwave mm0, Ltd
5 Langdale Road
Stokeley Park
East Uxbridge
Middlesex
UB8 1TT

Job Title
FRUITEX STORAGE & DISTRIBUTION
STATION YARD, DONNINGTON
SPALDING, Lincs, PE11 4HQ

Drawing Title
PLANNING DRAWING
PROPOSED SITE LAYOUT
SHEET 2 OF 3

Scale AS SHOWN DO NOT SCALE THE DRAWING

Country Ref LIN008

Approved by RP

Checked by MH

Date Drawn 28.03.02

Date Checked 27.03.02

Date Approved 27.03.02

Consultant Ref MMD1752


Site Code GF_LIN001

Drawing No. 02

Rev. D

PROPOSED COMPOUND PLAN

 (SCALE 1:200)



ORIGINAL SCALE AT A3 - 1:200

GENERAL NOTES


Based upon ordnance survey maps with the permission of the controller of her majesty's stationery office, © Crown Copyright.

Consultant Licence No. : 100020449



O.S. Ref. : E 520273 / N 334985

SITE LOCATION

SITE LOCATION

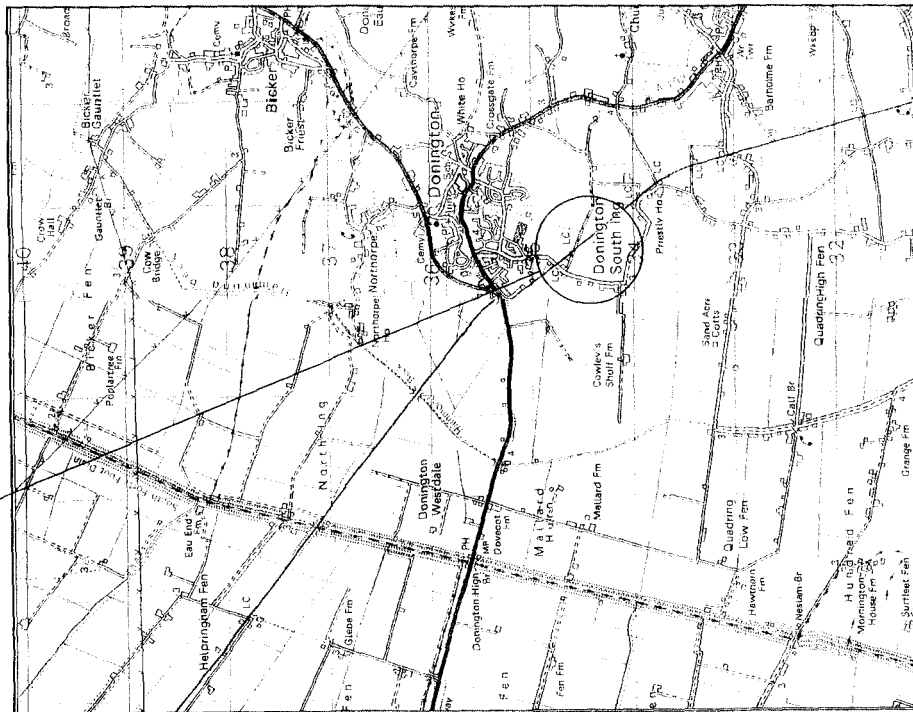

LOCATION PLAN (1:50000)

 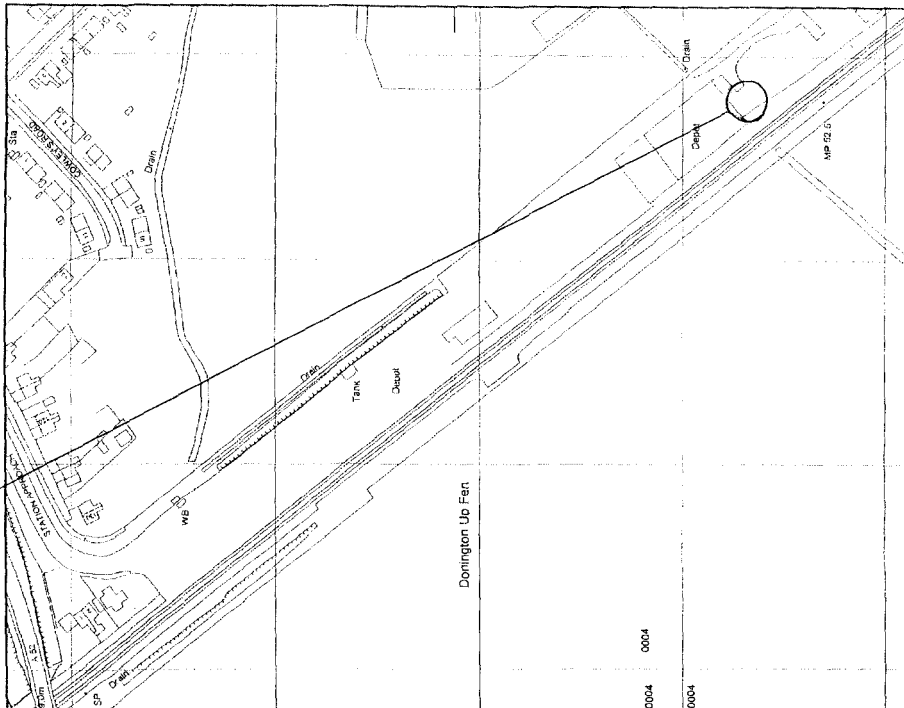

LOCATION PLAN (1:2500)

SHDC
Planning & Development
20
594/2

Rev	Date	Amendments	Drawn By	Checked By	Approved By
B	19.04.02	Issued for planning	LC	MP	
A	27.03.02	Issued for comments and approval	LC	RF	



Galliford Communications

Wolvey, Hinckley LE10 3JF

Leicestershire, LE10 3JF

Tel: 01455 222777 Fax: 01455 222758

Client

Alreva (UK) Ltd
5 Longwood Road
East Leake
Leicestershire
LE15 1TT


O₂

Job Title

Drawing Title

PLANNING & DEVELOPMENT
0004

Scale	AS SHOWN	DO NOT SCALE	County Ref	UN 008
Drawn by	Checked by	Map	Approved by	
LC	MP			
Date Drawn	Date Checked	Date Approved		
28/03/02	27/03/02	27/03/02		
Consultant Ref	Site Code	Drawing No.		
0004	0004	0004		

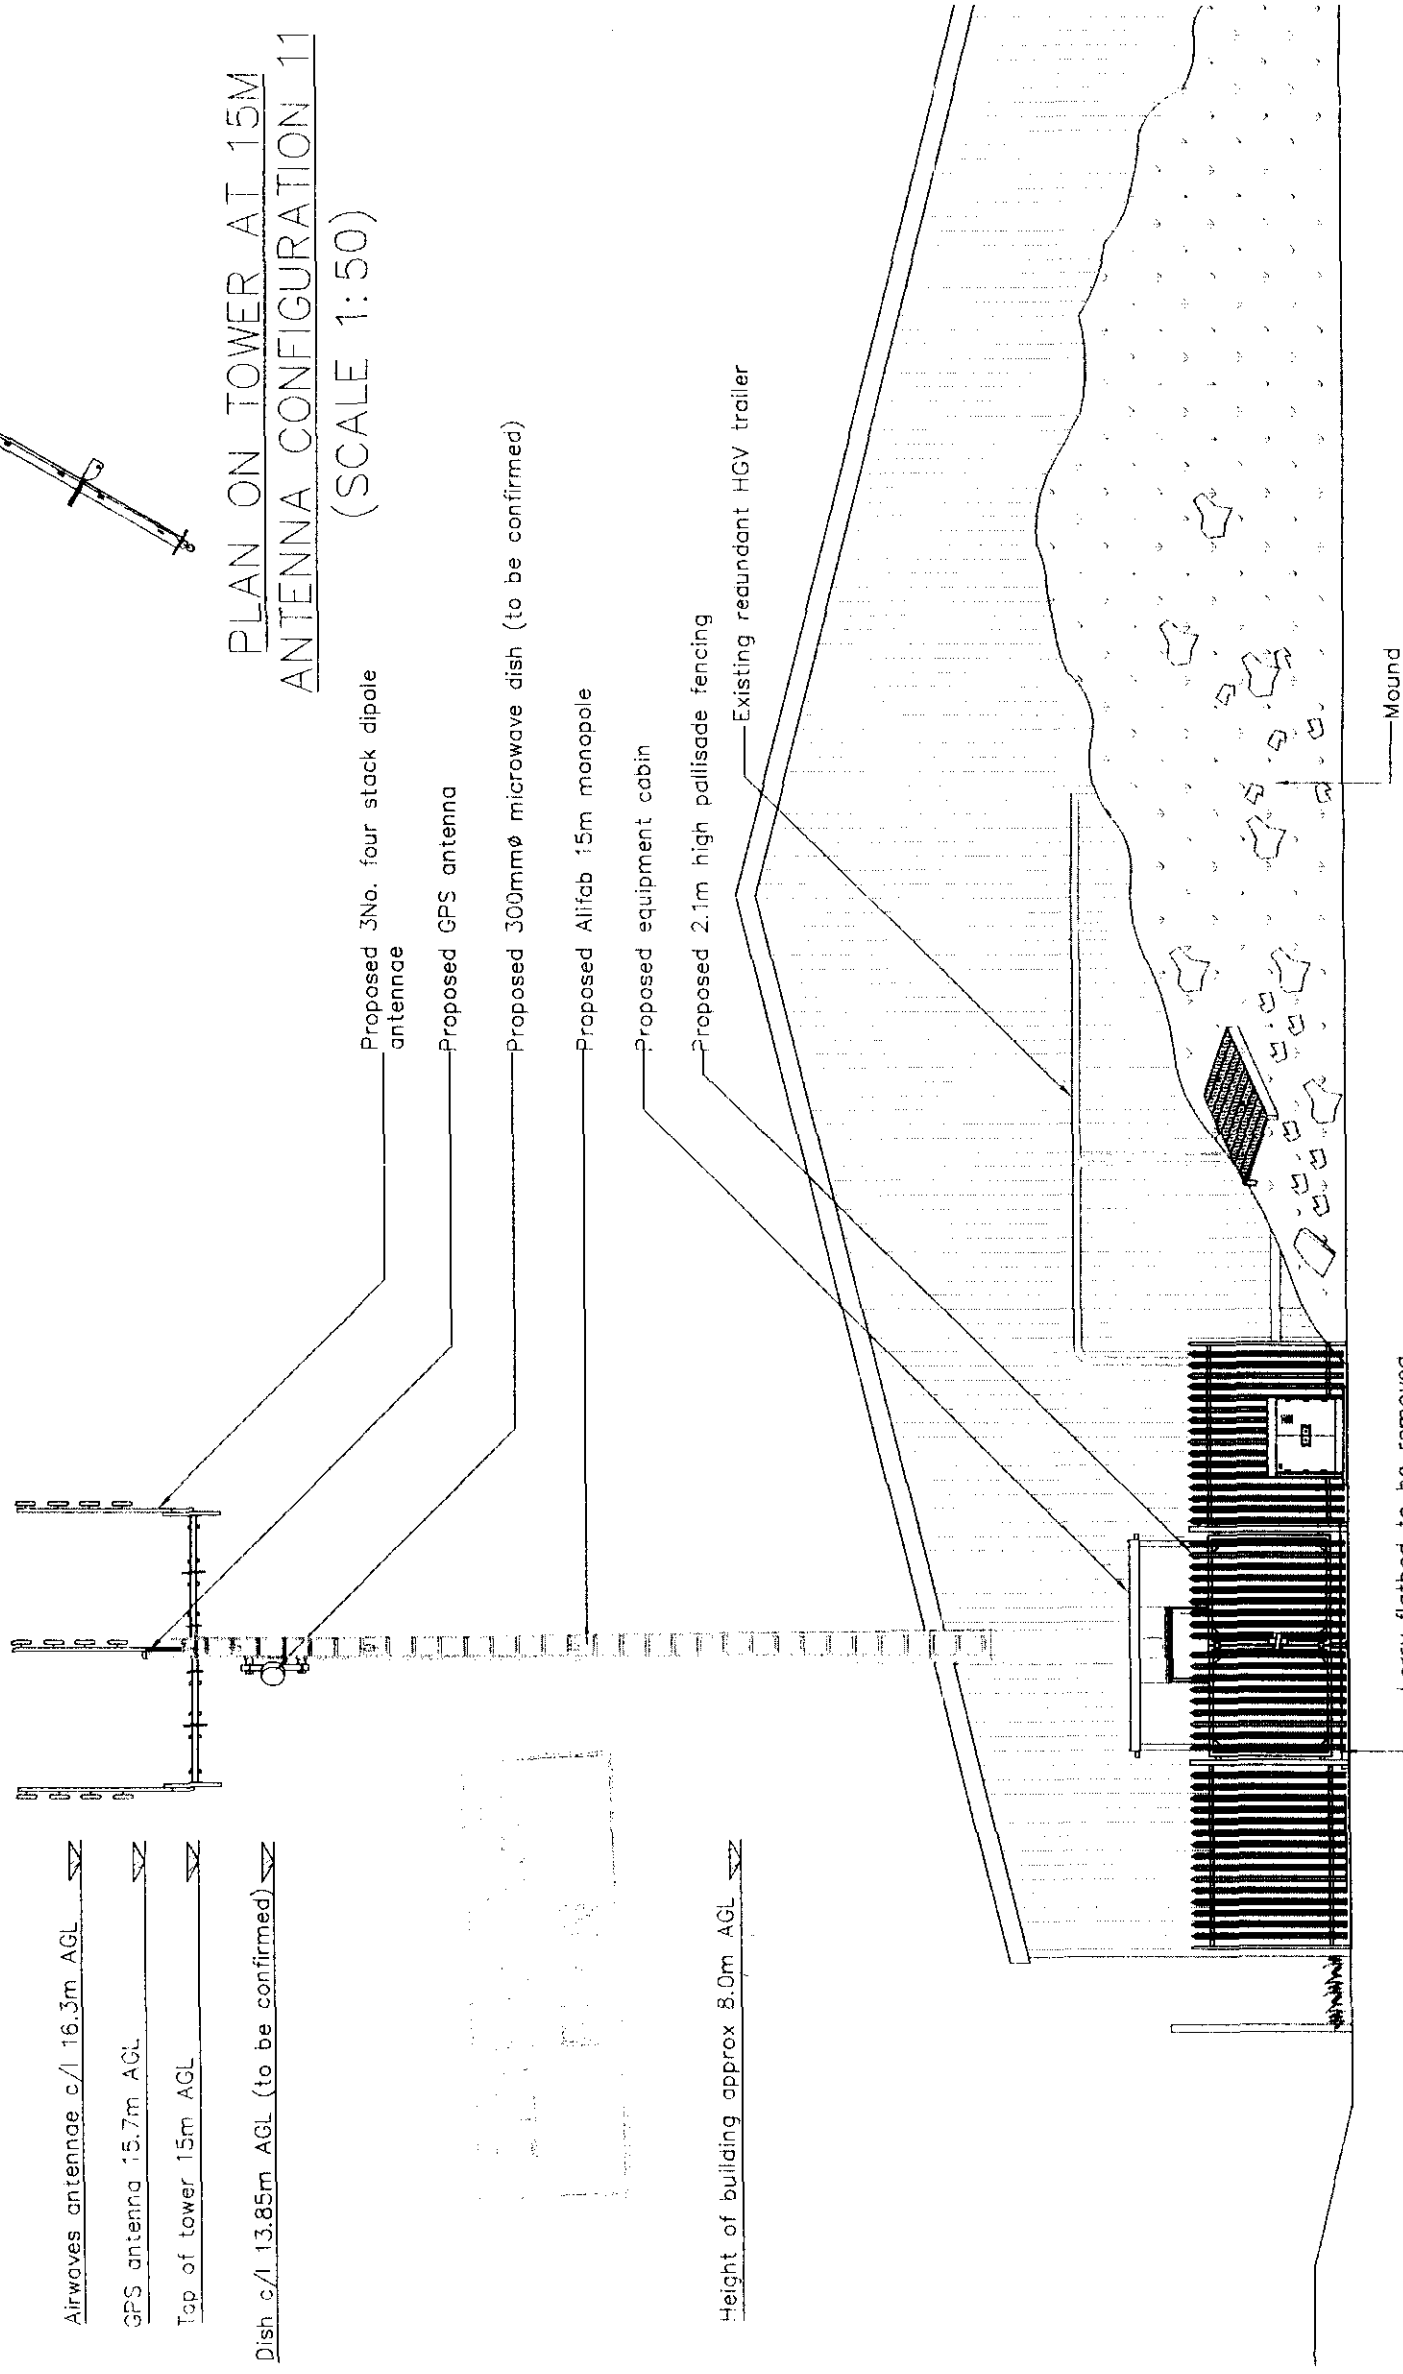

PROPOSED SOUTH EAST ELEVATION

(SCALE 1:100)

Lorry flatbed to be removed
by site provider prior to
construction

Mound

Lorry flatbed to be removed
by site provider prior to
construction

ORIGINAL SCALE AT A3 - 1:100

ALL DIMENSIONS IN MILLIMETRES

3. All dimensions are in mm unless otherwise noted.

[illegible]

BT-PSRCP Antenna / Dish Schedule
Antenna Configuration

Duplexer Required Y / 4

Antenna/ Dish Ref.	Antenna Type	Size (mm)	Height AGL (m)	Antenna Bearing	Cable Type	Cable Length(m)
SA410	SIGMA	2600	16.3	OMNI	LDF5-50	22
DISH	TBC	300	13.85	TBC	TBC	TBC

Rev	Date	Amendments	Drawn By	Approved By
B	19.04.02	Issued for planning	LC	MH
A	27.03.02	Issued for comments and approval	LC	RP



Galliford

Galliford Communications

Wolvey, Hinckley

Leicestershire. LE10 3JF

Tel: 01455 222777 Fax: 01455 222758

1

Almaviva mmQ, Ltd.
5 Longwalk Road
Stoddley Park
East Uxbridge
Middlesex
UB8 3 1TT

Job Title

Drawing Title

Scale	AS SHOWN	DO NOT SCALE THIS DRAWING	County Ref	JUN 0006
Drawn by LC	Checked by MH		Approved by RP	
Date Drawn 28.03.02	Date Checked 27.03.02		Date Approved 27.03.02	
Consultant Ref	Site Code	Drawing No.	Rev.	