
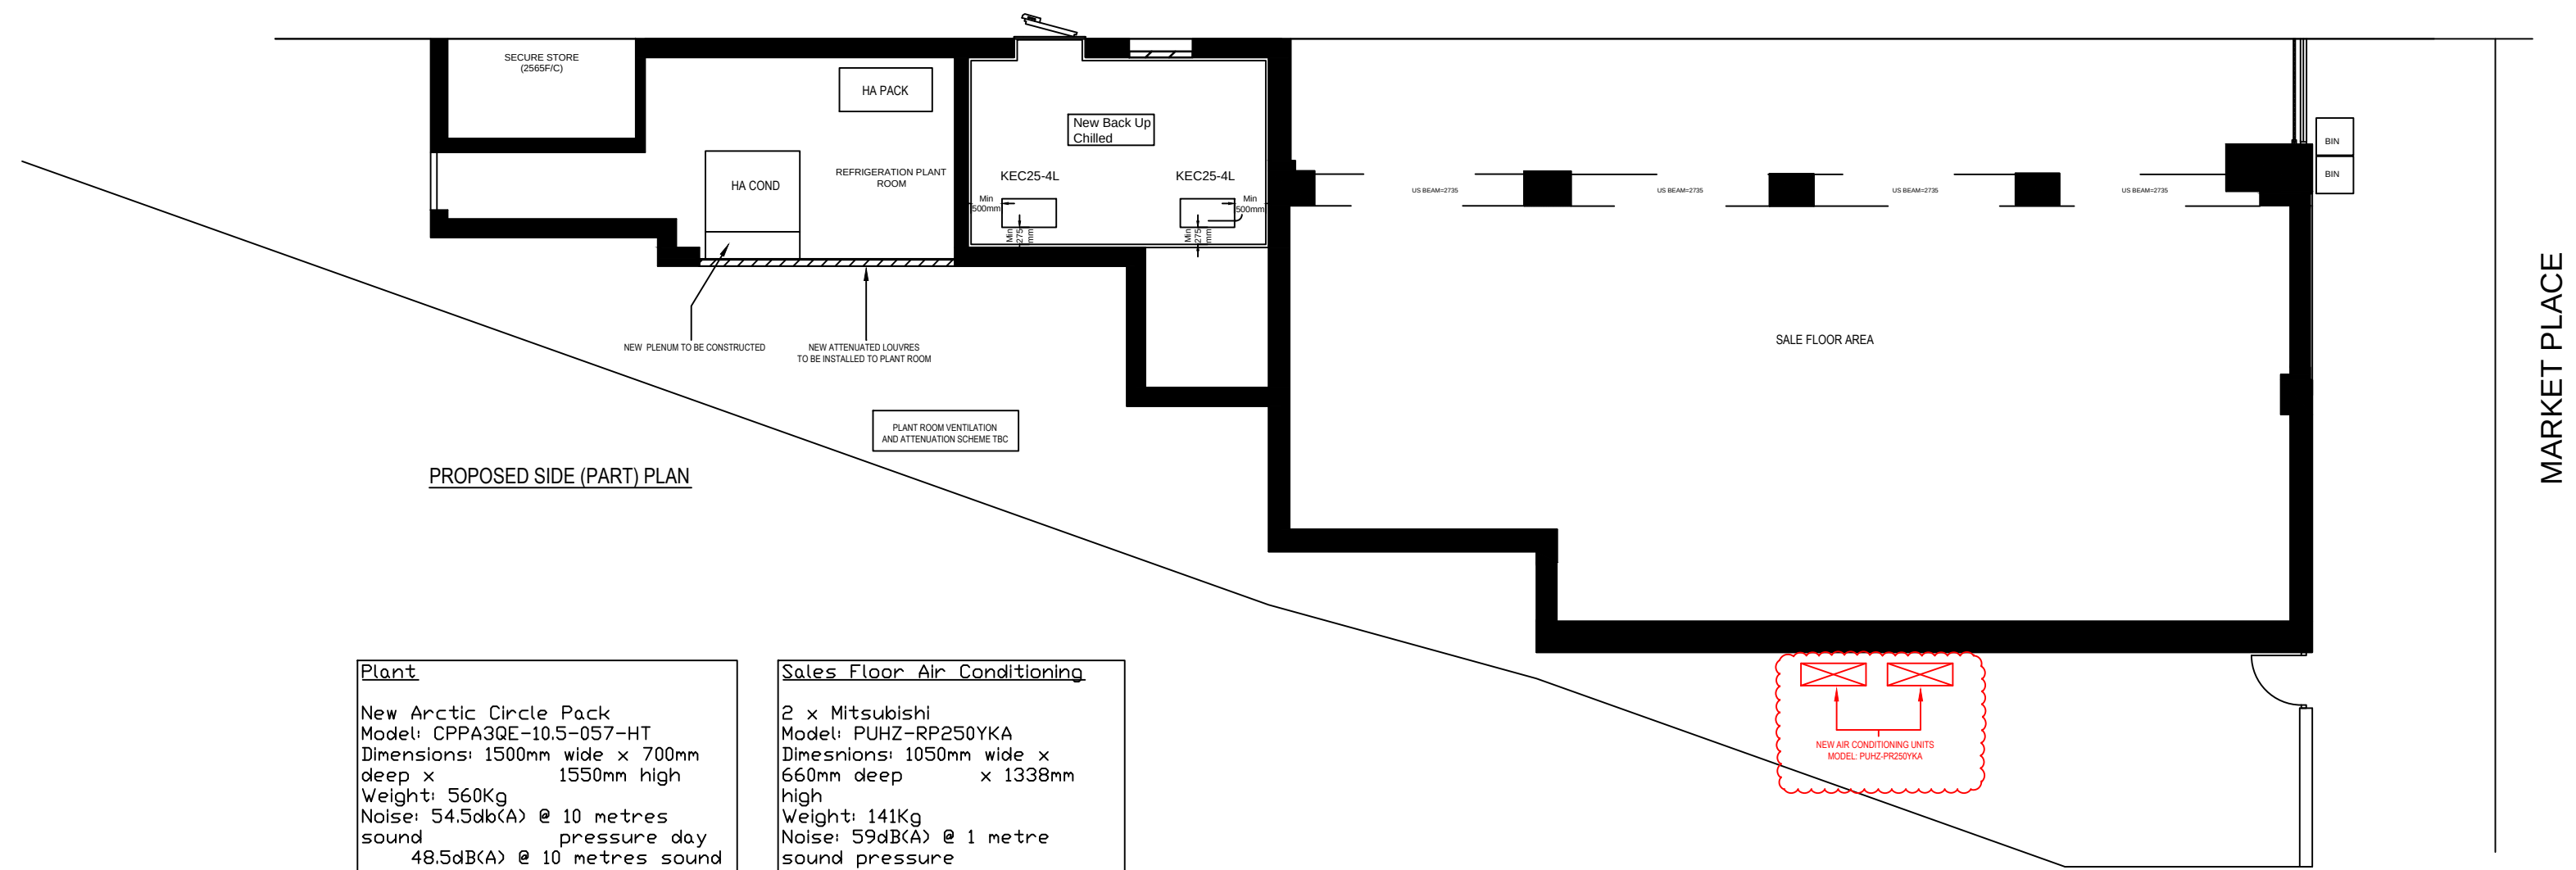


DRAWING NOTES

Please note: These drawings are for planning purposes only and should not be used for construction.

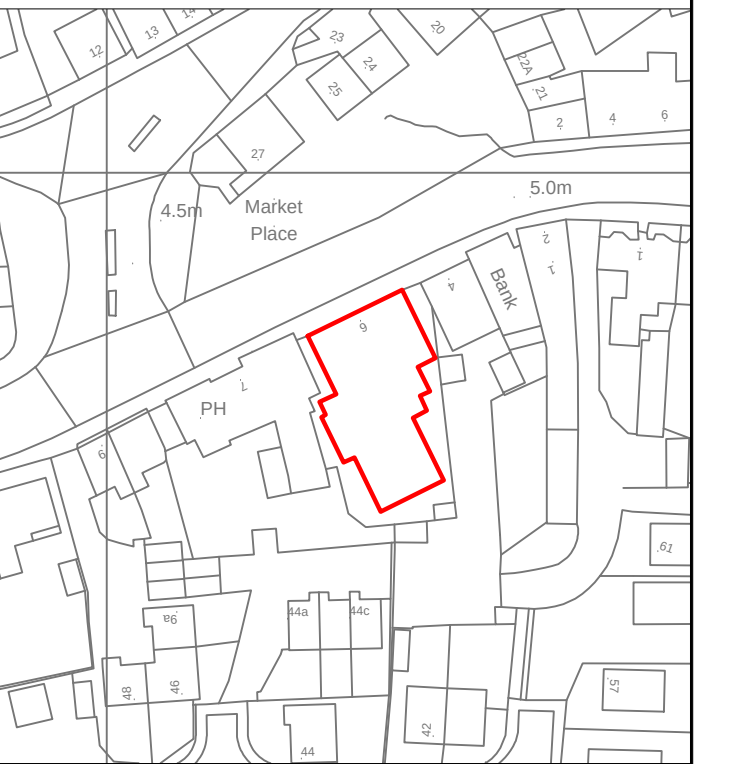

PROPOSED SIDE (PART) PLAN

Plant


New Arctic Circle Pack
Model: CPPA3QE-10.5-057-HT
Dimensions: 1500mm wide x 700mm
deep x 1550mm high
Weight: 560Kg
Noise: 54.5dB(A) @ 10 metres
sound pressure day
48.5dB(A) @ 10 metres sound
pressure night

New Searle Condenser
Model:
RF-PA201T3V-091P770-SC5-AV-1JB
Dimensions: 1523mm long x 1300mm
deep x 2335mm high
Weight: 390Kg
Noise: 50dB(A) @ 10 metres day


Sales Floor Air Conditioning

2 x Mitsubishi
Model: PUHZ-RP250YKA
Dimensions: 1050mm wide x
660mm deep x 1338mm
high
Weight: 141Kg
Noise: 59dB(A) @ 1 metre
sound pressure


Ceiling cassettes to be installed to suit the new lighting layout

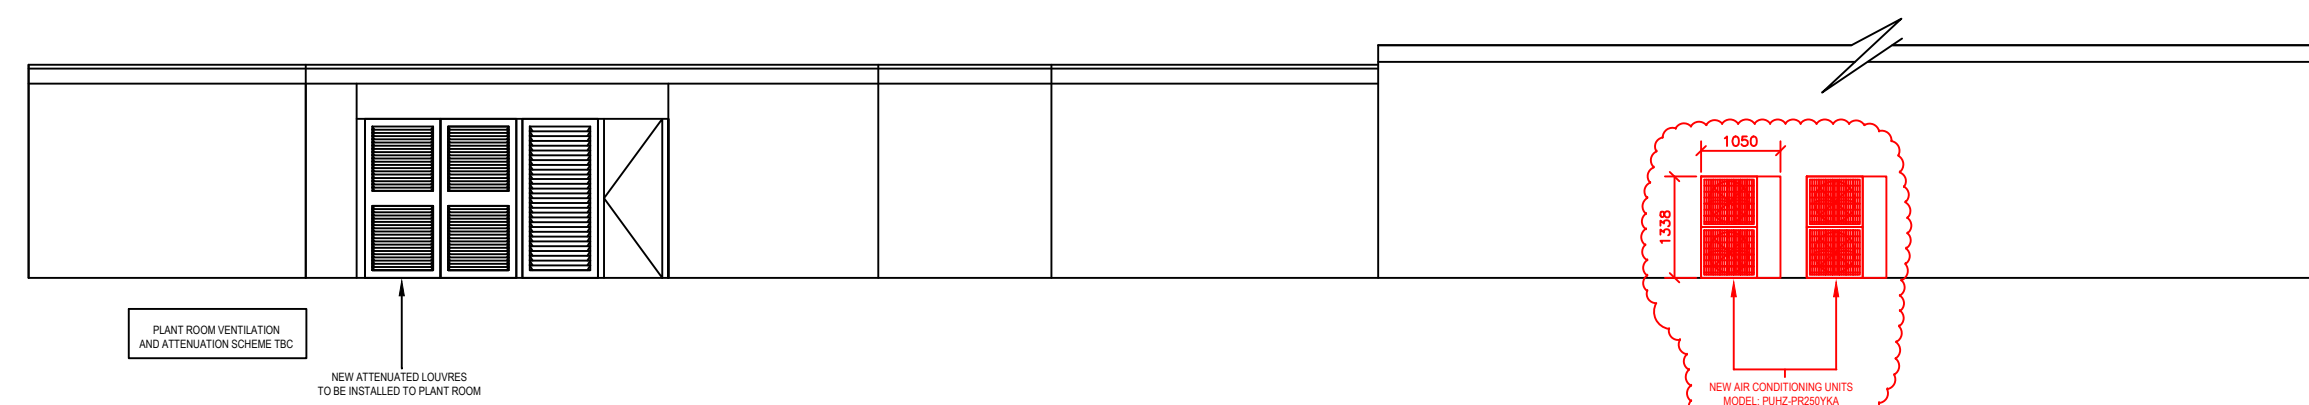

PROPOSED SIDE ELEVATION

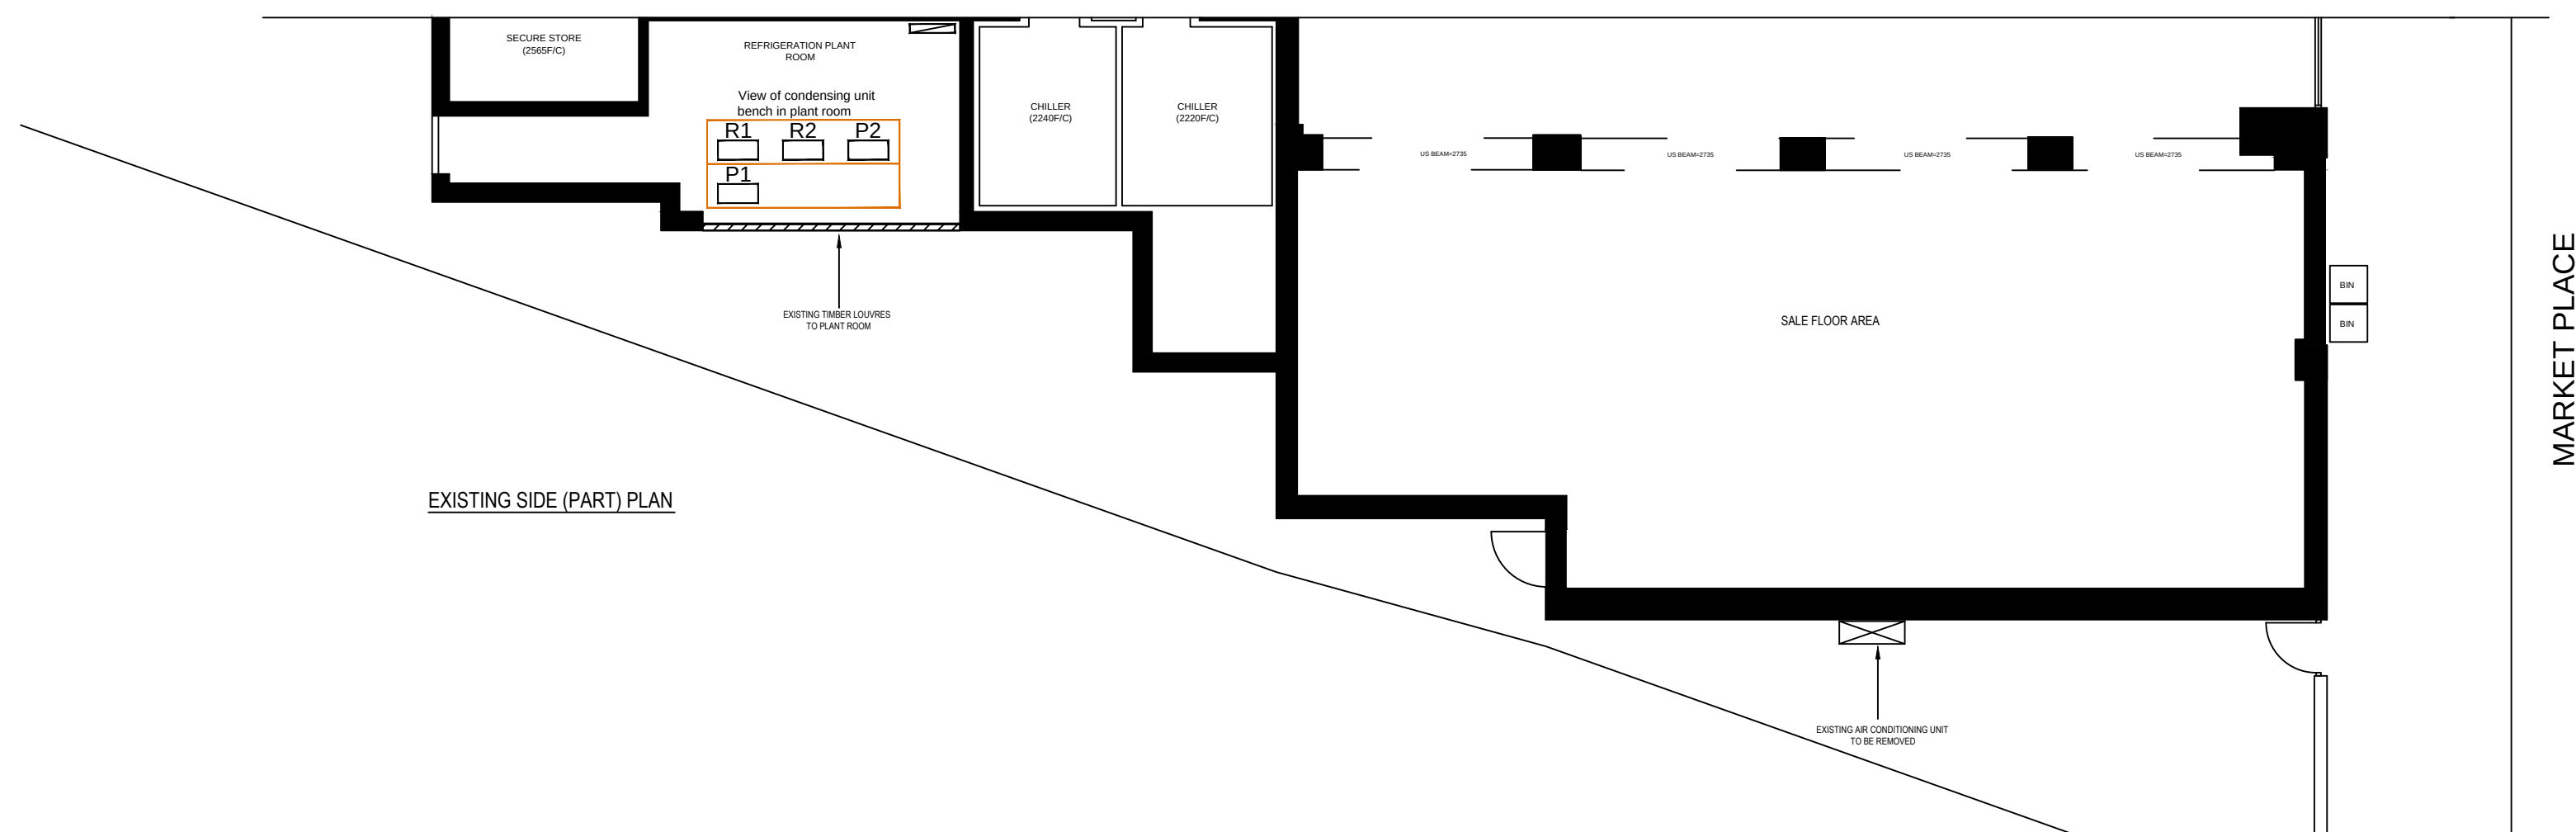

EXISTING SIDE (PART) PLAN

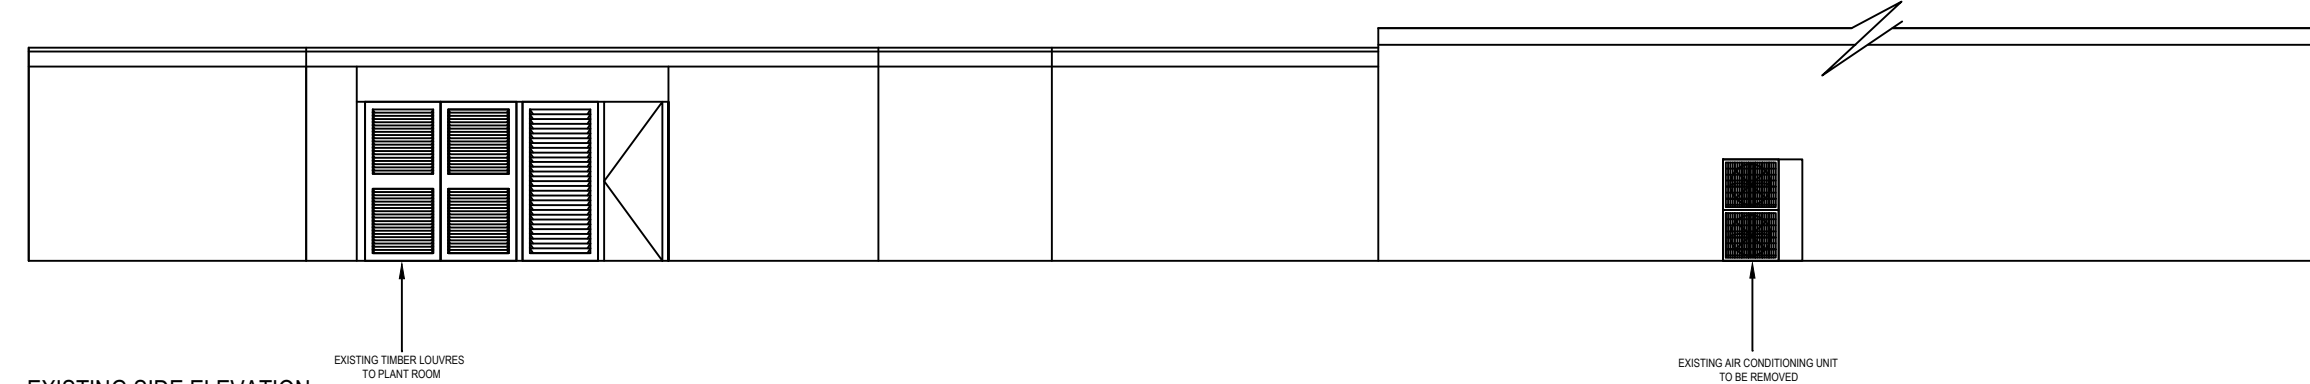

EXISTING SIDE ELEVATION

PLANNING

[illegible]

REV.	DESCRIPTION	REV.	DATE
		CLIENT: Co-operative Group	
PROJECT: Donnington			
ADDRESS: Co-operative Store 6 Market Place Donnington Spalding PE11 4ST			
TITLE: SIDE LAYOUTS (PART) PLAN & ELEVATION			
DRAWN BY: RH CHECKED: RM	SCALE: 1:100 @A1	DRAWN DATE: 01/09/14	REVISED DATE: .
DRG.NO.: CP-DONN-001-002		REV.: 	

ENCLOSURE (DONNINGTON) 1/10

T. 01430 260000

F. 01430 260001

E. 01430 260002

THIS DRAWING AND ITS DATA IS THE PROPERTY OF EVOLVE DESIGN LIMITED & SHALL NOT BE REPRODUCED WITHOUT THE COMPANY'S CONSENT. WRITTEN DIMENSIONS TAKE PREFERENCE. ANY DISCREPANCIES SHOULD BE REPORTED TO EVOLVE DESIGN LIMITED IMMEDIATELY - IF IN DOUBT ASK.