


- General Notes
- 1. All work to comply with the current Building regulations
 - 2. All works may be subject to revision on site
 - 3. All drawings are the copyright of Deco Limited
 - 4. This drawing may not be copied without prior permission

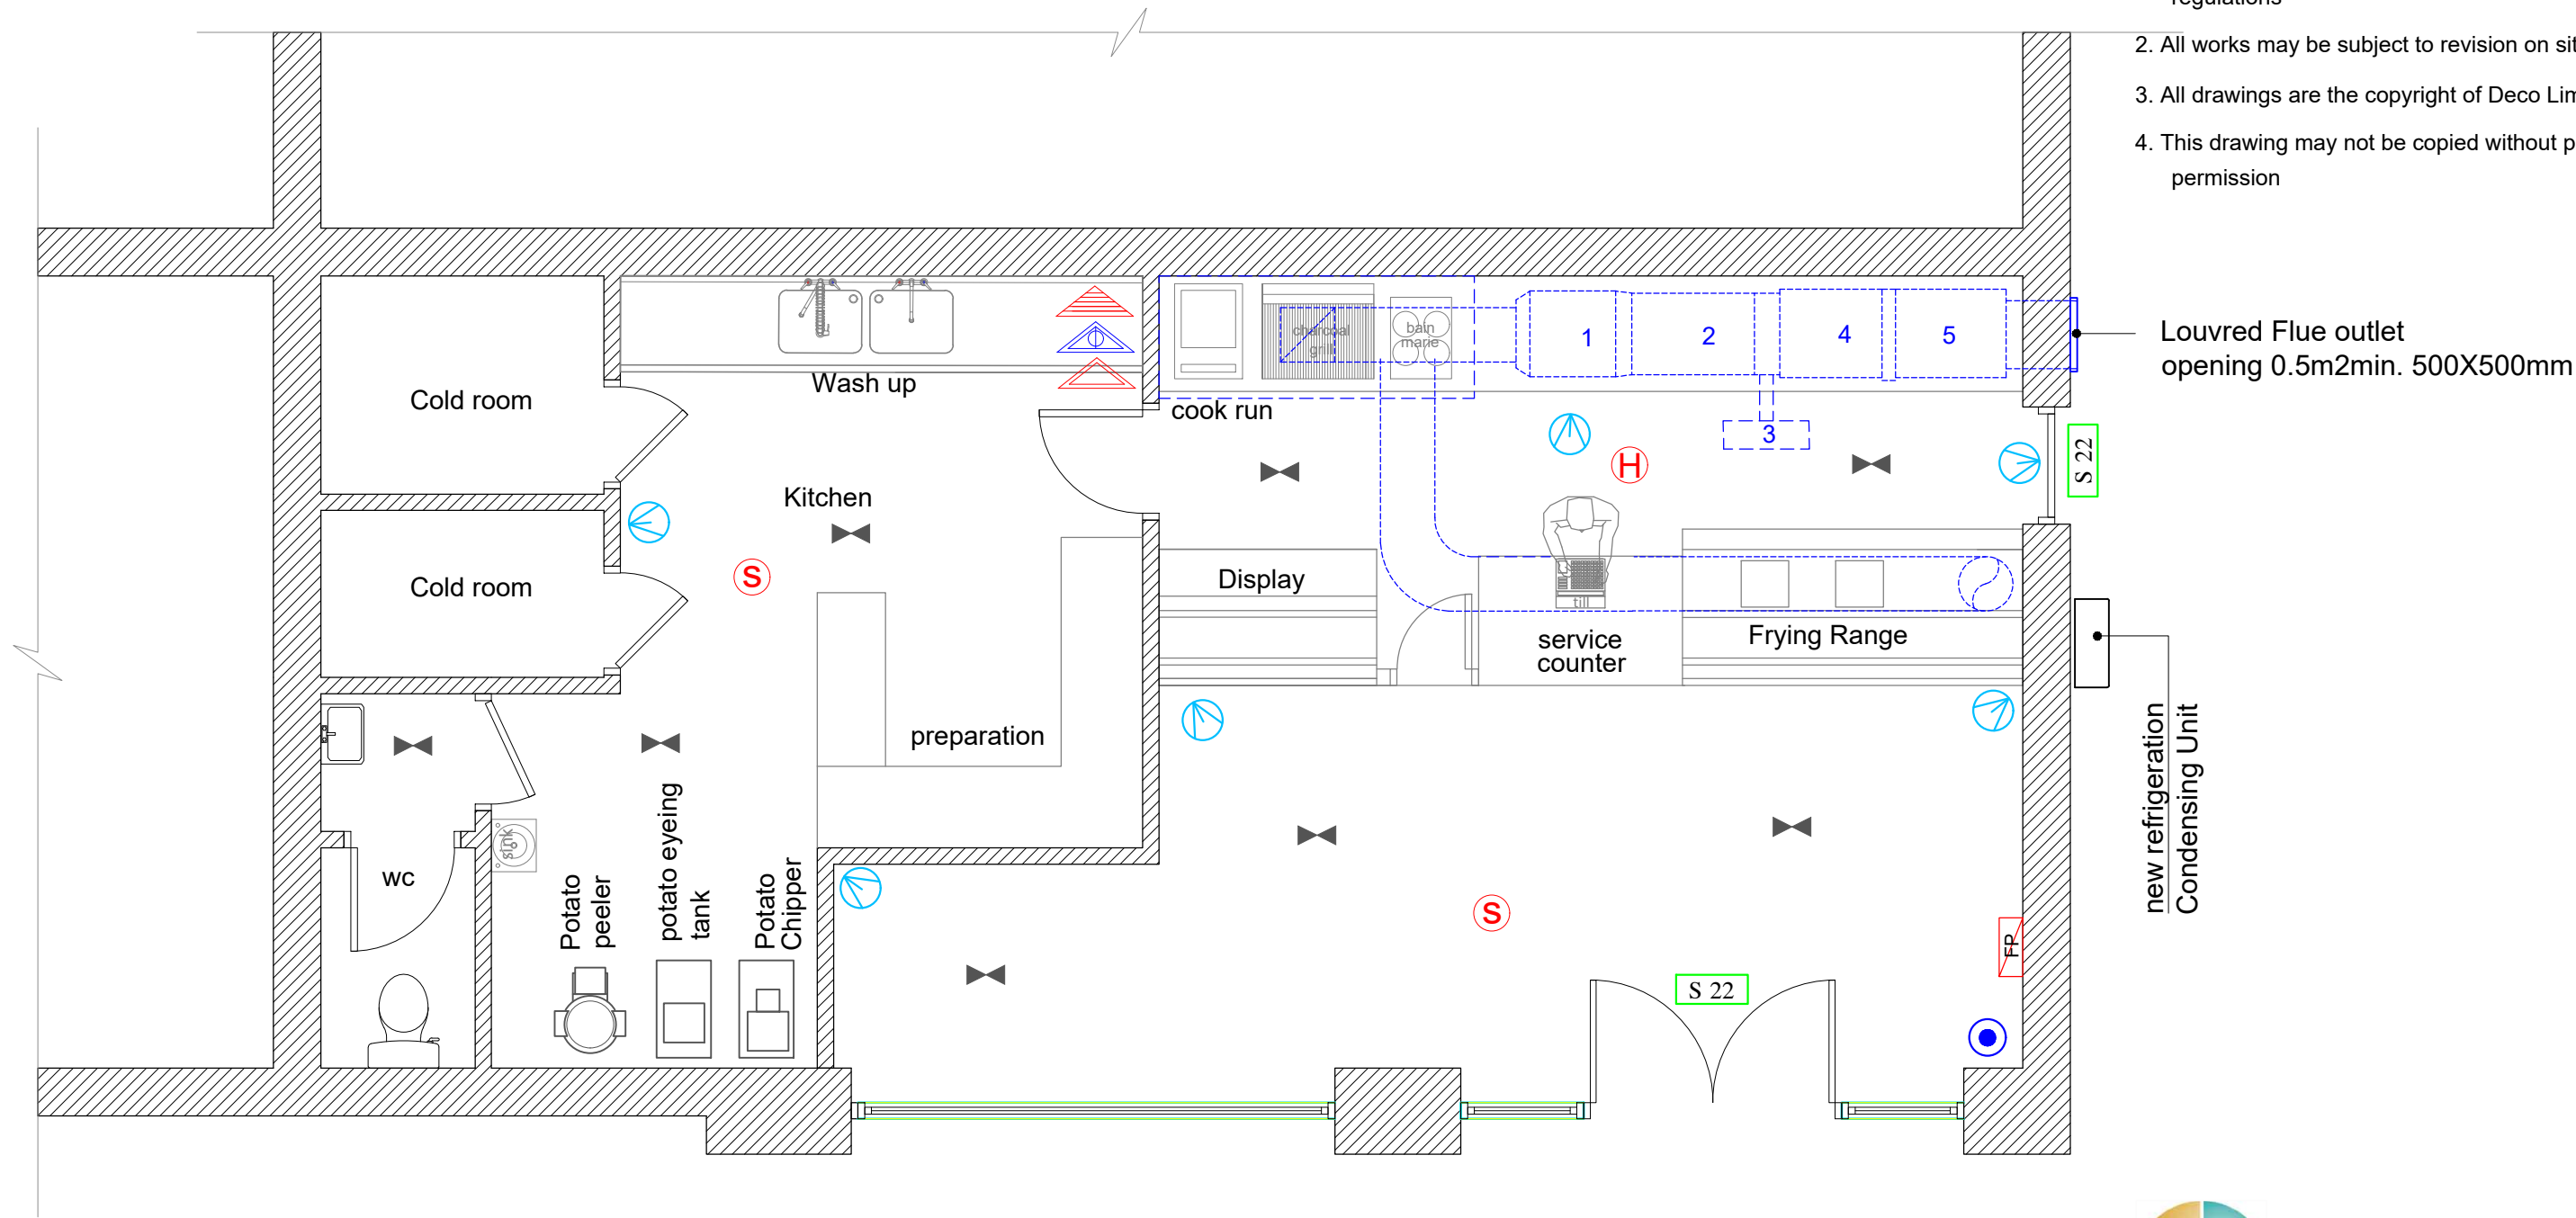

KEY

- 1- ELECTROSTATIC PRECIPITATOR (ESP 3000)
- 2- CARBON FILTER
- 3- UV-O 1000
- 4- MOTOR FAN
- 5- SILENCER

LEGEND

- SIGN-EMERGENCY EXIT
- SMOKE DEDECTOR
- HEAT DEDECTOR
- CALL POINT
- CCTV



CARBON DIOXIDE FIRE EXTINGUISHER



9 LT. WATER FIRE EXTINGUISHER



WET CHEMICAL FIRE EXTINGUISHER



EMERGENCY LIGHT
3 hour non maintained



FIRE PANEL
Fire Alarm & Detection systems
should comply with BS5839.



deco architecture & engineering
devrim@decoeng.co.uk

Project		Land at Church Street, Donington	
Drawing Title		Proposed Ground Floor Plan	
Project Number	40	Date	10/05/2022
Drawn by	DS	Checked by	-
Scale	1:50@A3	Revision	-
Drawing No	P-103		