


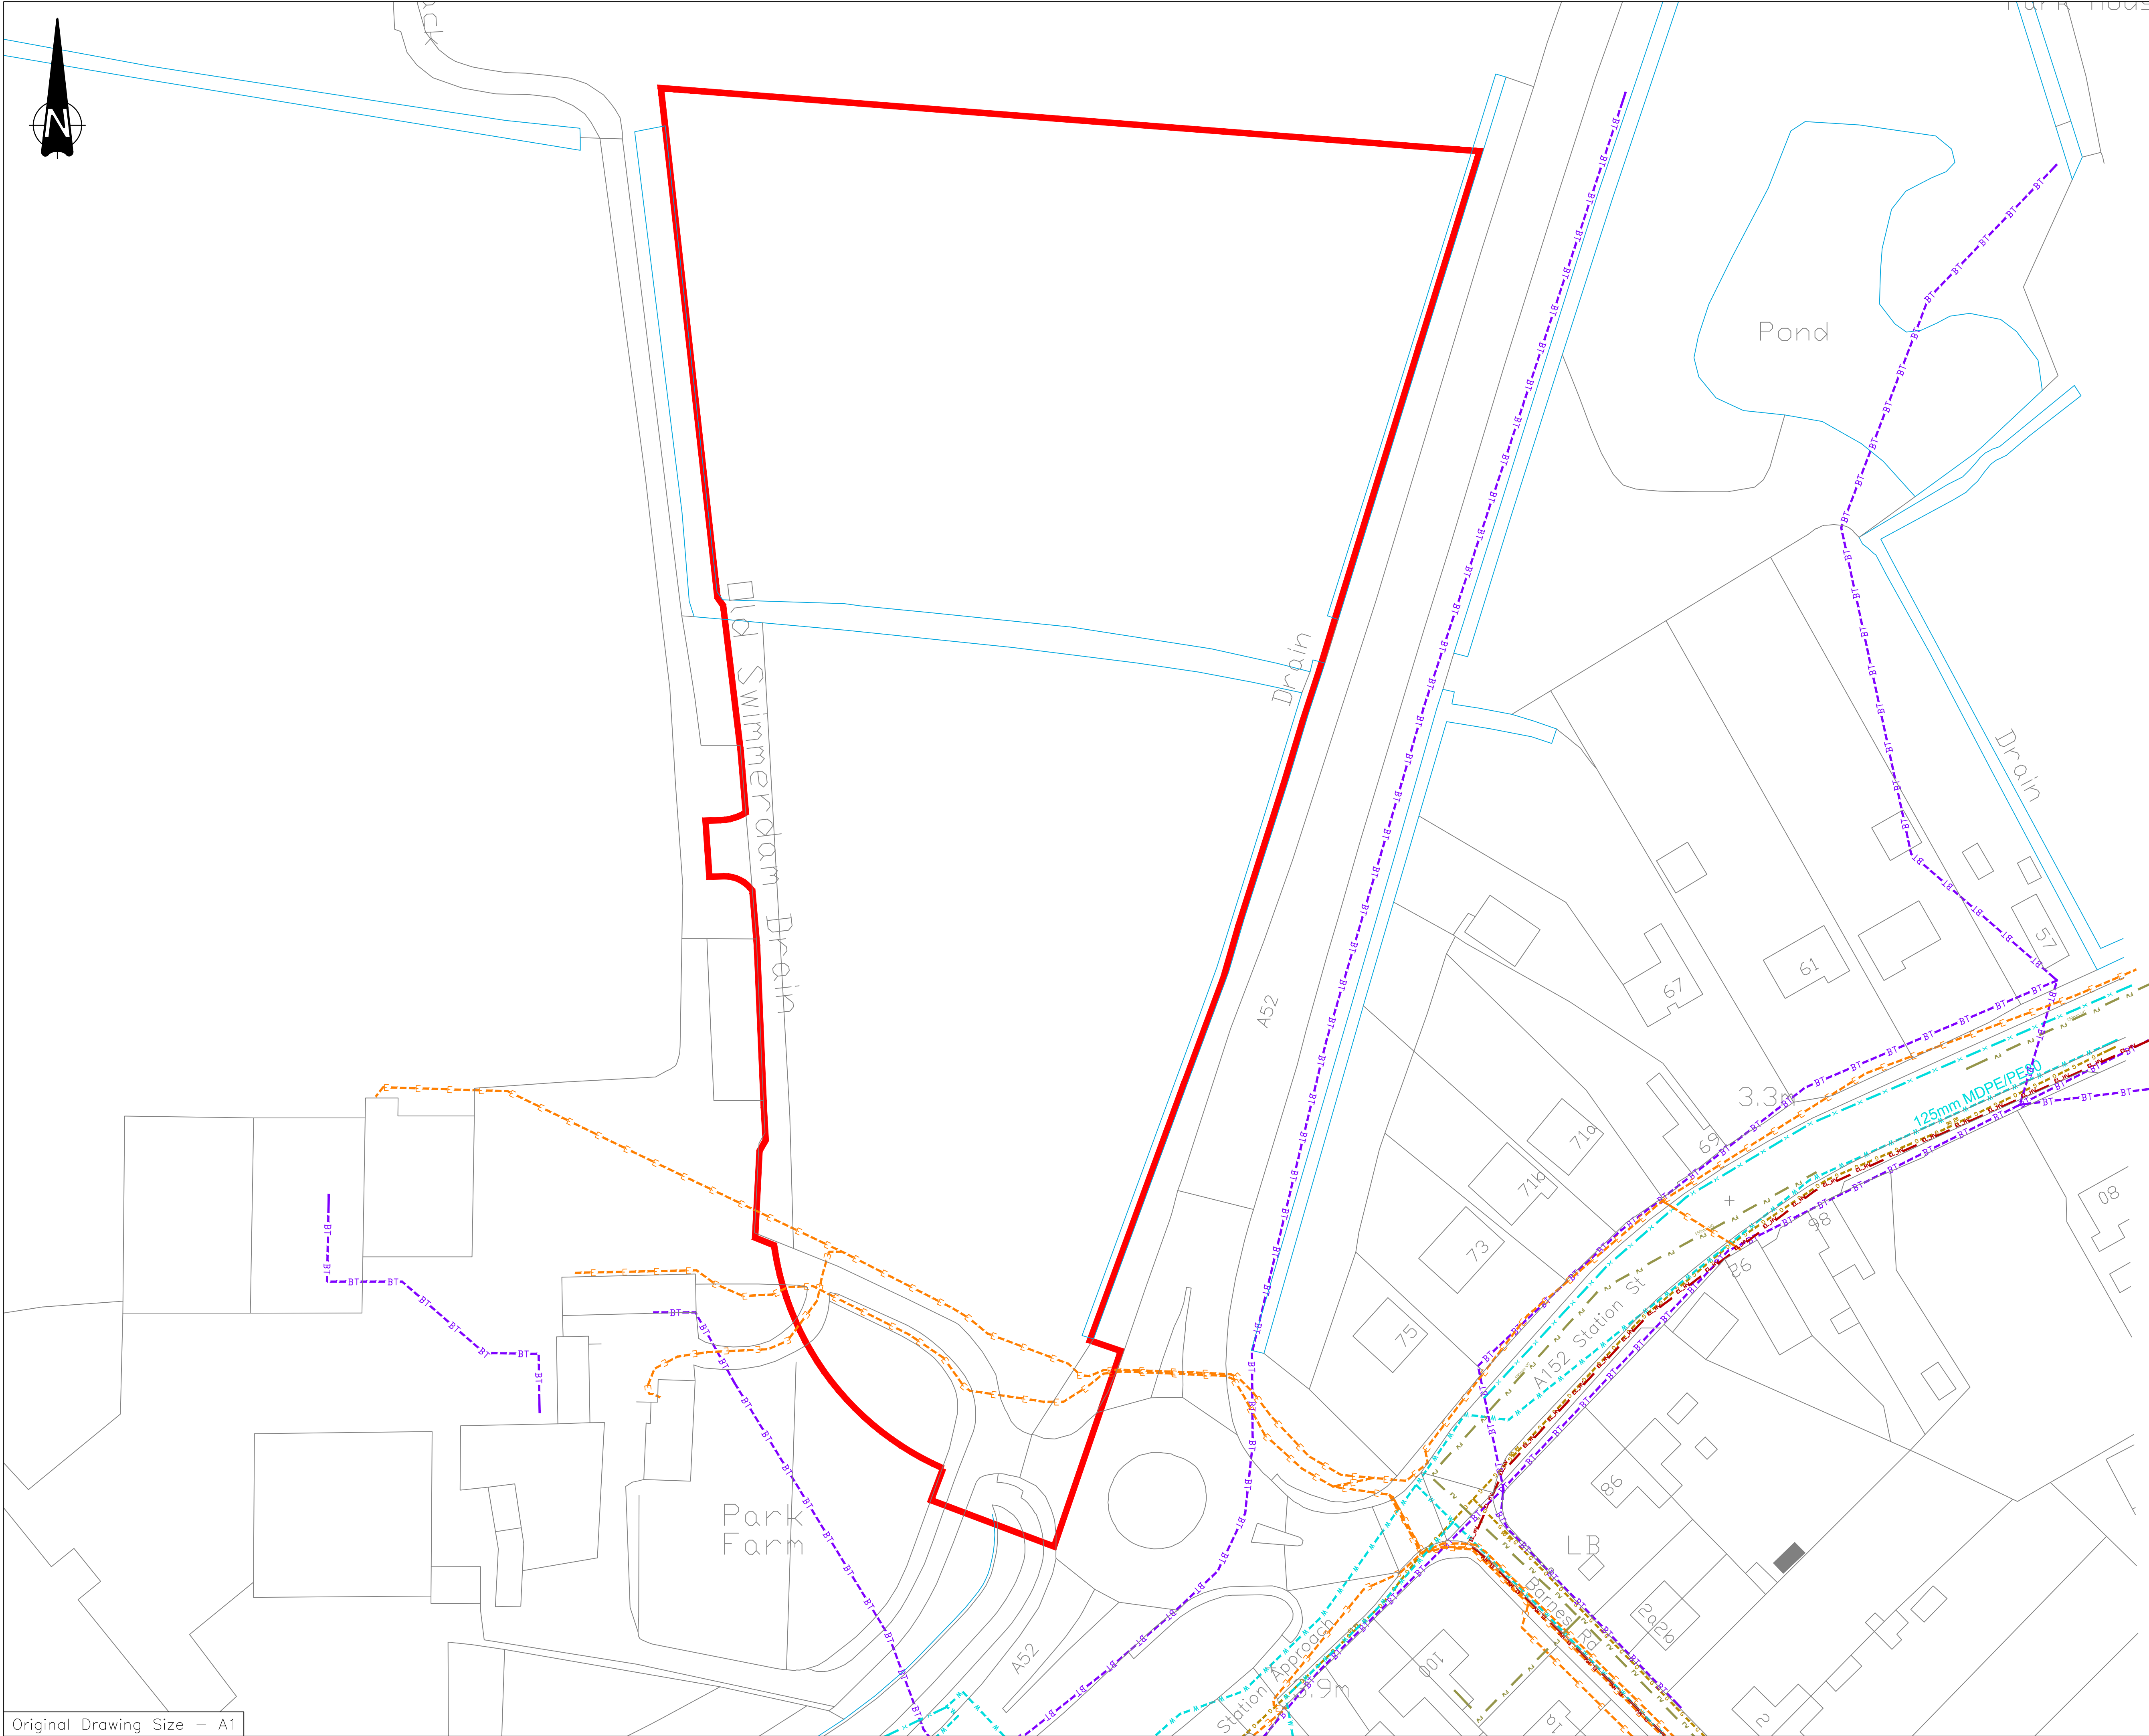

DESCRIPTION

REV	DATE	DESCRIPTION	DWN	CHK	APP
A	08/16	FIRST ISSUE	VHG		

REVISIONS

REV	DATE	DESCRIPTION	DWN	CHK	APP

NOTES:

- ALL UTILITY PLANT AND ITS LOCATION SHOWN IS BASED ON PLANS PROVIDED BY THE RELEVANT UTILITY COMPANY AND IS INDICATIVE ONLY.
- UTILITY DETAILS SHOWN ON THIS DRAWING HAVE BEEN PROVIDED IN GOOD FAITH BY EACH STATUTORY UNDERTAKER. NO LIABILITY OF ANY KIND IS ACCEPTED BY THE OPERATOR, AMEC FOSTER WHEELER, ITS AGENTS OR SERVANTS FOR ANY ERROR OR OMISSION. THE INFORMATION IS GIVEN WITHOUT OBLIGATION, OR WARRANTY AND AS A RESULT THE ACCURACY OF THE INFORMATION SHOWN CANNOT BE GUARANTEED.
- DO NOT SCALE OFF THIS DRAWING.

KEY:

	SITE BOUNDARY
	LOW PRESSURE GAS MAIN NATIONAL GAS
	WATER SUPPLY MAIN ANGLIAN WATER
	DECOMMISSIONED MAIN ANGLIAN WATER
	FOUL WATER SEWER ANGLIAN WATER
	BRITISH TELECOM LINE
	LOW VOLTAGE ELECTRICITY LINE
	WESTERN POWER DISTRIBUTION
	HIGH VOLTAGE ELECTRICITY LINE (11kV)
	WESTERN POWER DISTRIBUTION

0m 10m 20m 30m 40m

SCALE 1:500

SCALES: 1:500 @A1 / 1:1000 @A3

PROJECT TITLE:

PARK FARM, DONNINGTON
OUTLINE PLANNING APPLICATION

DRAWING TITLE:

EXISTING UTILITIES

CLIENT:

DUCHY of LANCASTER

GABLES HOUSE,
KENILWORTH ROAD,
LEAMINGTON SPA,
WARWICKSHIRE
CV32 6JX
TEL: (01926) 439000

amec
foster
wheeler

DRAWING No.

38780/LEA/CVD/10

REV.

A