
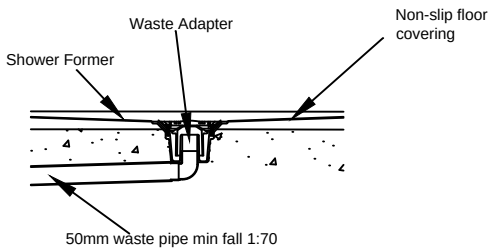


Do Not Scale From This Drawing

This drawing is copyright and may not be altered , traced, photographed or copied without prior written consent from South Holland Building Consultancy.

The contractor should check all dimensions on site prior to commencement and report any discrepancies to the Draftsperon.

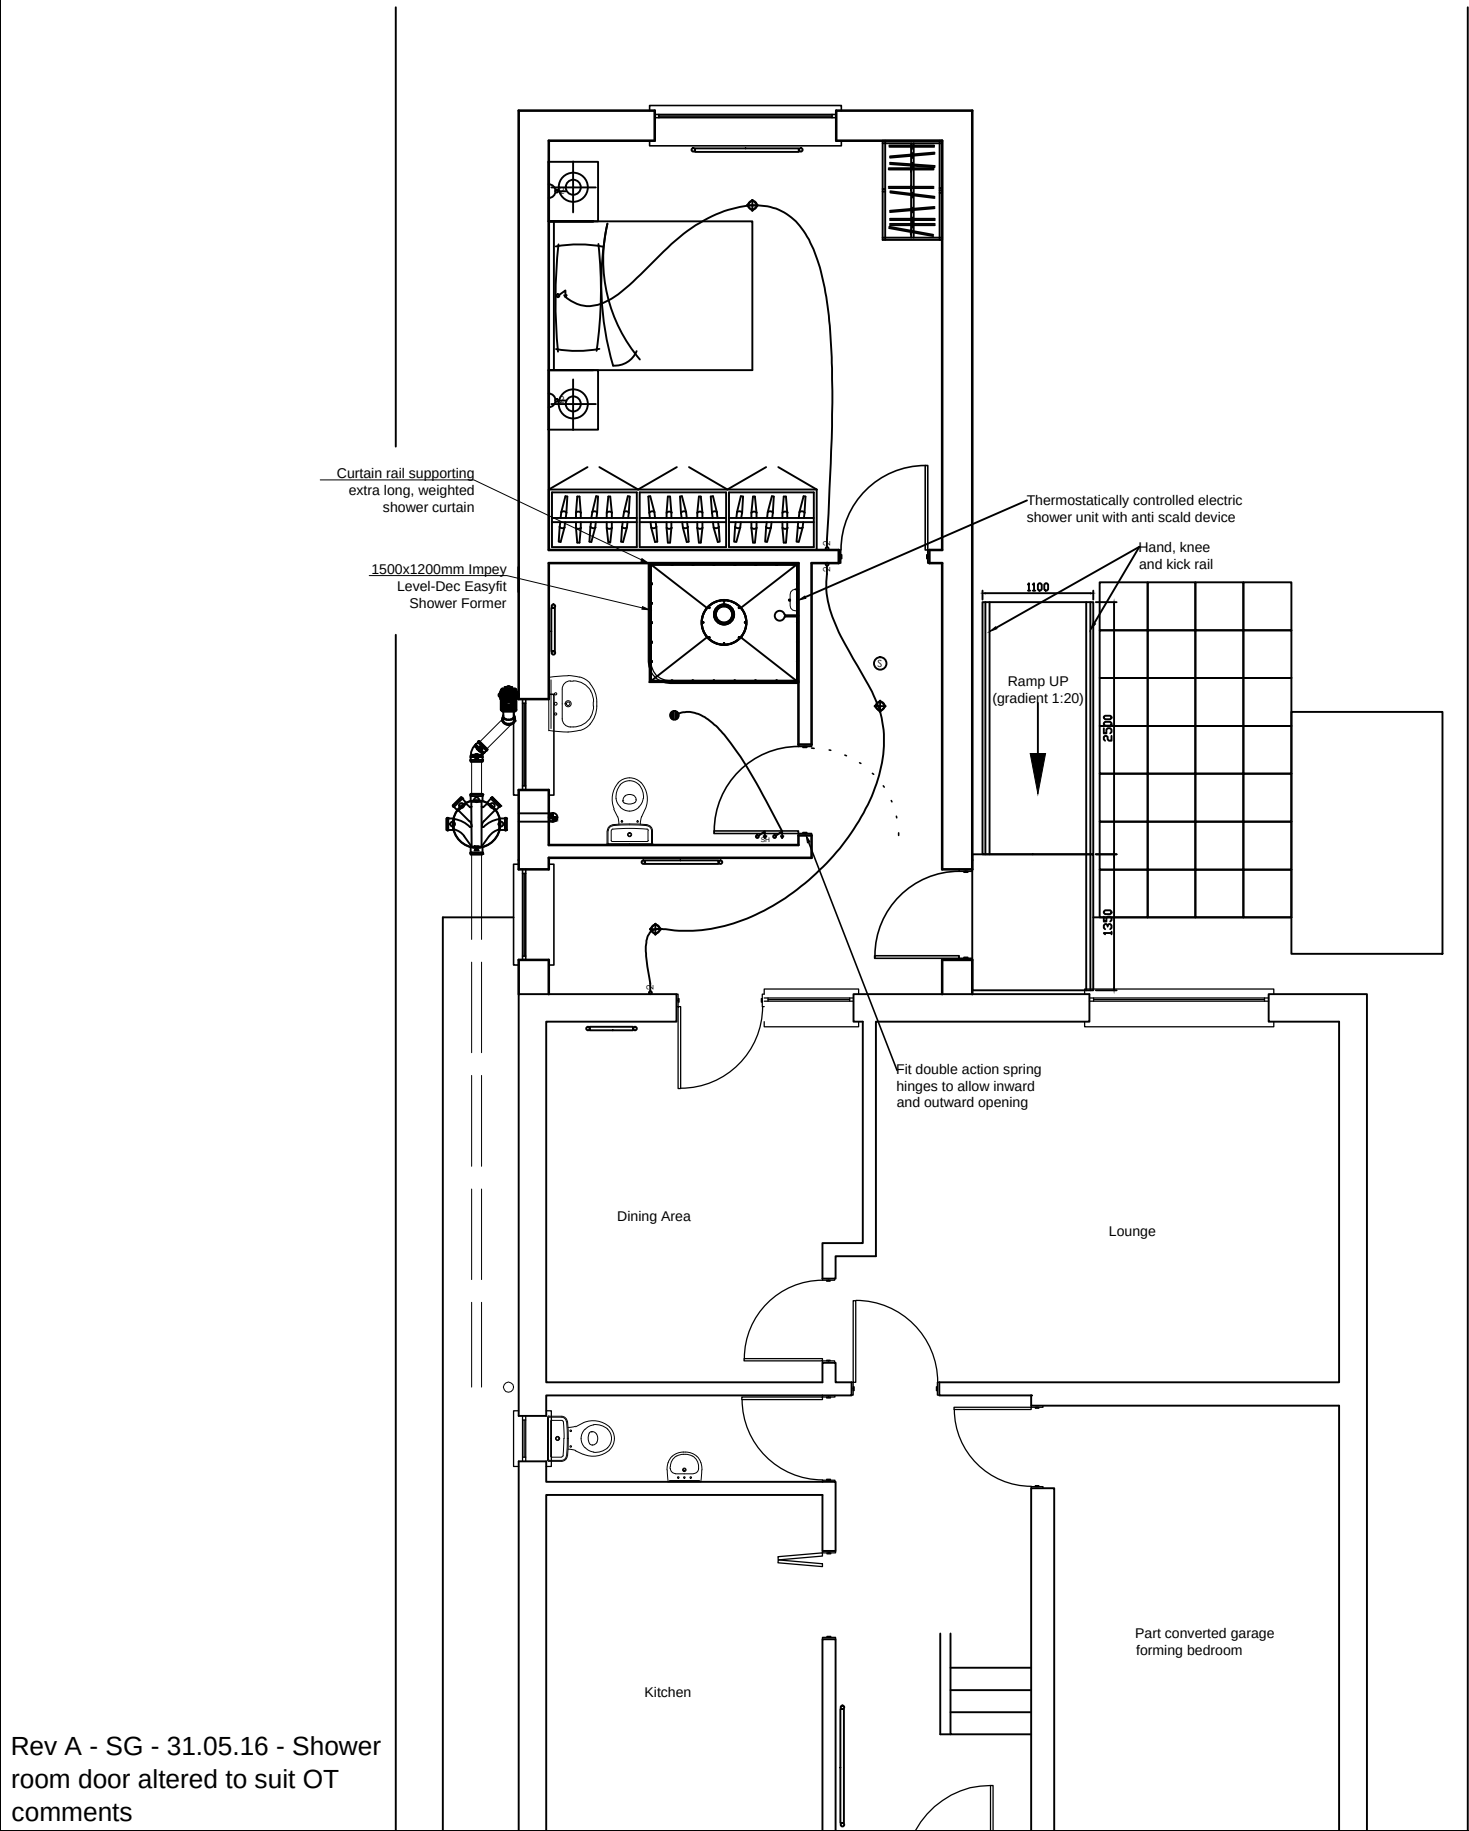

Scale 1:20

ELECTRICAL SYMBOLS KEY

- CU CONSUMER UNIT
- DOUBLE SWITCHED WALL SOCKET
- 1GANG 2 WAY LIGHT SWITCH
- 1 GANG PULL CORD LIGHT SWITCH

- SH SHOWER ISOLATOR PULL CORD SWITCH
- Light Point - Pendant Holder (4 inch)
- MECHANICAL EXTRACT FAN
- INTERNAL LIGHT - BULKHEAD TYPE
- COMBINED SMOKE/HEAT DETECTOR AND FIRE ALARM SOUNDER



South Holland Building Consultancy  
Council Offices  
Priory Road  
Spalding  
Lincs  
PE11 2XE  
01775 764447

Project : Bedroom and Level Access Shower Extension  
Address 114 Siltside, Gosberton Risegate  
Client : Mr P Twell  
Scale : 1 : 75  
Date : 1st February 2016  
Title: Proposed Ground Floor Plan  
Dwg No : 707/Grant/02 A Drawn : SG