


Ref: 0183-11
 08 MAR 2011
 SHDC
 Planning & Development

DO NOT SCALE FROM THIS DRAWING
 THE CONTRACTOR IS TO CHECK ALL
 DIMENSIONS ON SITE AND REPORT
 DISCREPANCIES TO THE ARCHITECT
 THIS DRAWING IS CORRECT



- Existing services
- HV High Voltage cable
 - Electric Cable
 - 63mm MOPE water pt
 - 80mm MOPE gas pipe
 - Steam Duct

NOTE - this is not a complete route of all services only those taken from some record drawings - therefore the Contractor is to carry out all necessary check/ scans

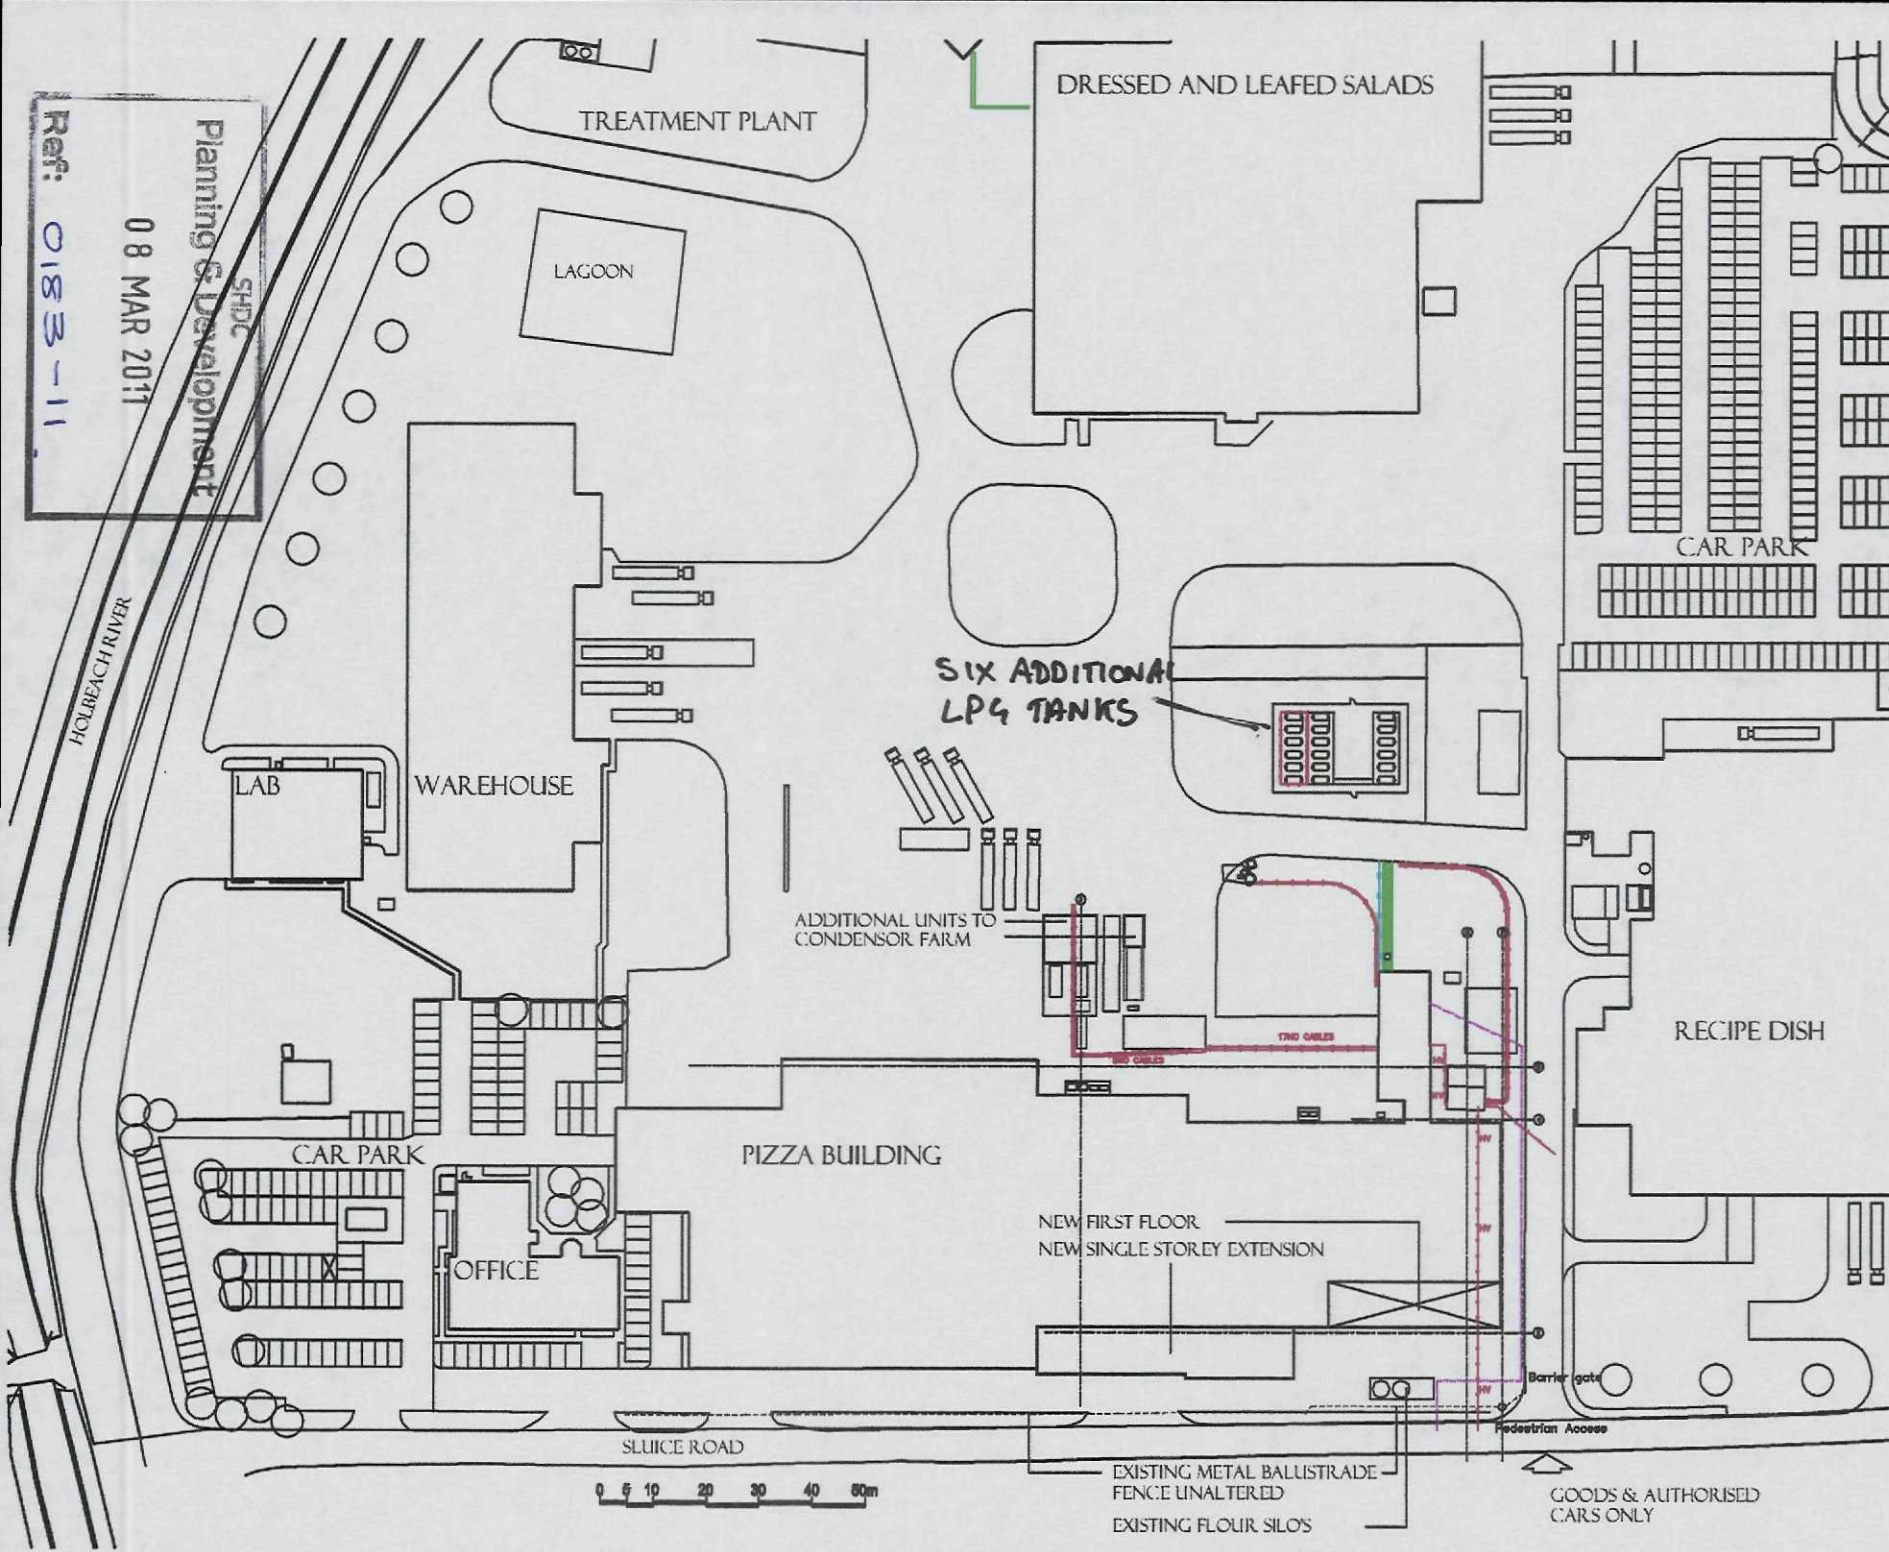

SIX ADDITIONAL
 LP4 TANKS

ADDITIONAL UNITS TO
 CONDENSOR FARM

NEW FIRST FLOOR
 NEW SINGLE STOREY EXTENSION

Barrier gate
 Pedestrian Access

EXISTING METAL BALUSTRADE
 FENCE UNALTERED
 EXISTING FLOUR SILOS

GOODS & AUTHORISED
 CARS ONLY


DATE	11/03/11	DATE OF DESIGN CHECKED + OK	11/03/11
DESIGNED BY	ARCTICA	DESIGNED FOR	BAKKAHOR HOLBEACH
DRAWN BY	ARCTICA	CHECKED BY	ARCTICA
APPROVED BY	ARCTICA	APPROVED FOR	ARCTICA
DATE	11/03/11	DATE	11/03/11

ARCTICA
 ARCHITECTURAL PROJECT MANAGEMENT
 Telephone 01780 400000 Fax 01780 400010
 www.arctica.co.uk

PROJECT
 BAKKAHOR HOLBEACH
 THE PIZZA BUILDING

DRAWING
 PROPOSED
 SITE PLAN

A1 SCALE	A3 SCALE	JOB
1:500	1:1000	10-04
NUMBER	REV	
108	C.C.	

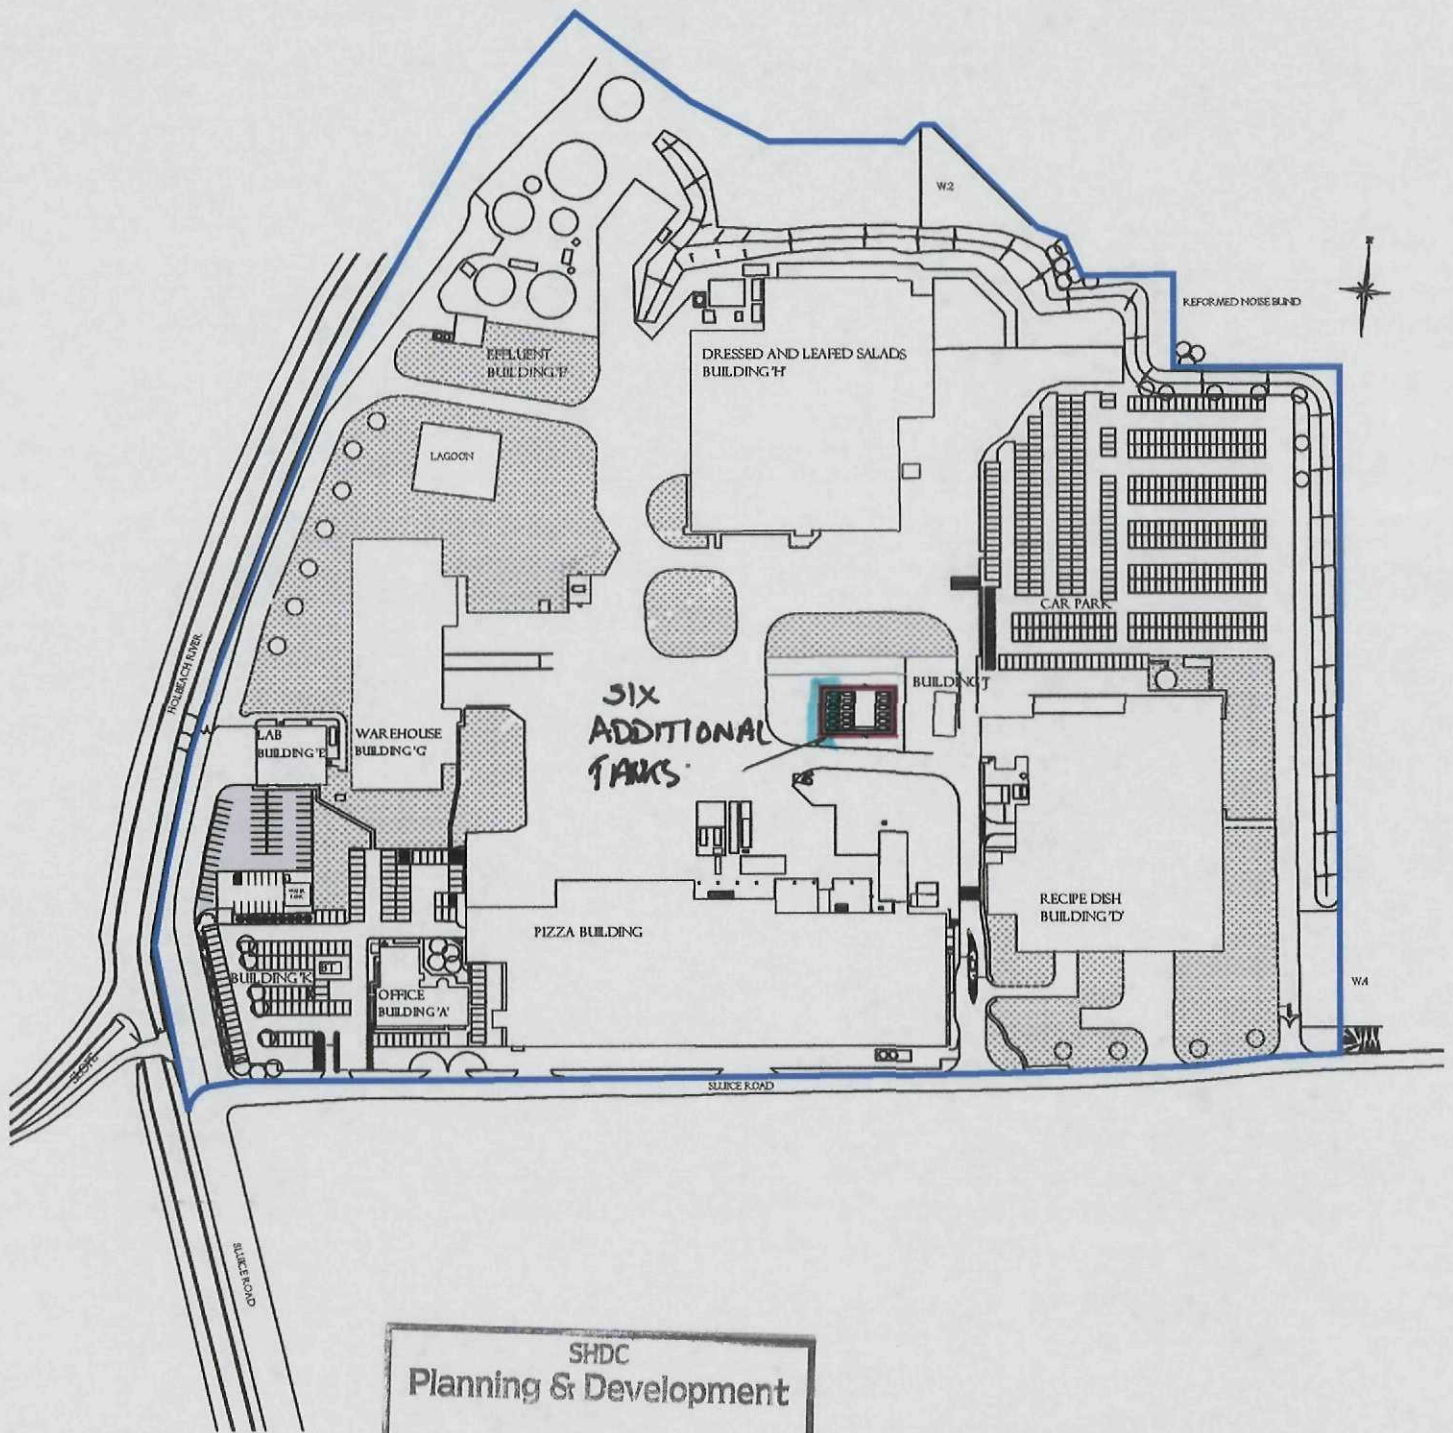

SHDC
Planning & Development
08 MAR 2011
Ref: 0183-11.

B	17/03/11	OF	OLD TANK AREA OVERLAP	
A	17/03/11	OF	PIZZA & OFFICE	
	24/03/11	OF	PIZZA BUILD	
Issue	date	drawn	notes	check

PROJECT
BAKKAVOR PIZZERIA
HOLBEACH ST MARKS

DRAWING
SITE
LOCATION PLAN

ARCTICA
ARCHITECTURE • PROJECTS • PROJECT MANAGEMENT
Telephone 01780 482200 Fax 01780 480716
succeed@arctica.co.uk

DO NOT SCALE FROM THIS DRAWING
THE CONTRACTOR IS TO CHECK ALL
DIMENSIONS ON SITE AND REPORT
DISCREPANCIES TO THE ARCHITECT
THIS DRAWING IS COPYRIGHT

SCALE
1/2500 @ A4
NUMBER
109

JOB
10-04
REV
B