


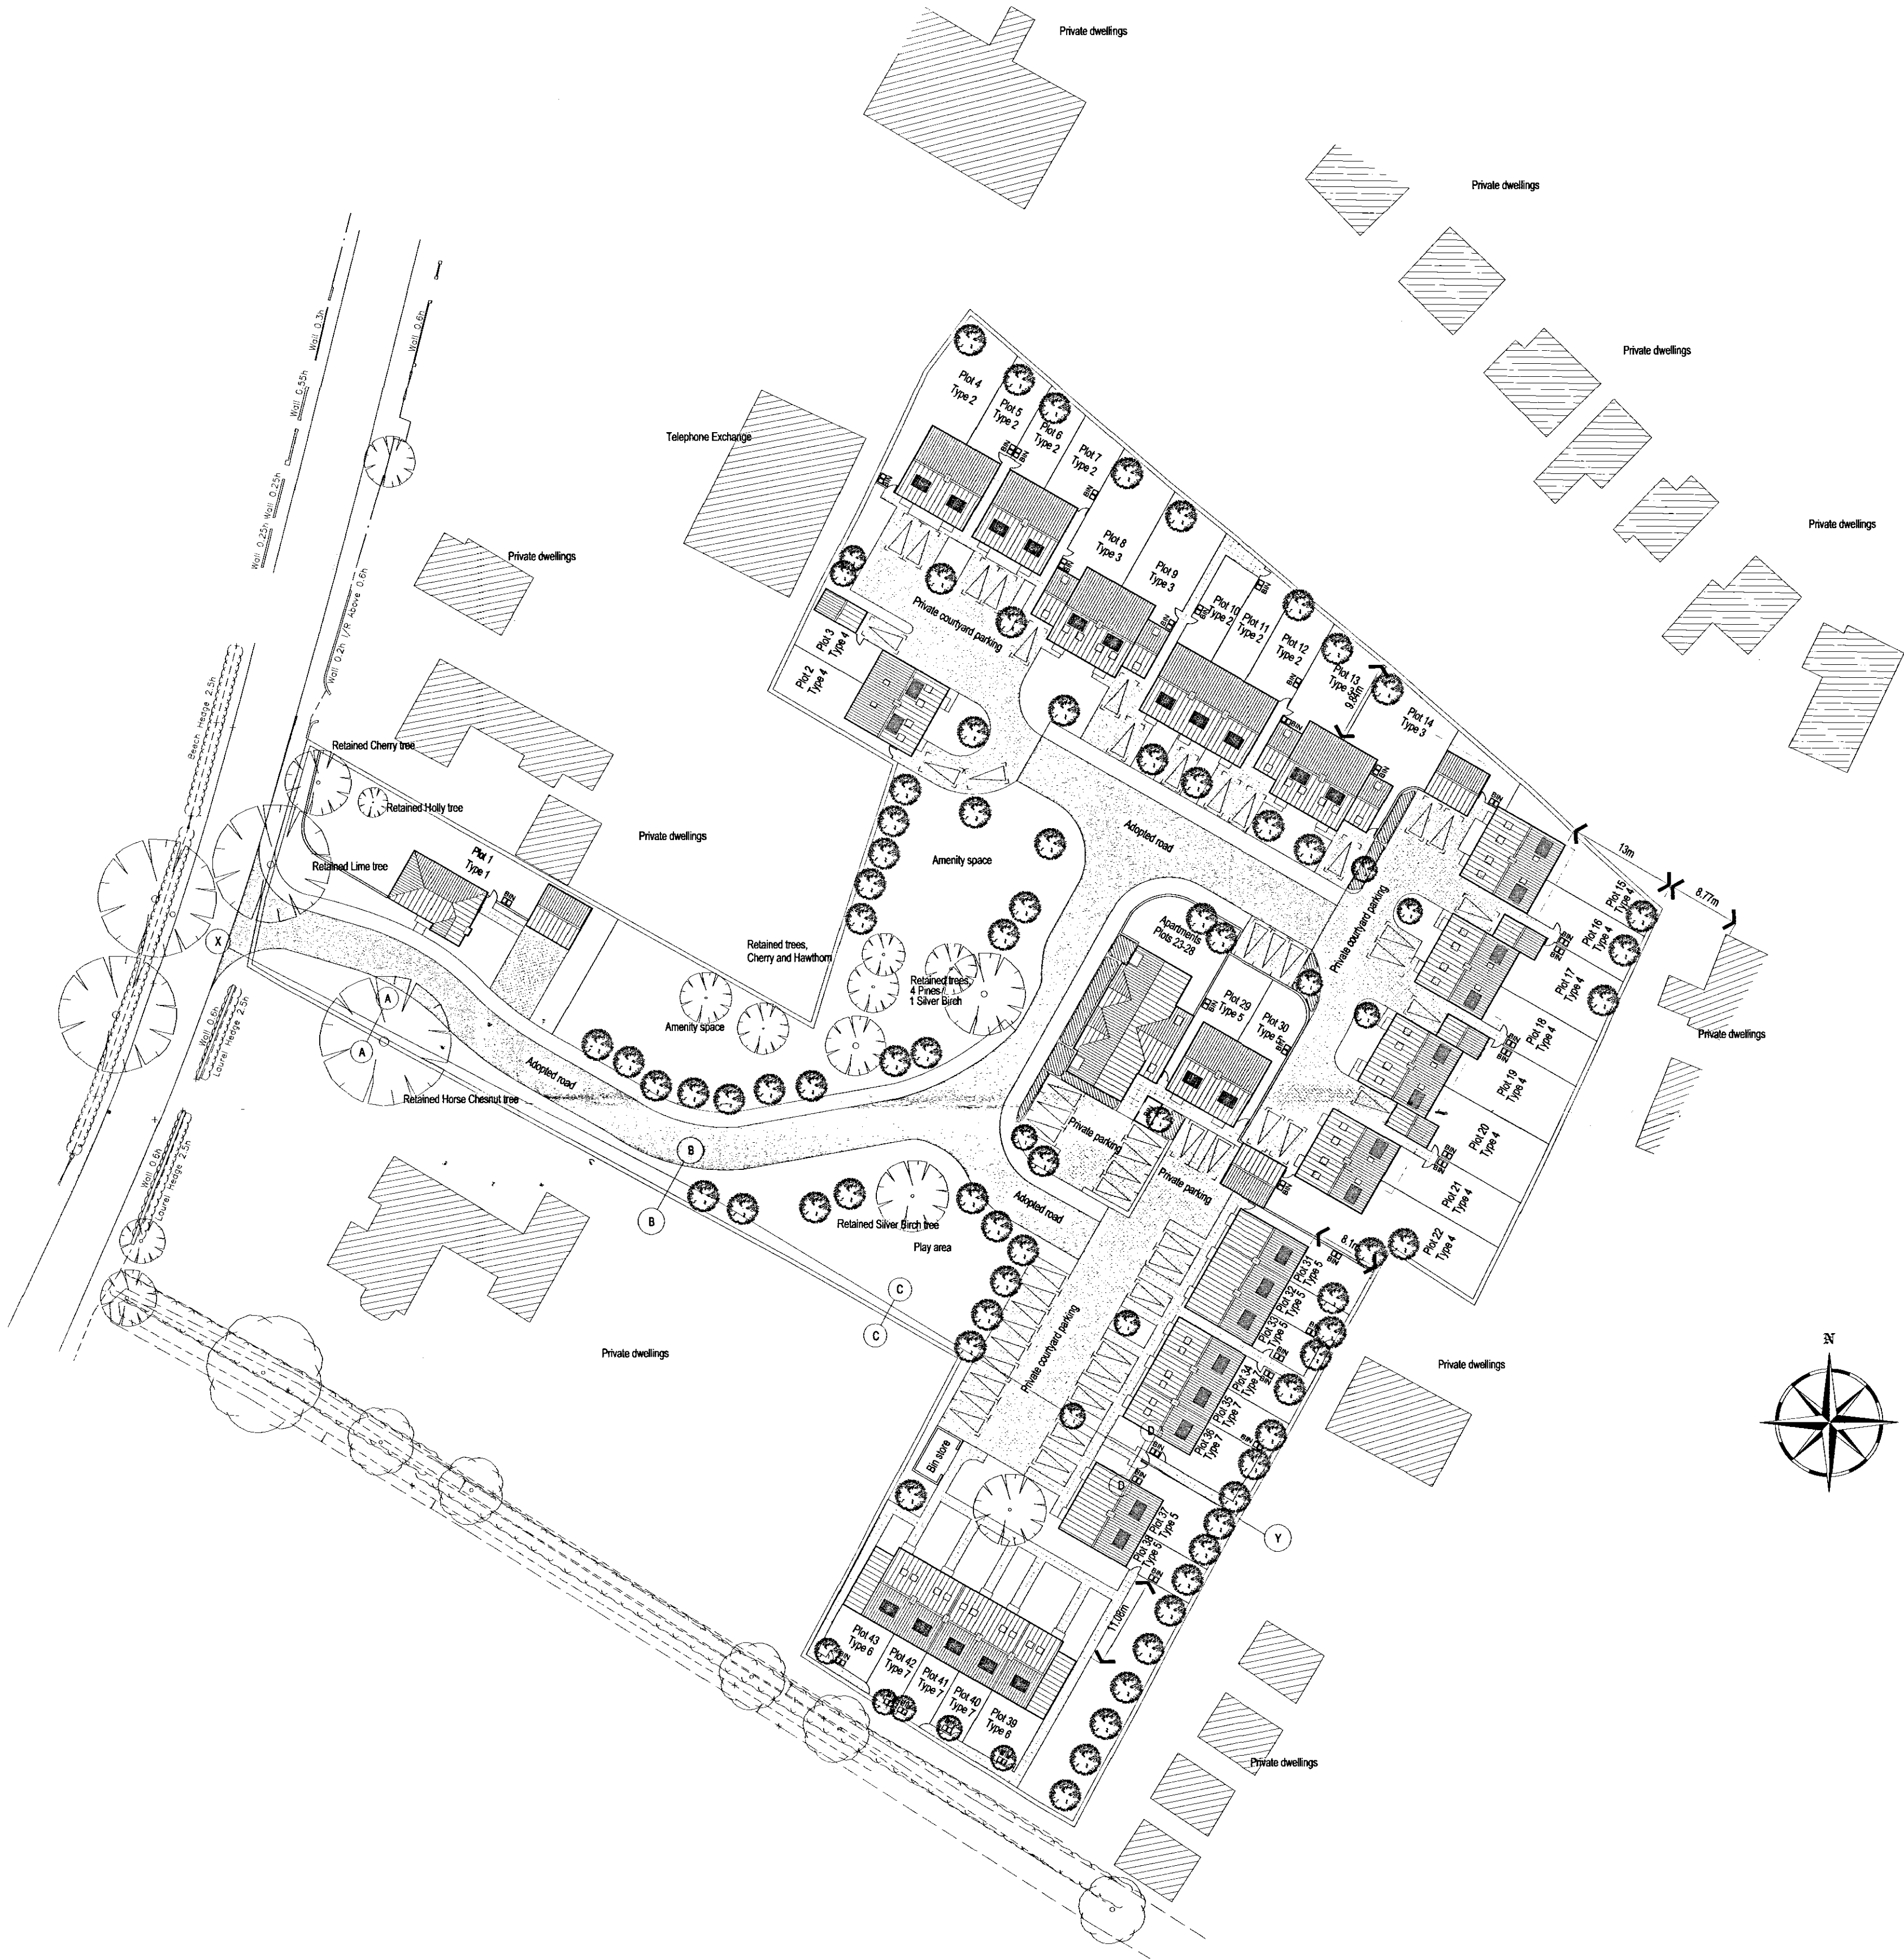

KEY	
	Outline of planning approved buildings
	Position of water mains pipe



Client:
Hill Residential Ltd
The Mill Building
Harston Mill, Cambridgeshire

Project:
Barrington Gate
Holbeach

Drawing:
Site Plan

Scale: 1/500 @ A1	Date: 02/01/08		
Drawn By: MC	Checked By:	Drawing No: 018-001	Rev. No:
CAD Ref:			

THIS DRAWING IS A COPYRIGHT
All dimensions to be checked on site or in the workshop before work commences.
Only figured dimensions to be worked to. Any discrepancies to be reported to the Architect.