


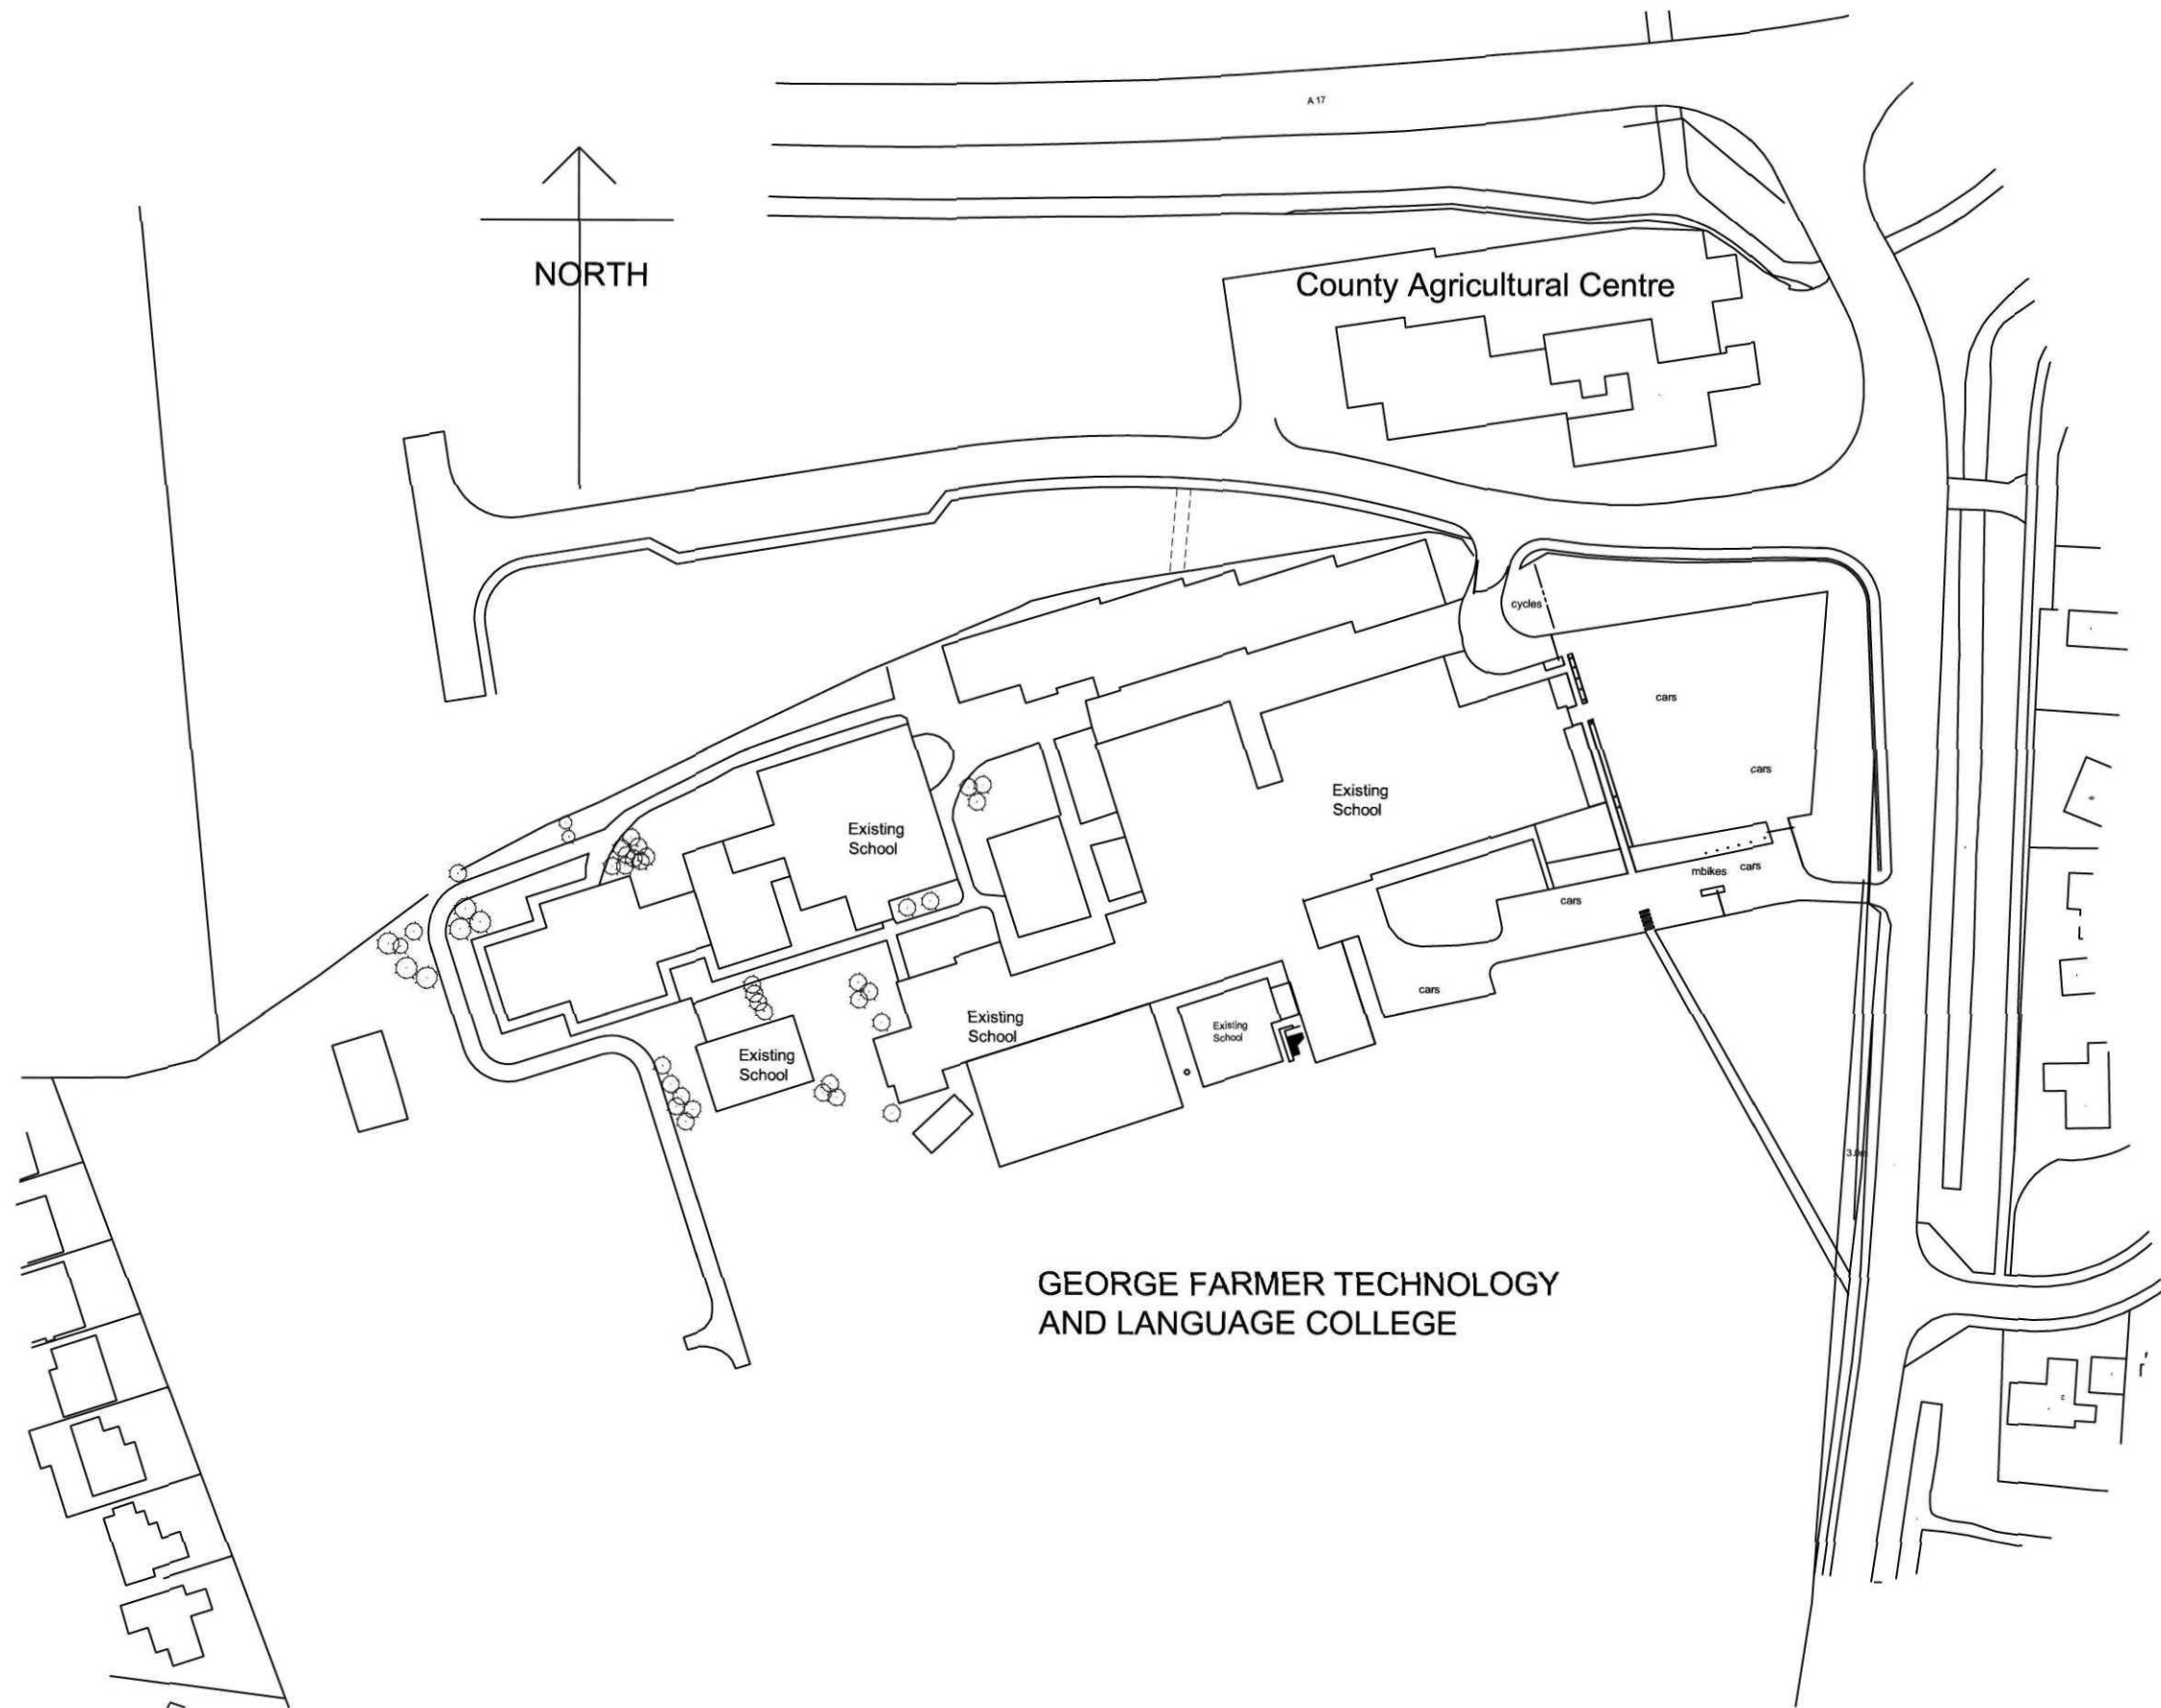

Client	George Farmer Technology College	Scale	1:1250
Project	PV installation to the 6th form and Technology Building at The George Farmer Technology College, Park Road, Holbeach, Lincolnshire.	Drawn	CB
		Date	JULY 11
		Drawing number	GFTC/PV/2
Drawing Title	SITE PLAN		