
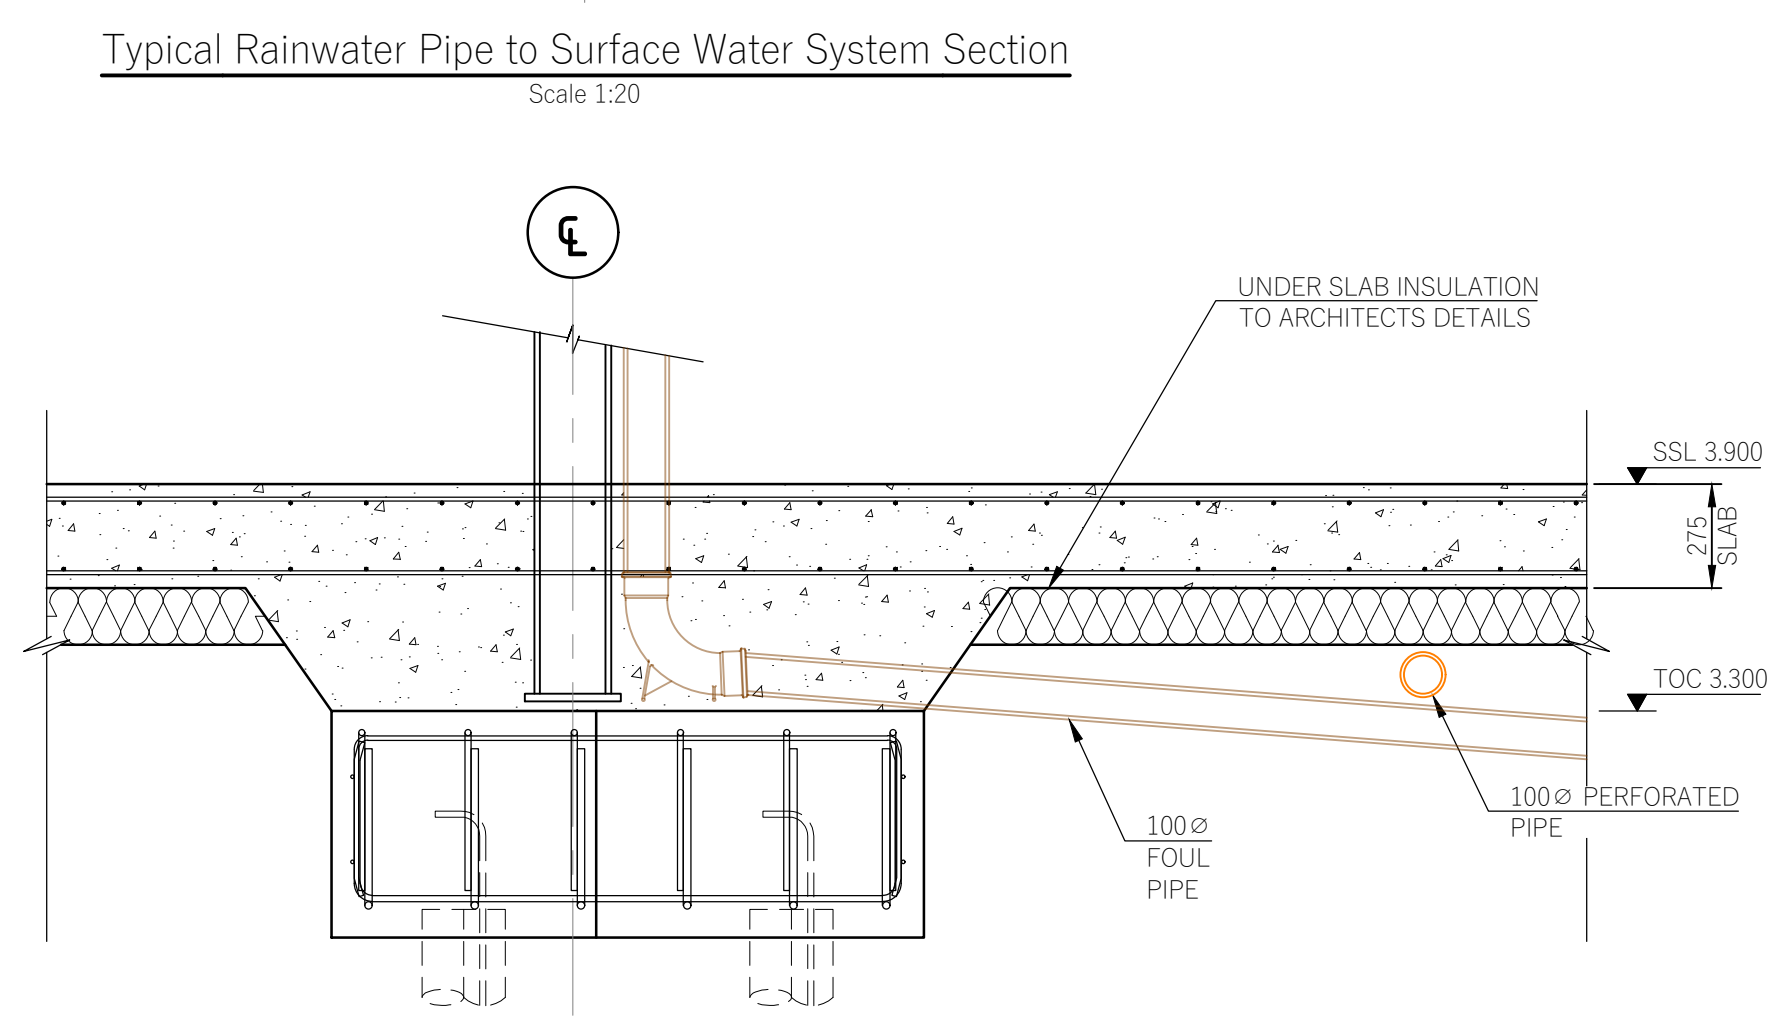
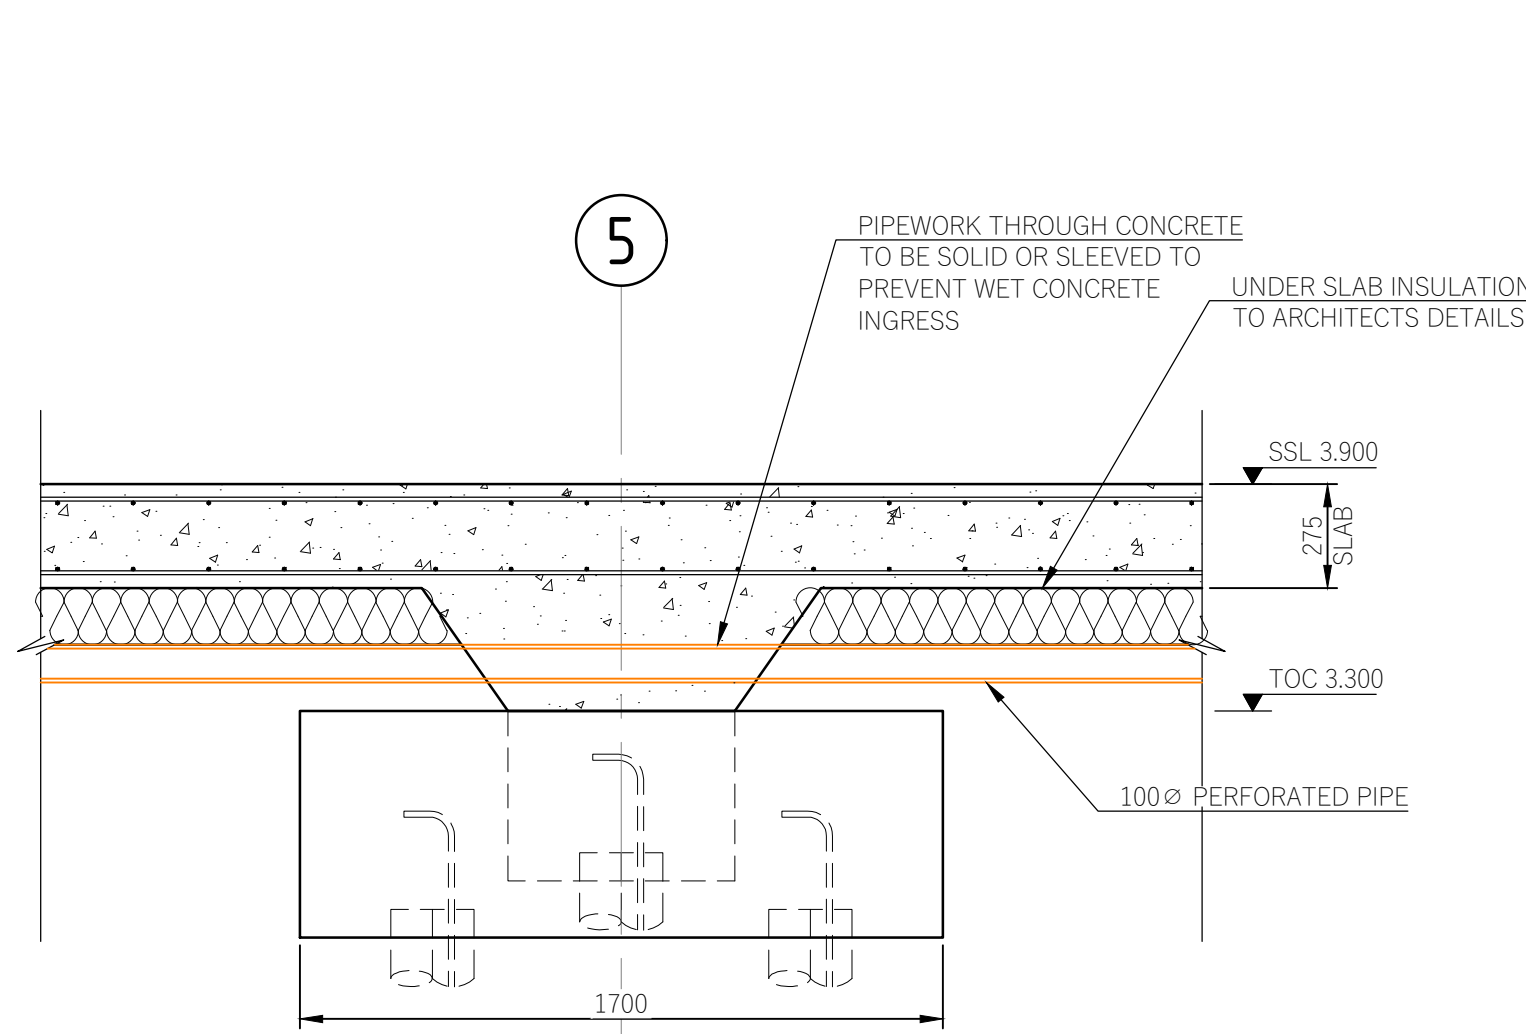
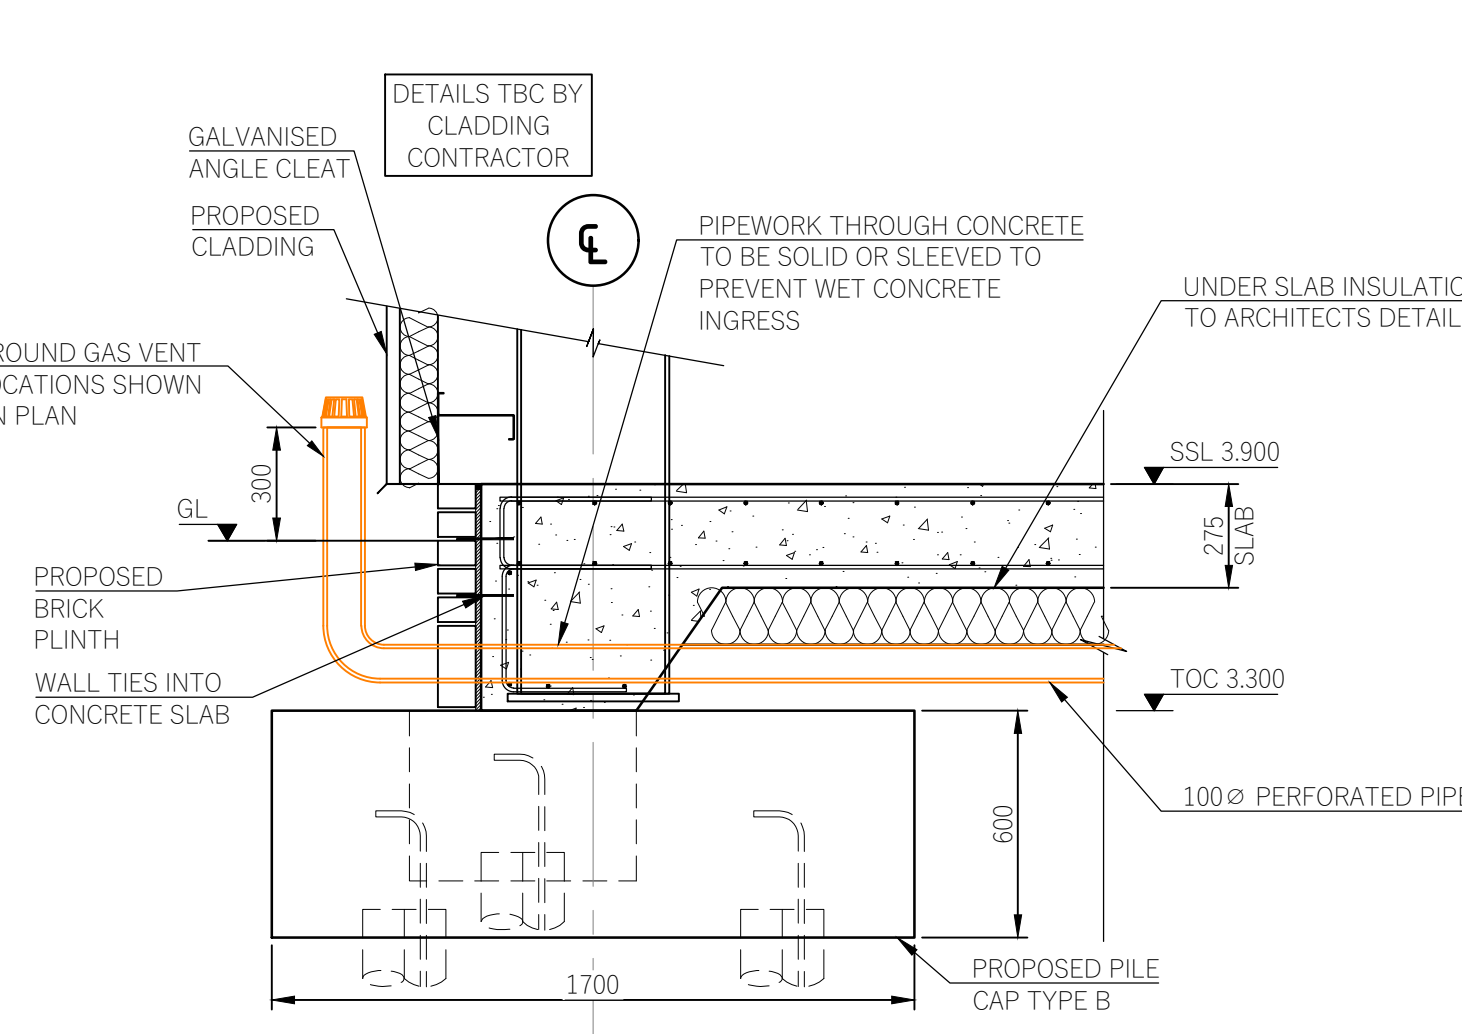
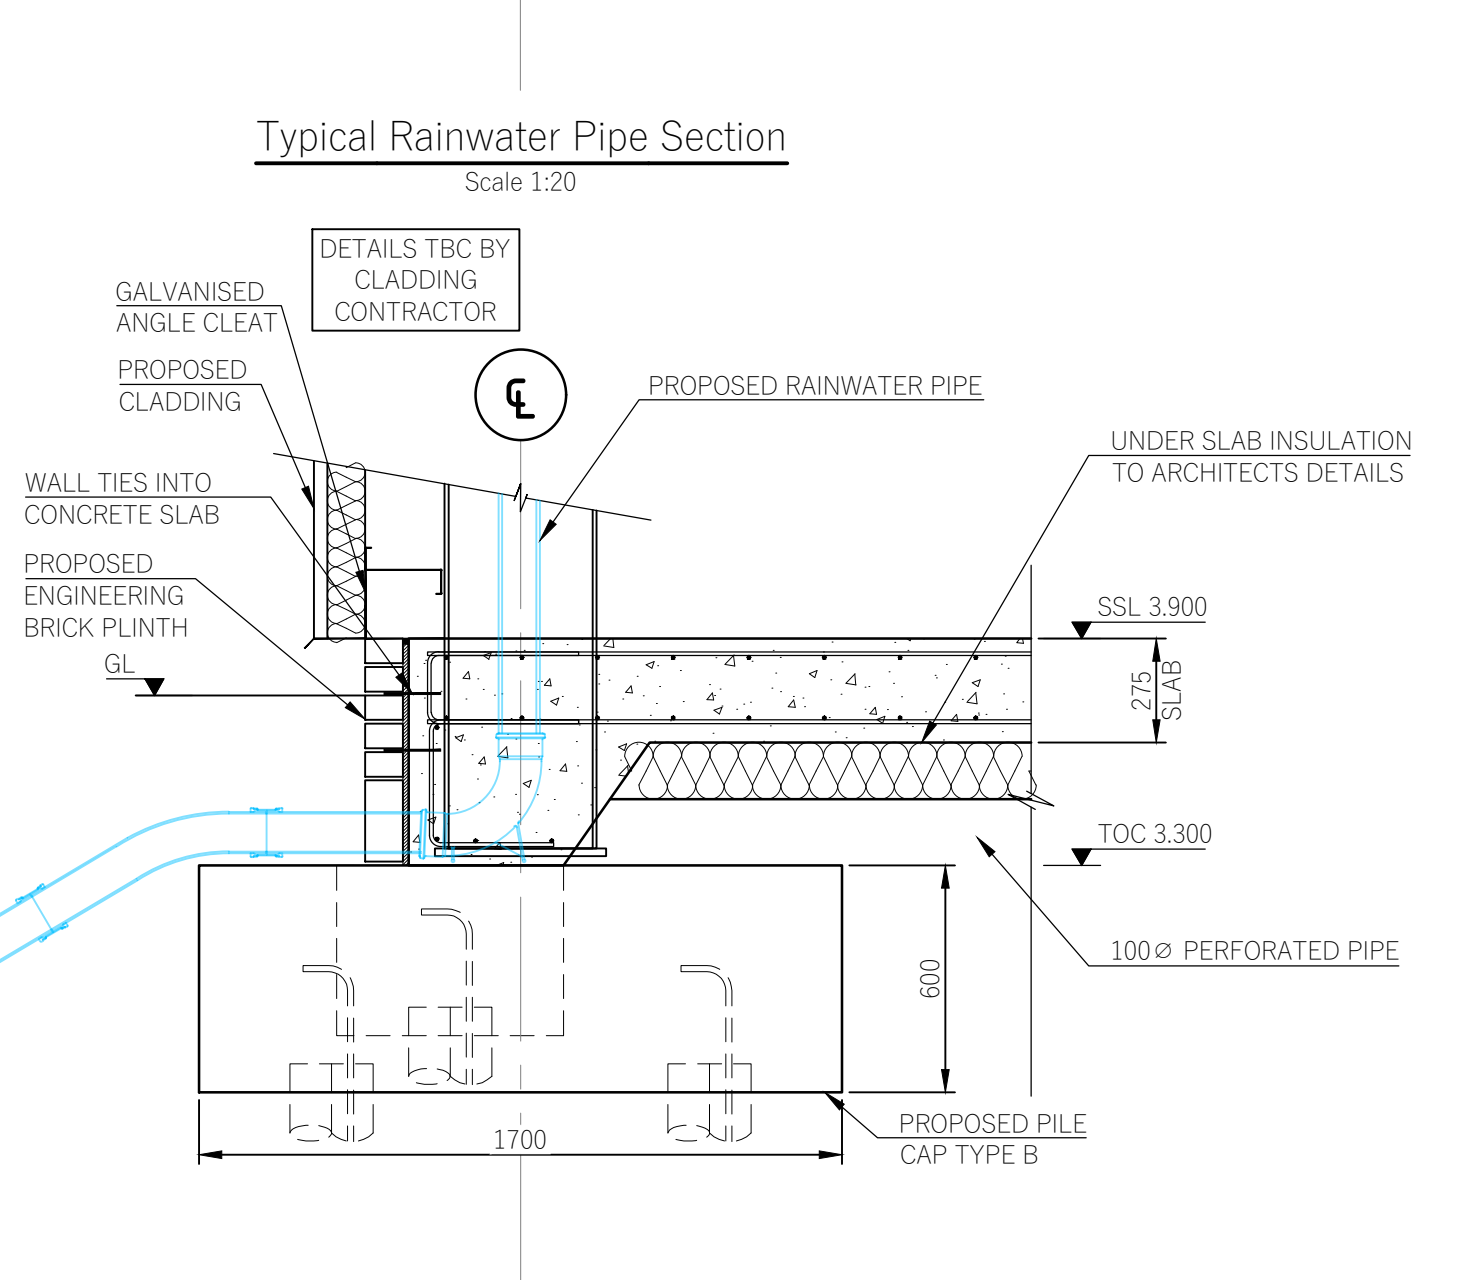
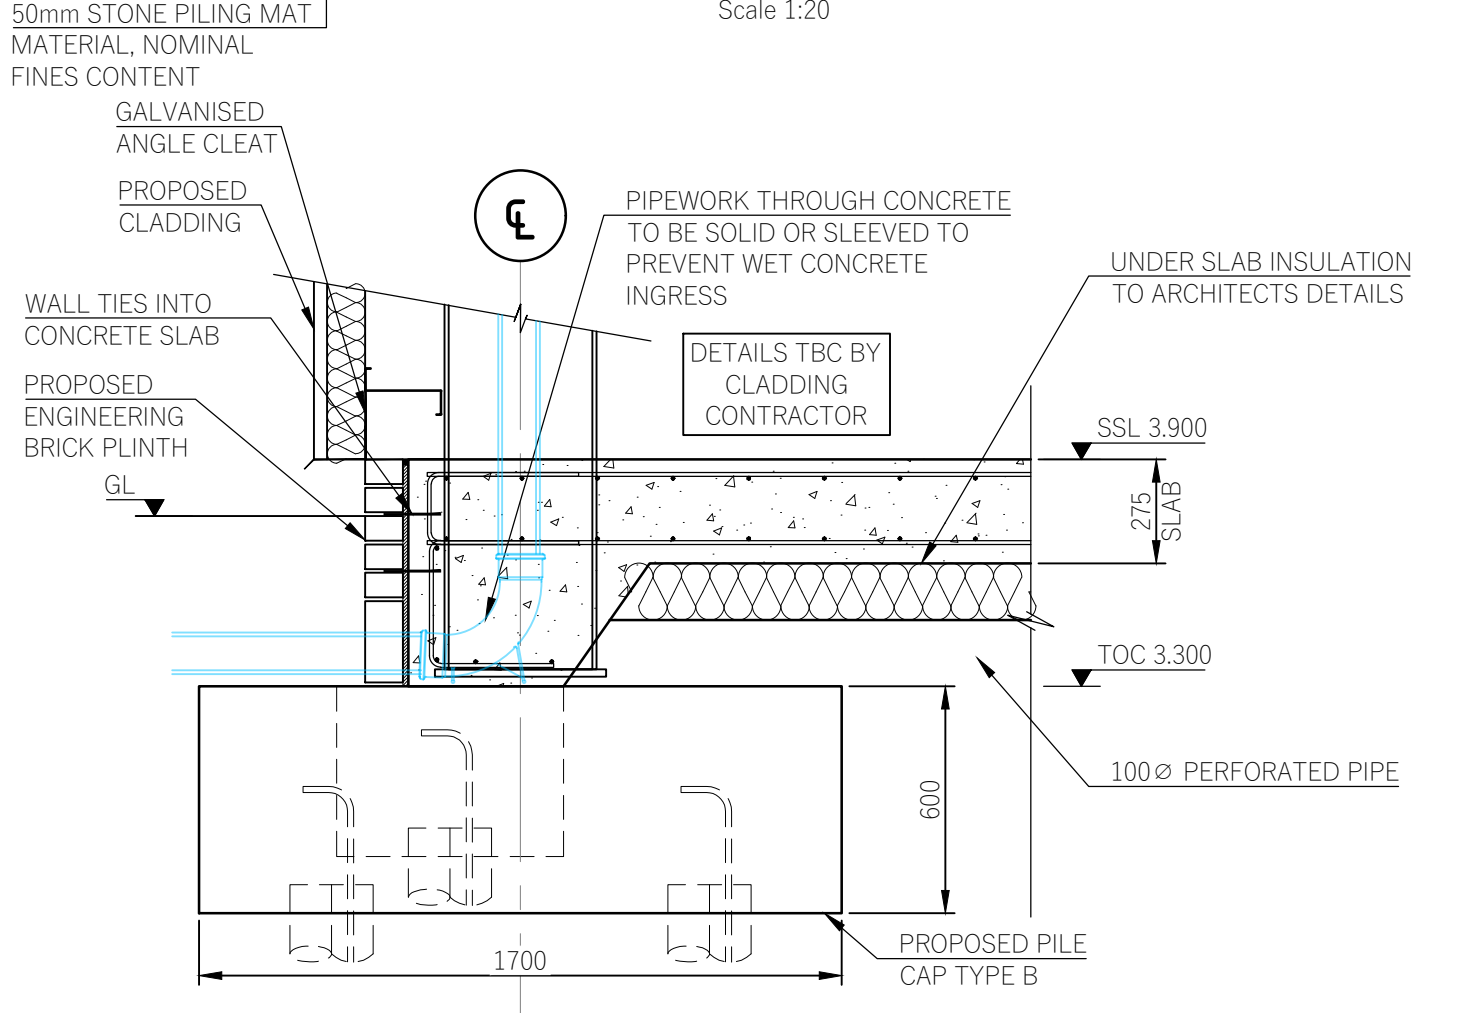
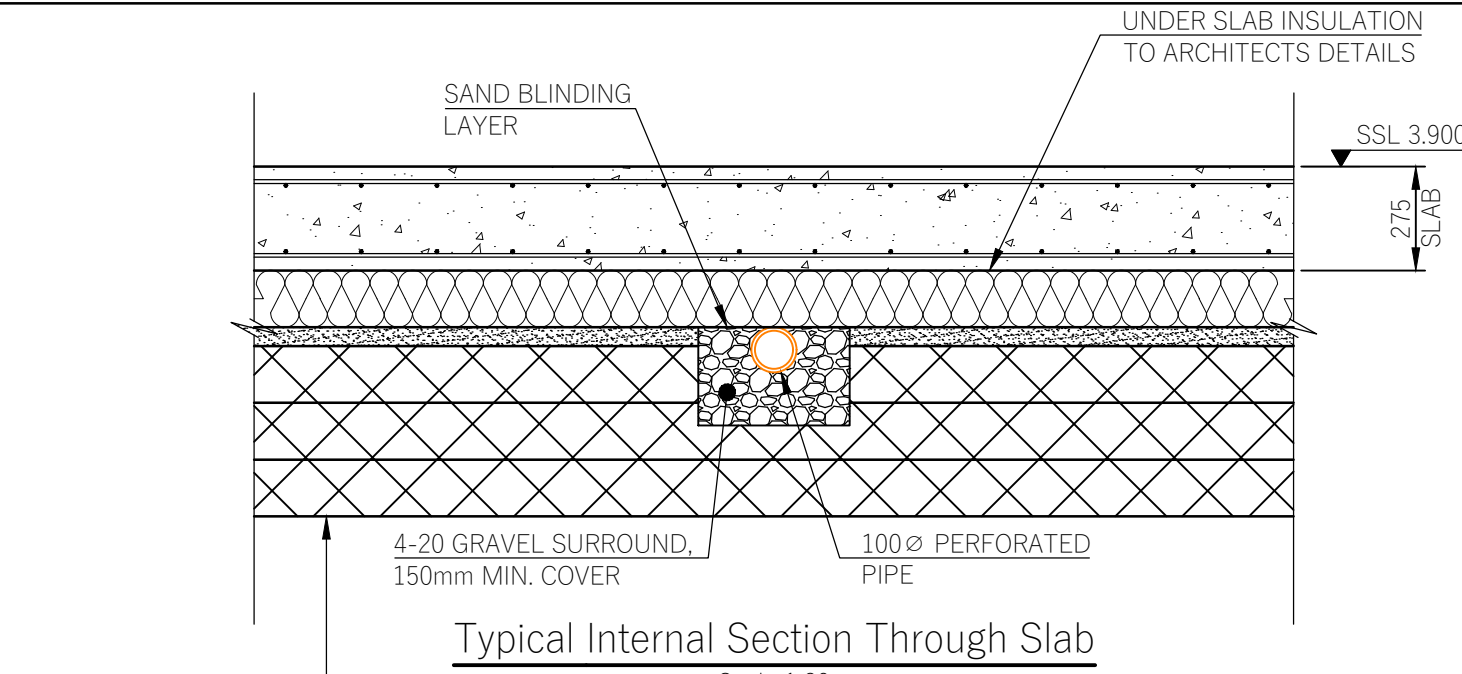


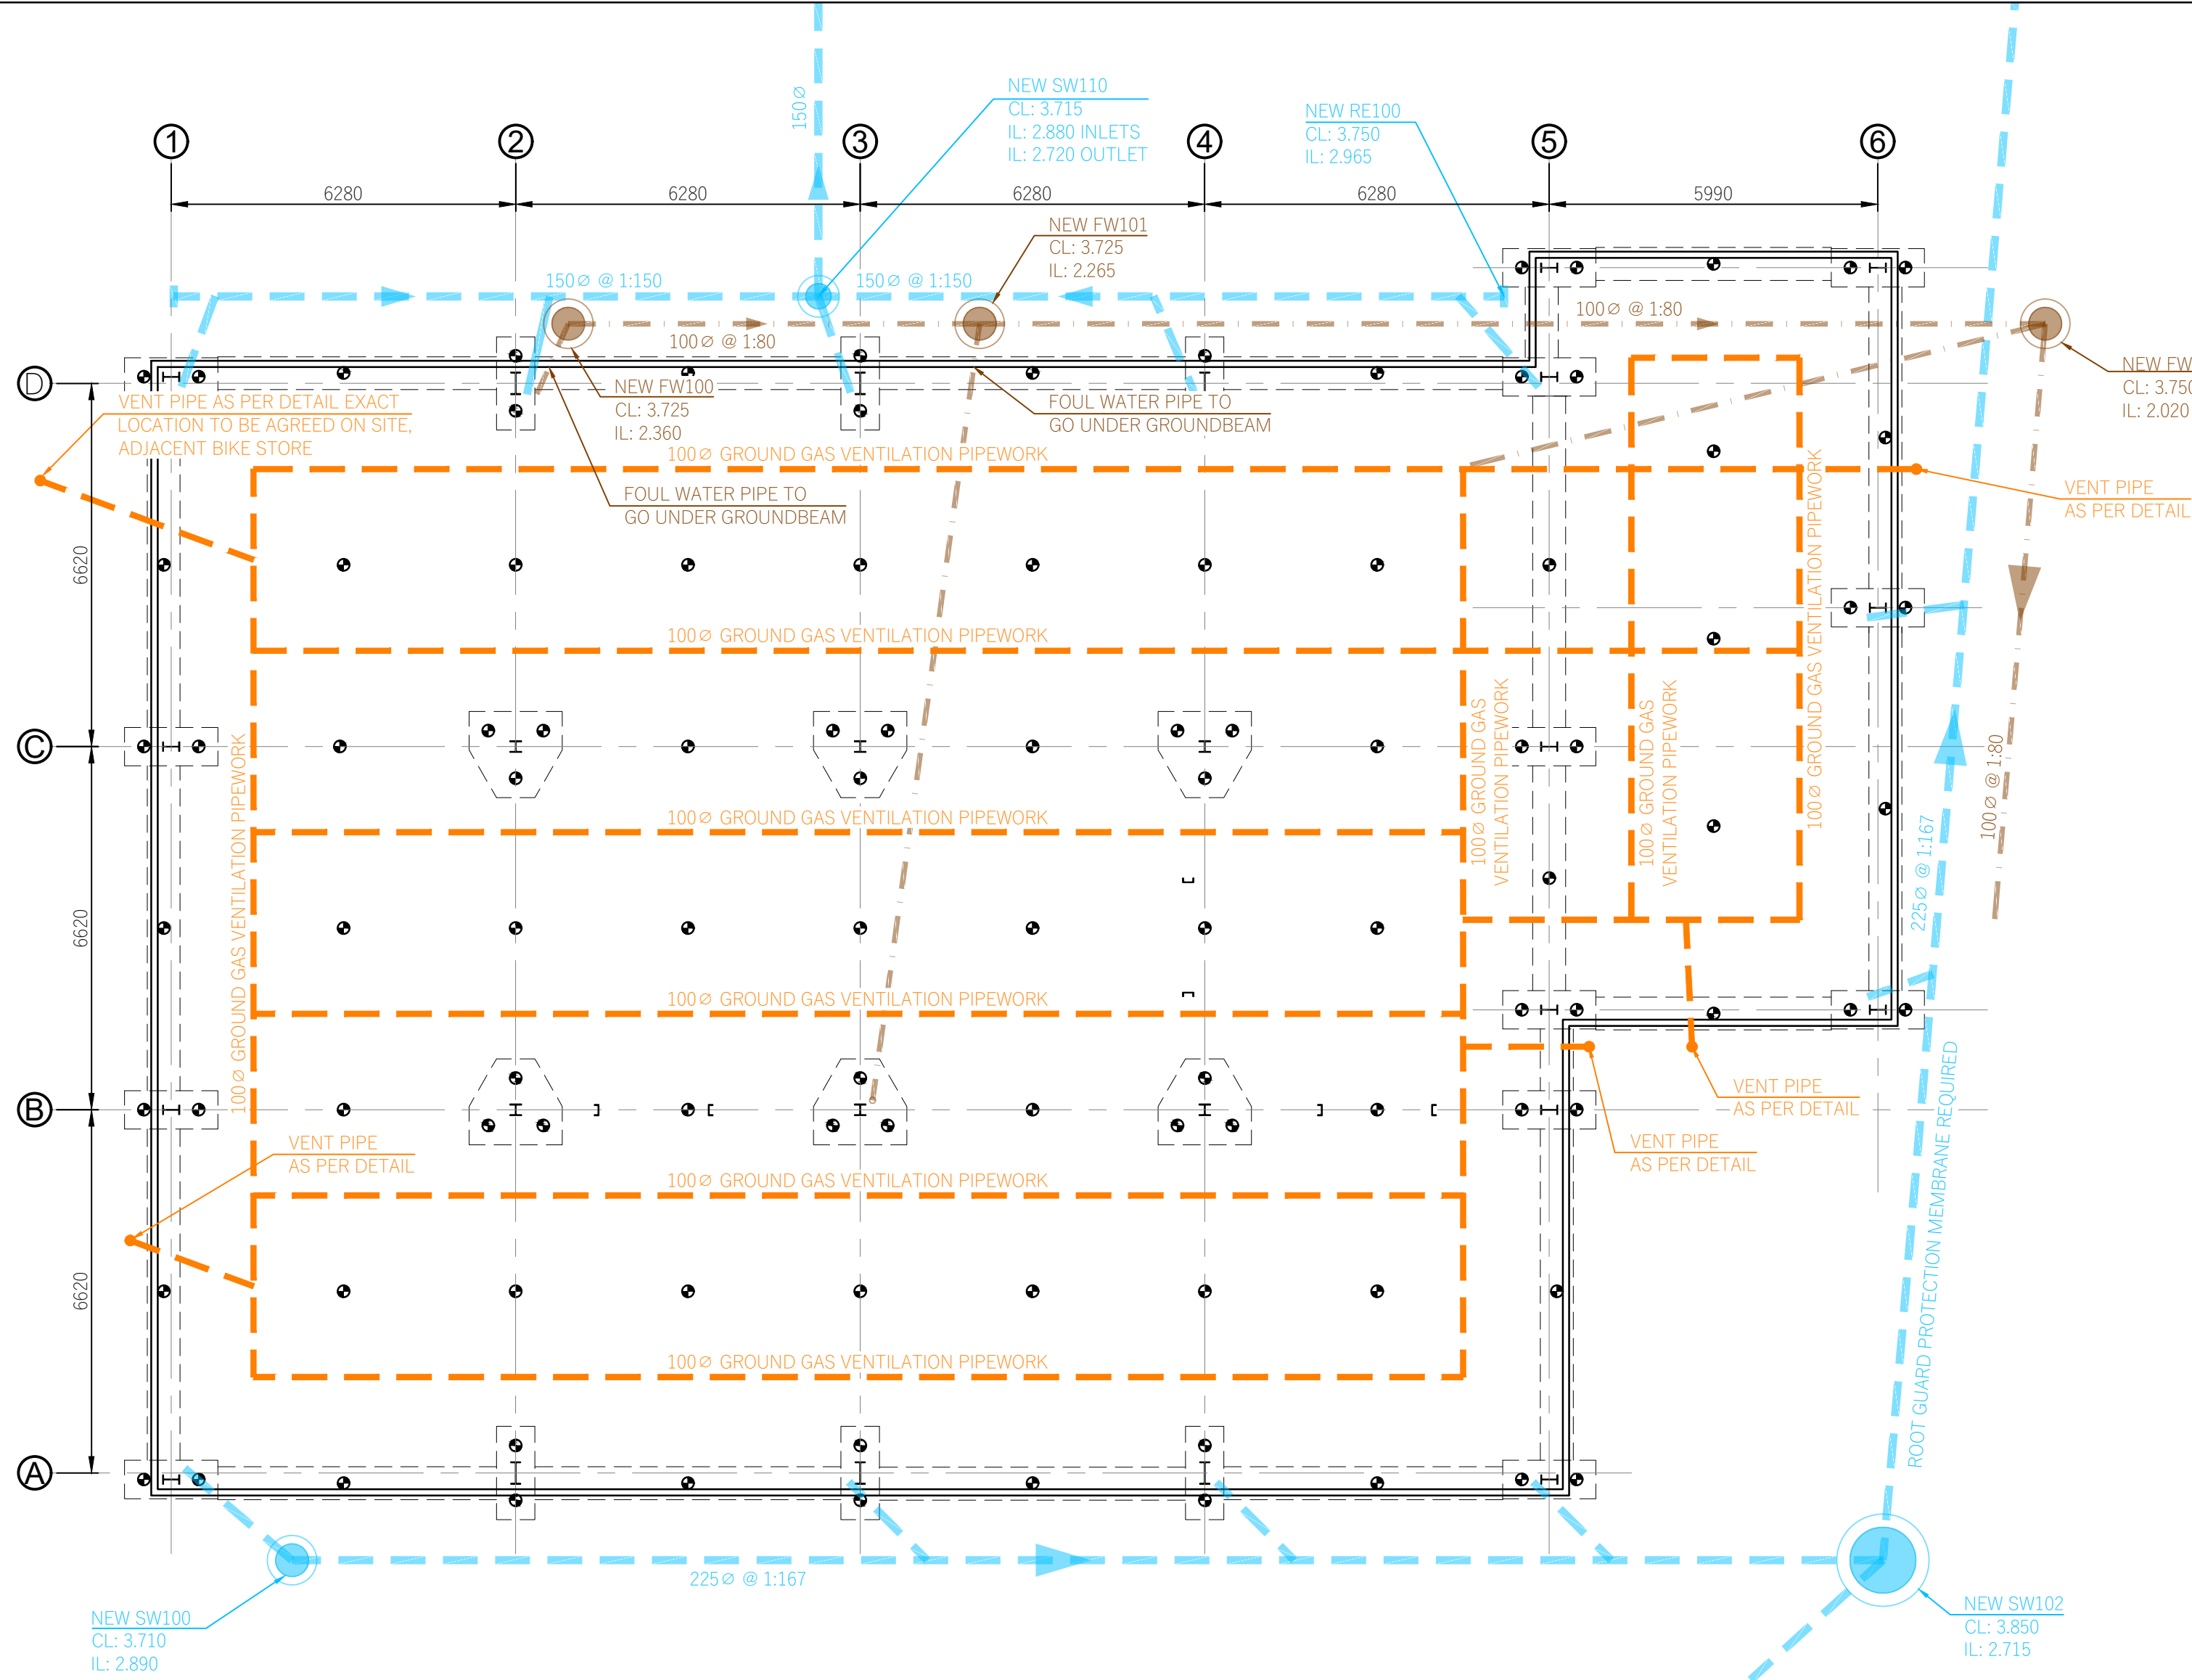

FOR DRAINAGE LAYOUT PLEASE
REFER TO SW DRAWING 21-257-10

PLEASE REFER TO ARCHITECTS DRAWINGS
FOR CONFIRMATION OF ALL WALL/SETTING
OUT DIMENSIONS PRIOR TO COMMENCING
OF WORKS

THIS DRAWING MUST BE READ IN
CONJUNCTION WITH ALL RELEVANT
DRAWINGS & STRUCTURAL CALCULATIONS

P2	PRELIMINARY – FOR APPROVAL	JL	APW	29/07	
P1	PRELIMINARY – FOR APPROVAL	JL	APW	27/07	
Rev	Revision	Drn	App	Date	
SHIELDS WILSON e: info@shieldswilson.co.uk t: 01775 729262 STRUCTURAL AND CIVIL ENGINEERING					
Status	FOR INFORMATION				
Client	AJS Automation				
Project	Proposed New Office & Workshop Plot 9 – SLFEZ, Holbeach, Lincs				
Title	Proposed Slab, Gas Protection & Sub-Floor Drainage				
Date	Jan. '22	Scale @A1	Drawing No.		Rev
Appr	APW	1:50 1:20	21-257-110		P2