

A17

 
 
Drawing Number

0005166-04


Notes

1. Levels and pipe sizes shown are Indicative only.
2. All new gullies to be Type G5 Trapped Road Gully's to L.C.C standard detail no. SD/5/1. Connections to be Ø150mm.
3. All new gullies shall connect into existing gully connections unless shown otherwise. The existing connection must first be located by the contractor.
4. Where new gullies tie into existing connections the contractor shall bondseal all new pipes into existing pipework, with all connections to be approved by the Engineer.
5. Exact position of rising main & easements to be agreed with Holbeach County Junior School & Anglian Water.
6. Proposed Combined Drainage and Kerb Block to be connected to existing Highway Drainage System.

KEY

-  Proposed Surface Water Sewer
-  Existing Surface Water Sewer
-  Existing Gully to be backfilled
-  New Trapped Gully. Connect to existing.
-  Existing Foul Water Gravity Sewer
-  Existing Foul Water Rising Main
-  Proposed Foul Water Gravity Sewer
-  Proposed Foul Water Rising Main
-  Proposed Combined Drainage and Kerb Block to Lincolnshire Standard Detail SD7/5/106.


Based on Topographical Survey produced by North Point Surveys,  
Drawing No. J430.GEO (Mar 2003).  
O.S. Reference: TF359257.  
Do not scale this drawing

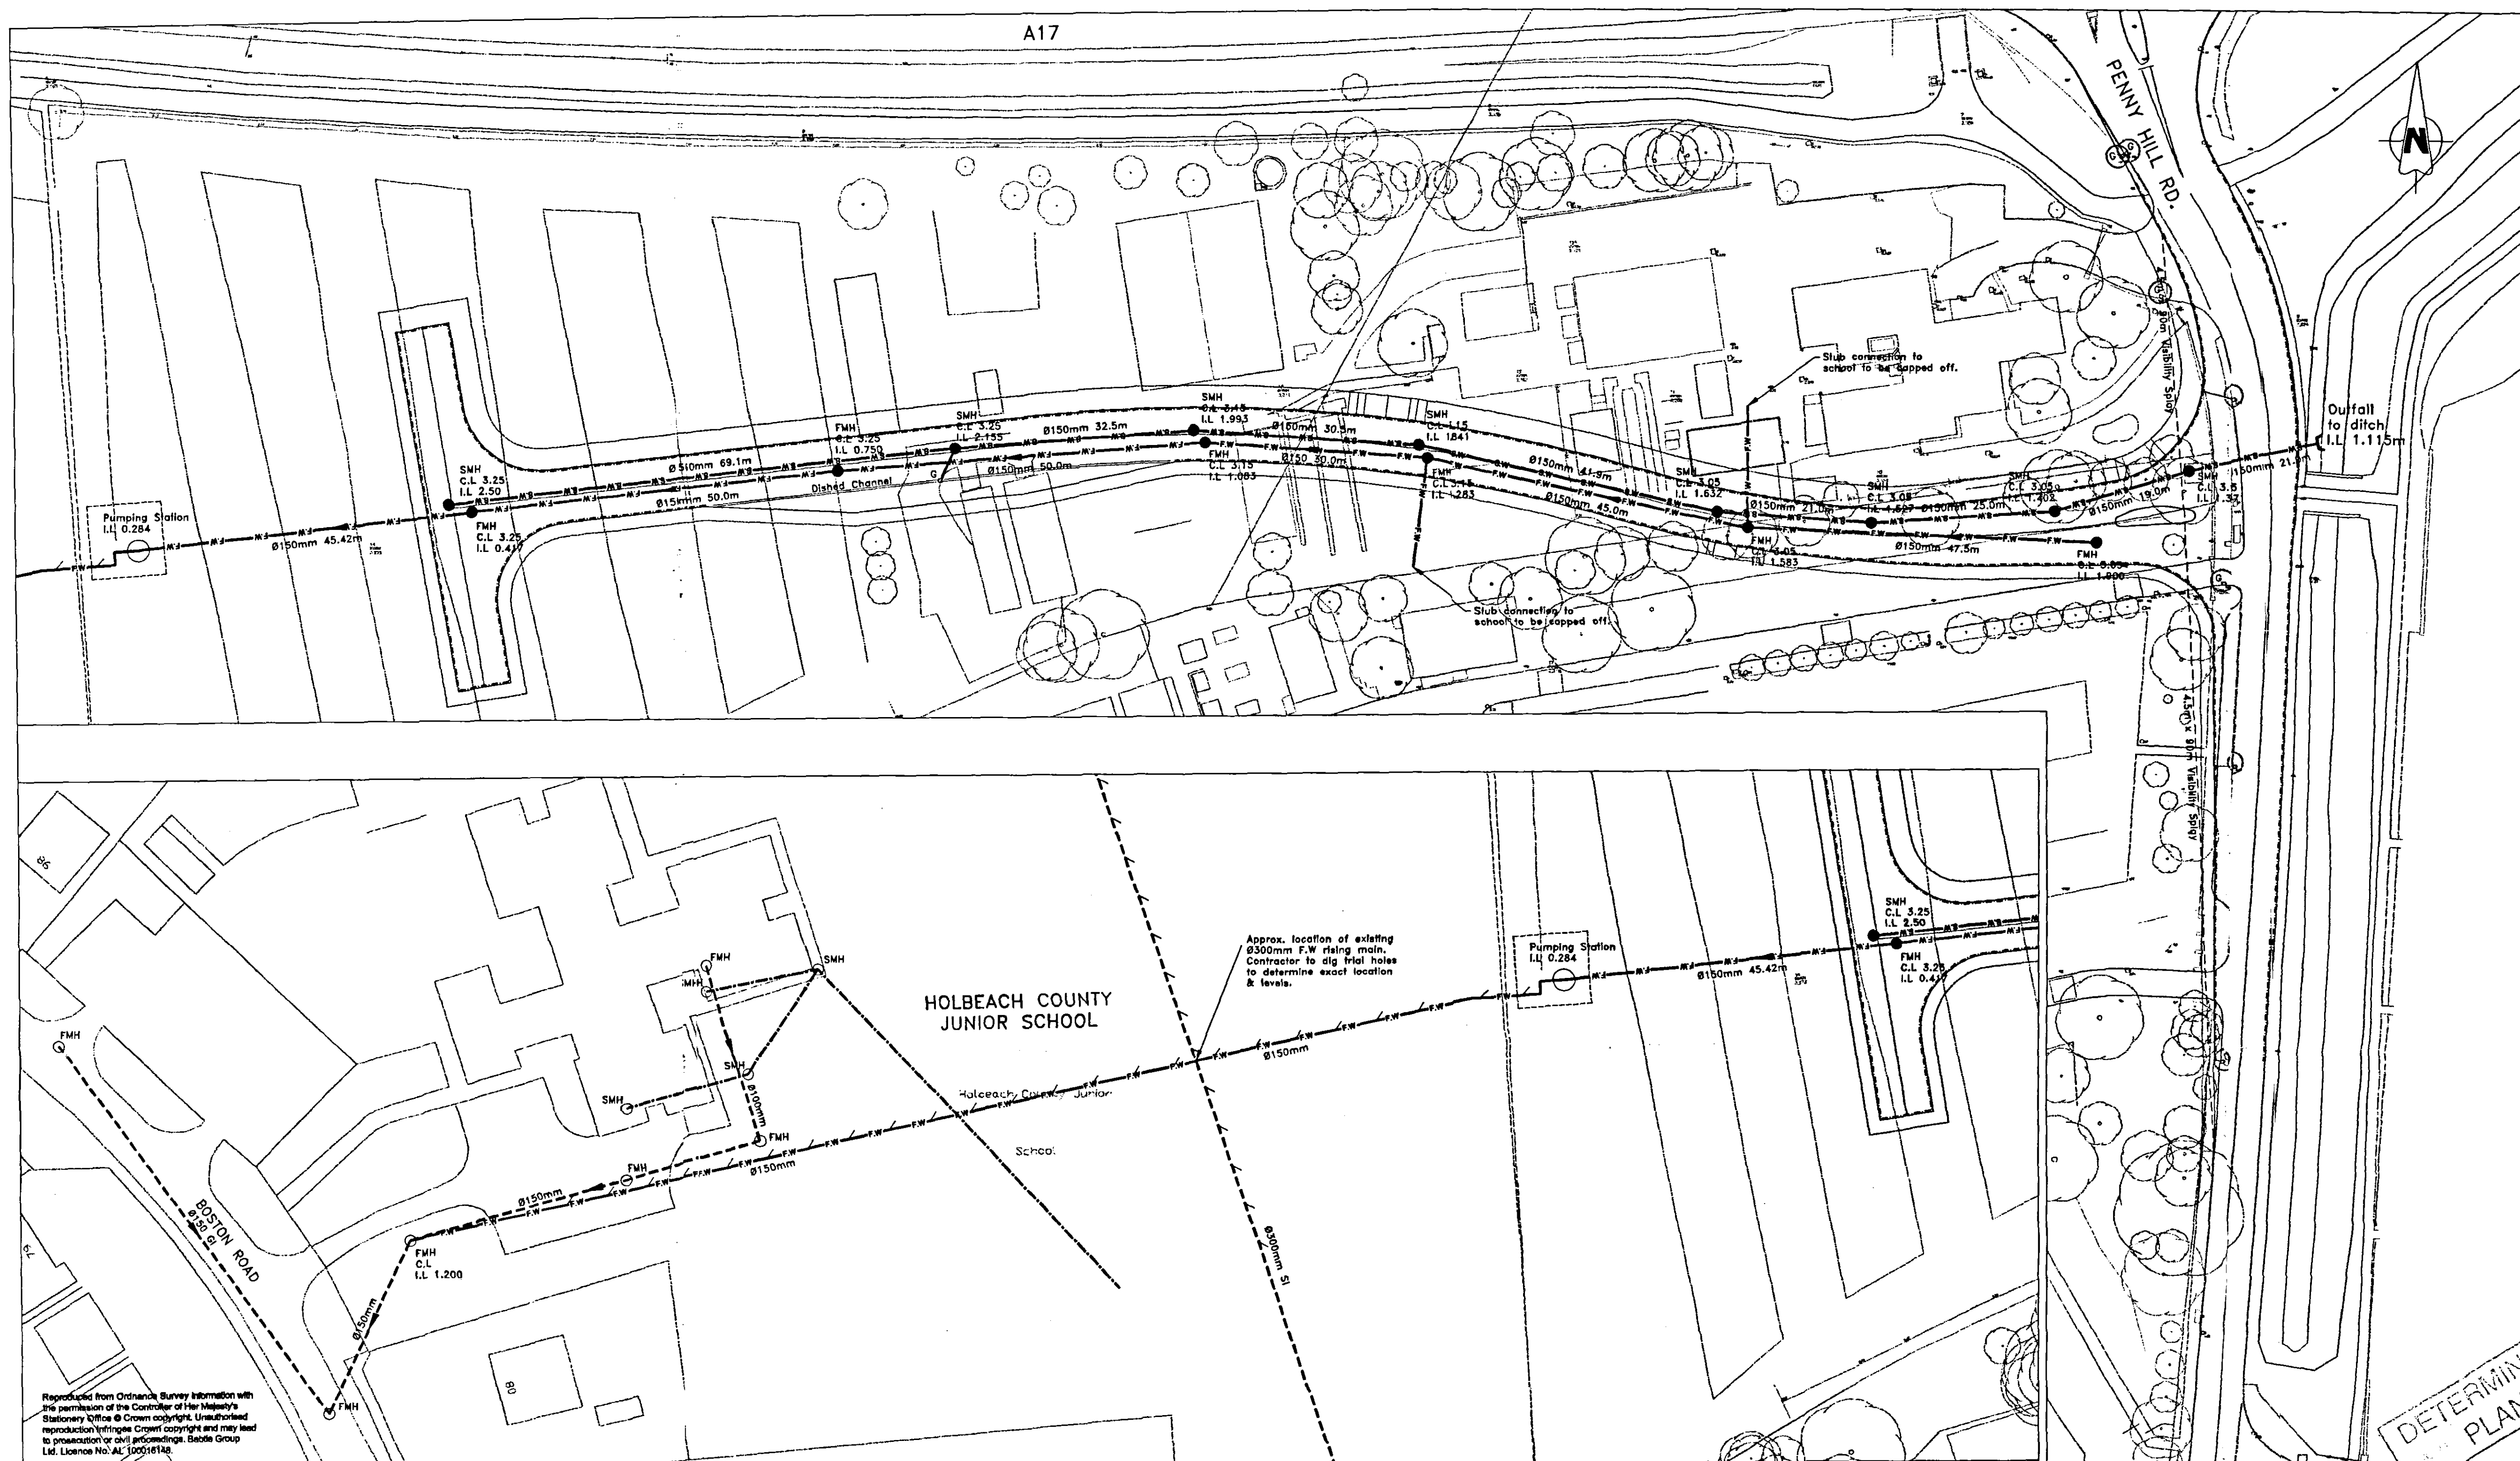

Reproduced from Ordnance Survey information with the permission of the Controller of Her Majesty's Stationery Office © Crown copyright. Unauthorised reproduction infringes Crown copyright and may lead to prosecution or civil proceedings. Babbie Group Ltd. Licence No. AL100016142

THESE DRAWINGS ARE AWAITING APPROVAL FROM ANGLIAN WATER AND ARE FOR INFORMATION PURPOSES ONLY.

DRAFT

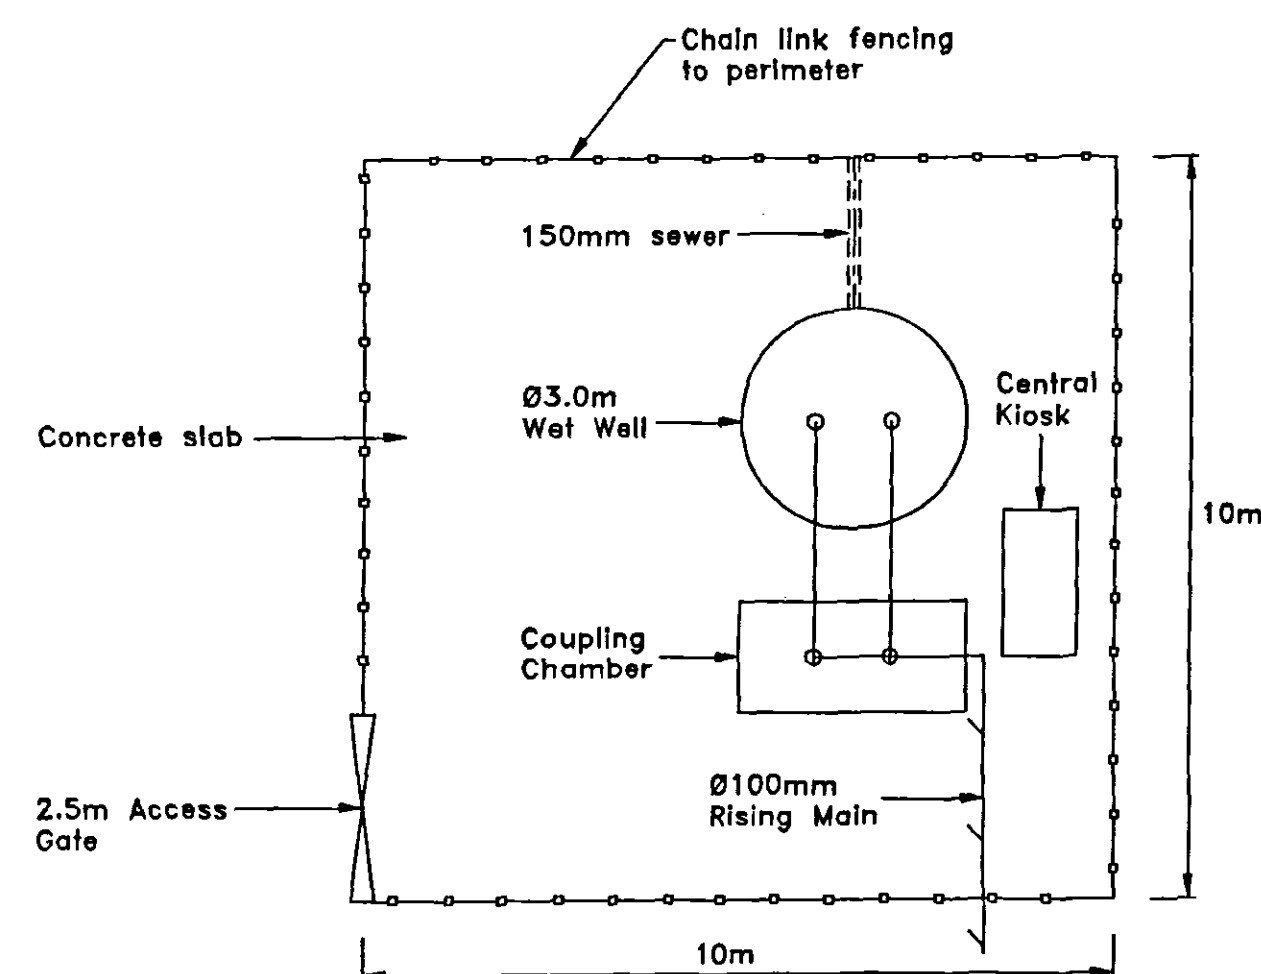

PUMPING STATION COMPOUND LAYOUT

Scale 1:100

DETERMINED PLAN

20 JUL 2003  
0936103

|     |         |                                             |            |
|-----|---------|---------------------------------------------|------------|
| D   | 16/7/03 | Surface water layout revised.               | D.Wing     |
| C   | 24/6/03 | Foul water layout revised.                  | D.Wing/URB |
| B   | 2/6/03  | Foul water design & drawing layout revised. | D.Wing/URB |
| A   | 20/5/03 | Junction & surface drainage layout amended. | D.Wing/URB |
| Rev | Date    |                                             | Checked    |



Client LINCOLNSHIRE DEVELOPMENT

Project HOLBEACH DMU CAMPUS  
NEW ACCESS ROAD & S278 WORKS

Title DRAINAGE PLAN

|             |            |         |       |          |
|-------------|------------|---------|-------|----------|
| Drawing No. | 0005166-04 | A       | B     | C        |
| Scale       | 1:500      | Date    | 03/03 |          |
| Drawn       | D.Wing     | Checked |       | Approved |

Copyright reserved  
Babbie Group Ltd  
Wheatcroft House, Wheatcroft Business Park,  
Landmere Lane, Edwalton, Nottingham, NG12 4DG.