


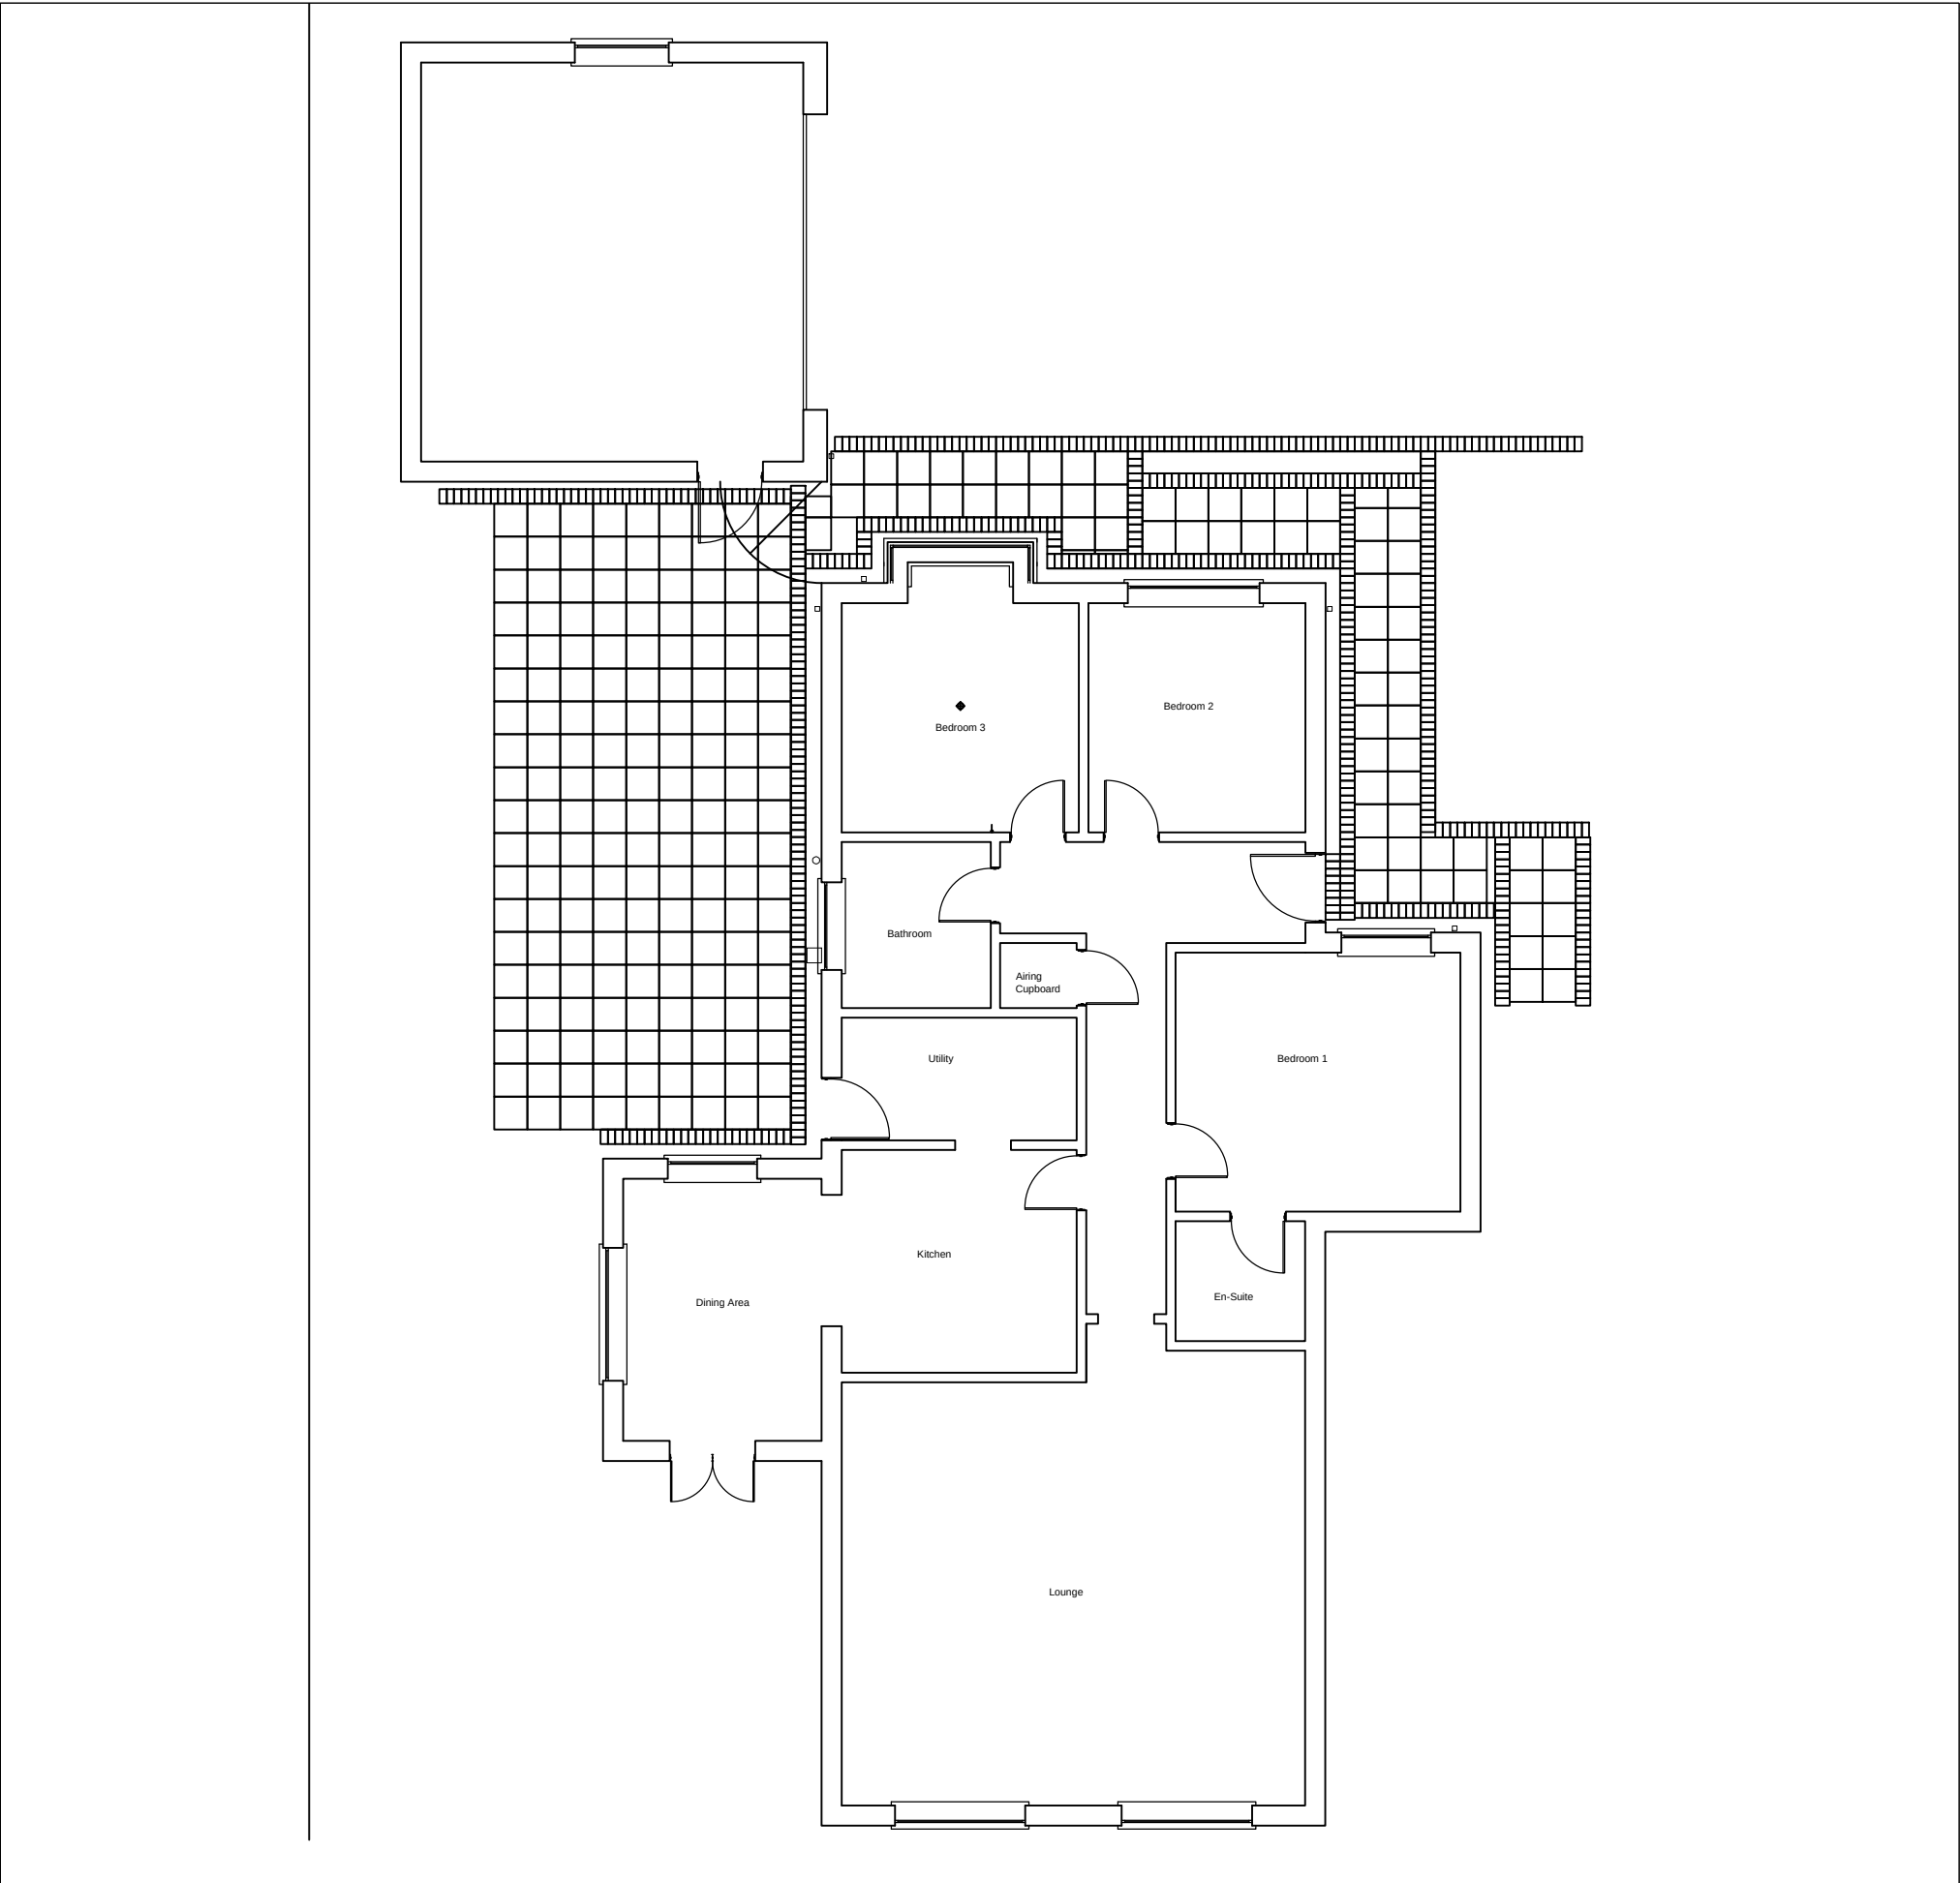

ELECTRICAL SYMBOLS KEY

- DOUBLE SWITCHED WALL SOCKET
- SHOWER ISOLATOR PULL CORD SWITCH
- INTERNAL LIGHT - BULKHEAD TYPE
- TV AERIAL POINT
- 1GANG 2 WAY LIGHT SWITCH

- 1 GANG LIGHT SWITCH
- LIGHT POINT - PENDANT HOLDER (4 INCH)
- 1 GANG PULL CORD LIGHT SWITCH
- SINGLE SWITCHED FUSE SPUR AT HIGH LEVEL FOR EXTRACT FAN
- MECHANICAL EXTRACT FAN
- FUSE SPUR

Rev A - 08.04.16 - SG - Electrical Symbols Key added

Do Not Scale From This Drawing
This drawing is copyright and may not be altered , traced, photographed or copied without prior written consent from South Holland Building Consultancy.
The contractor should check all dimensions on site prior to commencement and report any discrepancies to the Draftsperson.



South Holland Building Consultancy
Council Offices
Priory Road
Spalding
Lincs
PE11 2XE
01775 764447

Project : Disabled Adaptations
Address : Cornfields, Lutton Bank, Lutton
Client : Mr M Townsend
Scale : 1 : 100
Date : 19th November 2015
Title: Existing Ground Floor Plan
Dwg No : 686/Grant/01 A Drawn : SG