


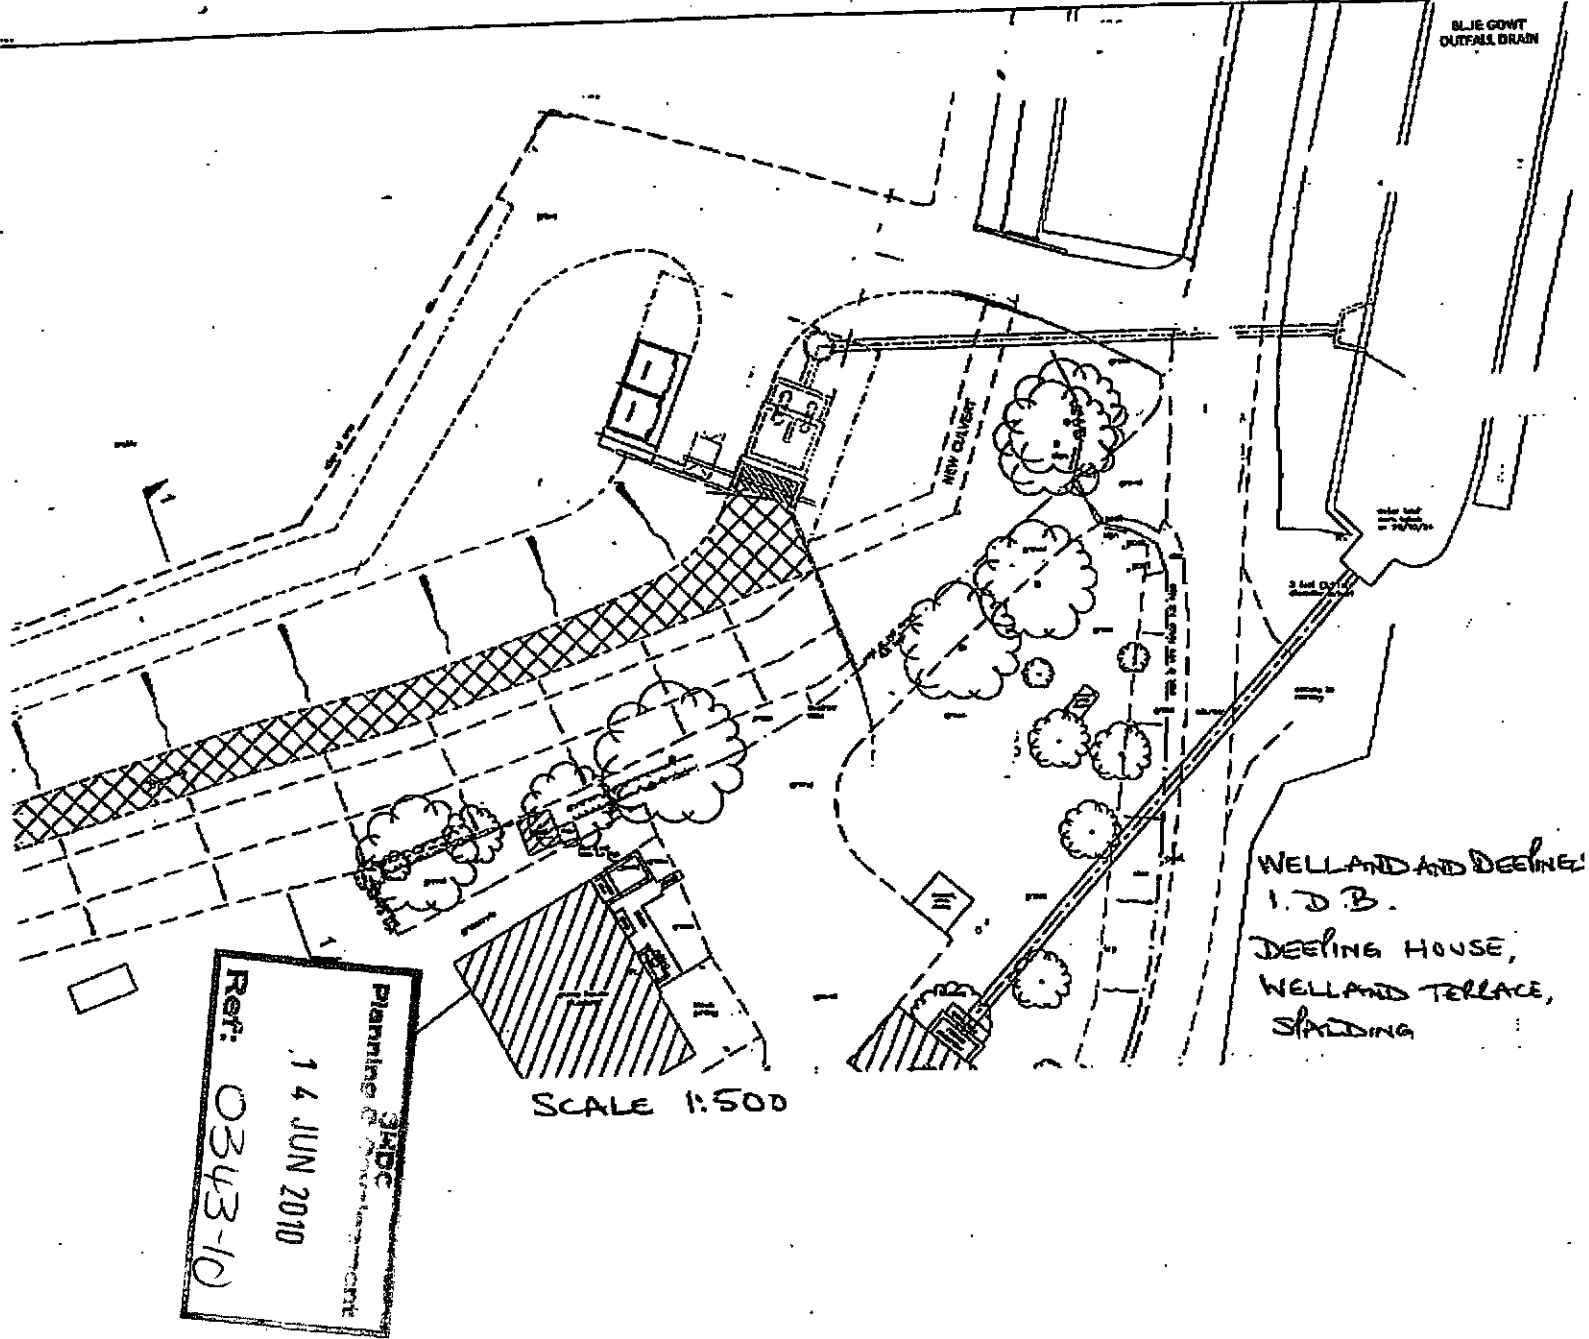

Drain

Track

WEST MARSH RD

SI

Sluices

Museum

Pinchbeck Marsh
Pumping Station

Ref: 0343-10

14 JUN 2010

SHDC
Planning & Environment


Welland and Deepings Internal
Drainage Board,
Deeping House,
Welland Terrace,
Spalding,
Lincs
PE11 2TD

1:2500

100 50 0 metres



Reproduced by permission of Ordnance Survey on behalf of
HMSO. Crown copyright and database right 2006. All rights
reserved. Ordnance Survey Licence number 10002480

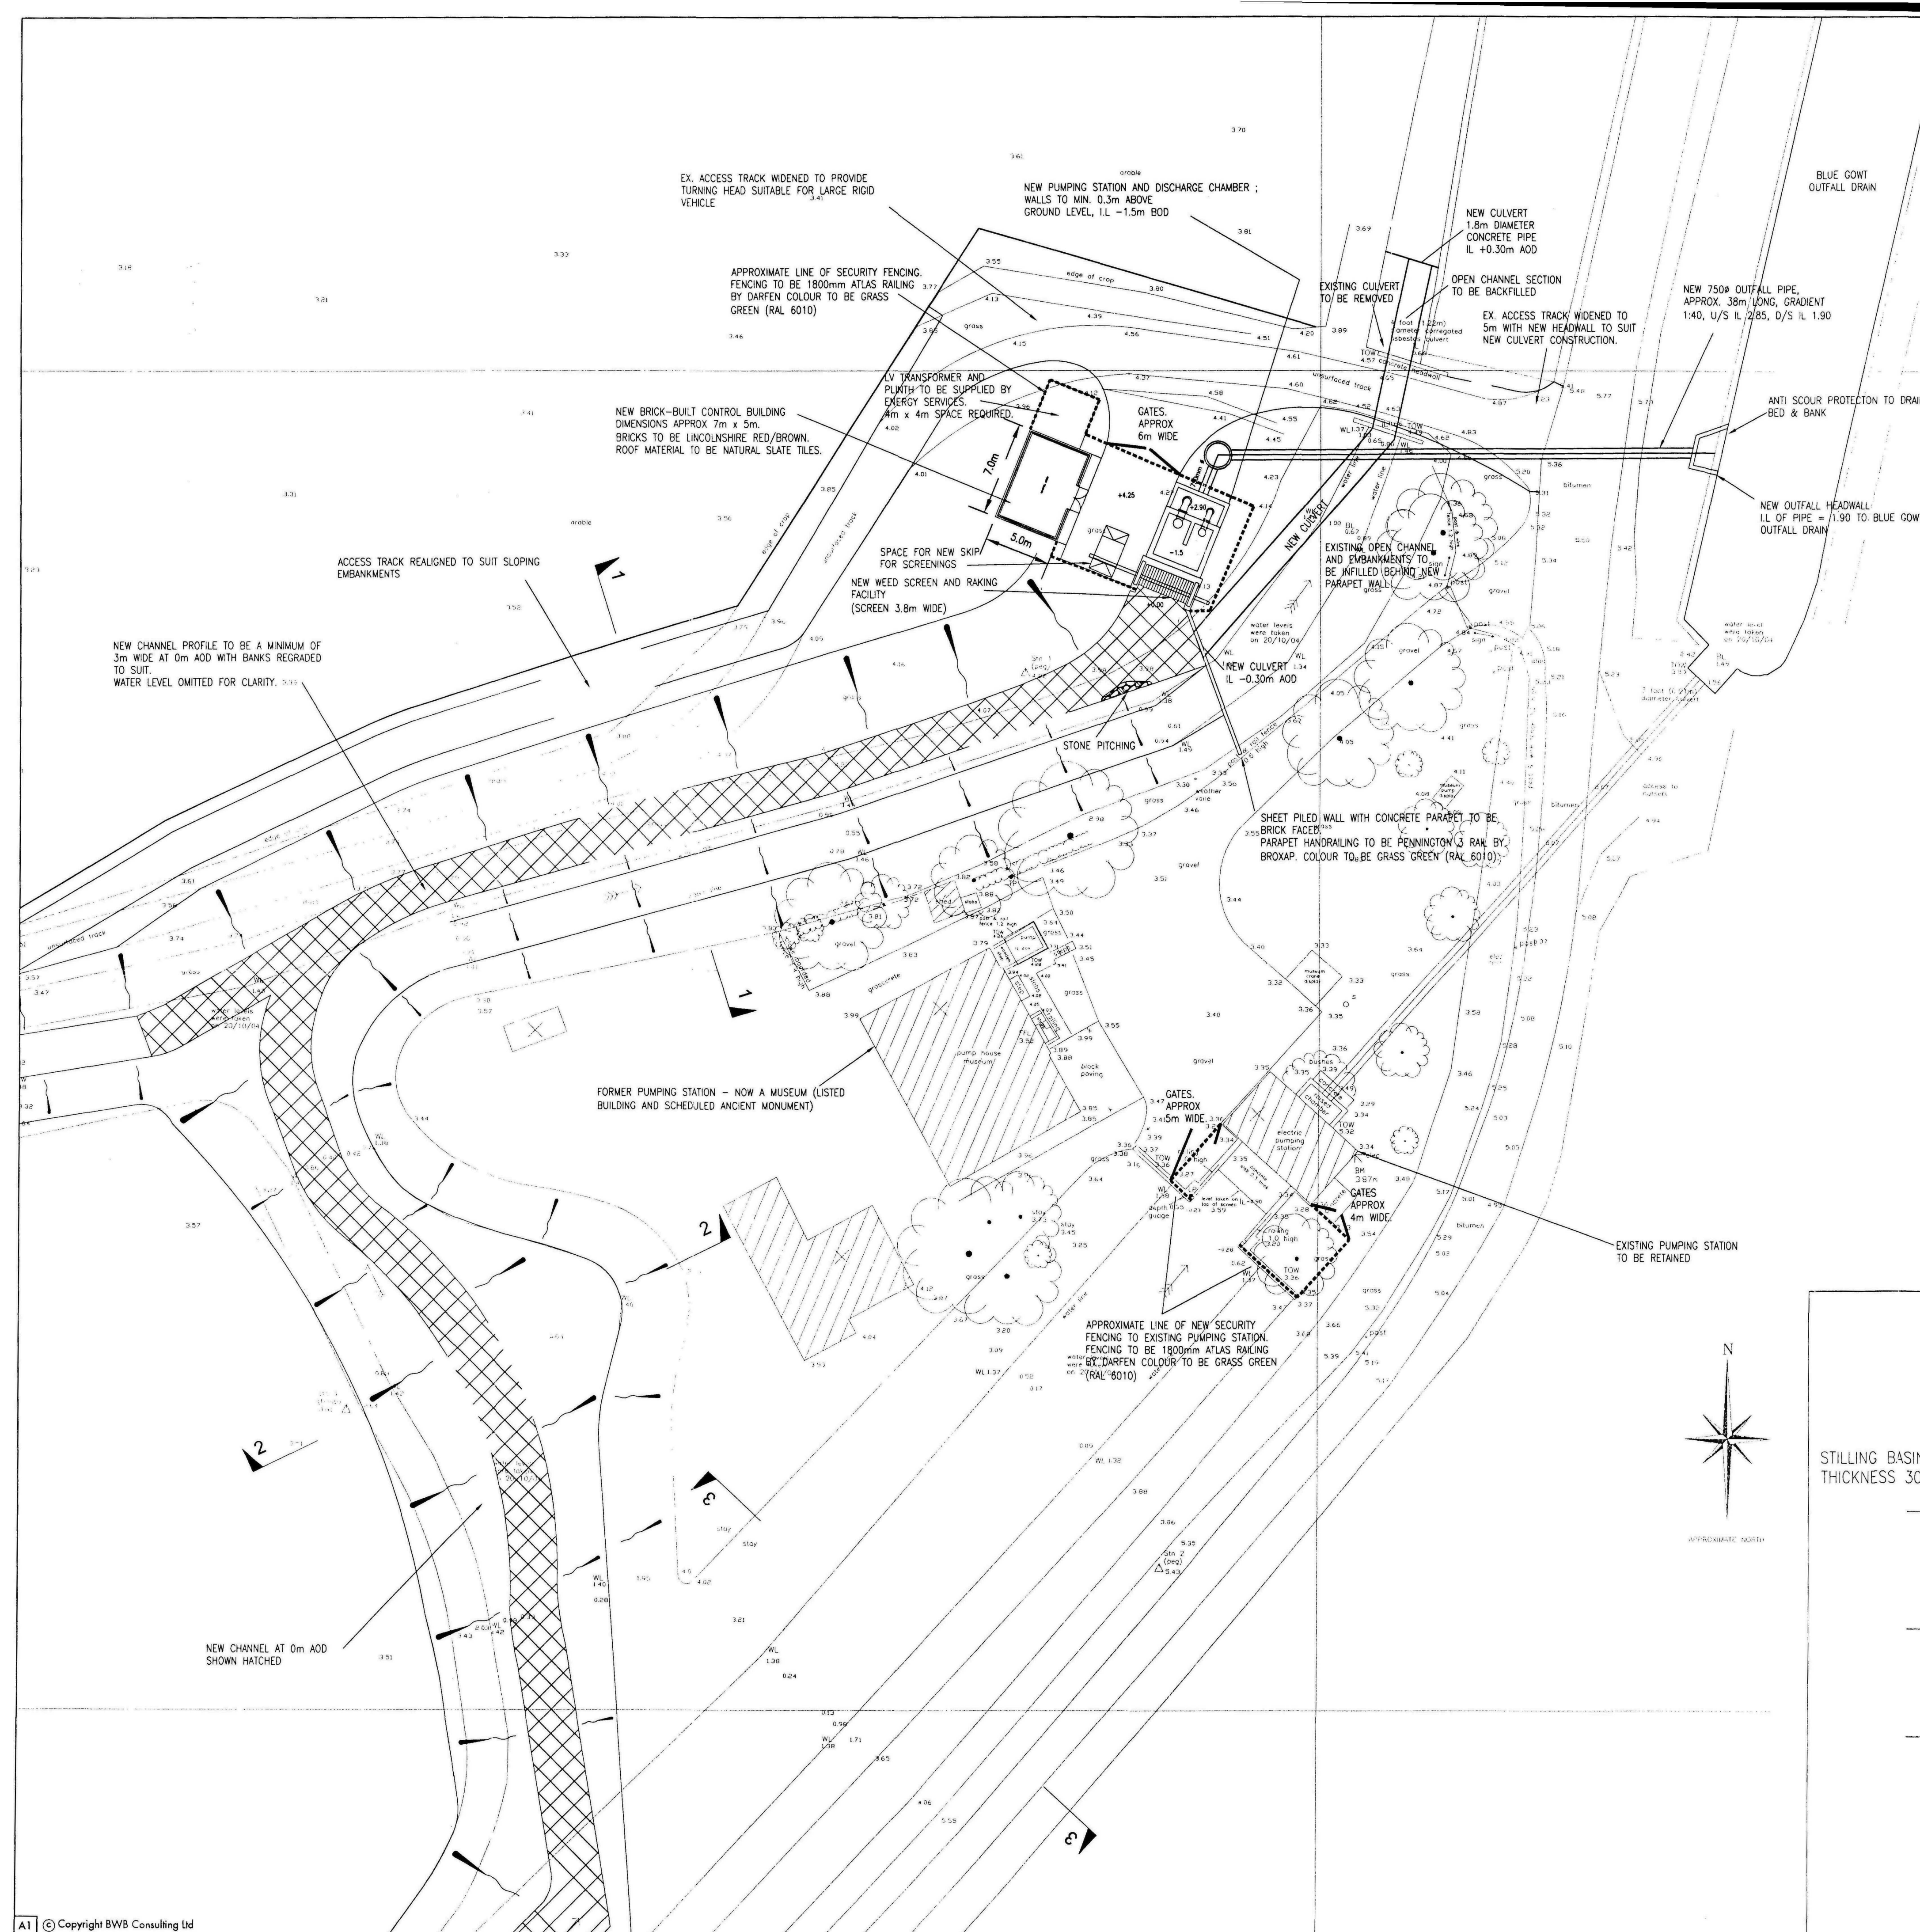

1. DO NOT SCALE THIS. BE CHECKED/ VERIFIED ON .
2. THIS DRAWING IS TO BE READ I ALL RELEVANT ARCHITECTS, ENGINE DRAWINGS AND SPECIFICATIONS.
3. ALL DIMENSIONS IN MILLIMETRES OTHERWISE. ALL LEVELS IN METRES OTHERWISE.
4. ANY DISCREPANCIES NOTED ON REPORTED TO THE ENGINEER IMMEL
5. REFER TO DRAWING NTW-076-C CROSS-SECTIONS.

KEY

C2	18.05.07	Pumping chamber dimension
C1	08.05.07	CONSTRUCTION ISSUE
T2	06.02.07	Security fencing extents owner
T1	20.12.06	TENDER ISSUE
P2	03.10.06	Layout modified
P1	01.09.06	PRELIMINARY ISSUE

AMENDMENT

BWB CONSULTING

Integrated Engineering and Environmental Con.
3-4 Kayes Walk, The Lace Market
T 0115 924 1100 F 0115 950 3961
environmental | water | transportation | civil | air

Client **WELLAND AND INTERNAL DRAIN.**
Project Title


PINCHBECK P STATIC


Drawing Title
PROPOSED SIT

Scale 1:250 Date SEP 2006 Drawn JS


Drawing Status
CONSTRUC

Drawing No.
NTW/076/0C

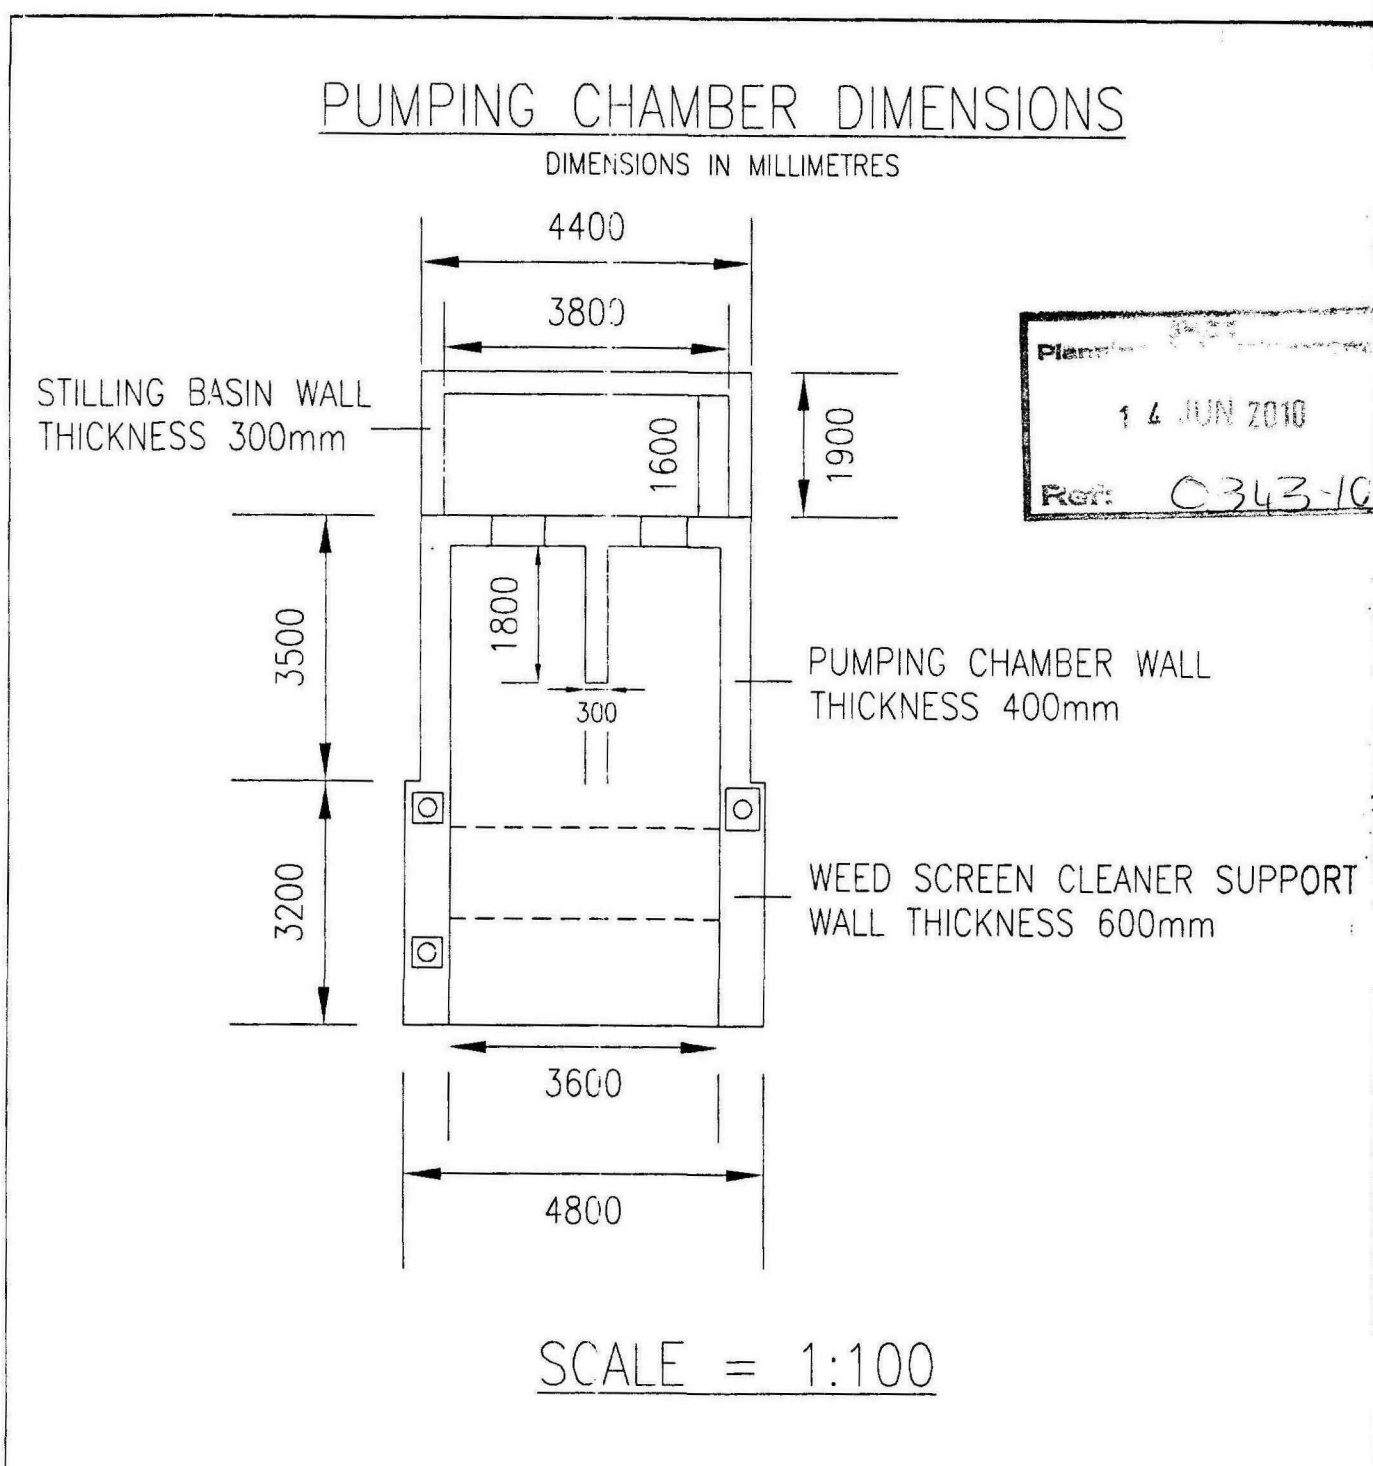


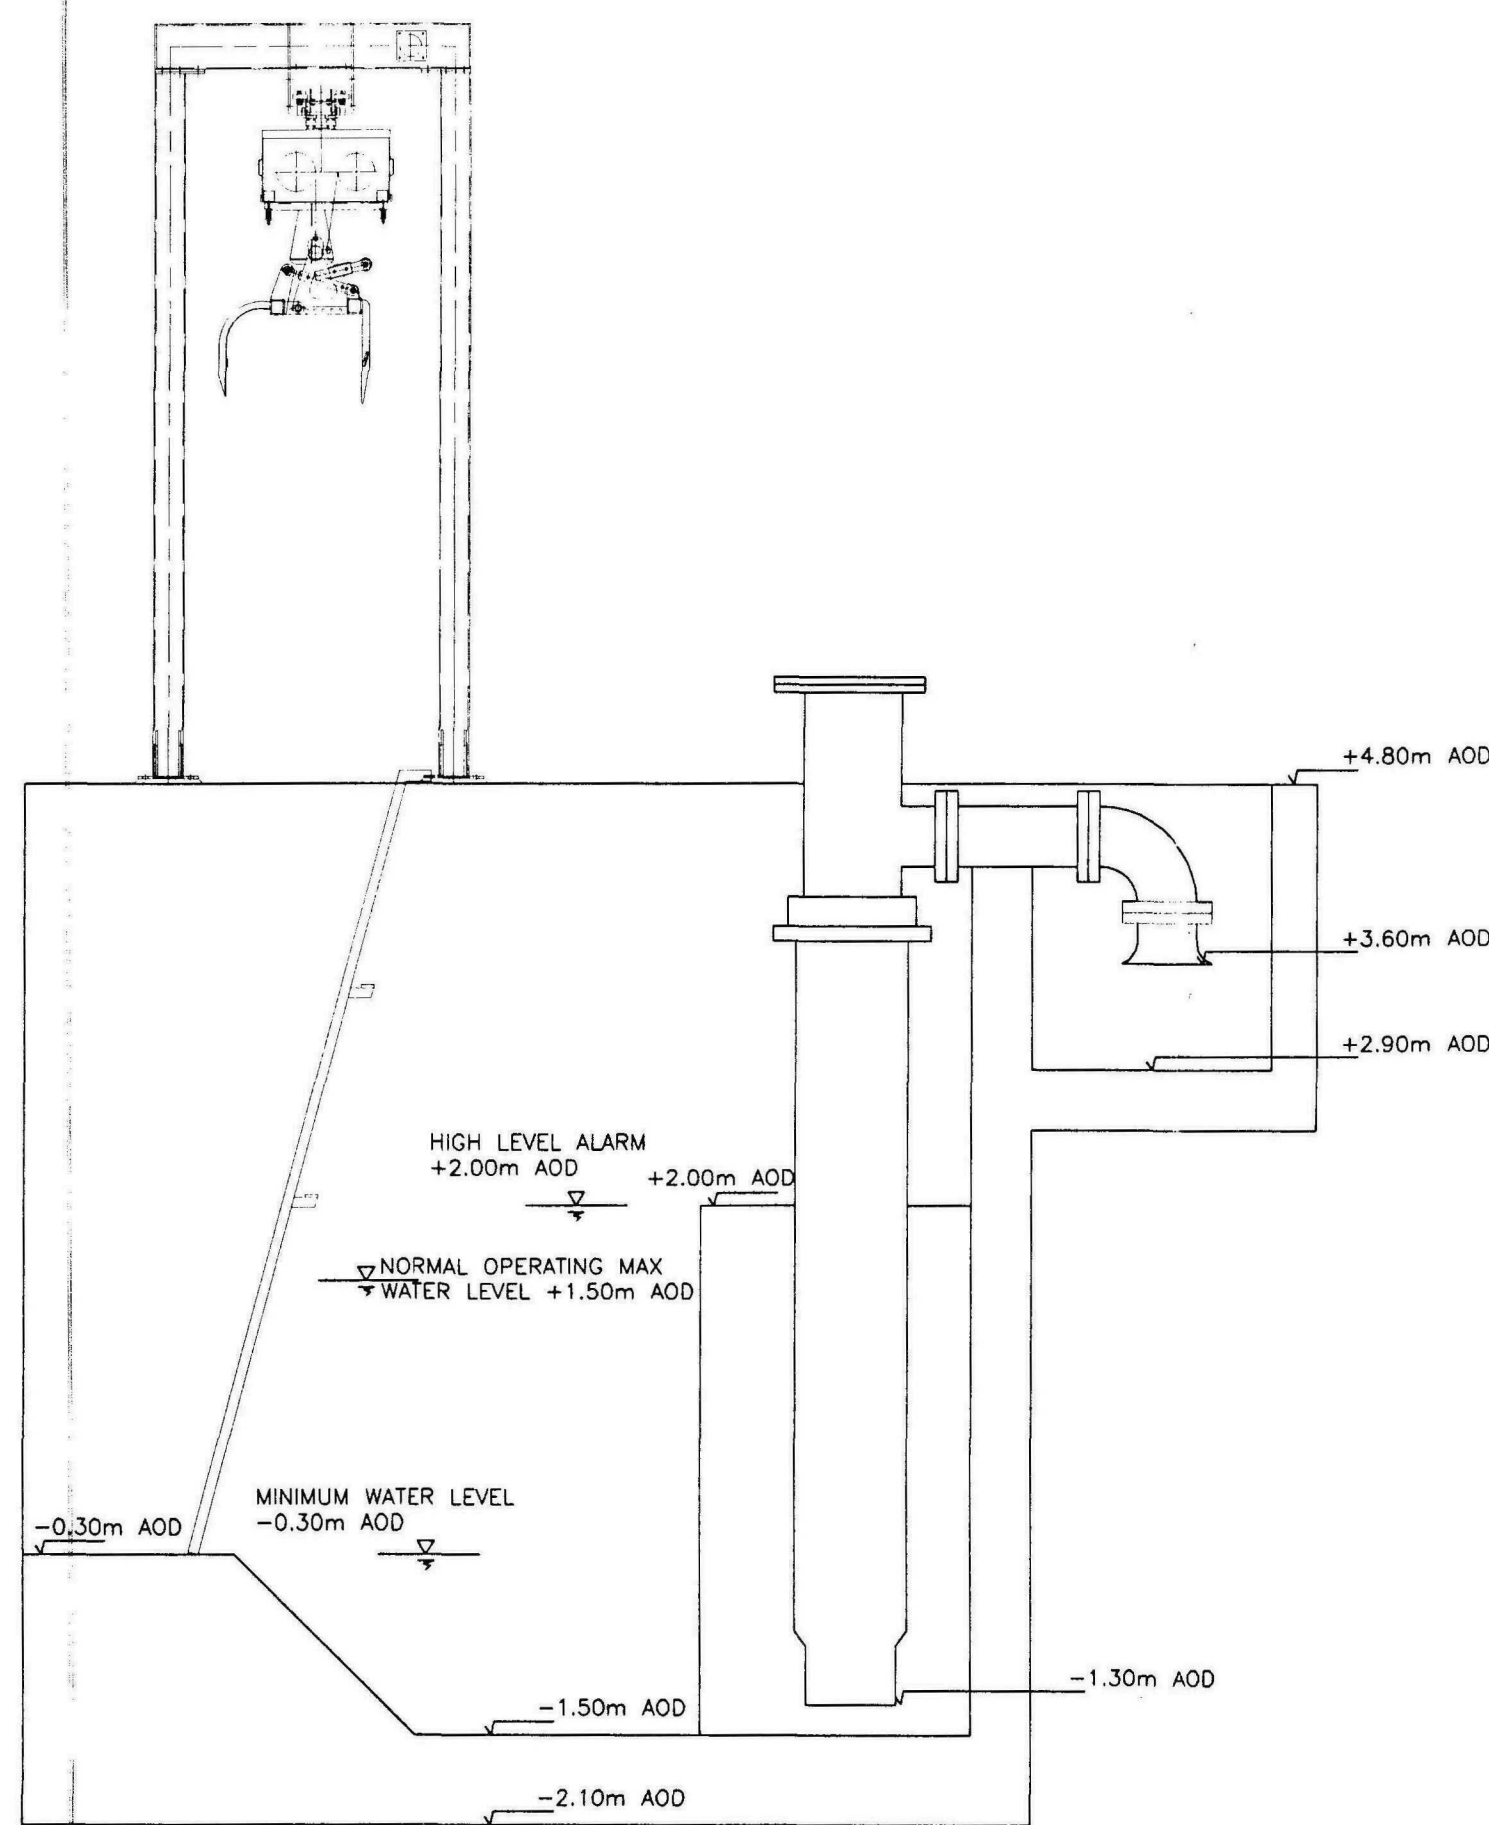


PUMPING STATION SECTION
SCALE = 1:50

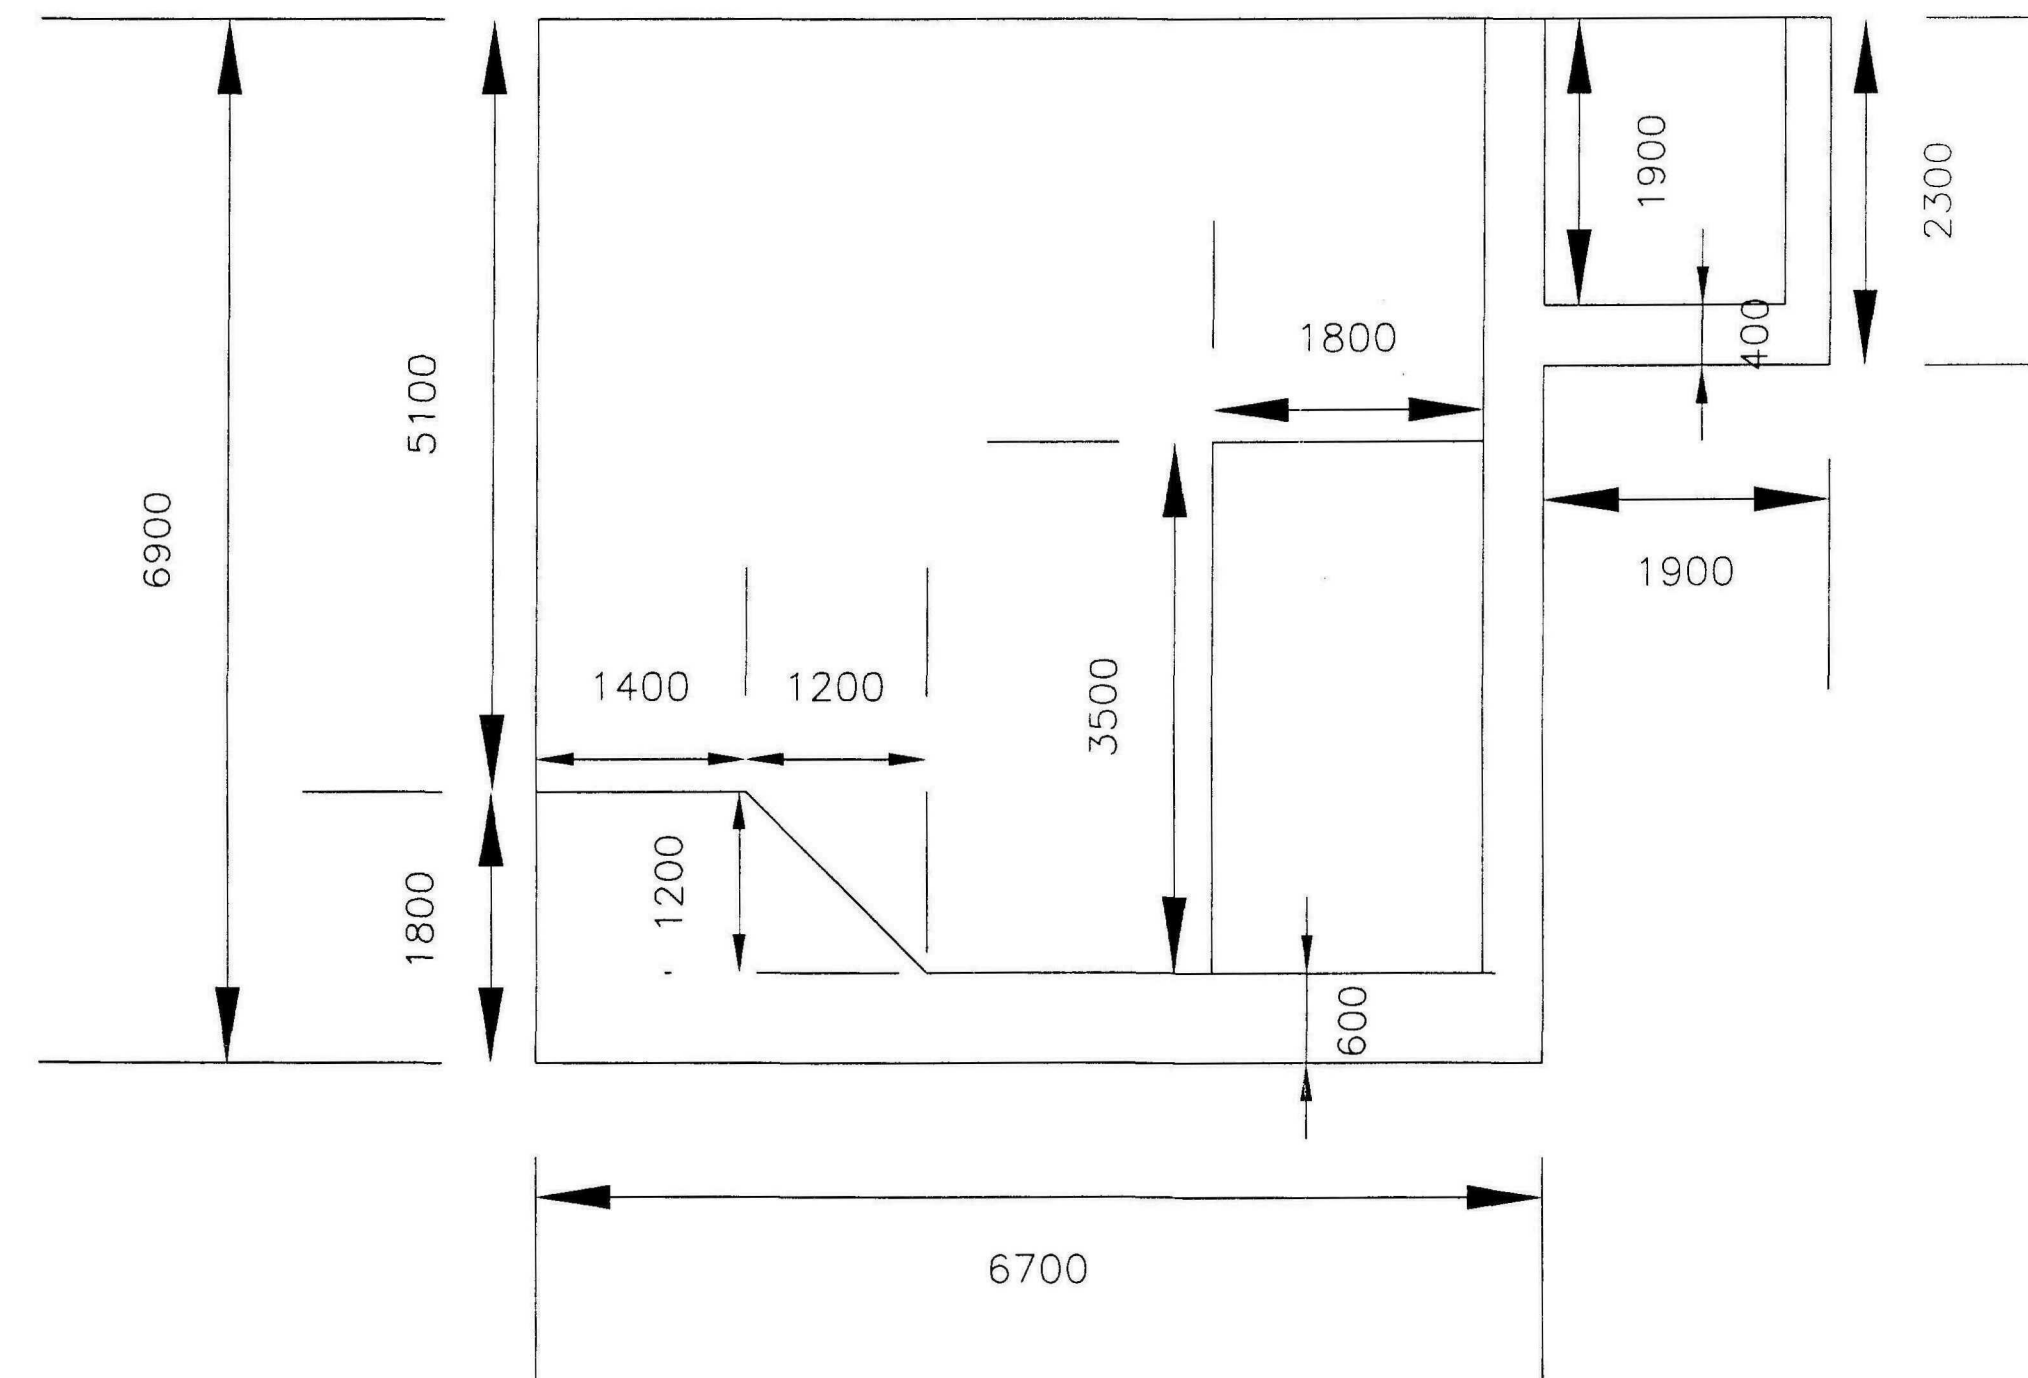




PLAN VIEW
SCALE = 1:50

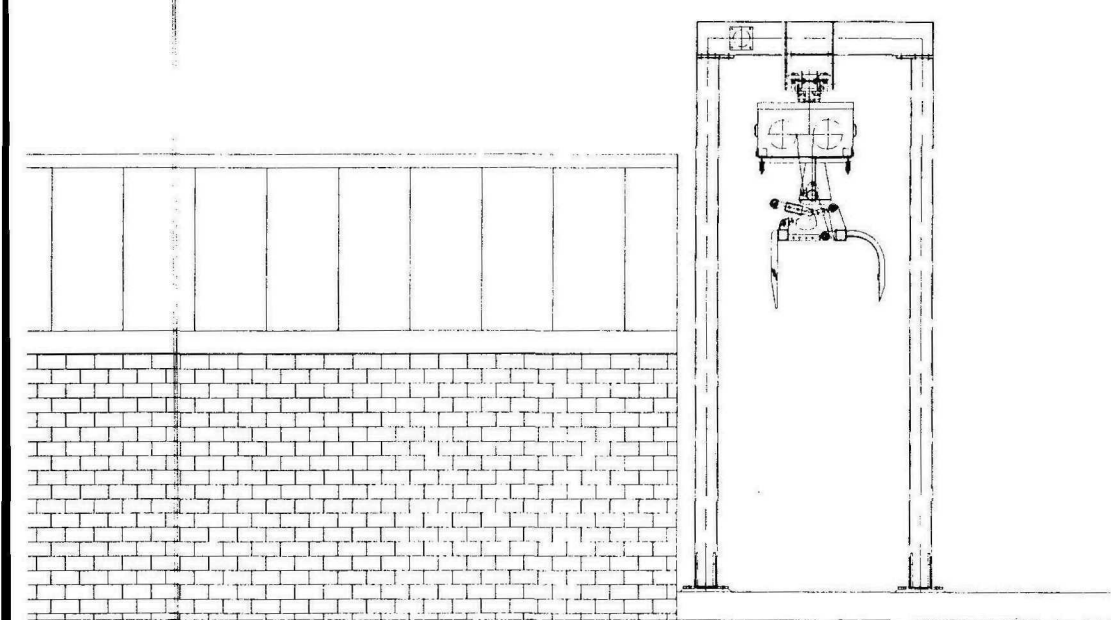

NORTH-WEST ELEVATION
Not to scale

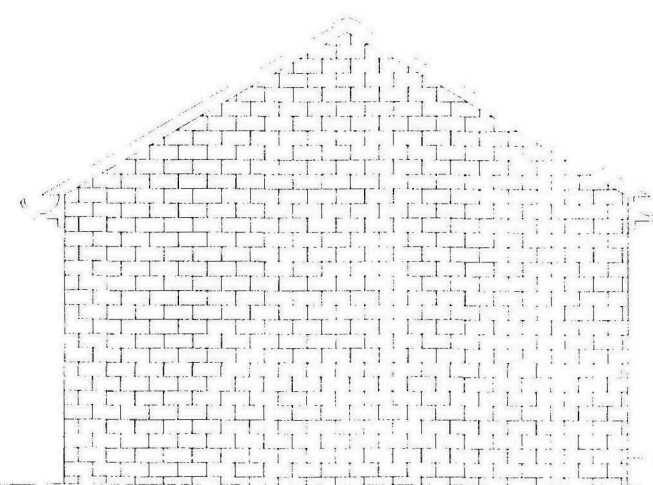

NORTH-EAST ELEVATION
Not to scale

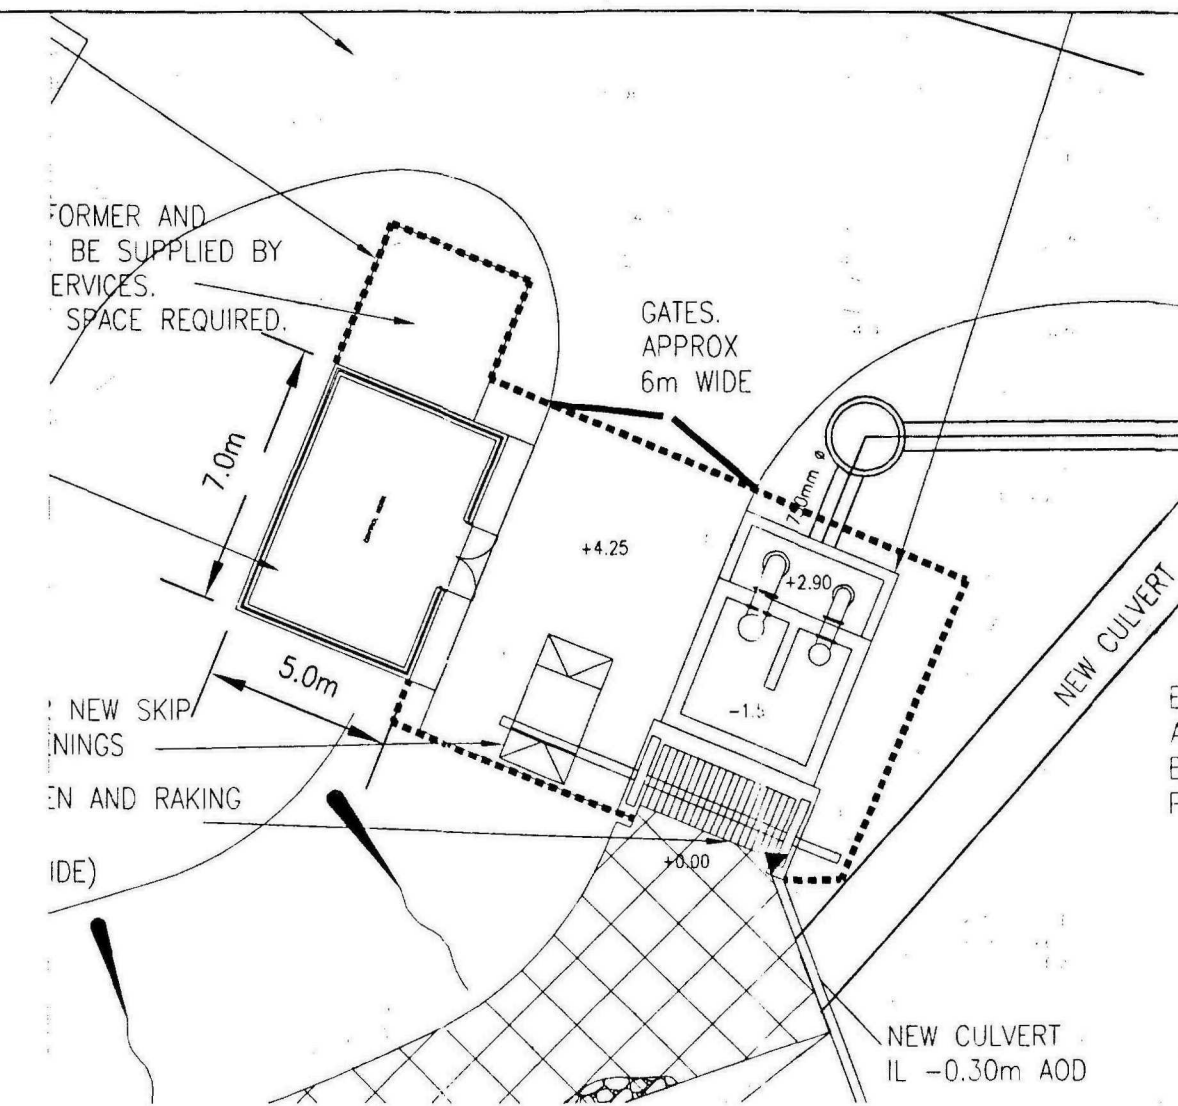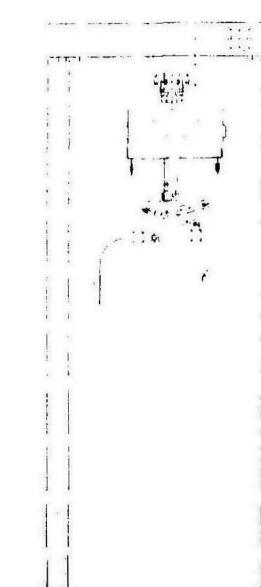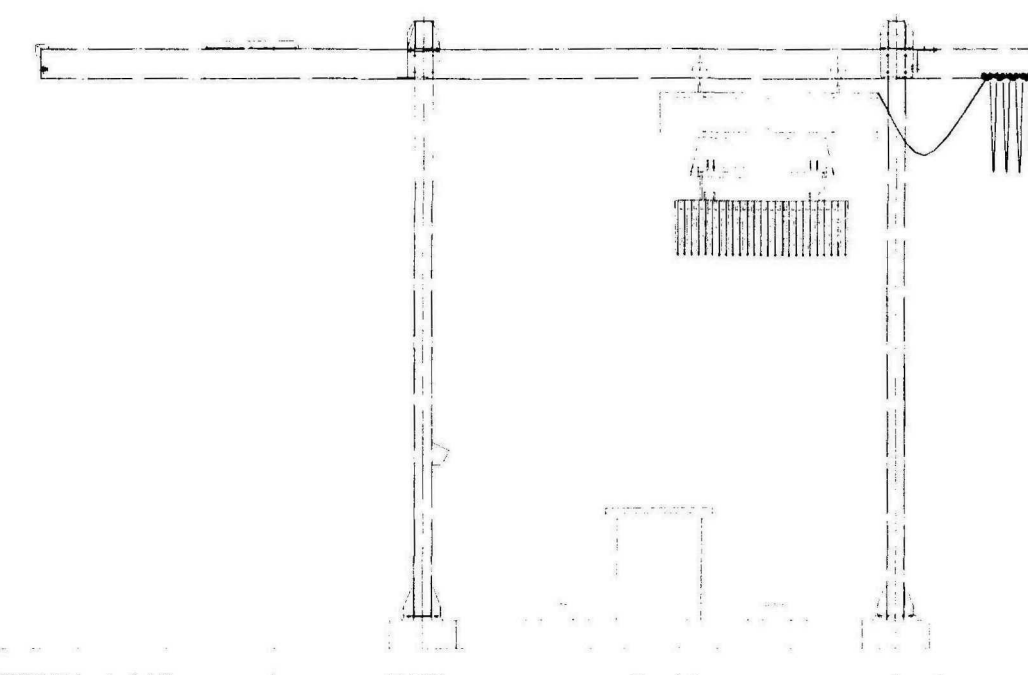


- NOTES
1. DO NOT SCALE THIS DRAWING. ALL DIMENSIONS MUST BE CHECKED/ VERIFIED ON SITE. IF IN DOUBT ASK.
 2. THIS DRAWING IS TO BE READ IN CONJUNCTION WITH ALL RELEVANT ARCHITECTS, ENGINEERS AND SPECIALISTS DRAWINGS AND SPECIFICATIONS.
 3. ALL DIMENSIONS IN MILLIMETRES UNLESS NOTED OTHERWISE. ALL LEVELS IN METRES UNLESS NOTED OTHERWISE.
 4. ANY DISCREPANCIES NOTED ON SITE ARE TO BE REPORTED TO THE ENGINEER IMMEDIATELY.

KEY

Rev	Date	Description	Drawn	Auth'd
C2	18.05.07	Pumping chamber sections amended Drawing moved to A1 sheet	DIH	TG
C1	08.05.07	CONSTRUCTION ISSUE	DIH	TG
T1	20.12.06	TENDER ISSUE	DIH	TG
P1	25.12.06	PRELIMINARY ISSUE	DIH	TG

AMENDMENTS

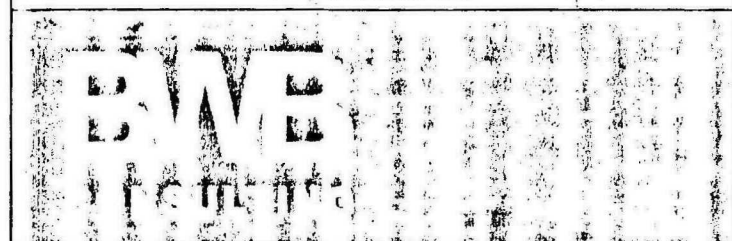

Integrated Engineering
and Environmental Consultants
3-4 Kayes Walk The Lace Market Nottingham NG1 1PY
T 0115 924 1100 F 0115 650 3966 W bwvconsulting.com
environmental | water | transportation | civil | structural | highways | infrastructure

Client
**WELLAND AND DEEPINGS
INTERNAL DRAINAGE BOARD**

Project Title
**PINCHBECK PUMPING
STATION**

Drawing Title
**PUMPING STATION
ELEVATIONS**

Scale	Date	Drawn	Authorised
1:250	OCT 2006	DIH	TG

Drawing Status
CONSTRUCTION

Drawing No	Revision
NTW/076/005	C2

Planning
14 JUN 2010
Ref: C343-1C