

 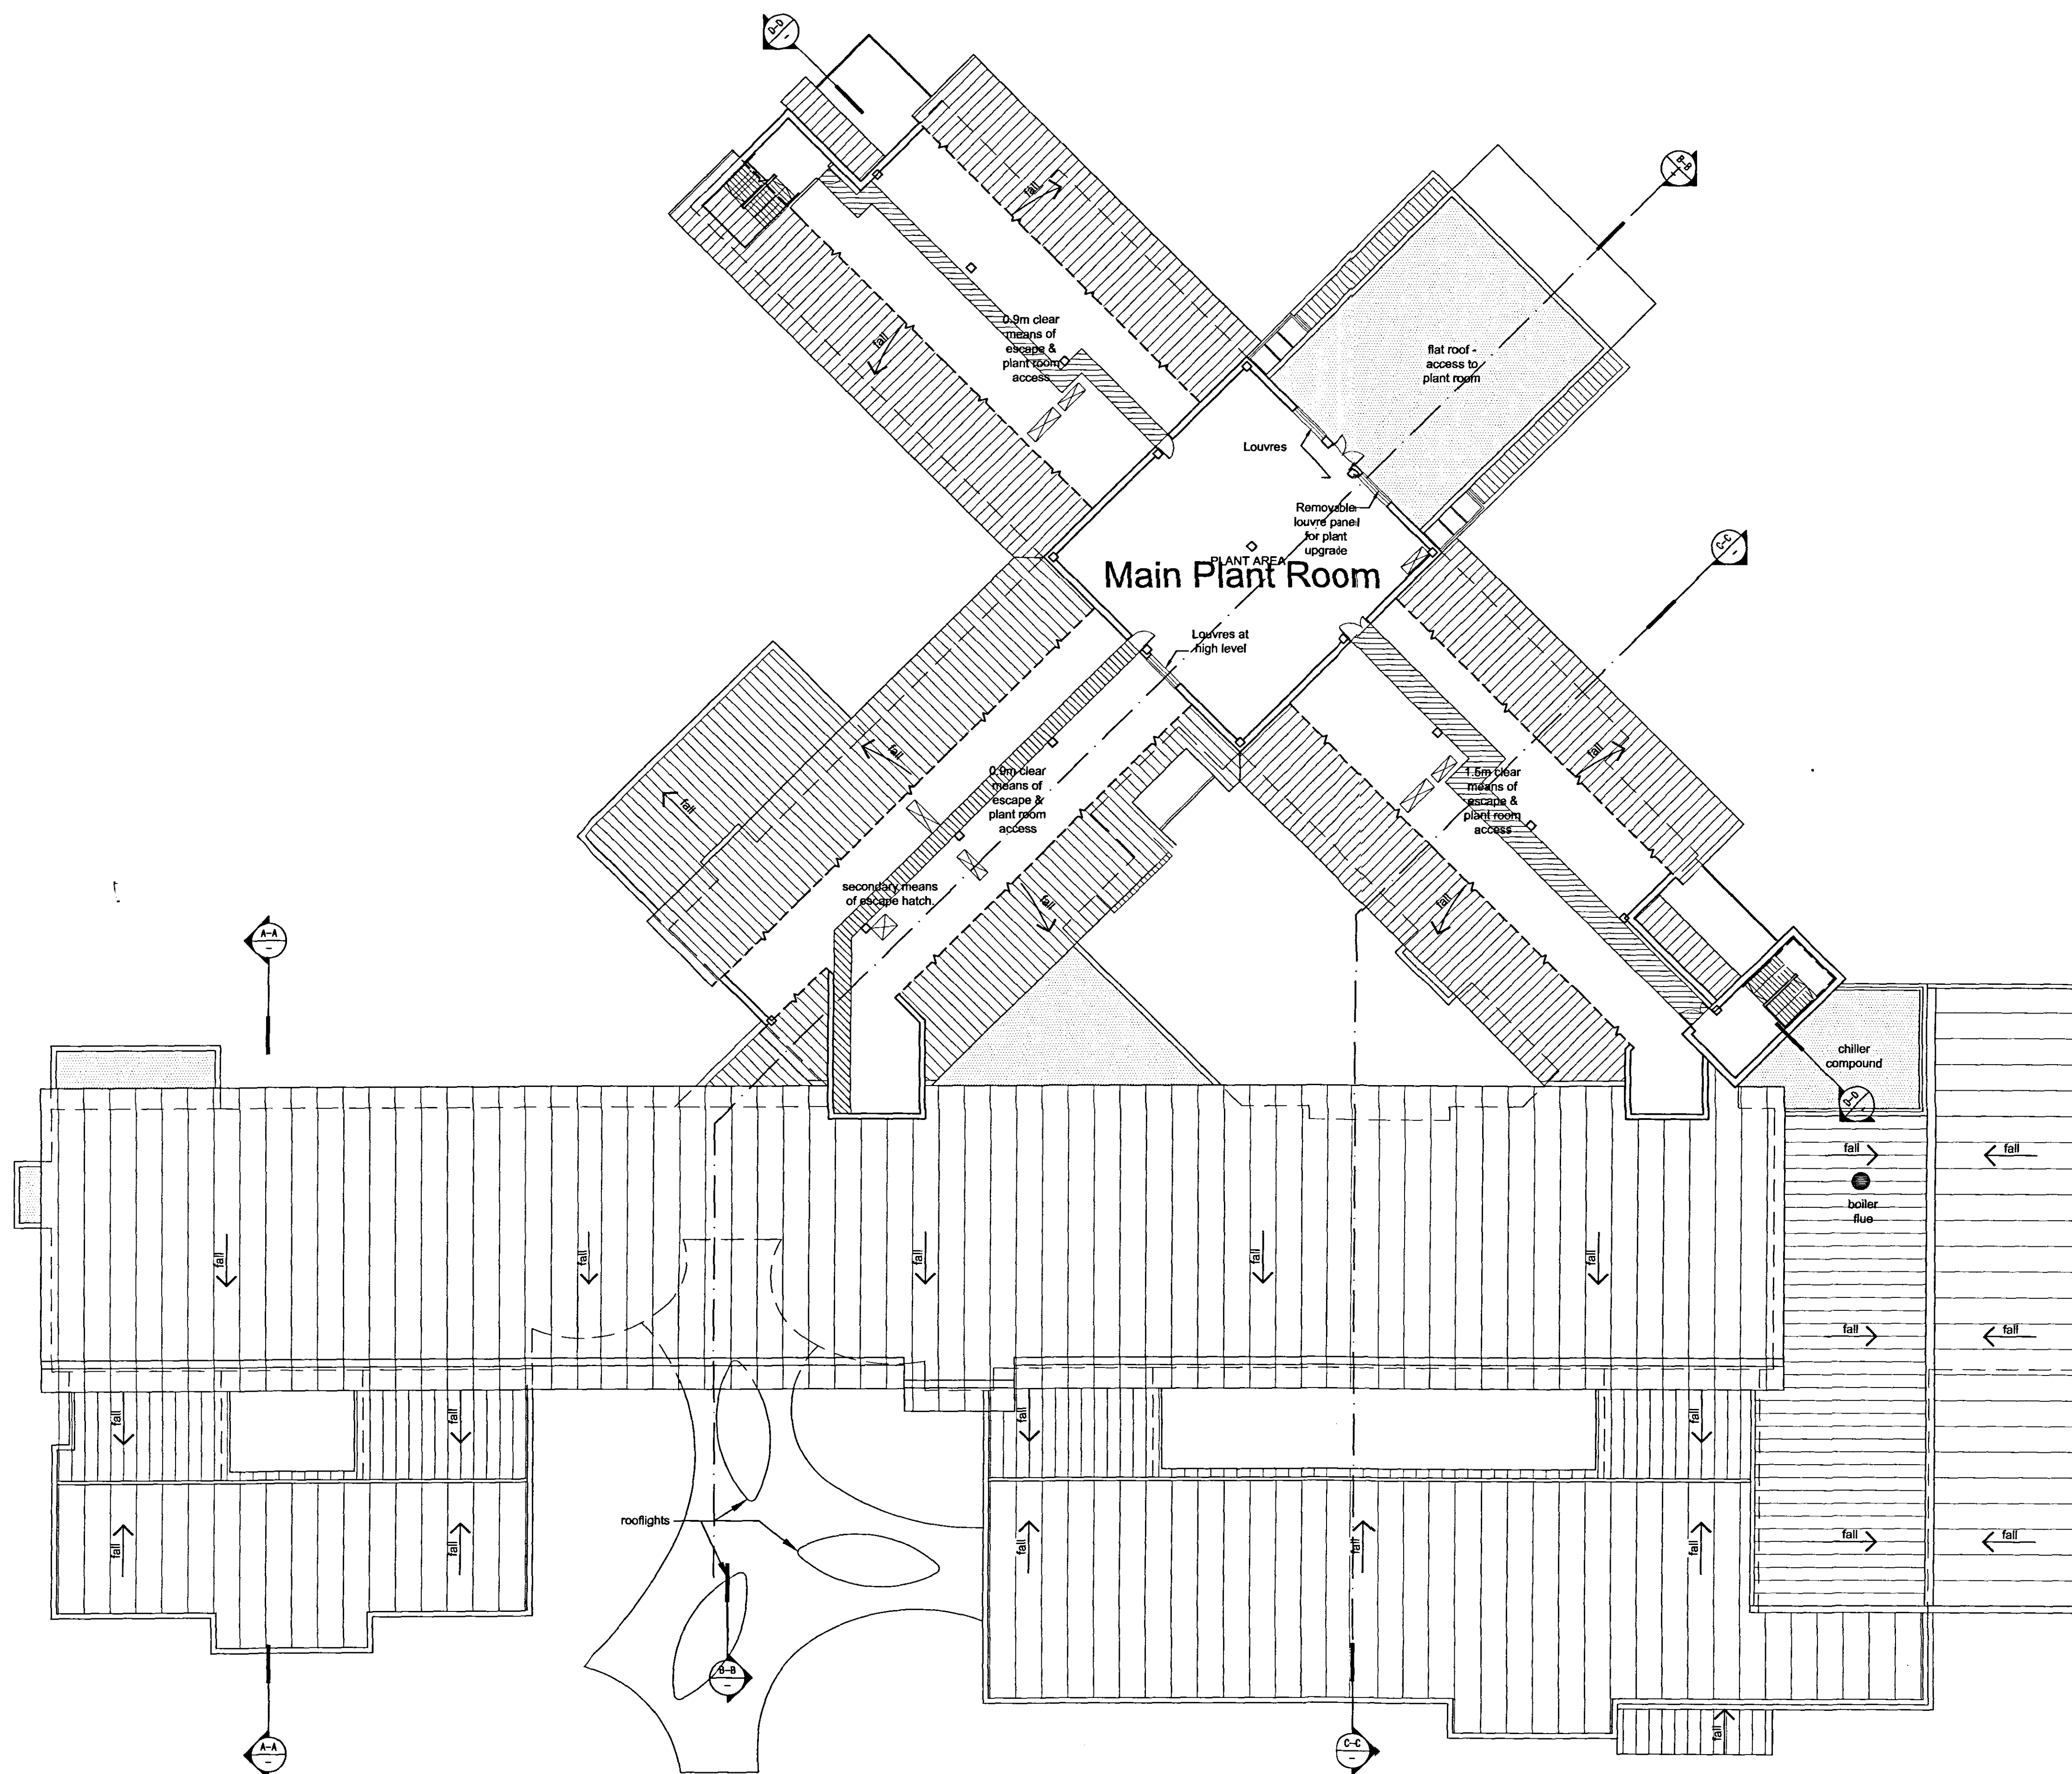


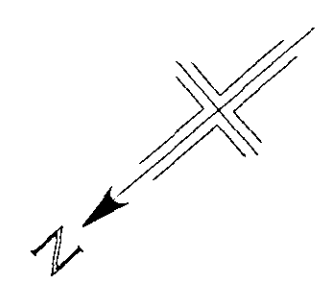

APPROXIMATE NORTH



LEGEND

-  Vertical Communication
-  Main Plant Area (AHU etc.)

**DETERMINED
PLAN**

20 MAR 2006
06/06

SOUTH HOLLAND PROPOSAL

PLANNING APPLICATION

Arden Partnership

WATKINS GRAY INTERNATIONAL LLP
ARCHITECTS PLANNERS INTERIOR DESIGNERS
Colechurch House 1 London Bridge Walk LONDON SE1 2SE
telephone 020 7940 8400 fax 020 7940 8444
Email mail@wgi.co.uk



project SOUTH HOLLAND COMMUNITY HOSPITAL
drawing ROOF PLANT PLAN
date 2006-03-09
scale 1:200@A1
no. 104030/03/P102