



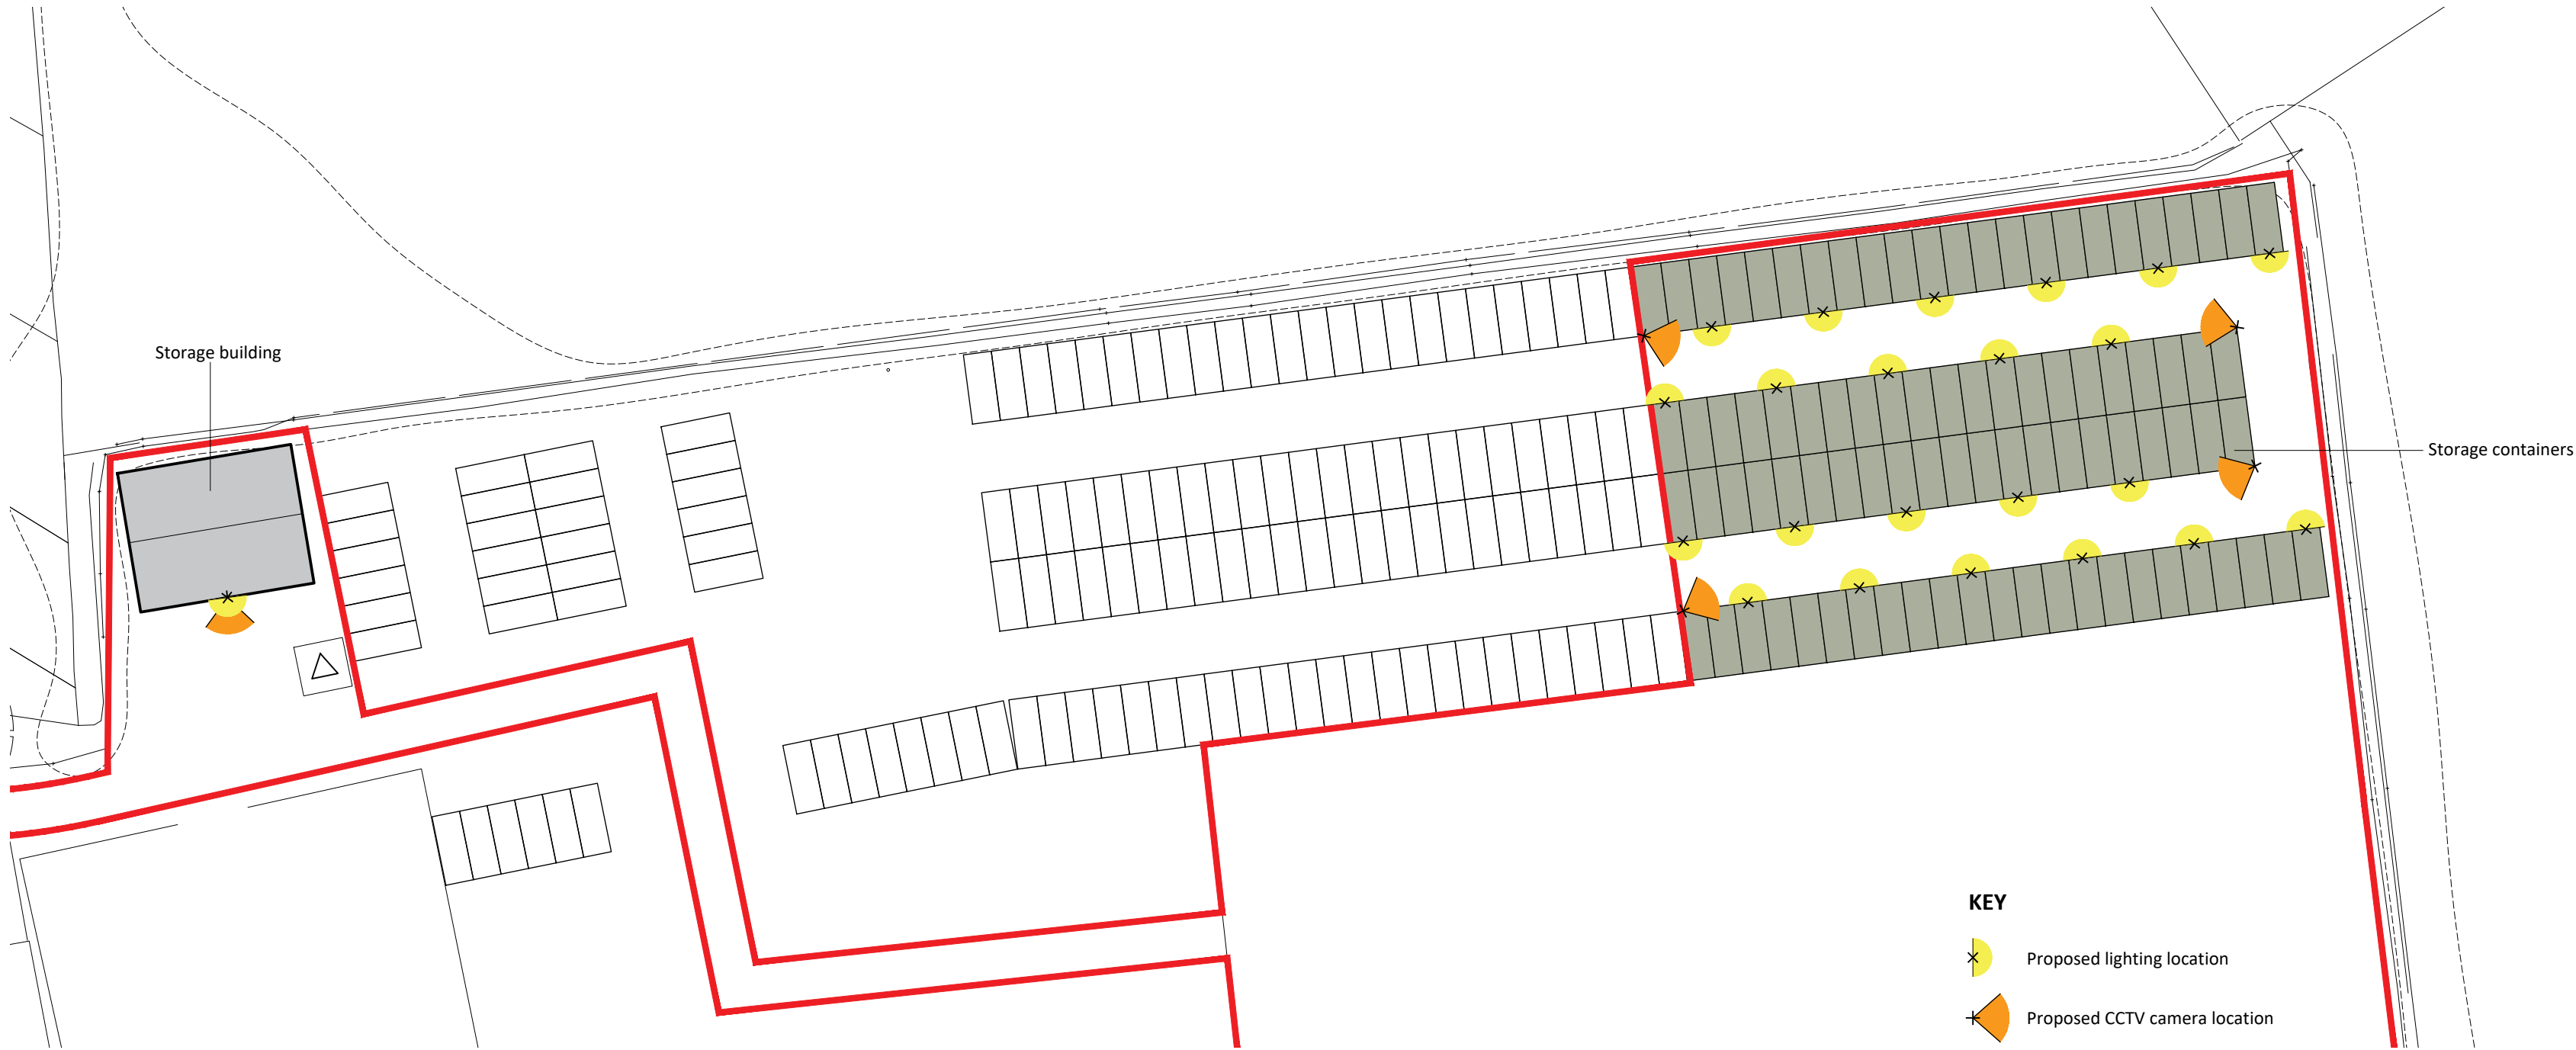

Proposed lighting detail

LED Wallwasher Wall Light 12W IP54 Black (or similar)


Average 130 Lux at 2m
4000K Cool White
IP54 rating
Dimensions 221x91x63mm
Colour: Black
Material: Powder coated aluminium
Non flickering

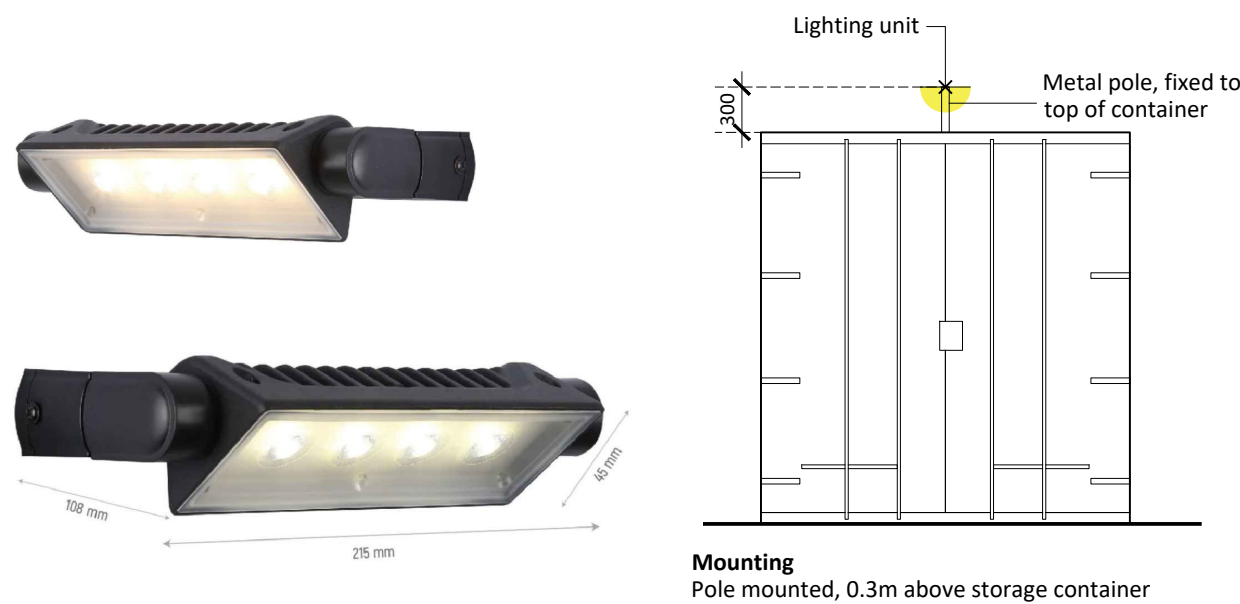

Proposed CCTV camera detail

4K AcuSense Fixed Turret Network Camera (or similar)

8mp resolution
Excellent low light performance
Focus on human and vehicle targets classification based on deep learning
Built-in microphone for real-time audio security
Water and dust resistant
IP67 rating
Dimensions: Ø138.3 mm × 126.3 mm

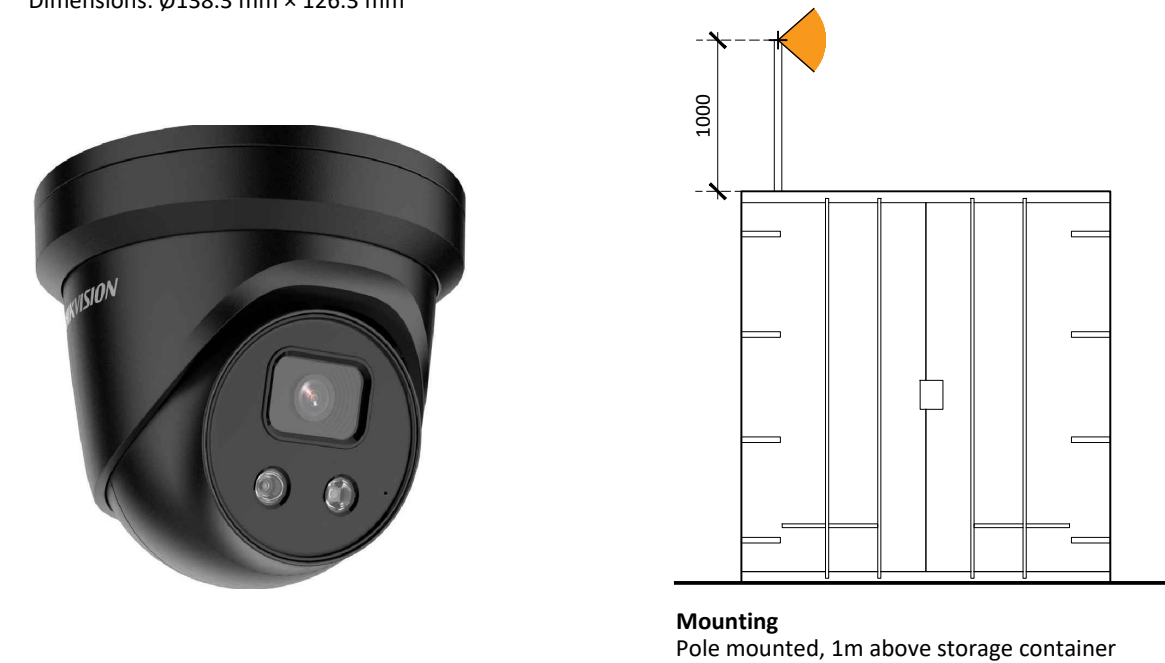

Notes

Copyright
© Robert Doughty Consultancy Limited.
All rights described in the Copyright, Designs and Patents Act 1988 have been asserted.

Ordnance Survey Map
© Crown Copyright. OS Licence No: AR 100010613.

Dimensions
All dimensions shown are for the purposes of obtaining the relevant planning permission only.

CDM 2015
This drawing is for illustrative purposes and/or obtaining the relevant planning permission only. It should not be used for construction and accordingly, risk identification under the Construction (Design & Management) Regulations 2015 has not been undertaken.

N			
0 10 20 30 40 50m			
-	-	-	-
Rev	By	Description	Date

Current revision checked by: -

rdc
Robert Doughty
Consultancy

32 High Street, Helpringham
Sleaford, Lincolnshire, NG34 0RA

Tel: 01529 421646
Email: admin@rdc-landplan.co.uk
Web: www.rdc-landplan.co.uk

Client
Anglia (UK) Ltd

Project
Self storage containers
Mill Green Road, Pinchbeck

Drawing
Proposed Site Plan indicating Lighting & CTV

Scale @ A2 1: 500	Date 13/09/24
-----------------------------	-------------------------

Drawn By NG	Checked By LMS
-----------------------	--------------------------

Job Number 823-31	Status FP	Purpose of Issue Planning
-----------------------------	---------------------	-------------------------------------

Drawing No. 823-31_FP_SP05	Rev -
--------------------------------------	-----------------