

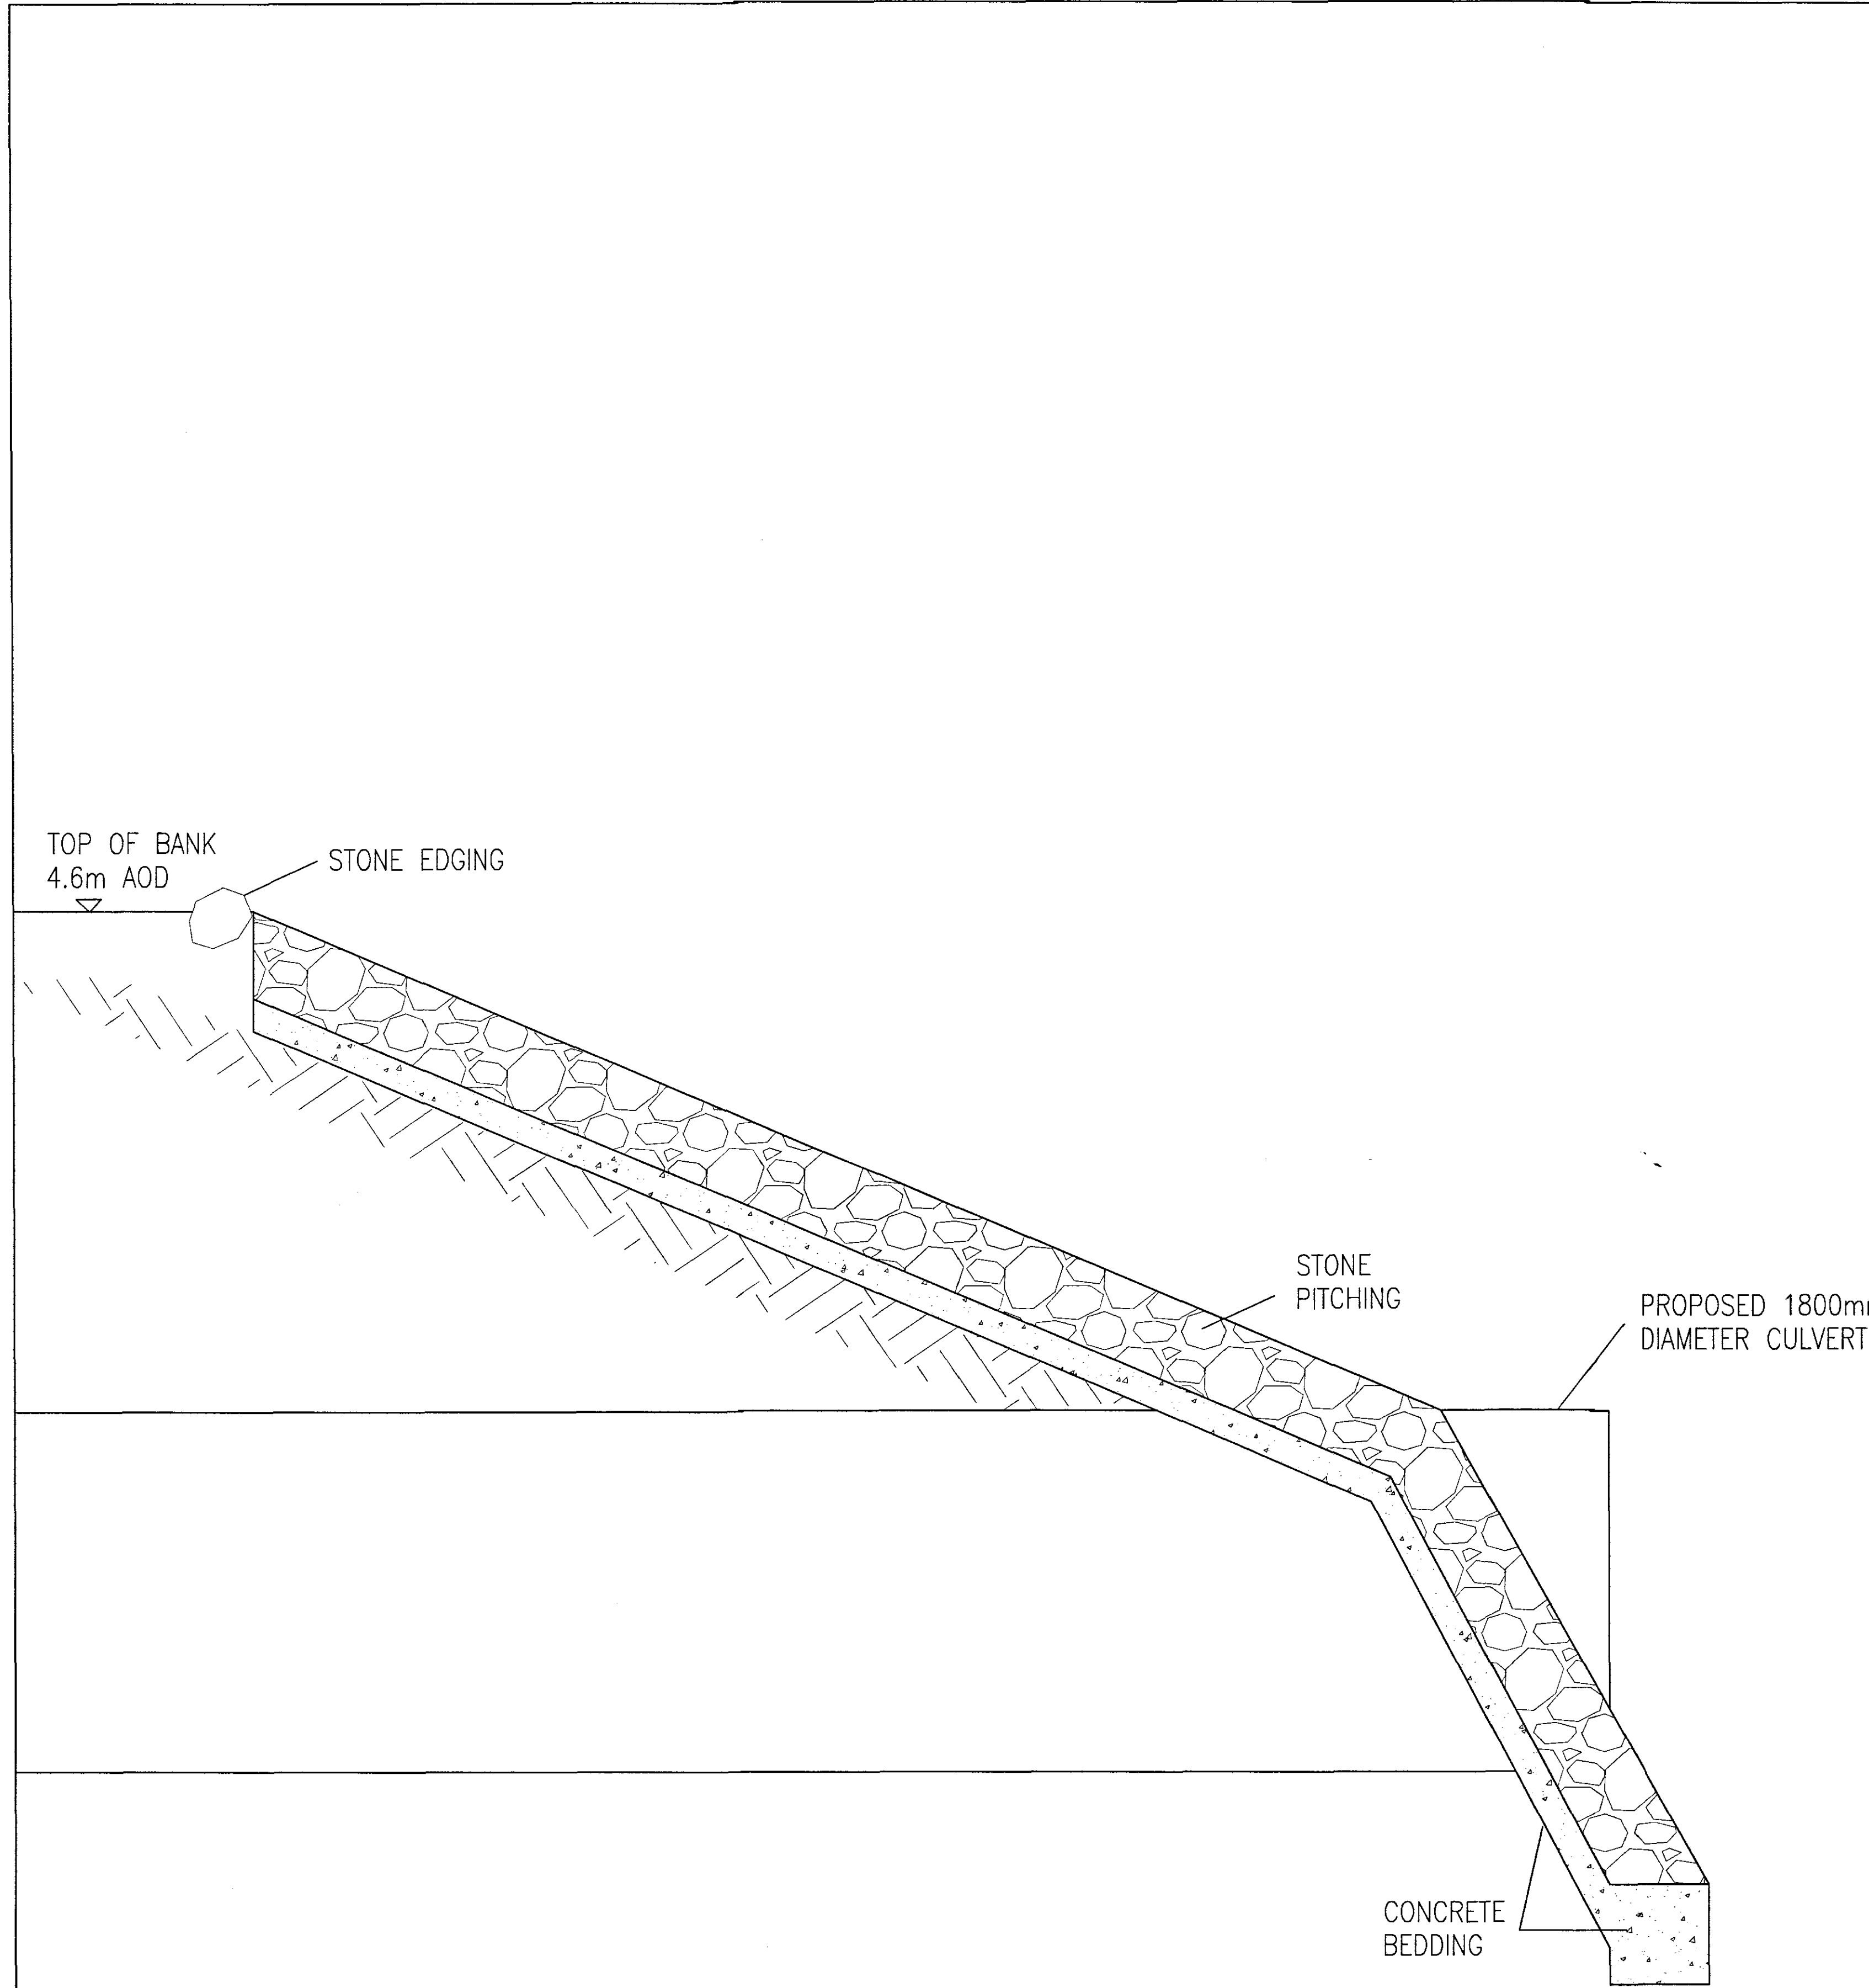


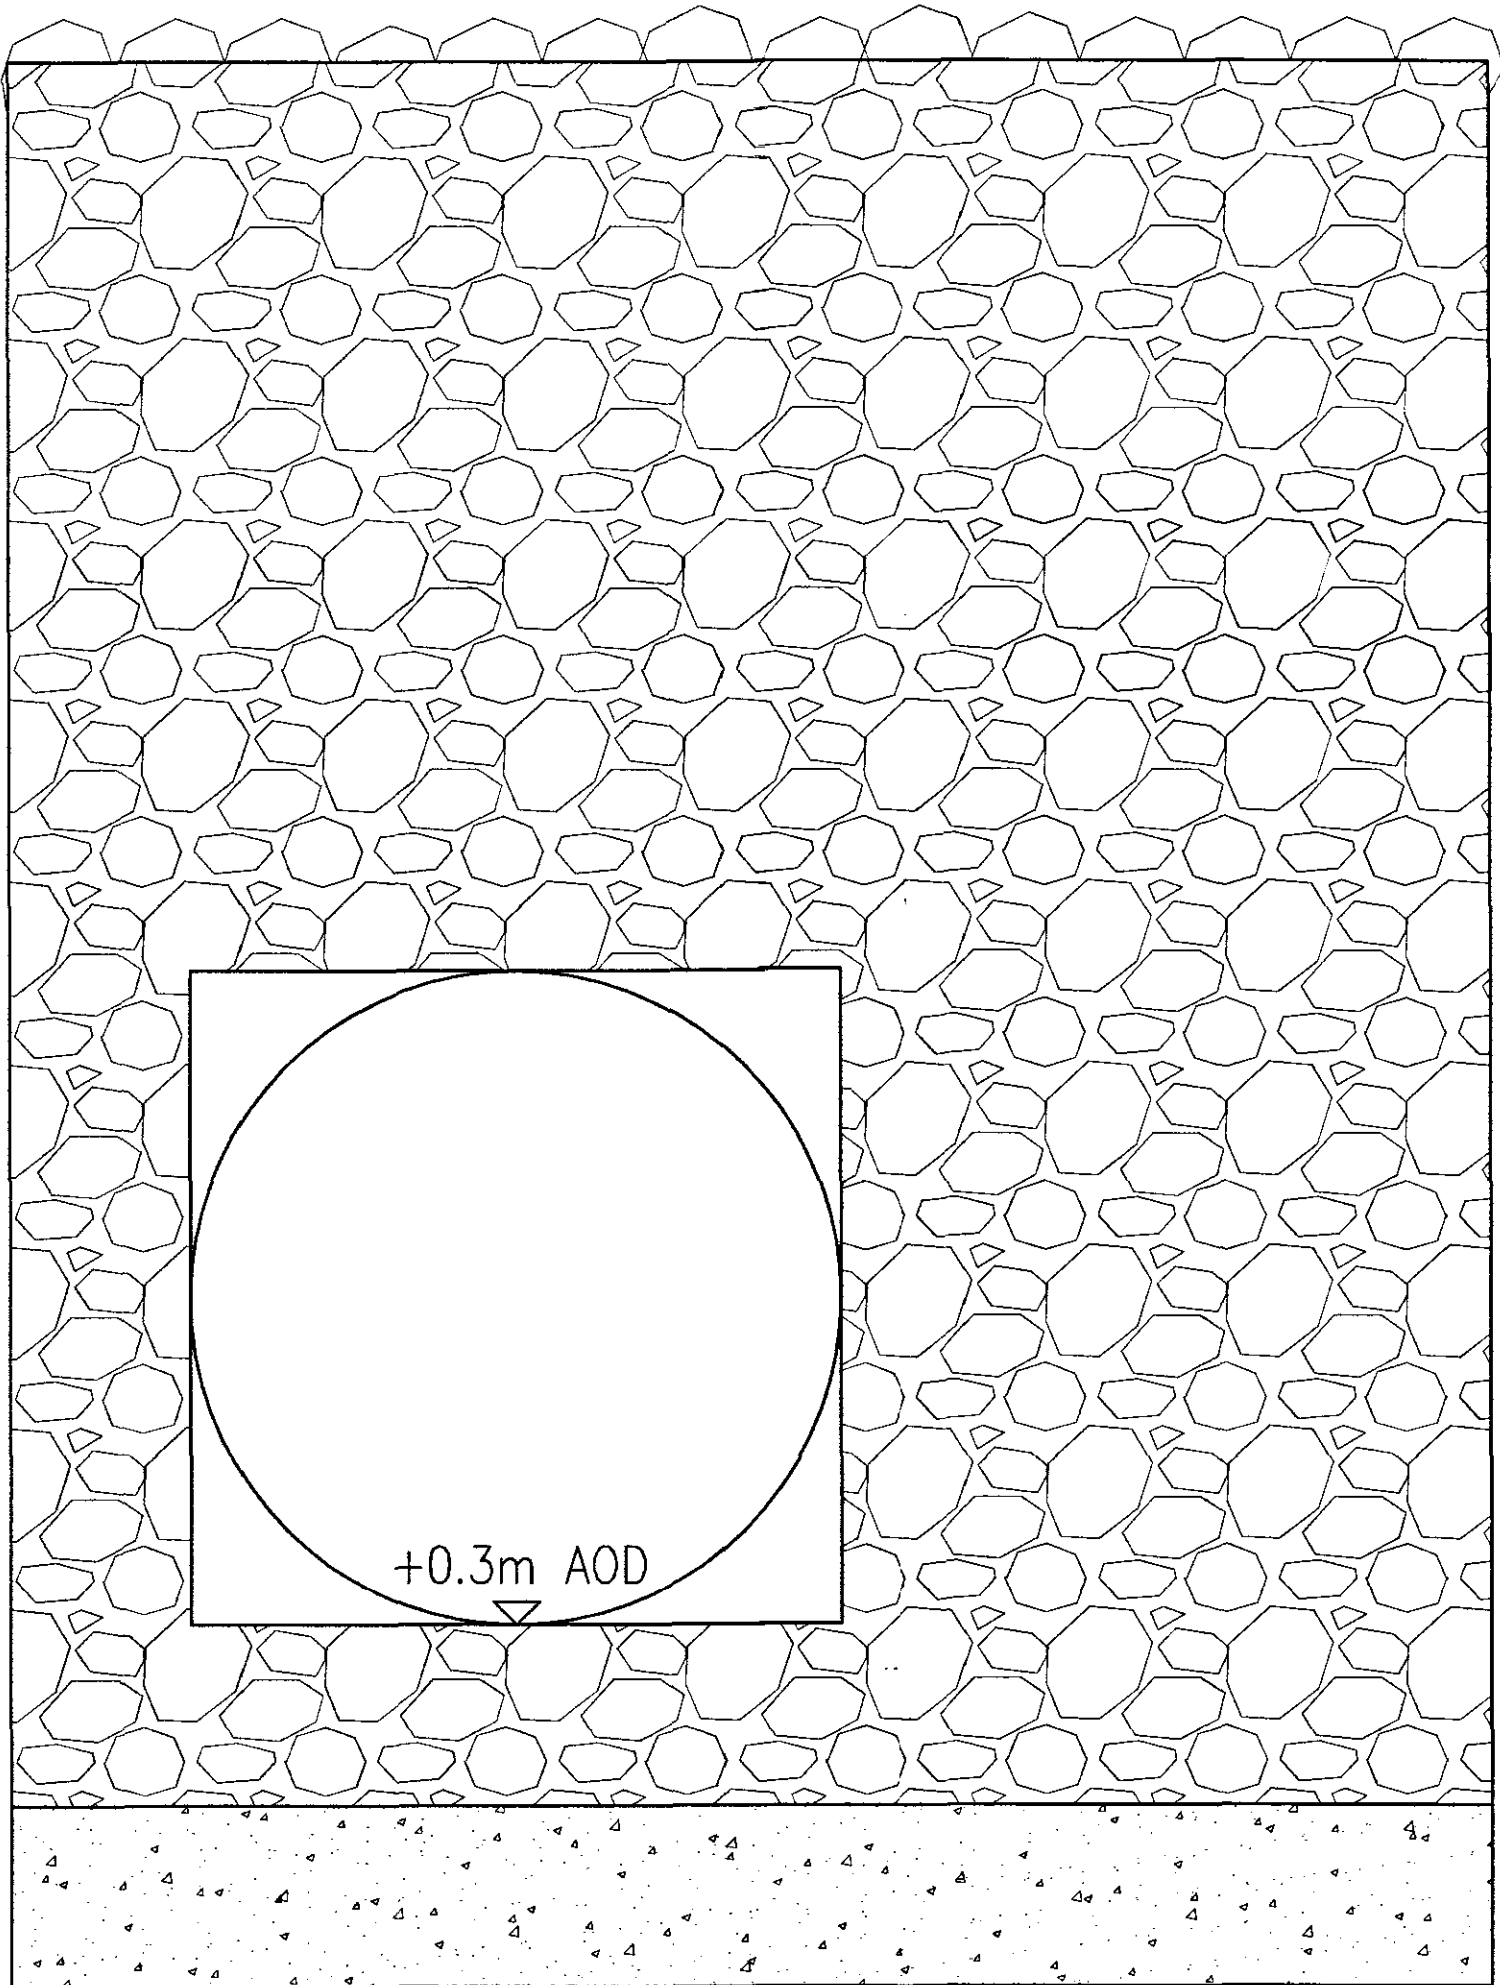

SECTION

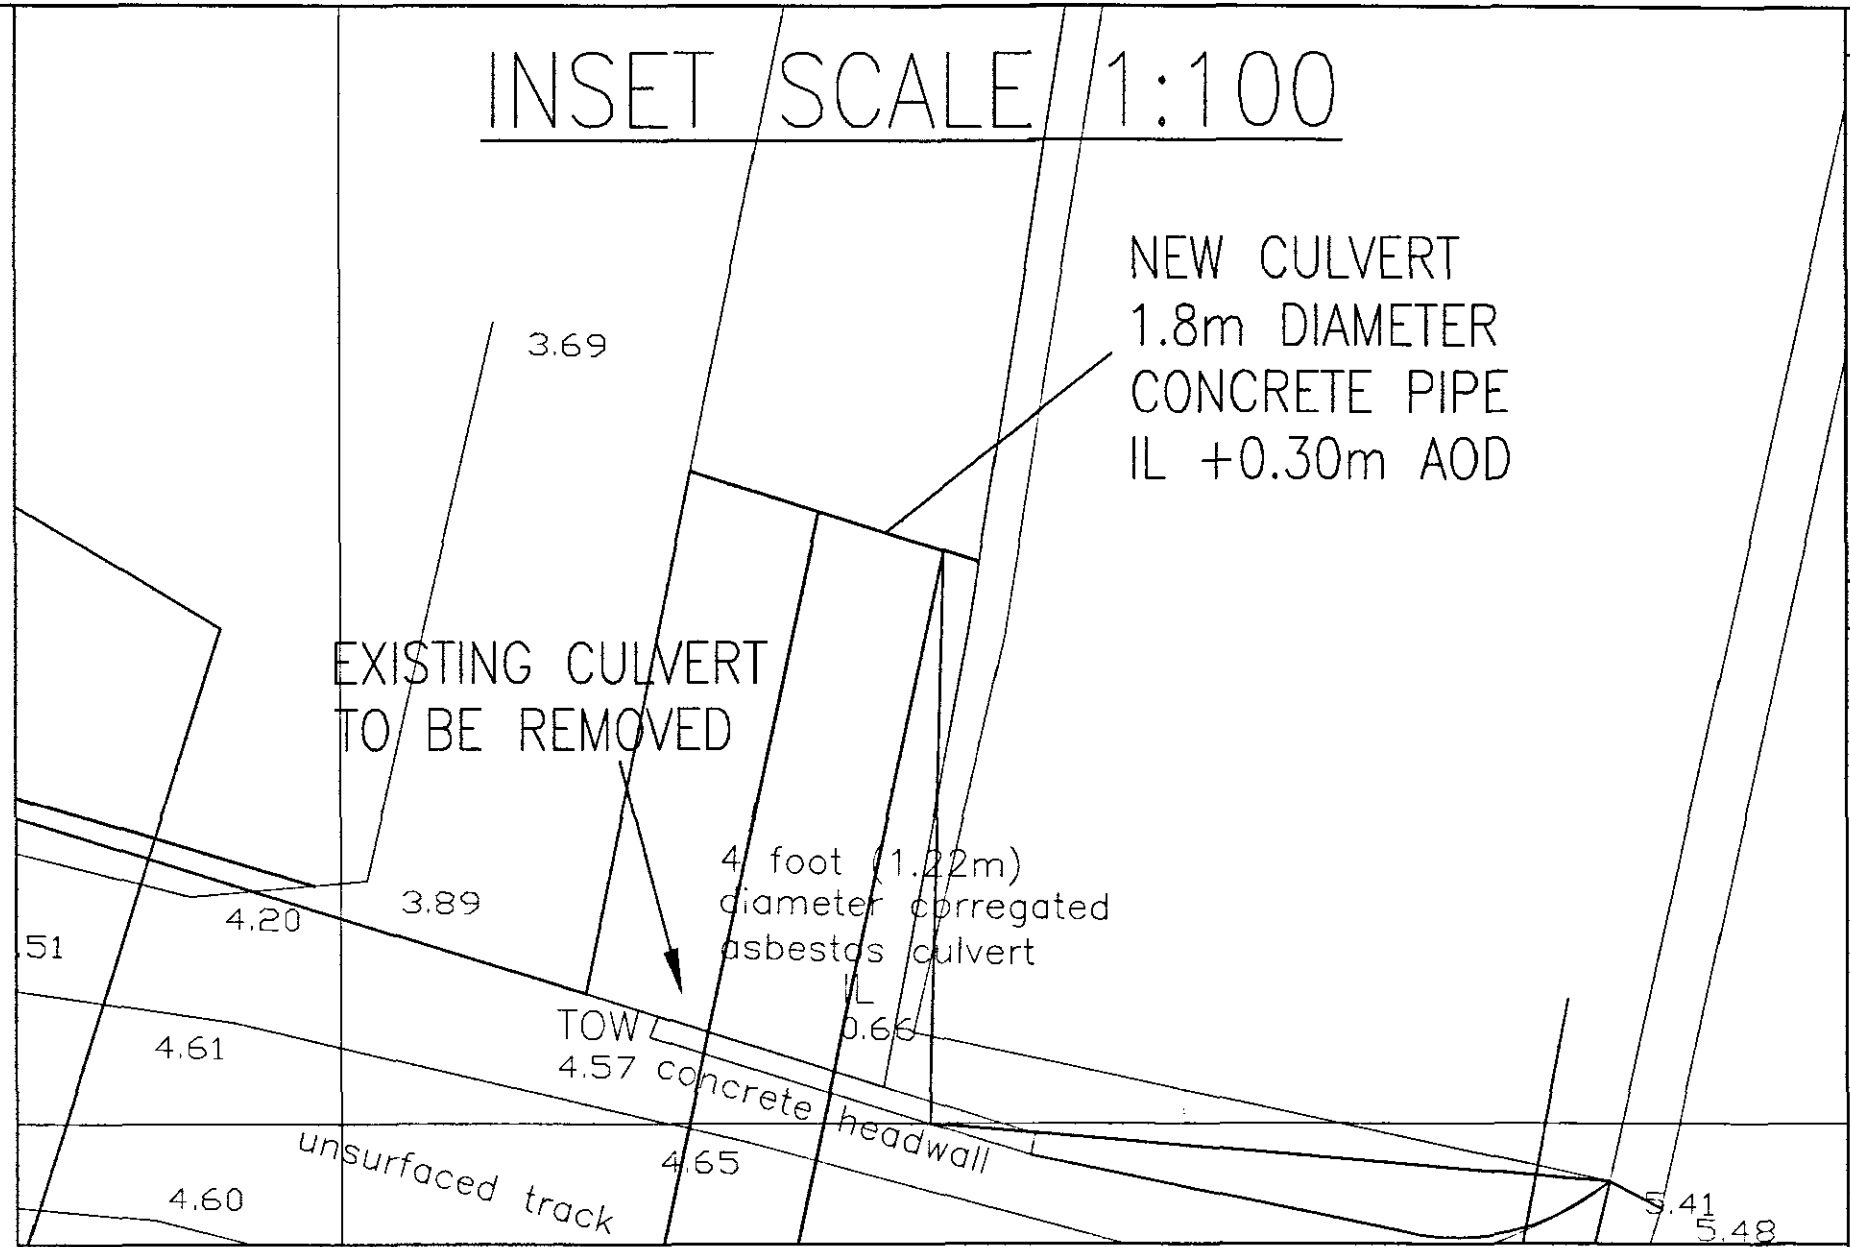

FRONT ELEVATION

- NOTES
1. DO NOT SCALE THIS DRAWING. ALL DIMENSIONS MUST BE CHECKED/ VERIFIED ON SITE. IF IN DOUBT ASK.
 2. THIS DRAWING IS TO BE READ IN CONJUNCTION WITH ALL RELEVANT ARCHITECTS, ENGINEERS AND SPECIALISTS DRAWINGS AND SPECIFICATIONS.
 3. ALL DIMENSIONS IN MILLIMETRES UNLESS NOTED OTHERWISE. ALL LEVELS IN METRES UNLESS NOTED OTHERWISE.
 4. ANY DISCREPANCIES NOTED ON SITE ARE TO BE REPORTED TO THE ENGINEER IMMEDIATELY.

KEY

Rev	Date	Description	Drawn	Auth'd
C1	20.09.07	PLANNING CONSTRUCTION ISSUE	DIH	TG
P1	17.09.07	PRELIMINARY ISSUE	DIH	TG

AMENDMENTS

BWB CONSULTING

Integrated Engineering and Environmental Consultants

3-4 Kayes Walk The Lace Market Nottingham NG1 1PY
T 0115 924 1100 F 0115 950 3966 W bwbconsulting.com

environmental | water | transportation | civil | structural | highways | infrastructure

Client **WELLAND AND DEEPINGS**
INTERNAL DRAINAGE BOARD

Project Title
PINCHBECK PUMPING STATION

Drawing Title
UPSTREAM HEADWALL DETAIL (1800mm CULVERT)

Scale	Date	Drawn	Authorised
1:20	AUG 2007	DIH	TG

Drawing Status
CONSTRUCTION

Drawing No:	Revision
NTW/076/SK04	C1