
 



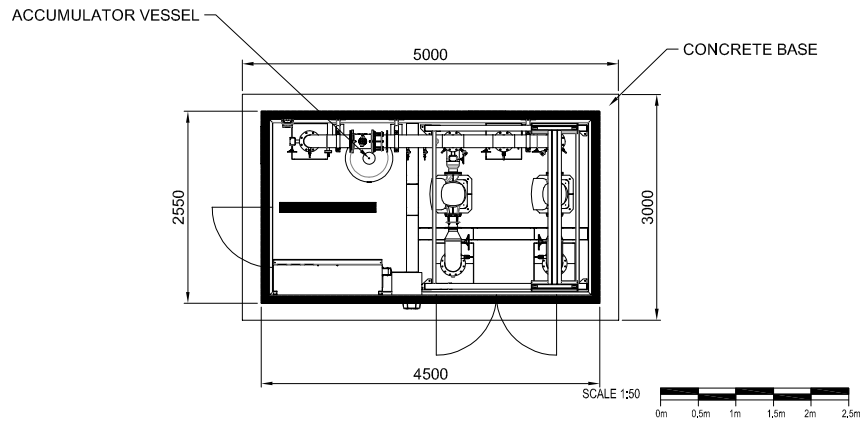


KIOSK PLAN LAYOUT (ROOF REMOVED)
SCALE 1:50




KIOSK - PLAN VIEW
SCALE 1:50

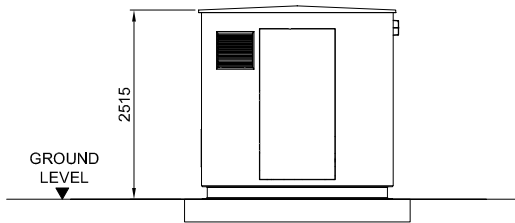


GRP KIOSK - LEFT SIDE VIEW
SCALE 1:50

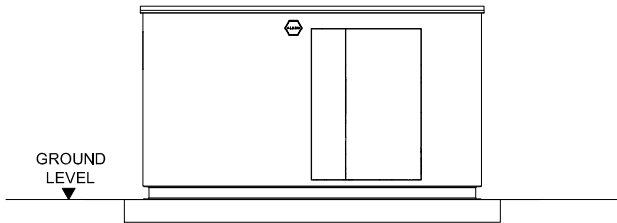

GRP KIOSK - FRONT ELEVATION VIEW
SCALE 1:50

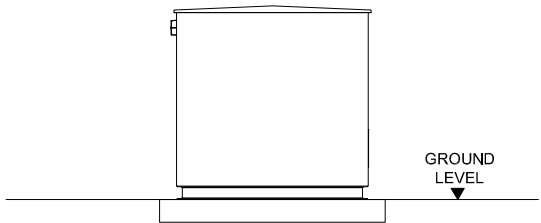

KIOSK ELEVATION - RIGHT SIDE VIEW
SCALE 1:50

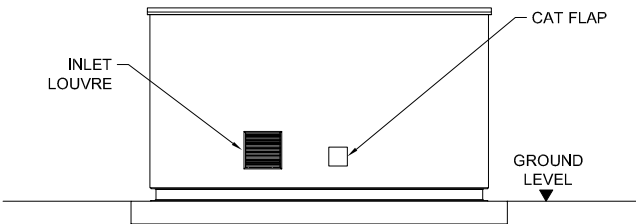

GRP KIOSK - BACK ELEVATION VIEW
SCALE 1:50

CLIENT		CLIENT REF NO.		SHEET SIZE	
ANGLIAN WATER SERVICES		WAT - 07144		A1	
SCHEME		PROJECT NO.		MAIN SCALE	
DONINGTON WB		16617		1:50	
TITLE		DRAWING NO.		ISSUE	
GRP KIOSK VIEWS		16617-2-003		2P	
PROVISIONAL ISSUE - SLIGHT MODS		WS	16.03.20	TC	SR 2P
FIRST ISSUE		WS	10.03.20	TC	SR 1P
DESCRIPTION		DRAWN	DATE	ENG APPR	ISSUE
Copyright FLI Water 2020					
		FLI water			