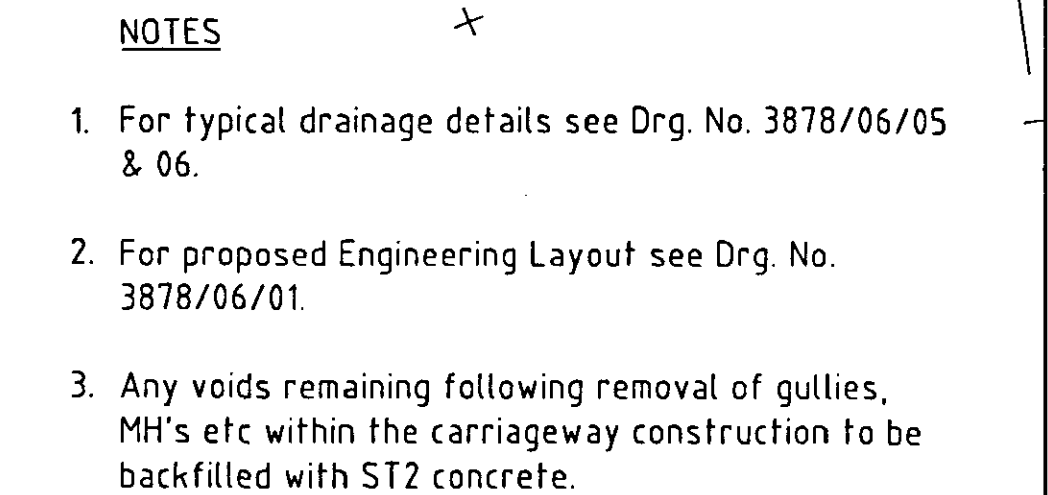


[illegible]

LONG SECTION
(H=1:500, V=1:50)

		0082/06		
A	REVISED IN ACCORDANCE WITH A.W. REQUIREMENTS		dc	19.10.05
Ref.	Amendment		Ch'kd	Date
			Stirling Maynard & Partners, Consulting Engineers, Stirling House, Rightwell, Bretton, Peterborough, PE3 8DJ Telephone: 01733 262319 Fax: 01733 331527 Email: enquiries@stirlingmaynard.com	
Client				
INTERGEN (UK) LTD			DETERMINED PLAN	
Scheme Title				
SPALDING ENERGY PROJECT 840 MW COMBINED CYCLE PLANT				
Drawing Title				
SOUTHERN DEVELOPMENT AREA PROPOSED JUNCTION DRAINAGE LAYOUT				
Project Manager		DR HALL	Drawing Status	
Drawn SMA/SA		Traced N/A	S278	
Checked PFC		Scale As Shown	Drawing No.	
Date 30/08/05		@ A1	3878/06/07A	