




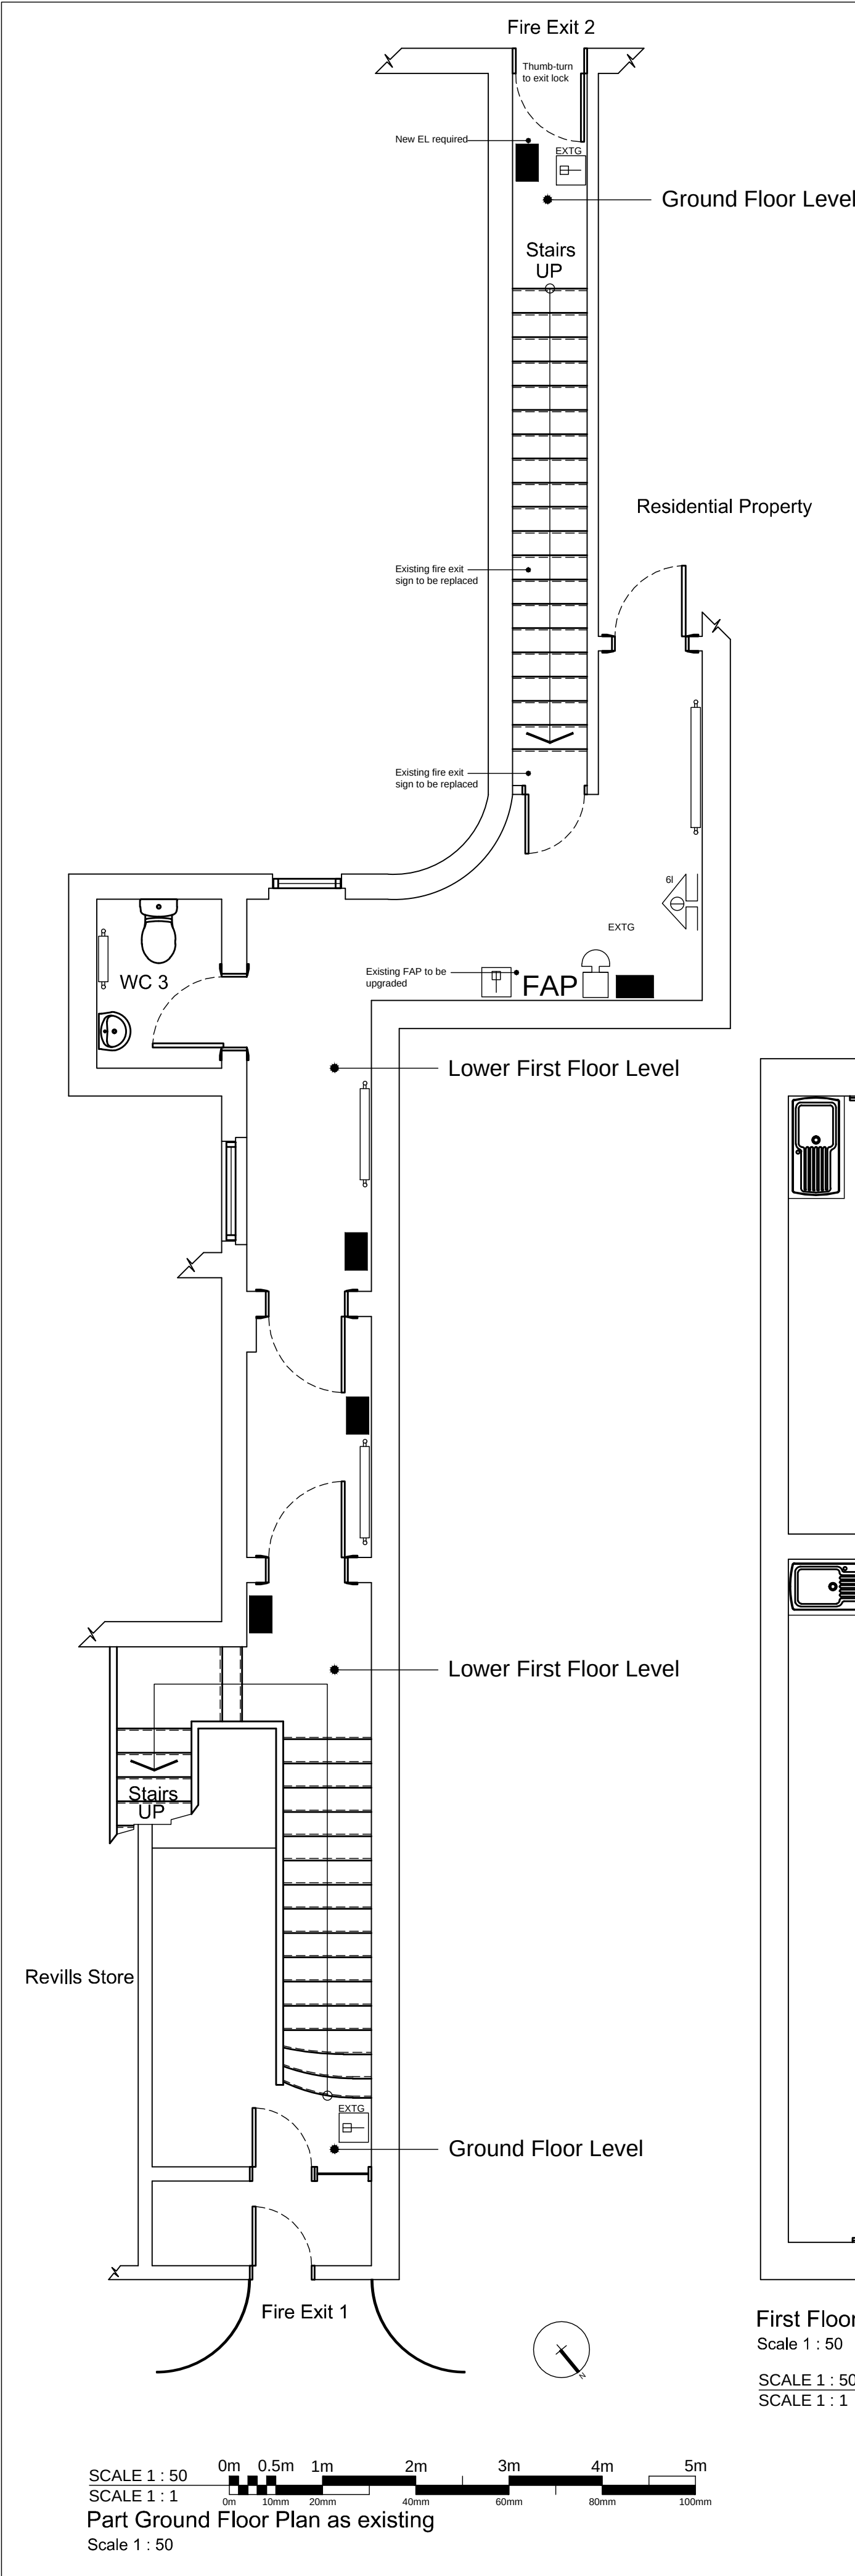

fire safety details	
	Emergency Lighting (Refer to Services Engineers Design & spec).
	Emergency Lighting Over Fire Exits (Refer to Services Engineers Design & Spec).
FAP	Fire Alarm Zoning (Master) Panel
	Fire Extinguisher (Water)
	Fire Extinguisher (Foam)
	Fire Blanket
S	Detector (smoke) Not shown (Refer to Services Engineers Design & Spec).
K	Detector (heat) Not shown (Refer to Services Engineers Design & Spec).
	"Break Glass" fire alarm call point (manual)
	Audible alarm.
S 22	"Fire Exit" sign

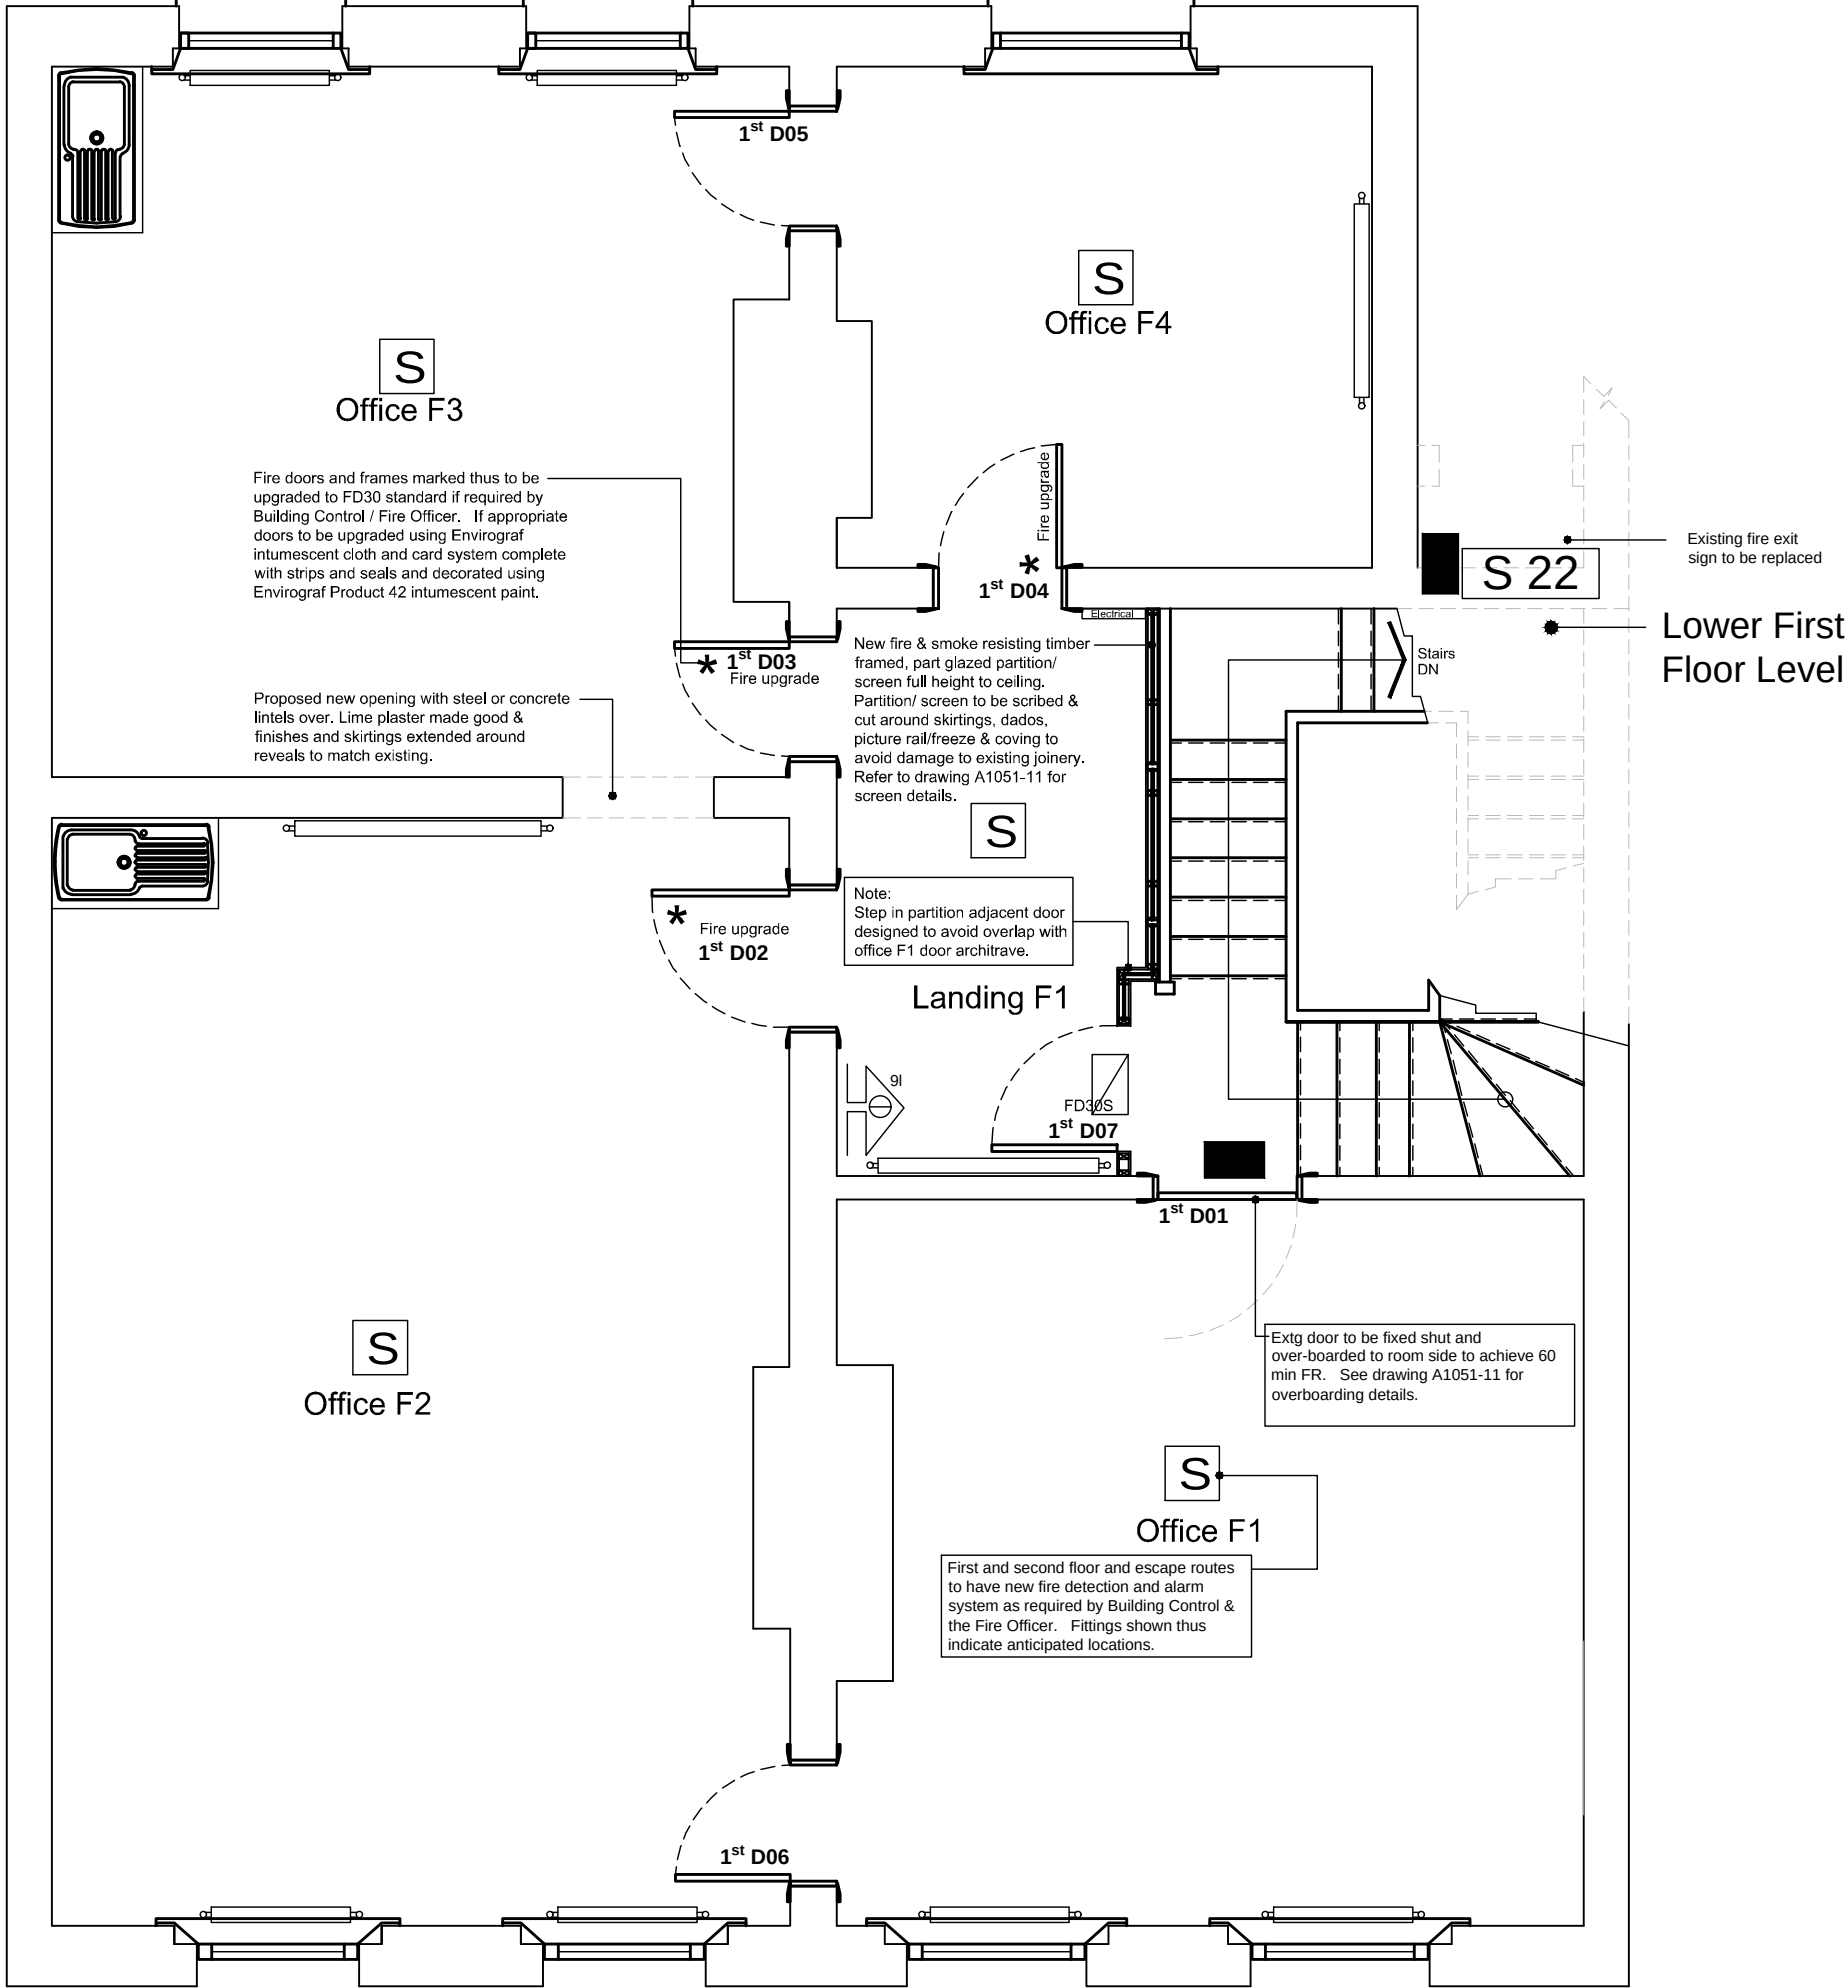

First Floor Plan as proposed
Scale 1 : 50
SCALE 1 : 50
SCALE 1 : 1

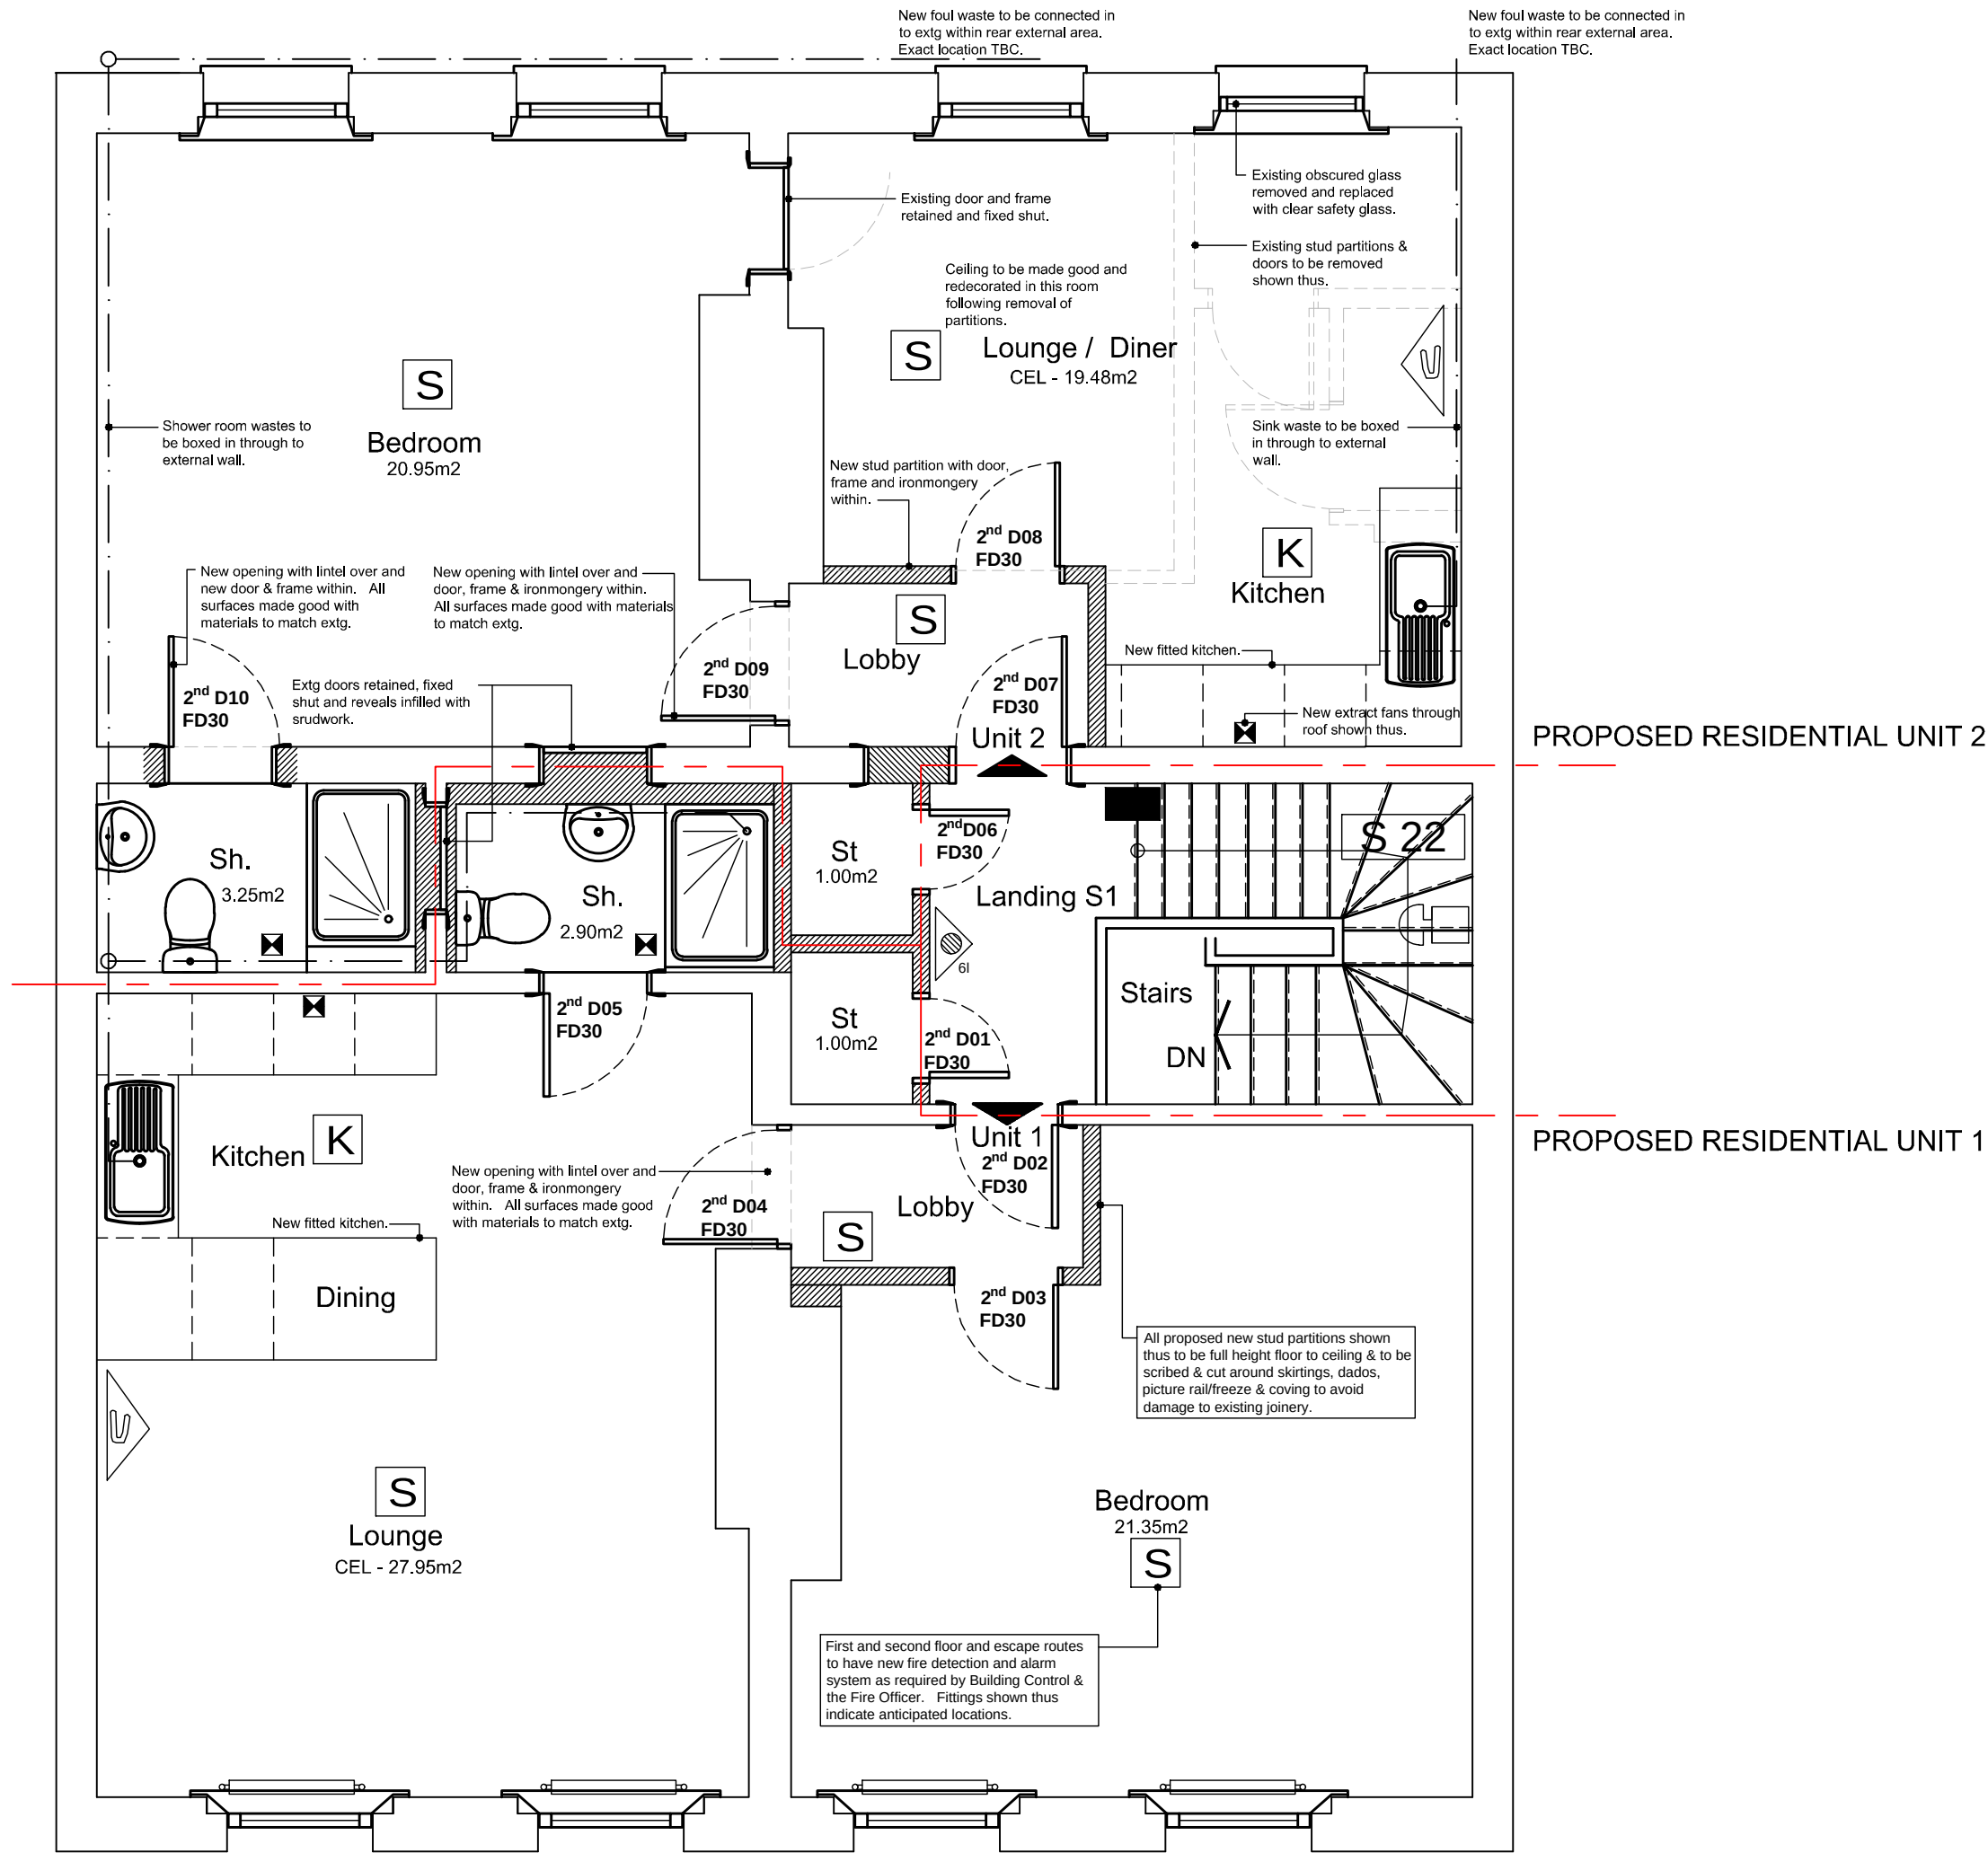

Second Floor Plan as proposed
Scale 1 : 50
SCALE 1 : 50
SCALE 1 : 1

DO NOT SCALE THIS DRAWING. THE CONTRACTOR IS DEEMED TO HAVE CHECKED ALL DIMENSIONS ON SITE AND REPORT ANY DISCREPANCIES TO OGLESBY & LIMB LTD. THE CONTENTS OF THIS DRAWING ARE COVERED BY COPYRIGHT AND REMAIN THE PROPERTY OF OGLESBY & LIMB LTD. WRITTEN APPROVAL MUST BE OBTAINED FROM OGLESBY & LIMB LTD PRIOR TO DUPLICATION OR REPRODUCTION OF THIS DRAWING OR ITS CONTENTS. ANY DIMENSIONS NOT SHOWN ARE TO BE CHECKED AND AGREED WITH OGLESBY & LIMB LTD.

XX	XX.XX.XX	XXXXXX	LS
Ref.	Date	Description	Initial
Oglesby & Limb Ltd			
Chartered Architect			
Suites 4 & 5, Market Chambers 12 Market Place, Spalding, Lincs PE11 1SL			
Tel: 01775 761196			
e-mail: design@o-ltd.co.uk			

Client:
Mr N Revill

Project:
**Proposed alterations to
12 Market Place
Spalding
Lincolnshire
PE11 1SL**

Drawing Title:
**Fire strategy layout drawing as
proposed**
PRELIMINARY FOR COMMENT

Date:	24.03.16	Scale:	1:50 @ A1
Drawn by:	LS	Checked by:	AJO

Drawing Number:	Rev:
A1051 - 12	-