


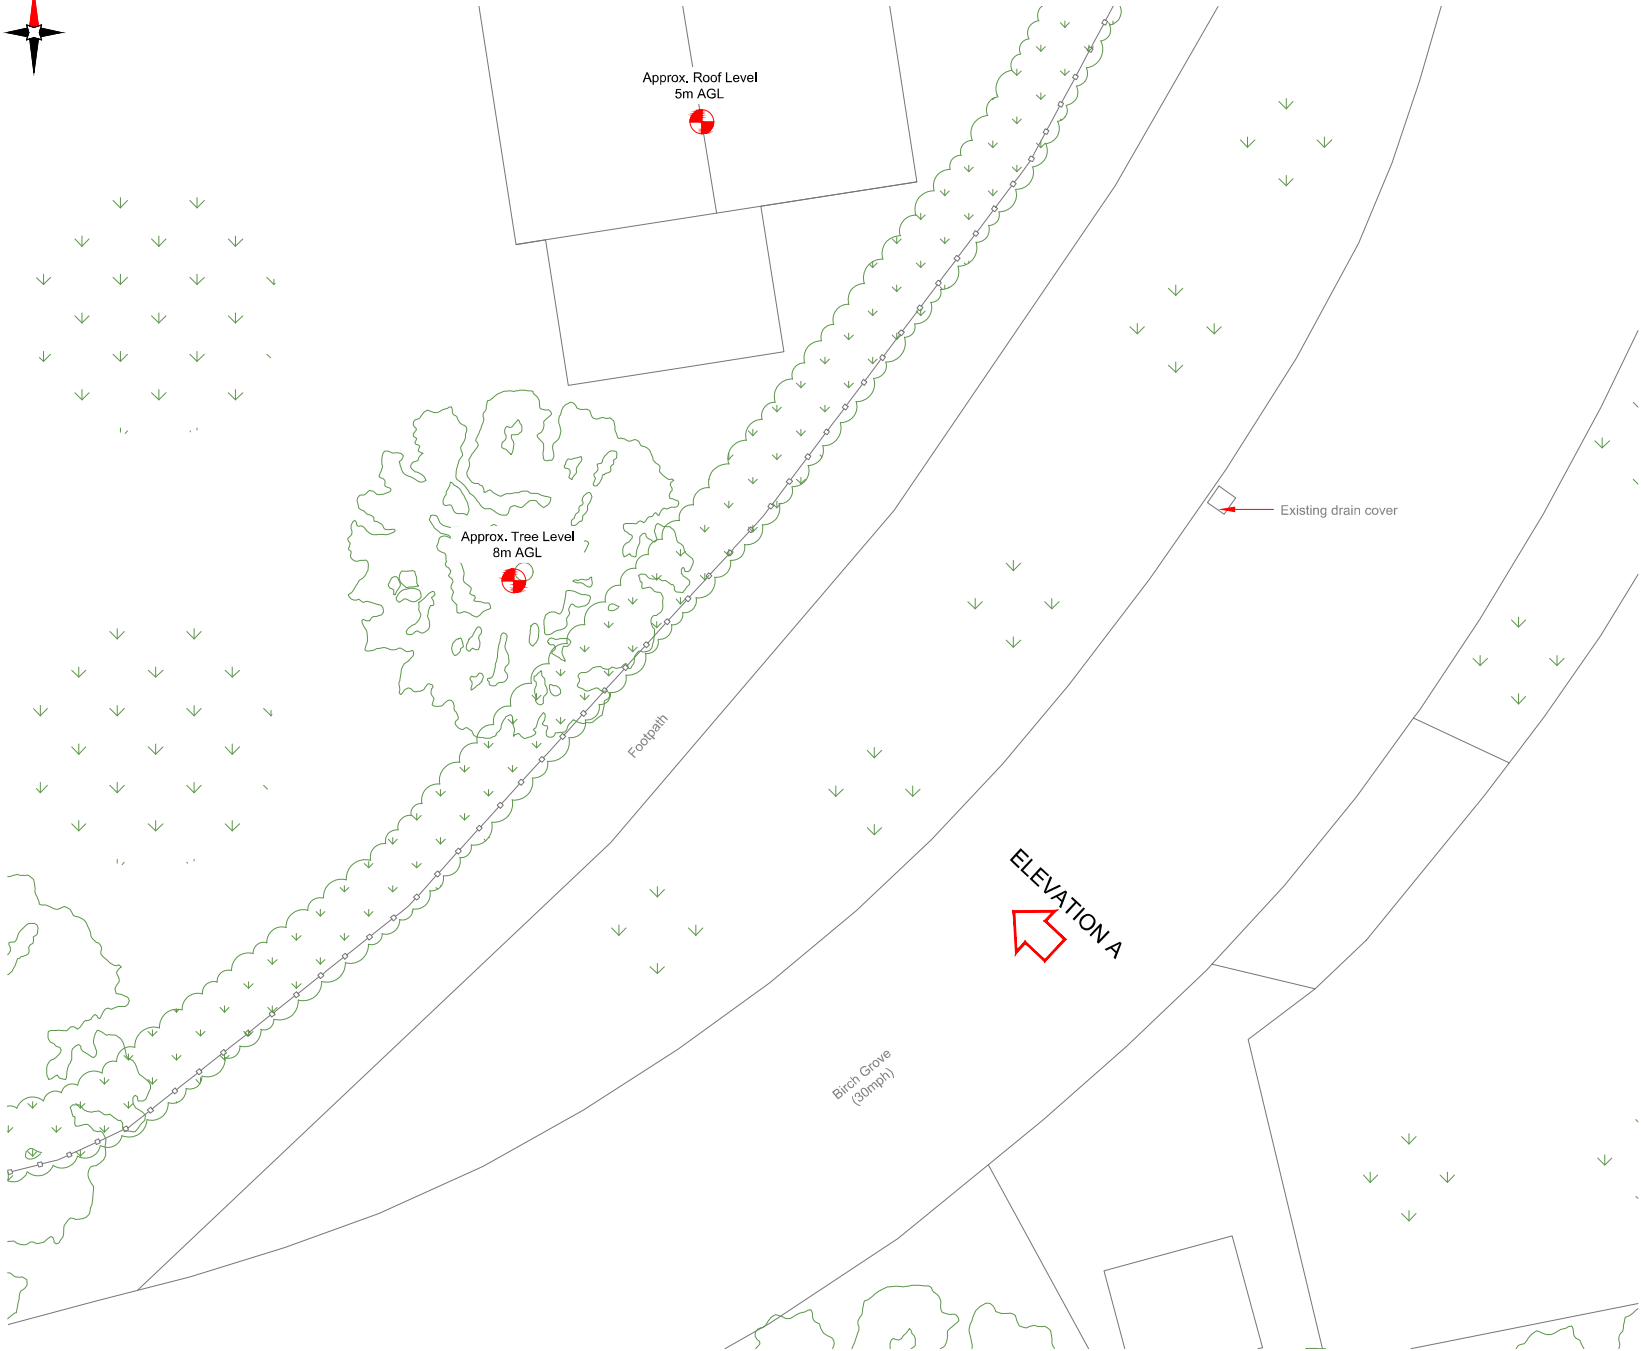

NOTES:

1. ALL DIMENSIONS IN MM UNLESS OTHERWISE NOTED.

Master:	MBNL / EE:	Project:	Purpose of Issue:	Issue:
M003	MBNL	3UK DNSW	Planning	C
Date:	06/02/2023	Revision / Upgrade Description:		
Drawn:	CDN	Pole location amended		
Checked:	DH			
Approved:	SD			
Master:	MBNL / EE:	Project:	Purpose of Issue:	Issue:
M002	MBNL	3UK DNSW	Planning	B
Date:	01/02/2022	Revision / Upgrade Description:		
Drawn:	CDN	Amended		
Checked:	DH			
Approved:	SD			
Master:	MBNL / EE:	Project:	Purpose of Issue:	Issue:
M001	MBNL	3UK DNSW	Planning	A
Date:	01/02/2021	Revision / Upgrade Description:		
Drawn:	CDN	First Issue - Site nomination dated: TBC		
Checked:	DH			
Approved:	SD			

**CK Hutchison
Networks (UK)
Limited**
Green Park
450 Longwater Avenue
Reading
RG30 3UR

Design Consultant & Principal Contractor:



WHP Telecoms
Unit 1 Maple Park,
Low Fields Avenue, Leeds
LS12 6HH
Tel: 01133023550
e-mail: info@whptelecoms.com

Site Name:
BIRCH GROVE STREETWORKS

Site ID:
SHO16420

Address:
**BIRCH GROVE,
SPALDING,
LINCOLNSHIRE,
PE11 2HL**

Title:
100 EXISTING SITE PLAN

Project:
3UK DNSW

Purpose of Issue:
PLANNING

EE Cell ID:	MBNL Cell ID:	Cell ID:
81488	SHO032	PE0693

Master Drawing No:	Issue:
SHO16420_M003	C