


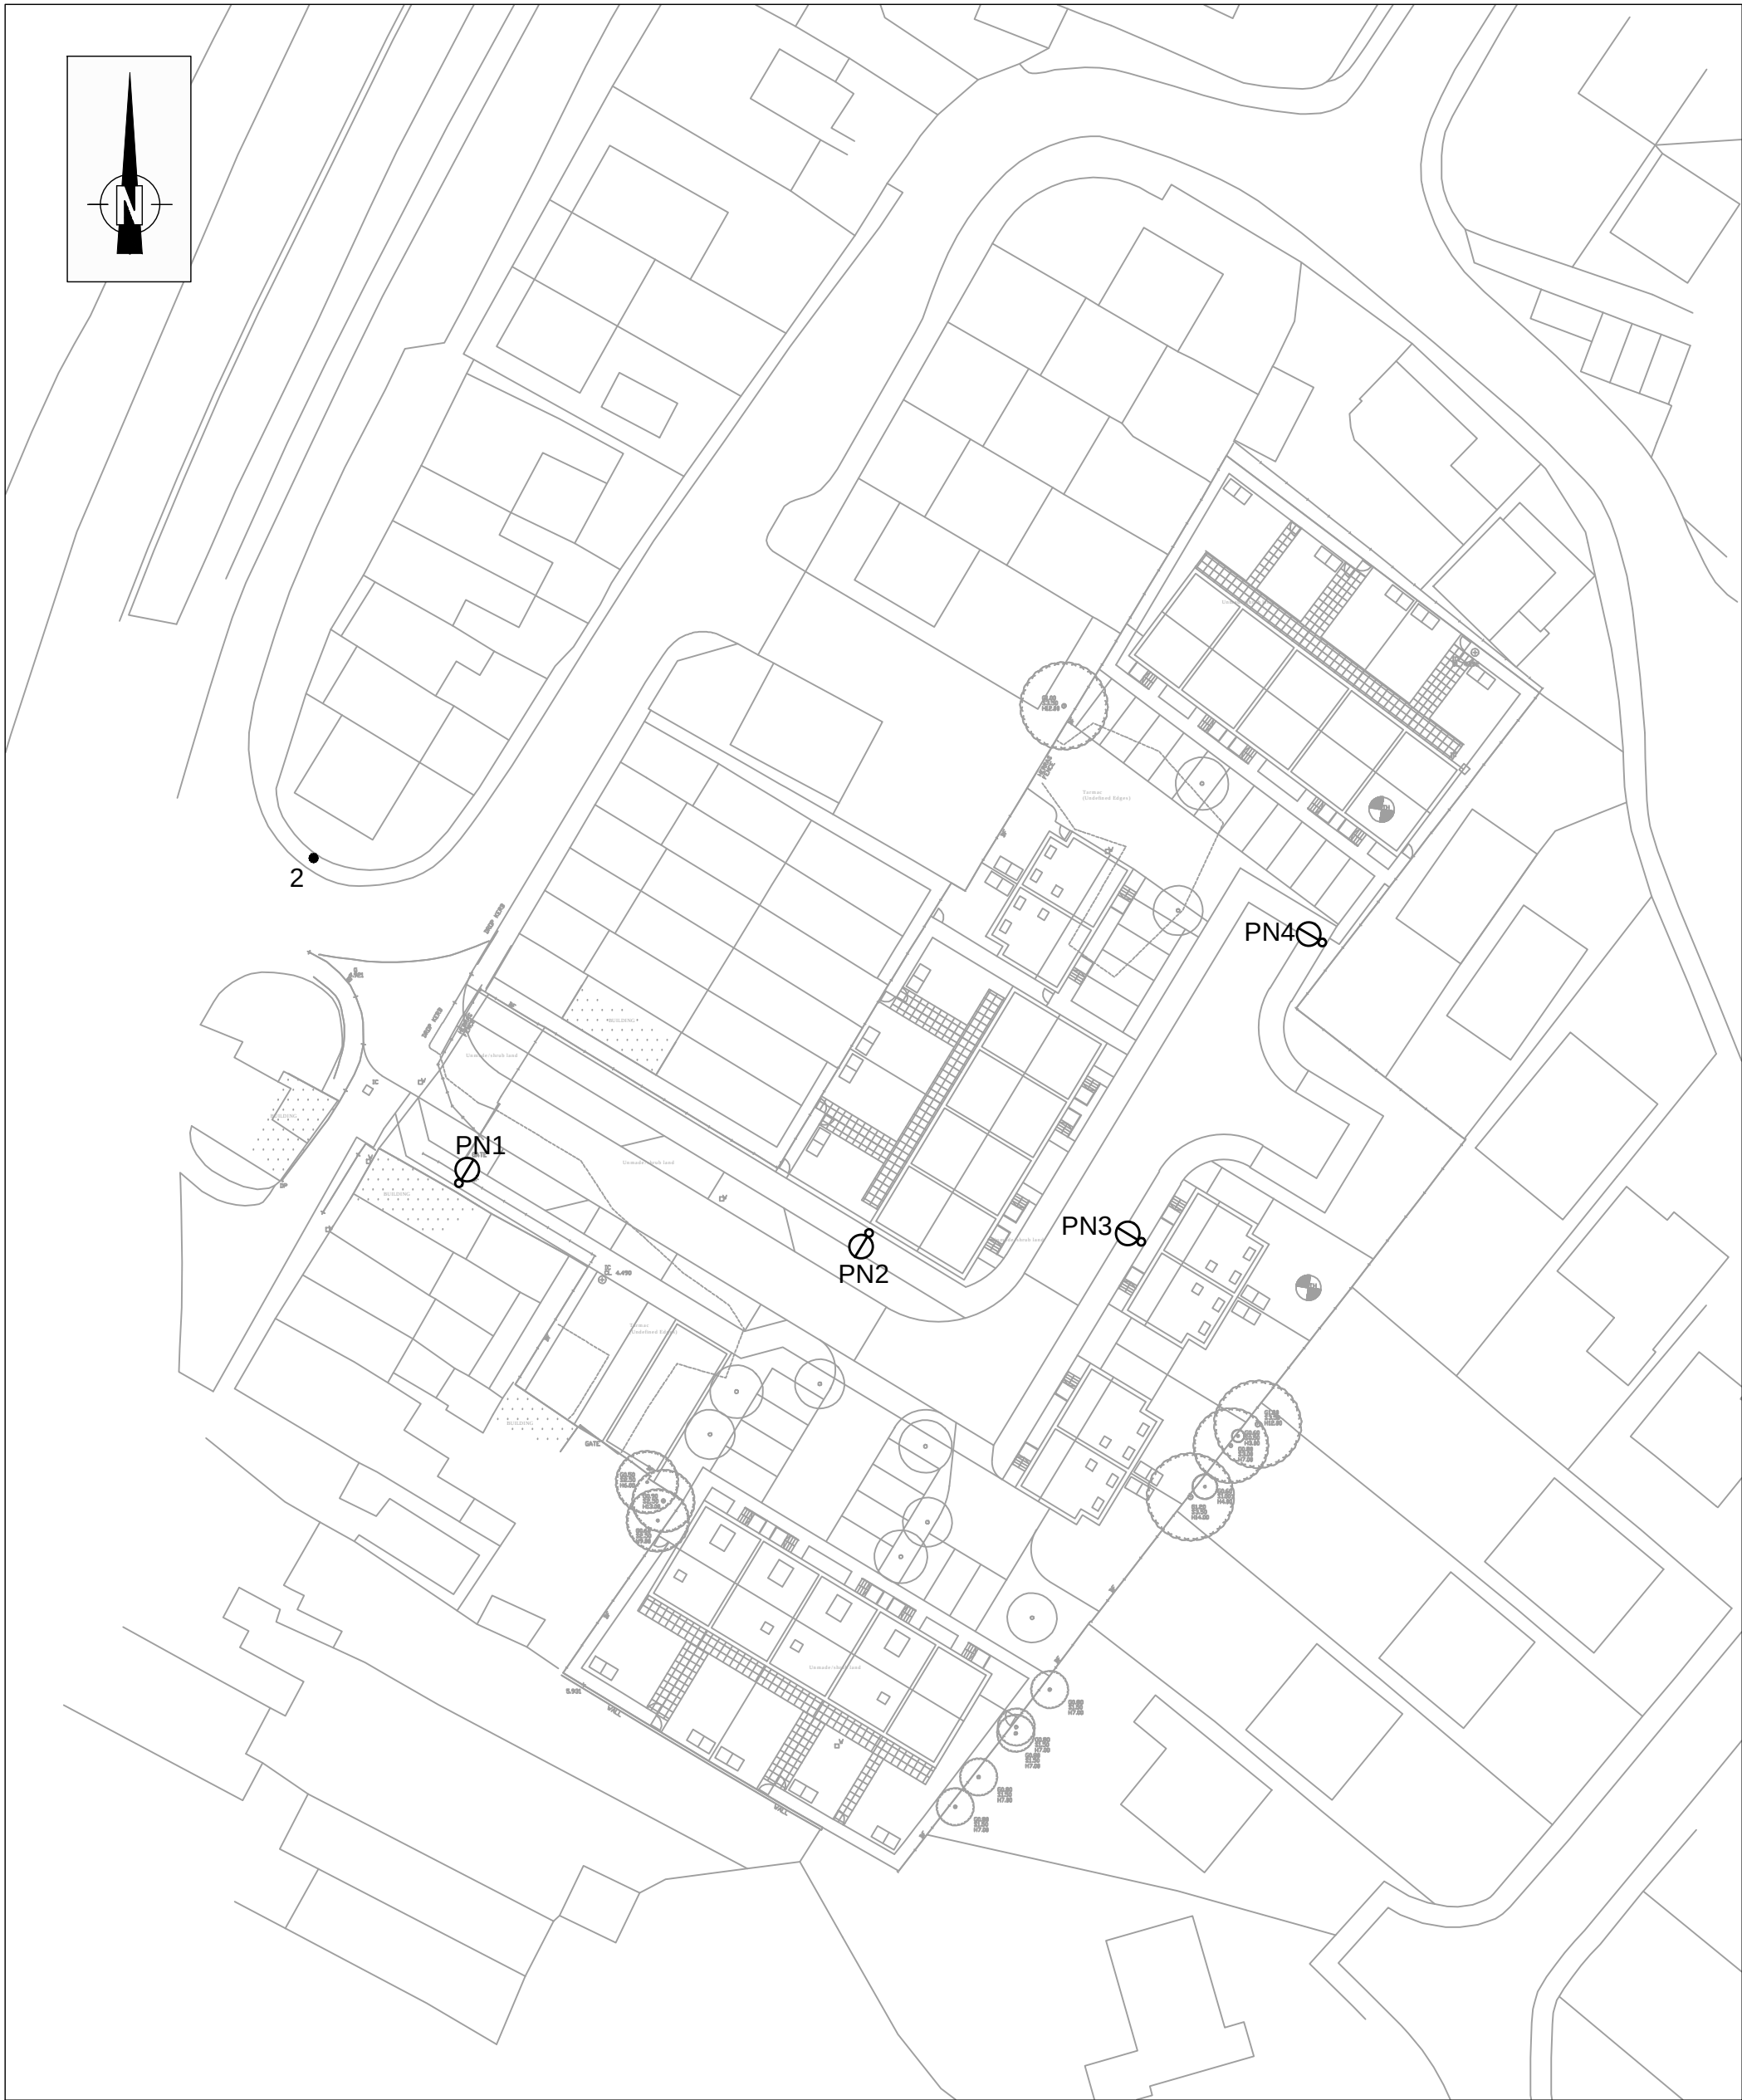

S38 Street Lighting Notes

- Column foundations to be as per SD/14/2A
- All columns to be provided with Distribution Network Operator (D.N.O.) Services and Termination Type A to LCC Standard Detail SD/14/4A unless otherwise specified. DNO Cutouts to be fitted with 16Amp BS88 Fuse Link. Double Pole Isolator to be fitted with BS 88 Fuse Link to L.C.C Appendix 14/4.
- Column setbacks shall comply with Table 2 Section 4.3.3.3 of BS 5489-1:2013.
- Columns shall not be installed within Drop Kerb areas and shall have a minimum clearance of 1.5m from Drives/Accesses.
- It is preferred that all Street Lighting works are undertaken by L.C.C Approved Contractors.
- Lanterns to be cleaned (during maintenance period) prior to adoption as detailed in S38 Agreement.
- Developer to liaise with Distribution Network Operator (D.N.O.) with regards to connections and disconnections of columns and appropriate black ducting. Where an independent D.N.O. (I.D.N.O.) has been used the cutout must be clearly and indelibly marked with the I.D.N.O. name and contact number.
- It is the Developers responsibility to inform property owners of part night street lighting switching where applicable.
- All private cabling shall have correct core colour identification as detailed in BS7671. Sleeving of conductors is not permitted.
- Due to ongoing technical innovations within the industry, if the street lighting equipment is to be ordered in excess of three years after the drawing approval date, the Authority reserves the right to upgrade the equipment specification.
- Lighting has been designed to comply with BS5489-1:2013 Lighting Class P5.

Street Lighting Key

- Proposed 6 metre galvanised T/S lighting column c/w root protection to G1a (LCC) spec. Column to have vertically mounted TRT Aspect 1 Eco 12 LED WW (3000K) General Road 4 (GR4) lens Powerset lantern set to 14W output. Lantern to have LCC Aggressive Dimming Regime overridden by internal wiring link. Lantern to have 7-pin NEMA socket c/w Westire 8480 35 lux Part Night (OFF 0000-0600) photocell. Lantern to be installed with 0° inclination.
- Existing lighting column to remain unaffected

X-Refs & Blocks used in this Drawing

x-cont base

x-SL

Lincolnshire Highway Alliance drawing created using base information supplied by external party detailed below:

Base Information Provided By: Burmr Construction

Client Provided Drawing Number: Site Layout

APPROVED FOR

CONSTRUCTION

FOR THIRD PARTY USE, THIS DRAWING SHALL BE DEEMED CURRENT ONLY AT THE DATE OF APPROVAL. PLEASE CHECK FOR AMENDMENTS BEFORE USE

Revision:	Description:	Drawn By:	CAD By:	Approved By:	Approval Date

Amendment Details

Drawing 1st Approval

1st Approval by: PC

Date: 14/02/19

Drawn/Designed by: NP

CAD Drawing Creation

Created By: DS

Date: 12/02/19

Scale: (@A2)

Primary: 1:500

Secondary: (Do not scale from this drawing)

Lincolnshire COUNTY COUNCIL

Highways Alliance

TECHNICAL SERVICES PARTNERSHIP

CROWN HOUSE

GRANTHAM STREET

LINCOLN

LN2 1BD

Customer Service Centre : (01522) 782070

FS 20705

Drawing Number:	1830	/LTG/	5000	Revision Number: (if applicable)
	Scheme Reference	ID Number	Drawing Series No.	
Alternative Scheme Code:			Road No:	
Parish: SPALDING				
Structure No: N/A		SCN No: N/A		Site Ref: N/A
Description:				
S38 DEVELOPMENT OFF WILLOW WALK				
PROPOSED STREET LIGHTING LAYOUT				

LINCOLNSHIRE COUNTY COUNCIL - Reproduced from Ordnance Survey material with the permission of Ordnance Survey on behalf of the Controller of Her Majesty's Stationery Office © Crown copyright. Unauthorised reproduction infringes Crown copyright and may lead to prosecution or civil proceedings. OS Licence 100025370

TSP Border Issue 2016