


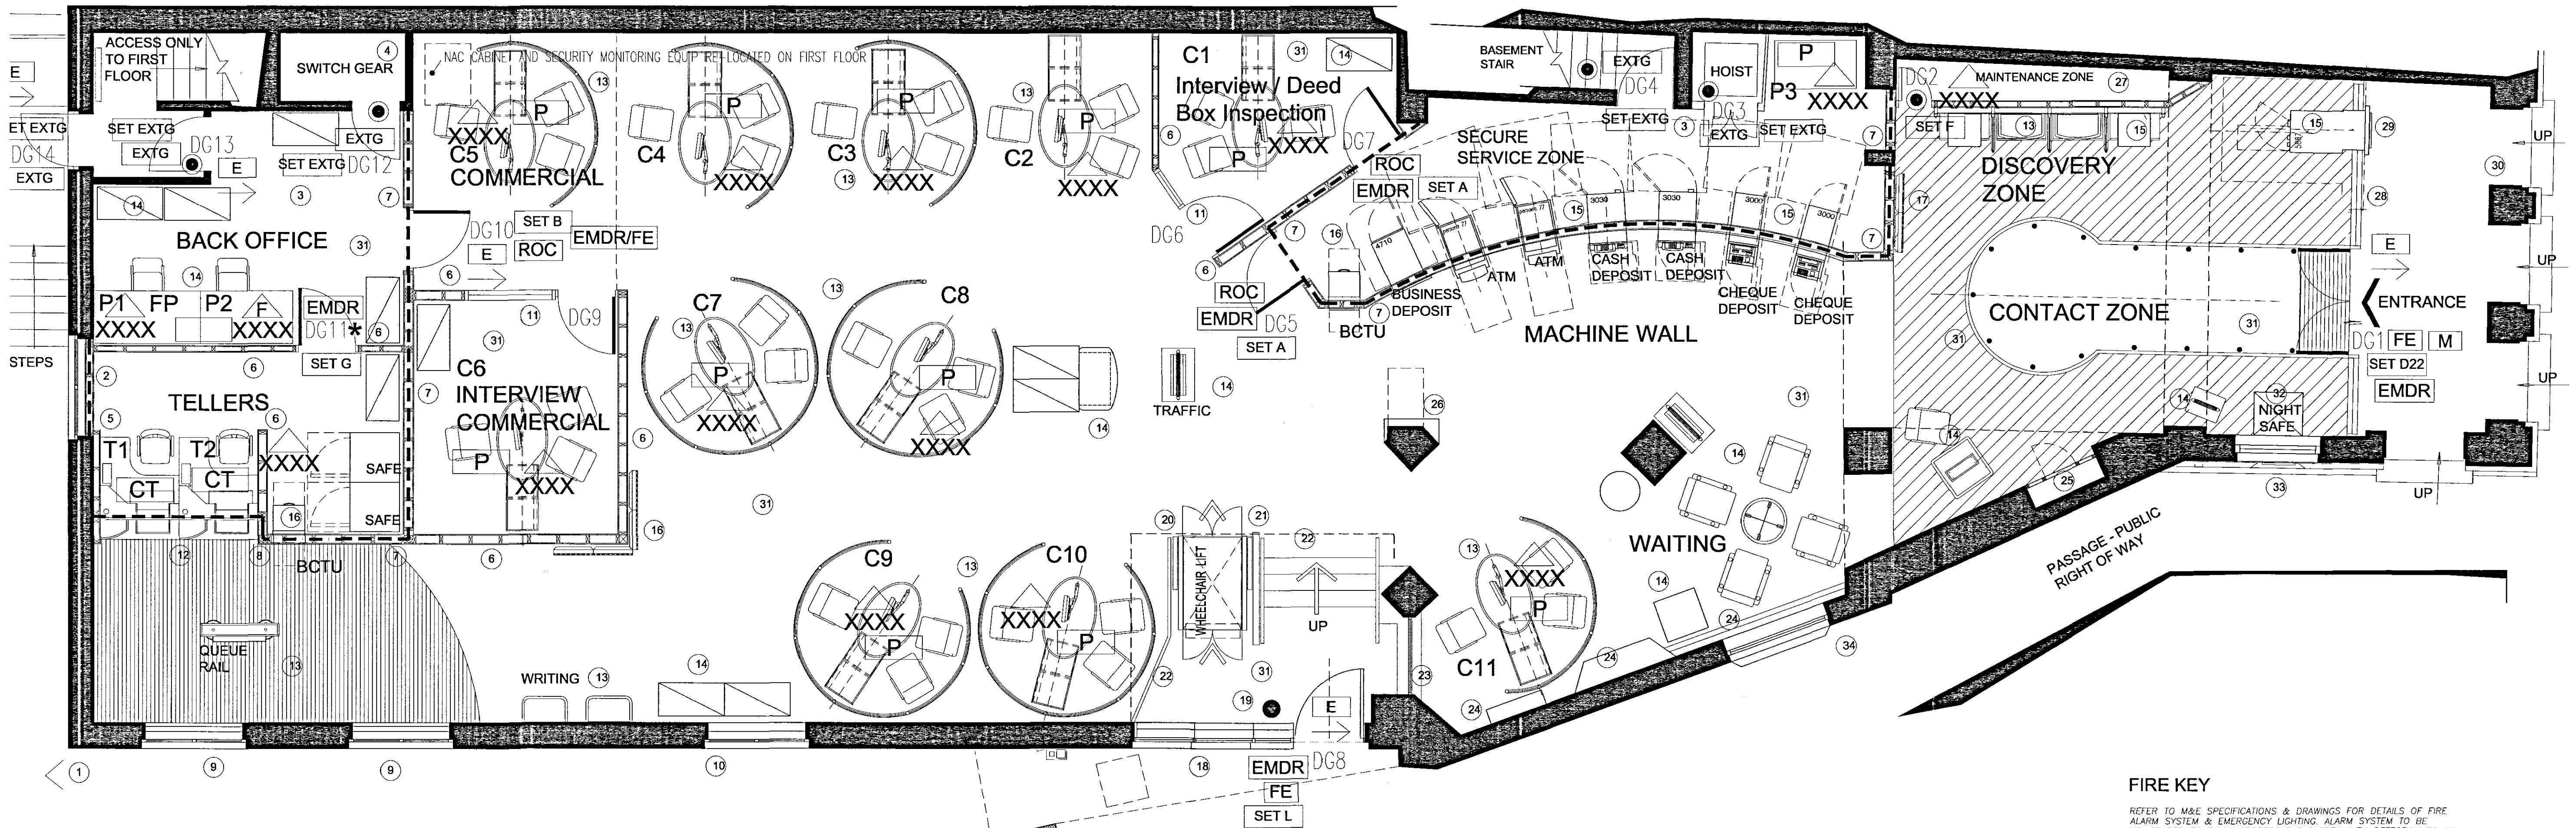

64 - SPALDING, MARKET PLACE

FIRE KEY

- REFER TO M&E SPECIFICATIONS & DRAWINGS FOR DETAILS OF FIRE ALARM SYSTEM & EMERGENCY LIGHTING ALARM SYSTEM TO BE UP-GRADED TO FULLY ADDRESSABLE SYSTEM WITH DETECTION TO ALL VOIDS - FIRE DETECTION SYSTEM/ALARM SYSTEM / FIGHTING EQUIP / ESCAPE SIGNAGE ETC BY BANK SPECIALIST CONTRACTORS
- E** RUNNING MAN FIRE EXIT SYMBOL TO BS 5548 TO DIRECTION OF ESCAPE
 - FR30SC DOOR**
 - FR30S DOOR**
 - VP** VISION PANEL 900 - 1500 ABOVE FFL
 - *** DOOR WITH AUTOMATIC CLOSER TO BE HELD OPEN ON ELECTRO-MAGNETIC HOLDER TO RELEASE ON FIRE ALARM ACTIVATION
 - 30 MIN FIRE RESISTING STRUCTURE TO FULL HEIGHT, ALL OPENINGS & PENETRATIONS TO BE FIRE STOPPED
 - 60 MIN FIRE RESISTING STRUCTURE TO FULL HEIGHT, ALL OPENINGS & PENETRATIONS TO BE FIRE STOPPED

SUPERSEDED

DETERMINED PLAN

260/06

PRELIMINARY
A X I S
 ARCHITECTURE
 TALBOT CHAMBERS 2 NORTH CHURCH STREET SHEFFIELD S1 2DH
 TEL 0114 2490944 FAX 0114 2490966 www.axis-architecture.com

SPALDING
 8 Market Place
 HSBC

Corporate Real Estate
PROPOSED GROUND FLOOR LEVEL
GENERAL ARRANGEMENT
 SCALE: A1 ISSUE: A3 ISSUE: DATE: DRAWN: CHECKED:
 1:50 1:100 Feb 2006 AXIS
 DRAWING NUMBER: 25061/GF_GA
 REVISION:

© COPYRIGHT EXISTS ON THE DESIGNS AND INFORMATION SHOWN ON THIS DRAWING. The Contractor must verify all dimensions on site before making shop drawings or commencing work of any kind. No dimensions to be scaled from this drawing.