


ALL DIMENSIONS TO BE CHECKED ON SITE AND NOT SCALED FROM THIS DRAWING

NOTES:
THIS DRAWING TO BE READ IN CONJUNCTION WITH
DRGS. No's: 4000/0807/A3/01 & 02.
VF/STD/A3/111 - ANTENNA SUPPORT DETAILS.
VF/STD/A3/123 - CABLE TRAY INSTALLATION.

NOTE! EXISTING VODAFONE
OMNI-ANTENNAS ETC. AT ROOF
LEVEL TO REMAIN.

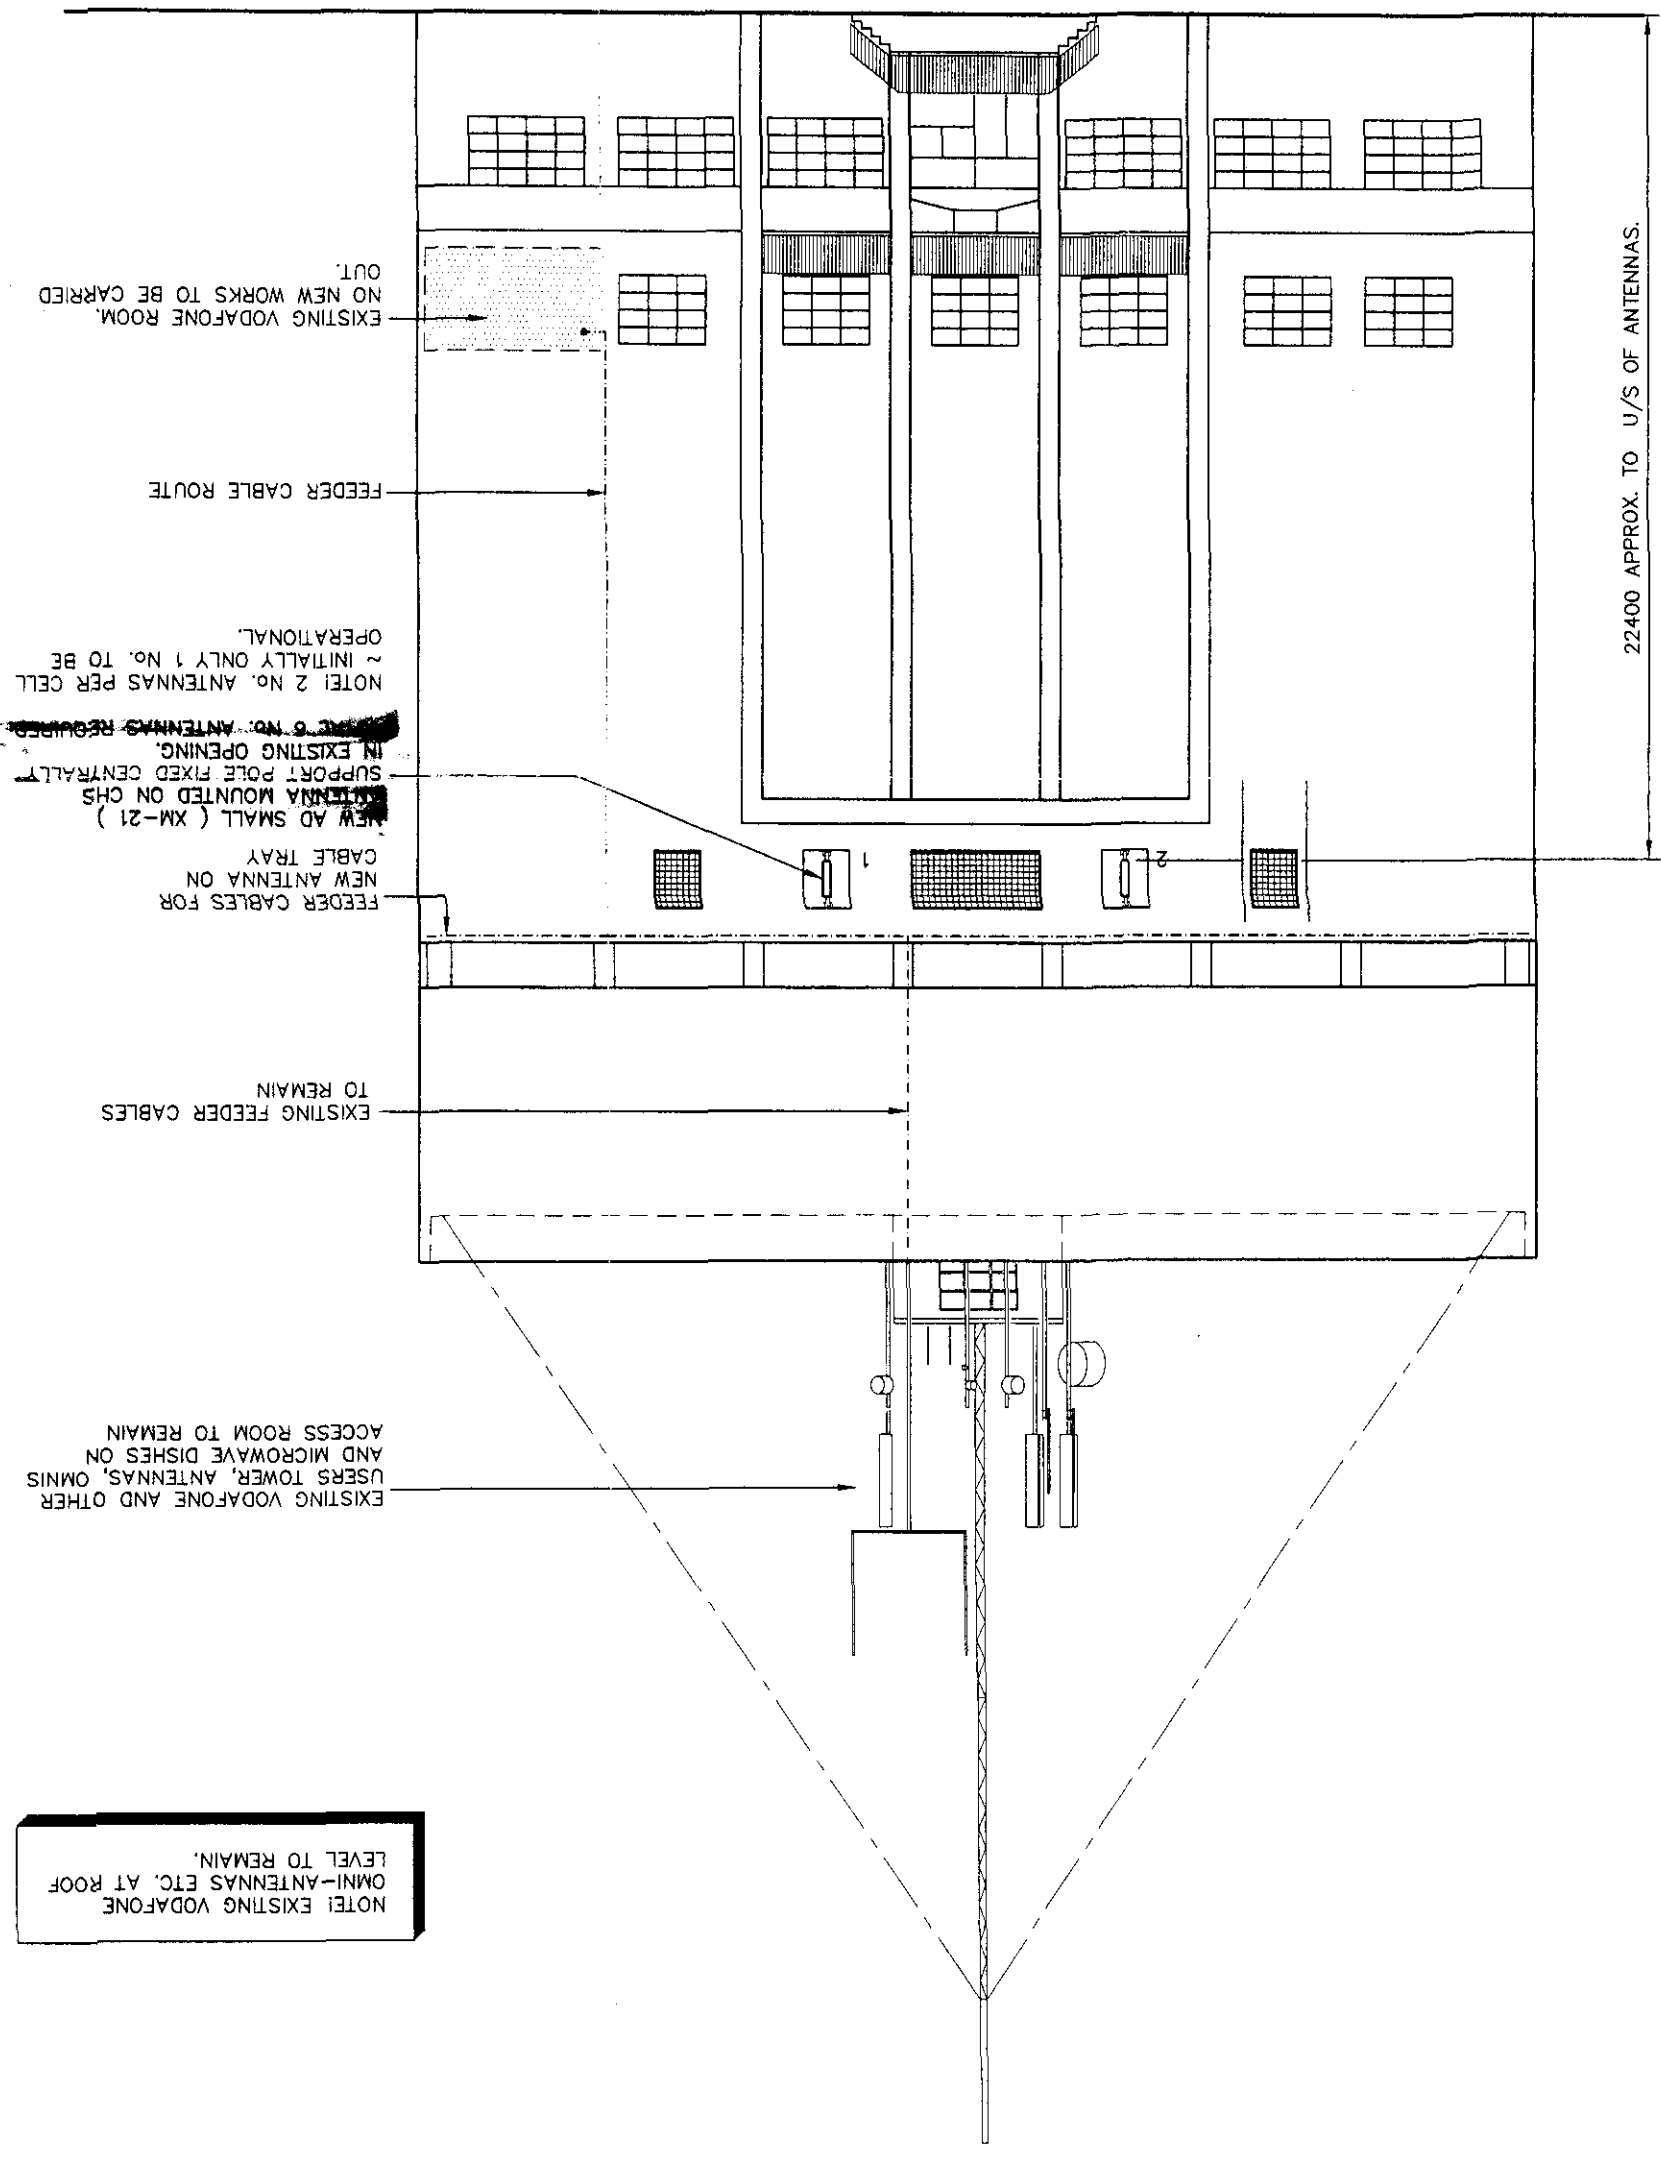

SCALE 1:200.

SOUTH-EAST ELEVATION.

SOUTH HOLLAND DC
HOUSING & PLANNING
66 MAR 2000
Ref: 0283/00



REV.	DATE	REMARKS	BY	CHK.	FILENAME 771_03_TD3_0807.dwg	CSL No. 771	CLIENT vodafone	THIS DRAWING SHOULD BE READ IN CONJUNCTION WITH R.B.S. DESIGN MANUAL ISSUE 2. VODAFONE P.B.S PROJECTS BUILDING REQUIREMENTS WORK AND ELECTRICAL SPECIFICATION. SITE ADDRESS CHATTERTON WATER TOWER, SPALDING, LINCOLNSHIRE.	DESIGN OFFICE 385 GEORGE ROAD, ERDINGTON, BIRMINGHAM, B23 7RZ. TEL. 0121 344-4888 FAX. 0121 344-4801	Tilbury & Douglas CONSTRUCTION	DRAWN A.M.	CHECKED M.W.	DATE 01_12_99.	SCALE AS SHOWN.
								DRAWING TITLE SOUTH-EAST ELEVATION.	DRAWING No. 4000/0807/A3/03.	REVISION				

DUE TO POSSIBLE DISCREPANCIES ARISING DURING
REPROGRAPHIC PROCESSES DO NOT SCALE THIS DRAWING


SOUTH HOLLAND DC
HOUSING & PLANNING

16 MAR 2000

Ref: 0283/00

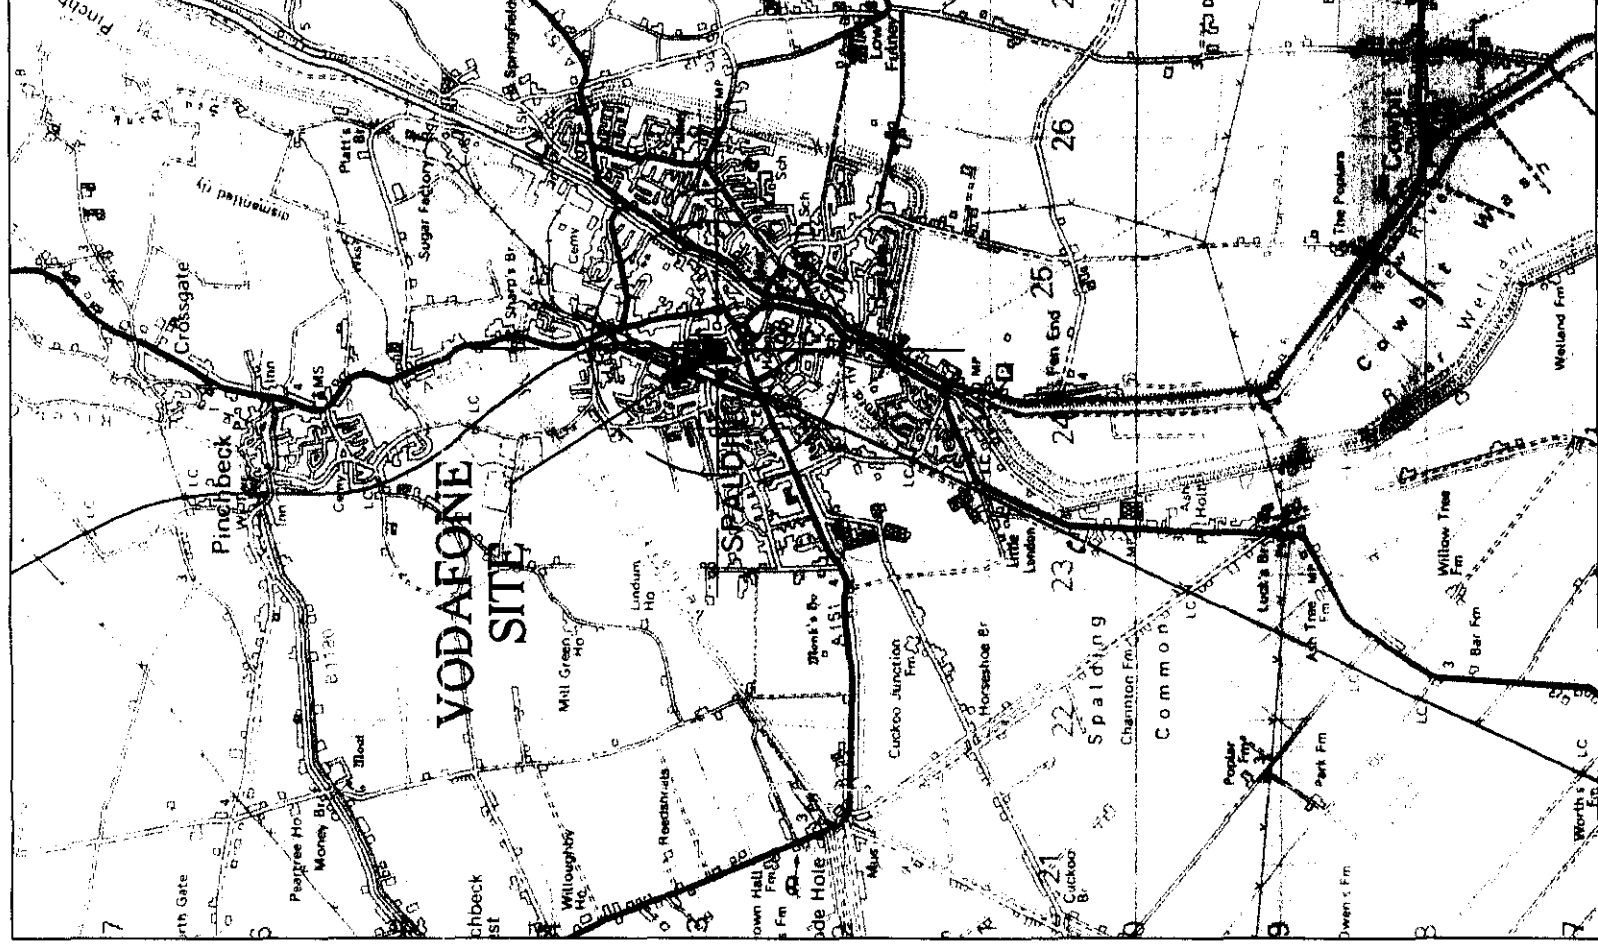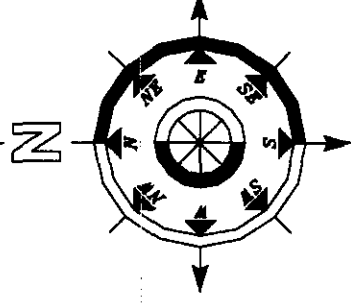

AREA PLAN Scale 1:50,000
EXTRACT FROM LANDRANGER SHEET 131.

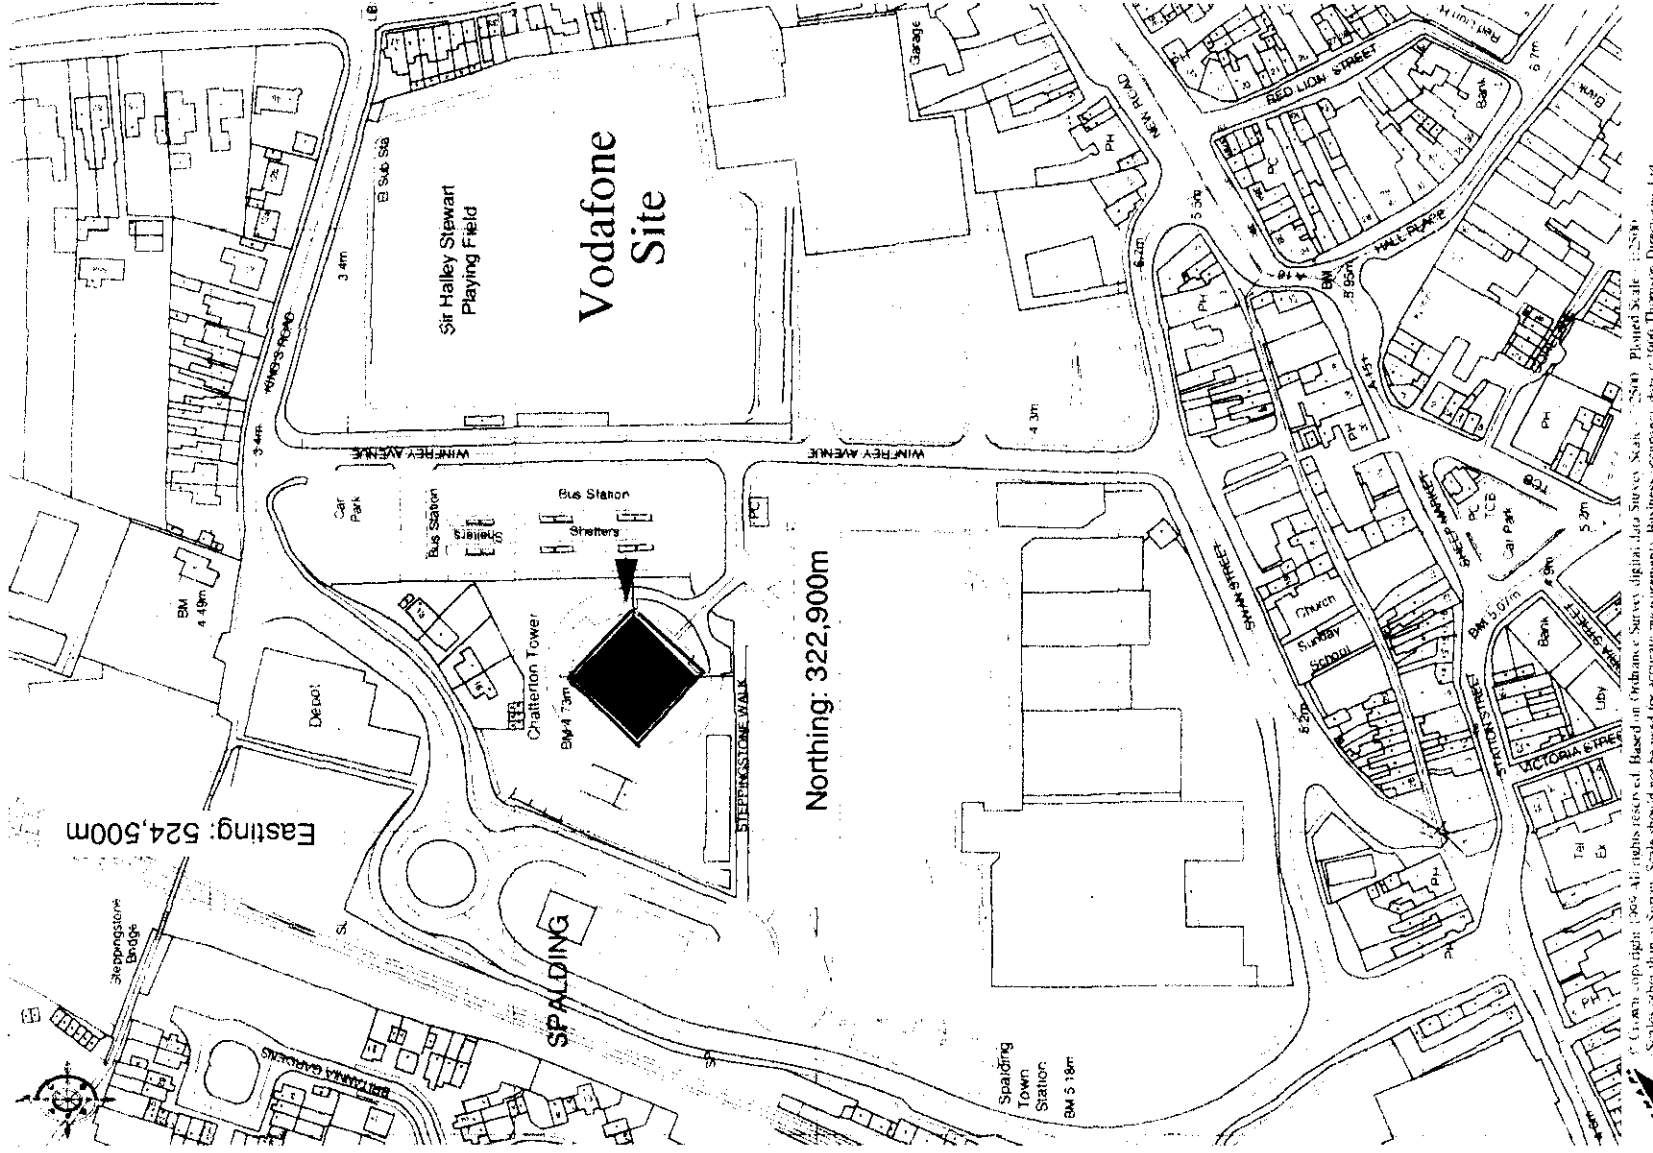

Location Plan Scale 1:2500
Easting: 524,551m Northing: 322,961m

REV	DATE	REMARKS	BY	CHK.

THIS DRAWING IS TO BE READ IN CONJUNCTION WITH R.B.S.
DESIGN MANUAL ISSUE 2, VODAFONE R.B.S. PROJECTS BUILDING
REQUIREMENTS WORK AND ELECTRICAL SPECIFICATION.

CLIENT

vodafone

CSL No.

771

SITE NAME

CHATTERTON WATER TOWER

SITE ADDRESS
RADIO BASE STATION AT
CHATTERTON WATER TOWER,
SPALDING,
LINCOLNSHIRE.

FILENAME 771_01_TD3_0807.dwg

DESIGN OFFICE

385 GEORGE ROAD, ERDINGTON,
BIRMINGHAM, B23 7RZ.
TEL 0121 944-4888
FAX 0121 944-4801



CONSTRUCTION

COMPUTER AIDED DRAWING - AVOID MANUAL MODIFICATION

DRAWN

MAH.

CHECKED

CH/CP/AD/MS

DATE

01 - 12 - 99

SCALE

AS PLOTTED

DRAWING TITLE

LOCATION & AREA PLANS

DRAWING No.

4000/0807/A3/01.

REVISION

