
 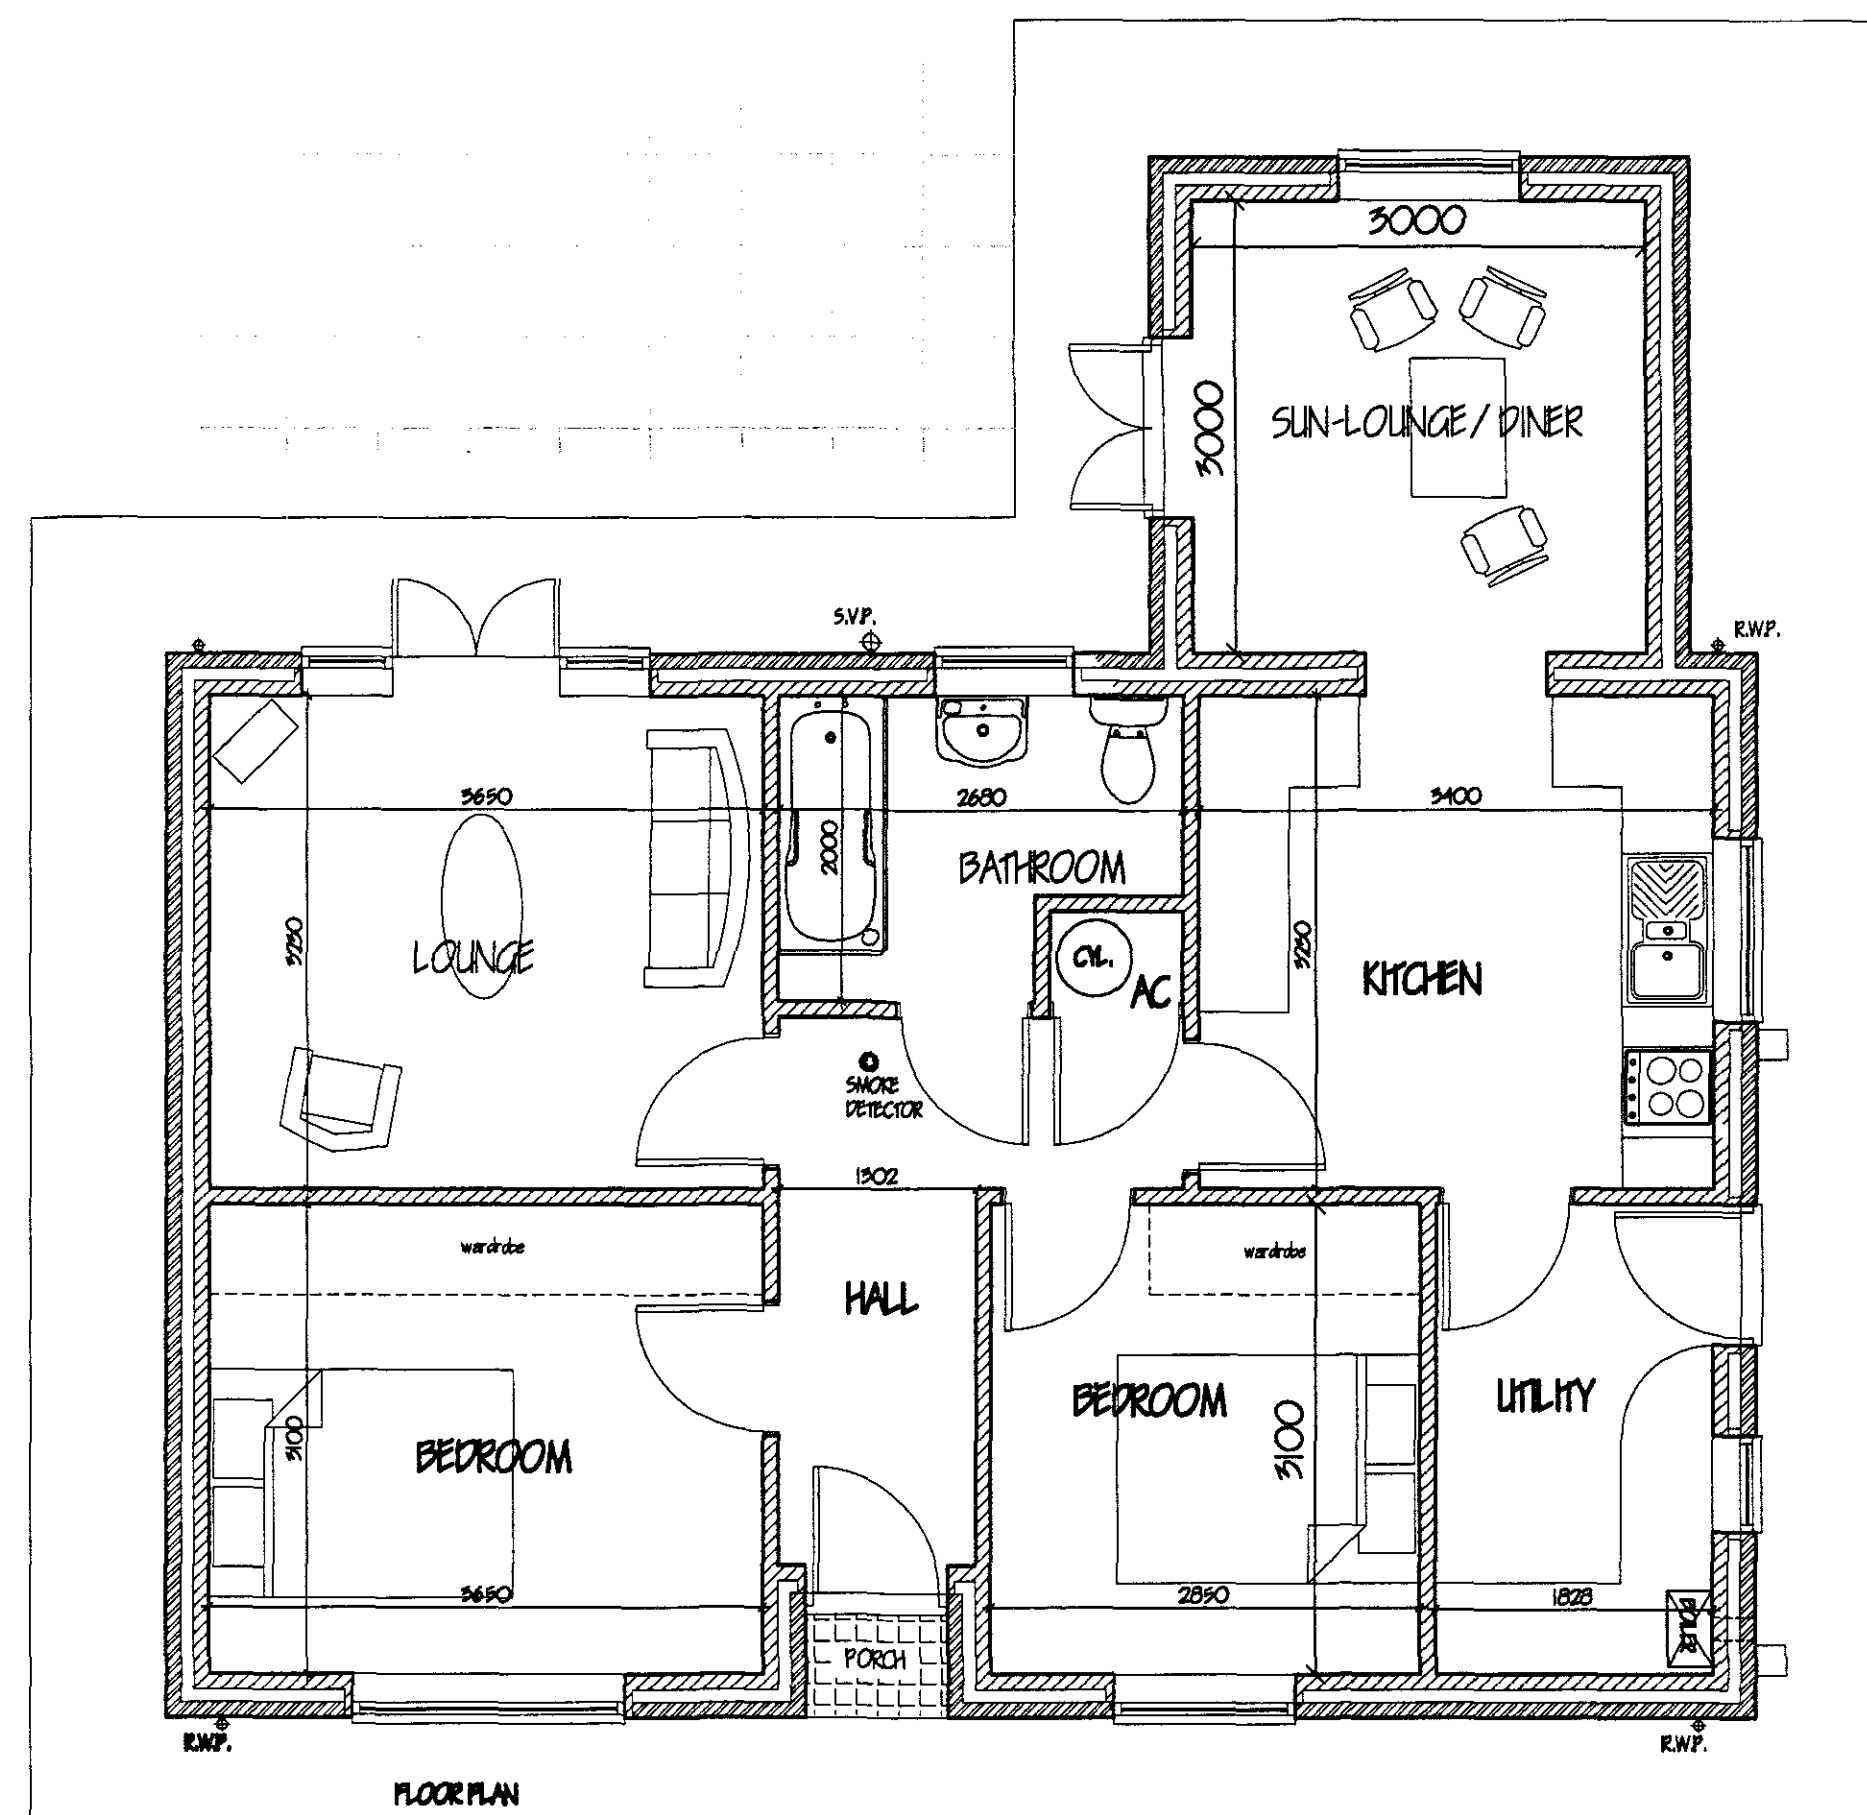
 
 




no. revision date	
G. R. MERCHANT LTD. 1120 ALCO FIVE ARCHITECTURAL, STRUCTURAL AND LAND DRAINAGE CONSULTANTS 4000 Highway 100, Suite 100, Houston, Texas 77057 TEL 813-833-8333 FAX 813-833-8333	
Project TWO BEDROOM PUNGALOW, Rear of 62 PINCHBECK ROAD, SPALDING, LINC.'S, PELL 107.	
Client J. C. ALSTIN.	
Jobbing FLOOR PLAN & ELEVATIONS.	
Job Ref. 1816-08	Drawing No. 04.
Date JULY '08	Drawn GRM.
Scales 1/50, 1/100.	