


WORK TO SEWAGE SYSTEM  
IN THIS LOCATION.

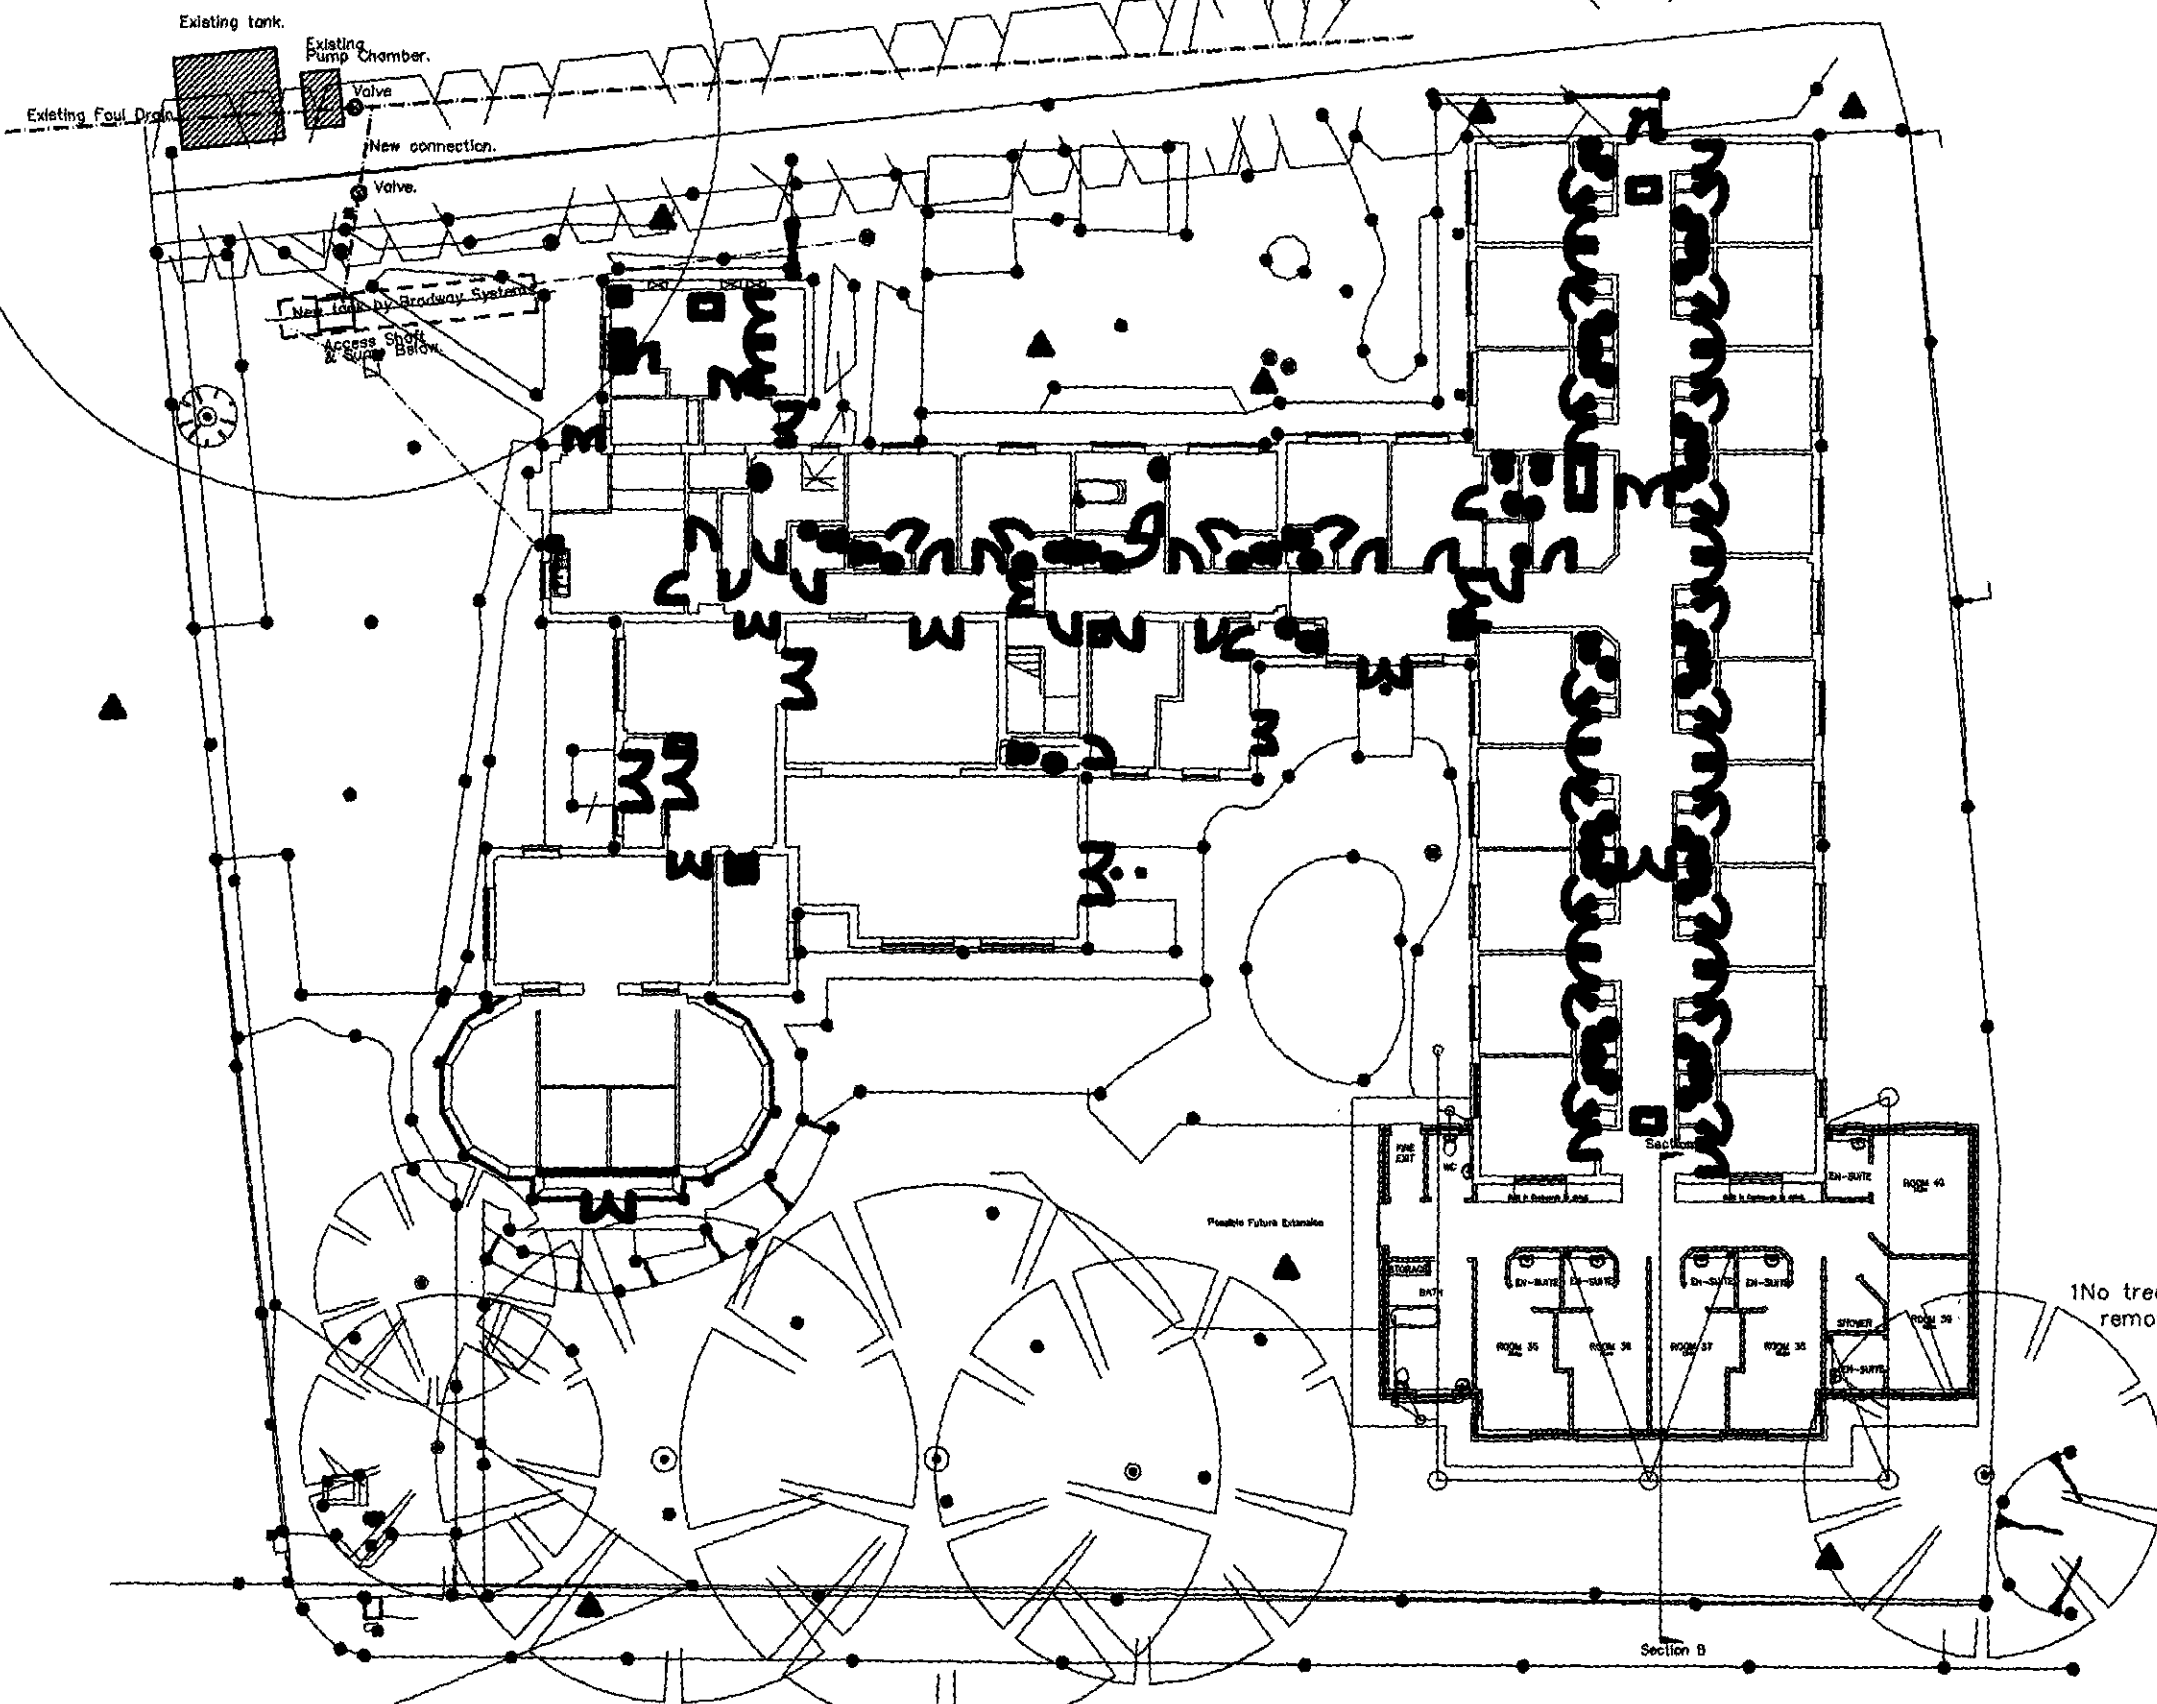

Plan No. 3405  
30 JUN 2010  
Ref: 0399-10

Do not scale from this drawing.  
This drawing is copyright and may not be altered, traced, photocopied, electronically copied or used for any purpose other than that for which it is issued, without the written permission from Barry Johnson Architects.

The General Contractor is to check all dimensions on site and report any discrepancy to the Architect.

Architect  
Client  
Country Court Care Homes Ltd.

Job No.  
New Foul Drainage Tank  
at  
Ashwood Nursing Home,  
Spalding,  
Lincolnshire.


Drawing Title  
Site Plan

Scale  
1:250 Date  
June 2010 C.A.D.

Barry Johnson Architects, RIBA  
Chartered Architects  
95 London Road, Spalding  
Lincolnshire PE21 7ER  
Tel: 01845 355400  
Fax: 01845 355401

Job No.  
1256 A, O2 A

LITTLEWORTH DROVE

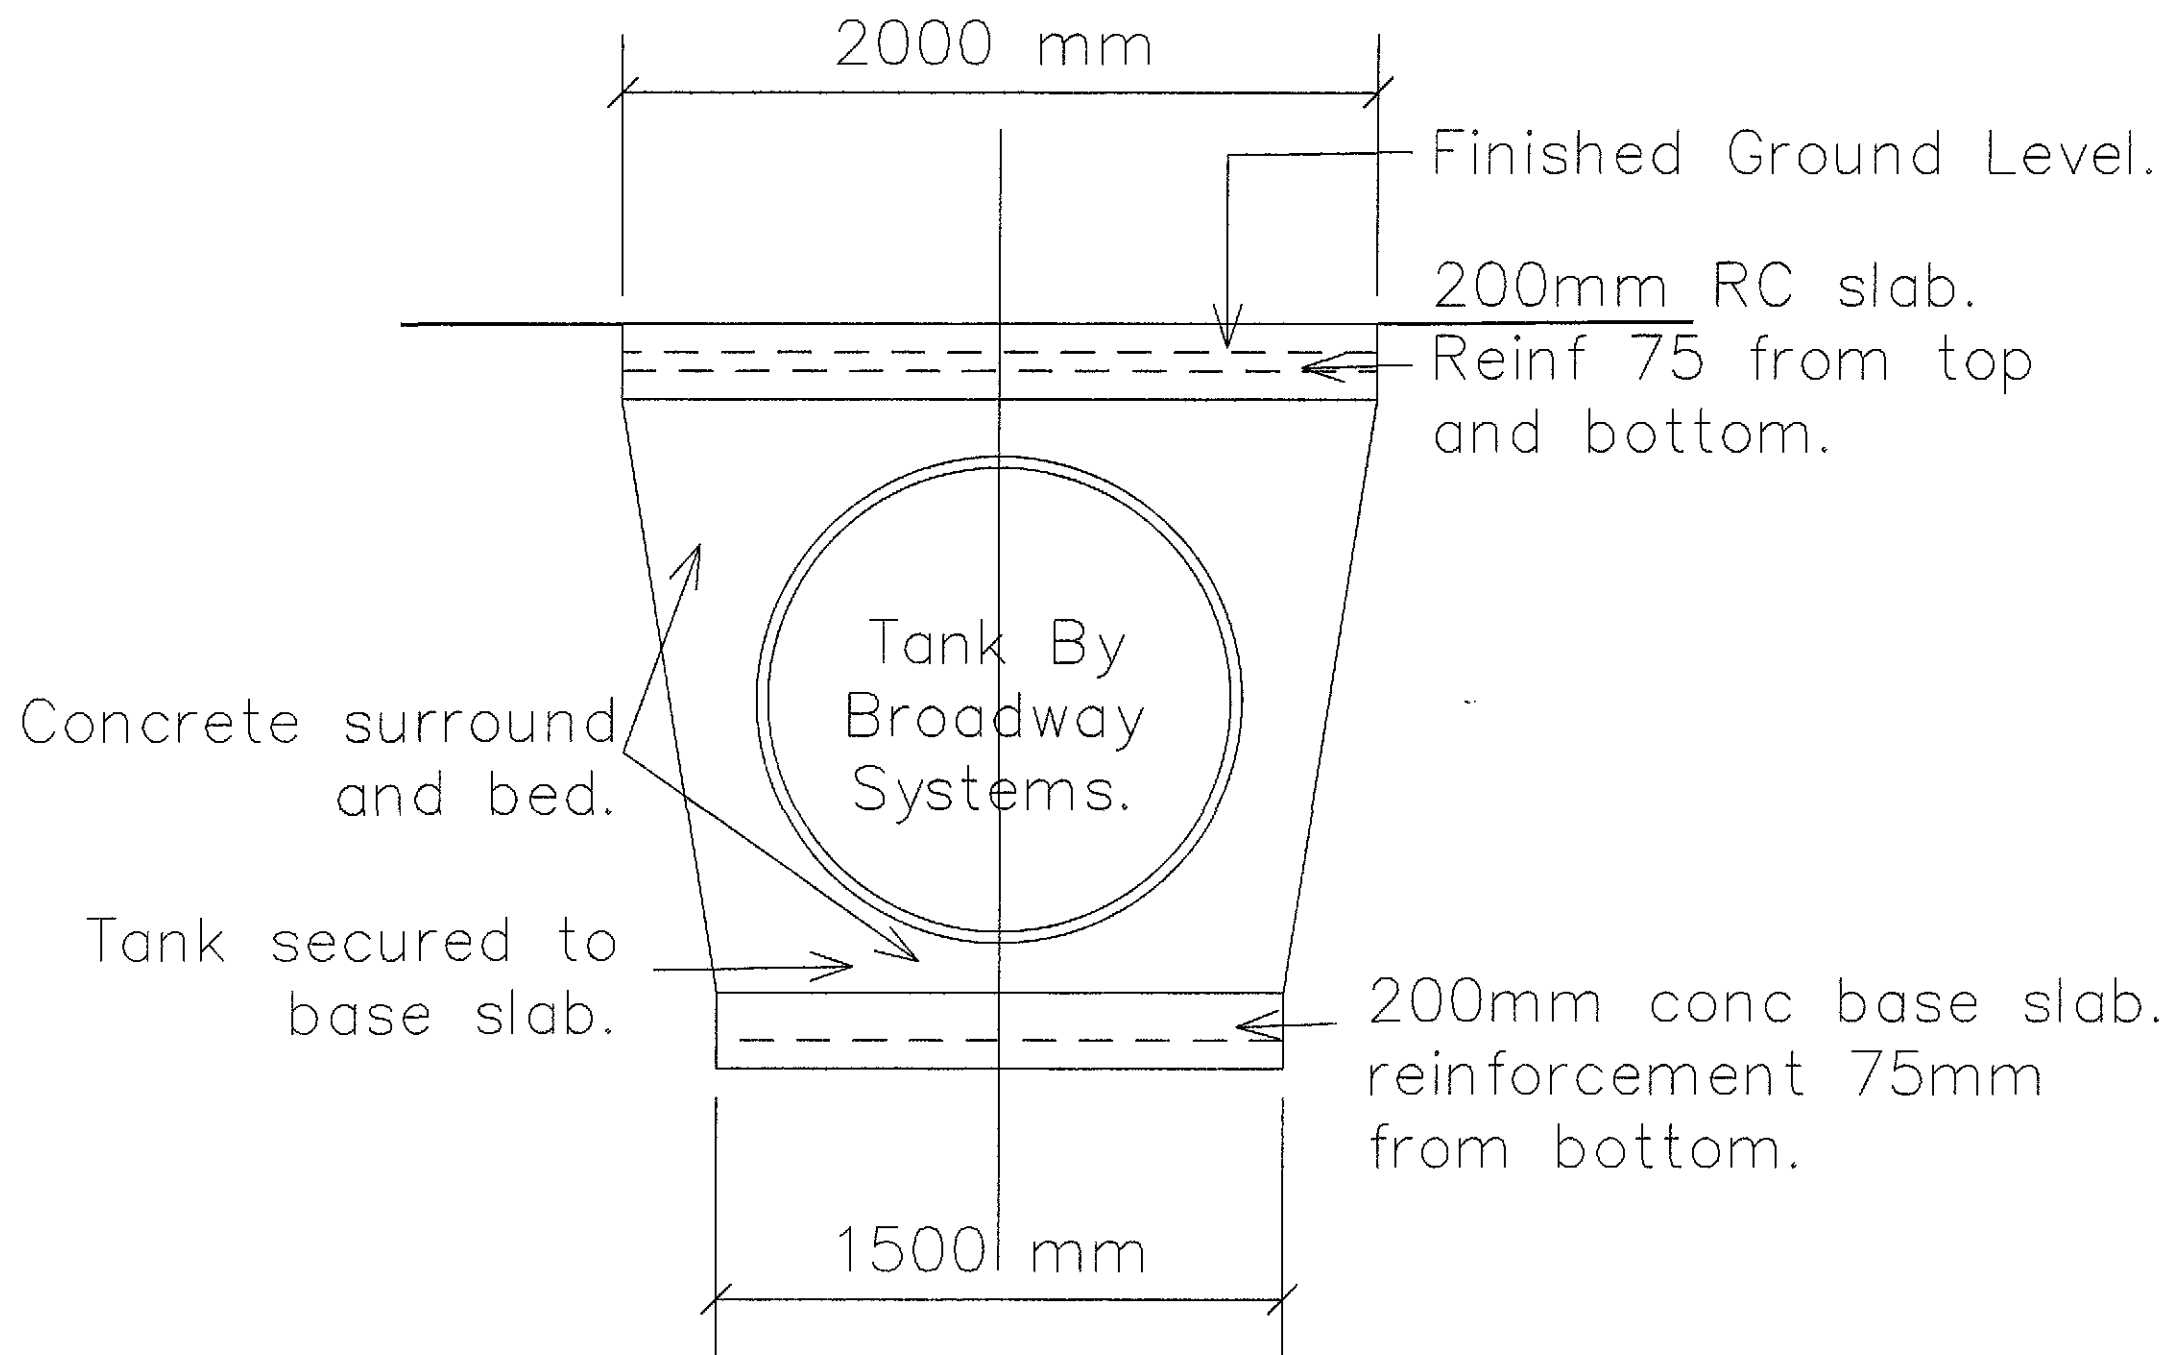

Do not scale from this drawing.

This drawing is copyright and may not be altered, traced, photographed, electronically copied or used for any purpose other than that for which it is issued, without the written permission from Barry Johnson Architect.

The General Contractor is to check all dimensions on site and report any discrepancy to the Architect.

Revisions


Client

Country Court Care Homes Ltd.

Job Title

Ashwood Nursing Home

Spalding.

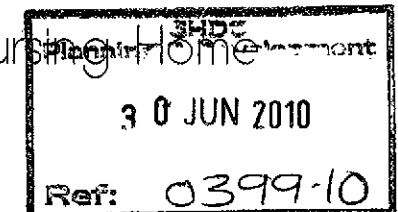

Drawing Title

Tank for Sewage Pumping System.

Scale  
1:20

Date  
June 2010. C.A.D.

Barry Johnson DipArch, RIBA  
Chartered Architect  
99 London Road, BOSTON.  
Lincolnshire PE21 7EN  
tel 01205 353473  
mob 07973 102383

Job No.

Drawing No

1256

A

01


A

**DRAWING APPROVAL**

Date

Approved By  
(Print)

Signed

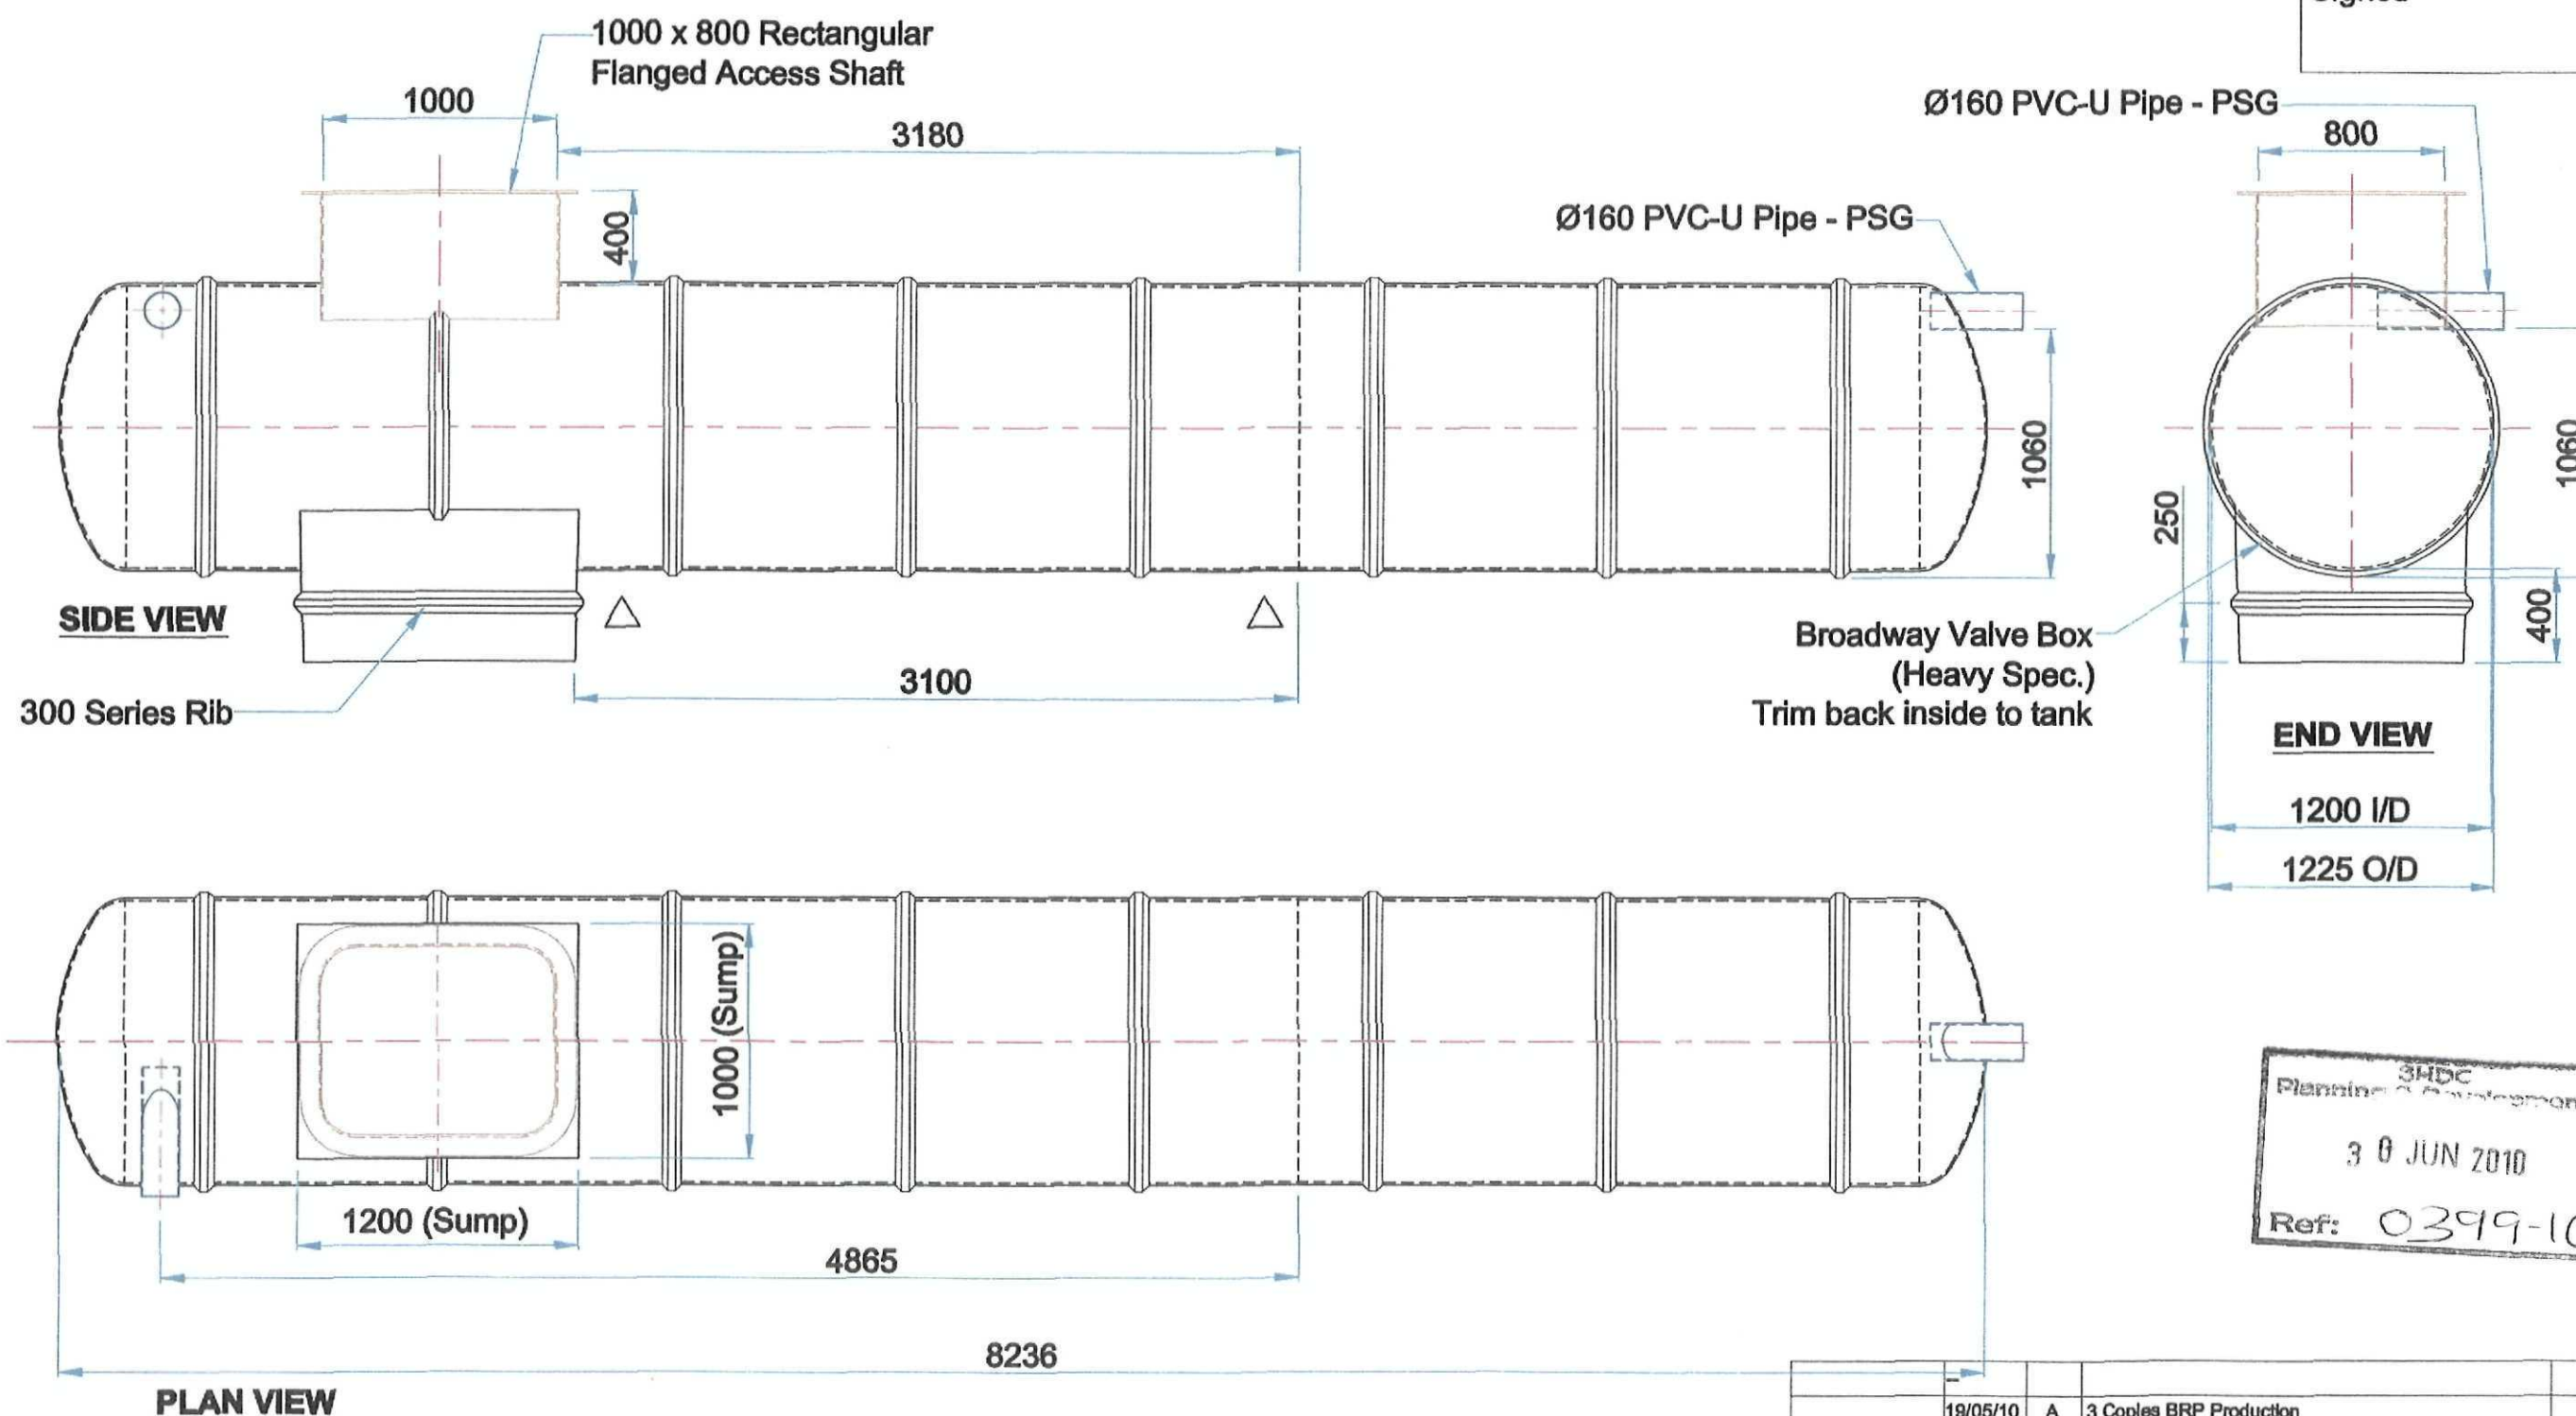Key to Symbols:  $\triangle$  Lifting Point $\circ$  Hold-down strap rib locations where mechanical anchoring is required

Manufacturing Joint

 $\bigcirc$  BoQ's reference no.

This drawing is confidential and must not be copied, reproduced or passed to a third party without written permission

DIMENSIONS ARE SUBJECT TO DIMENSIONAL TOLERANCES. If critical, check physically prior to installation

Water table & Burial Depth: The customer must check tank specification is compatible with ground water table level (in winter) and burial depth.

Title: 200 Series Tankstor Underground Storage tank

 
Contract:

Order No. : 57228

Capacity 9000 Ltr.

Tank Specification HEAVY

Laminate Specification GP



All sizes in mm  
If in doubt ASKI

broadway

0845 601 9006

Drawn JD

Checked DJB

Date 18/05/10

Scale 1:30 Sheet A3

Internal Ref T19587 06320/000

Drawing No.

T19587 06320\_000

Rev

A

| Distribution | Date     | Rev | Issued only for purpose indicated             | Date | App'd |
|--------------|----------|-----|-----------------------------------------------|------|-------|
|              | 19/05/10 | A   | 3 Copies BRP Production                       |      |       |
|              | 19/05/10 | A   | 110 Inlet removed - Re-issued For Information |      |       |
|              | 18/05/10 | -   | Issued to Broadway Systems For Approval       |      |       |