
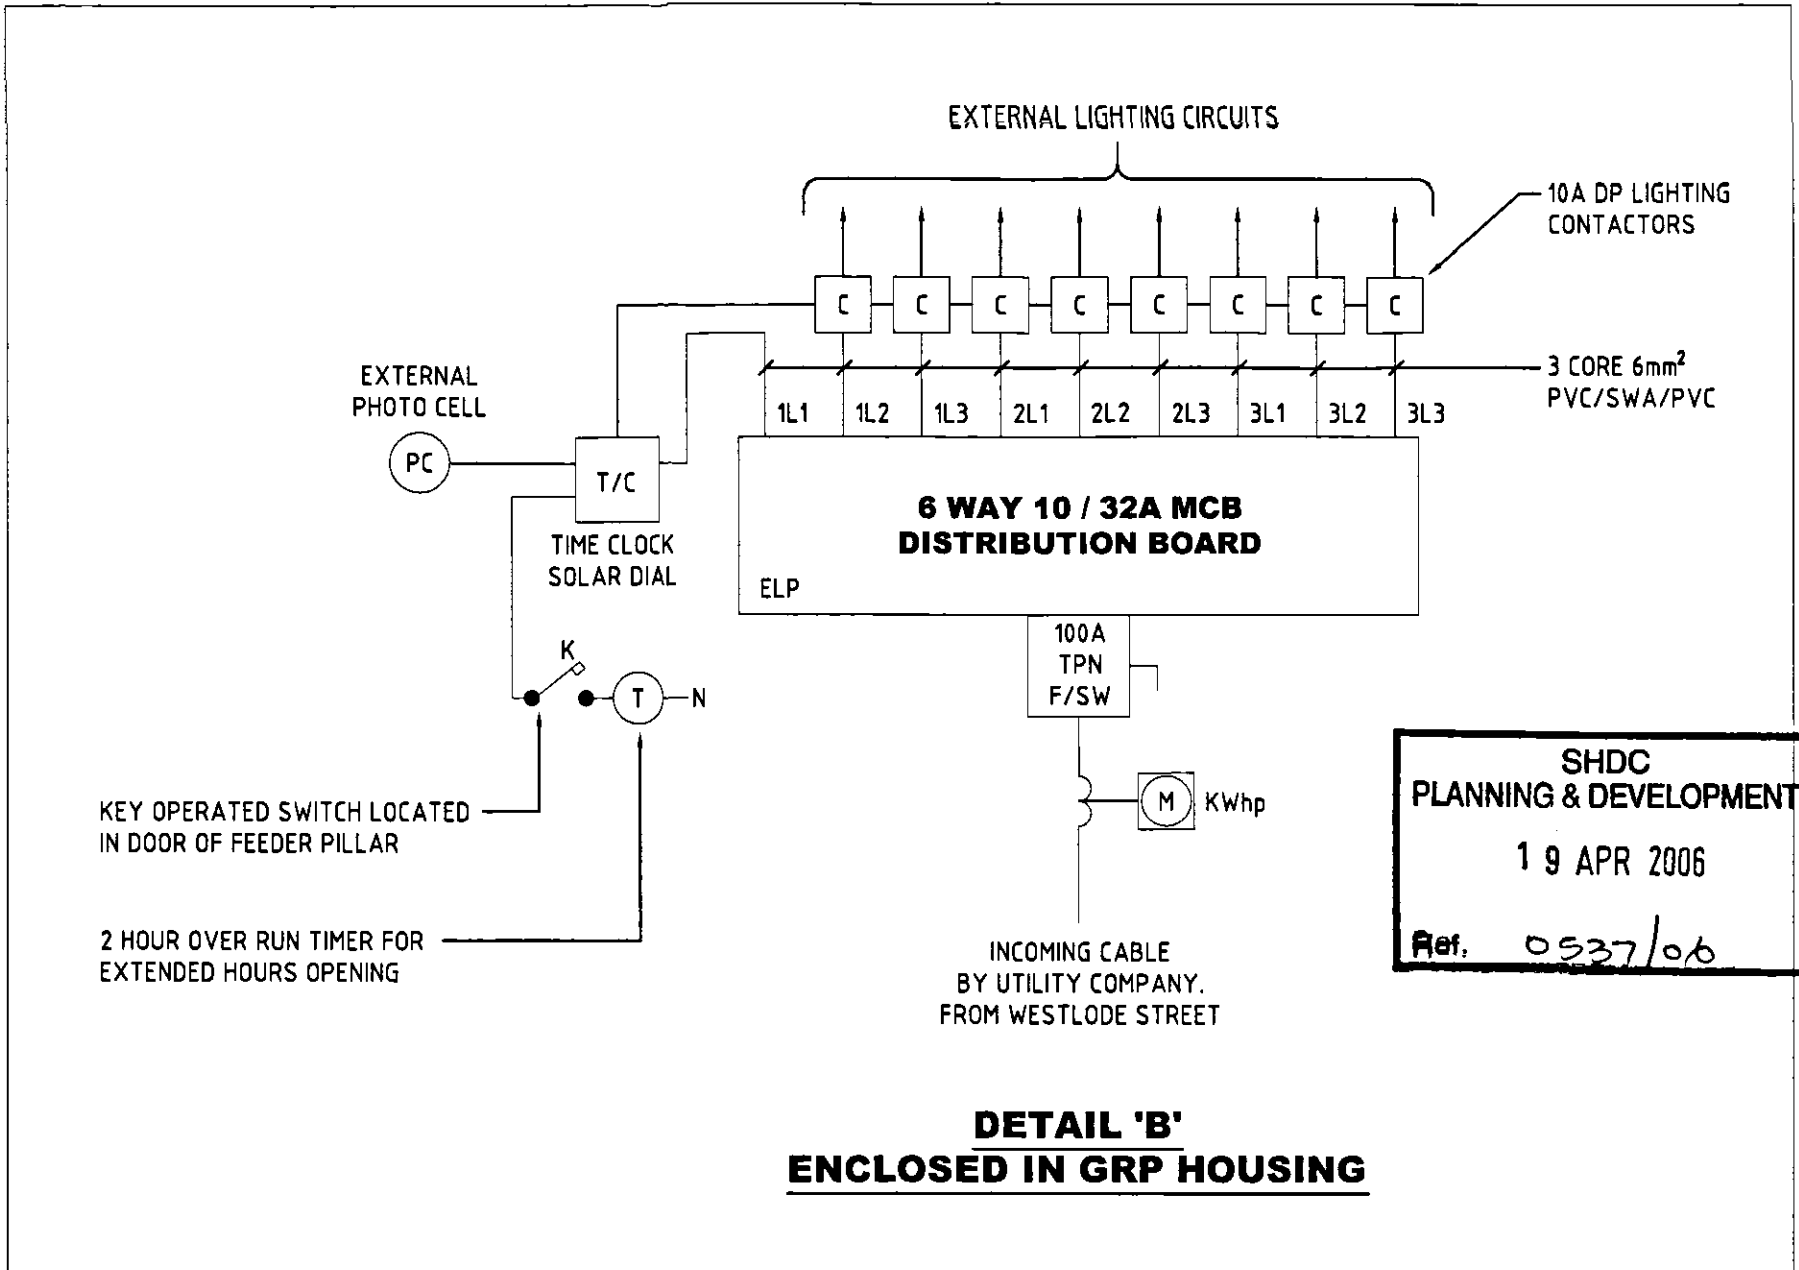
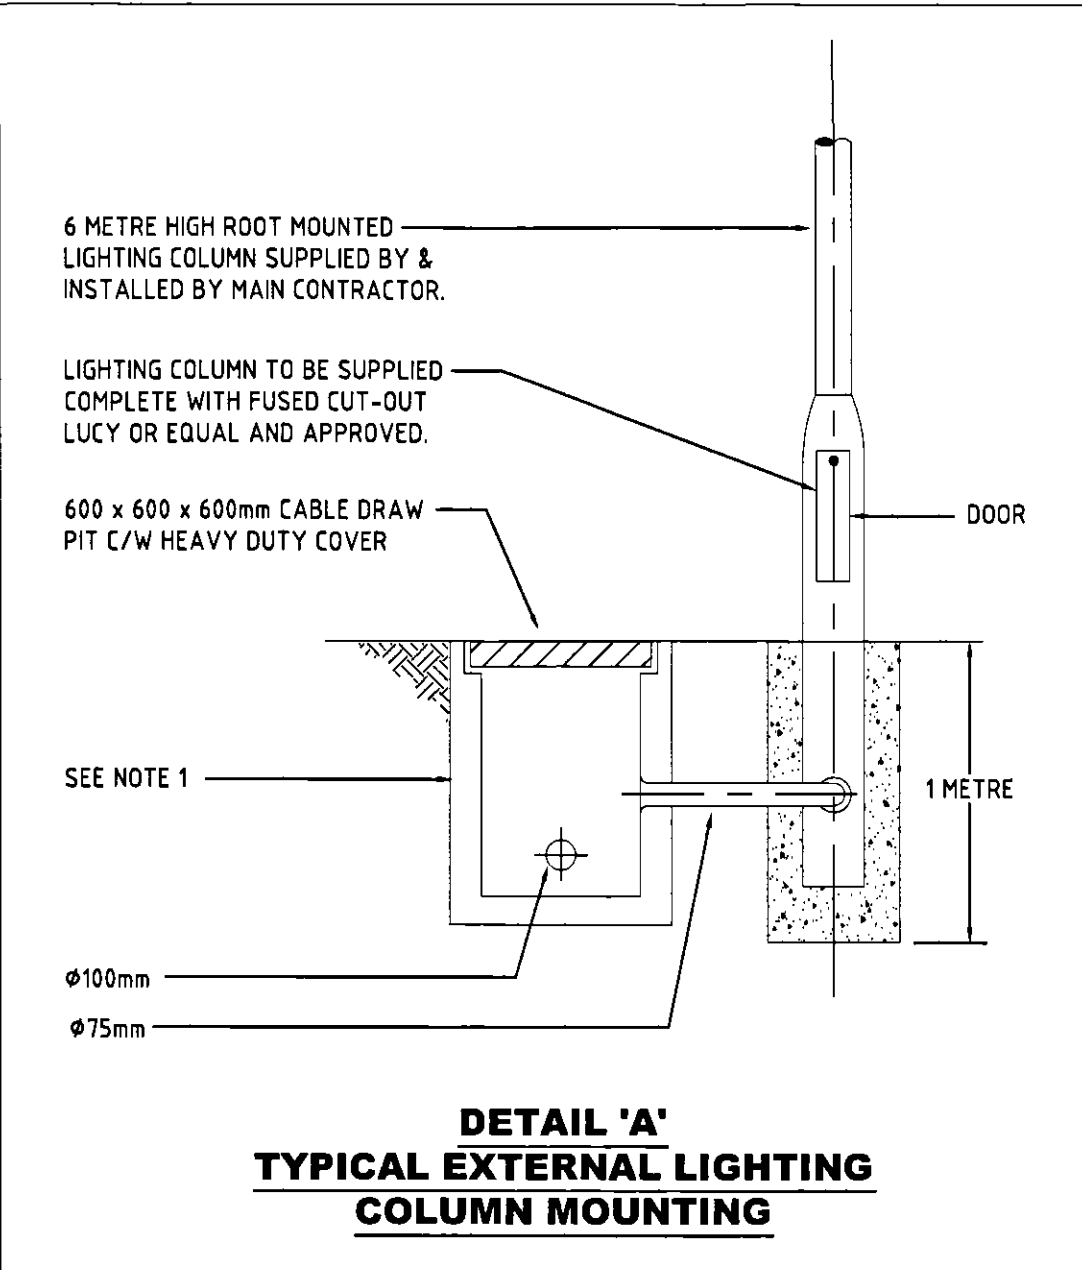


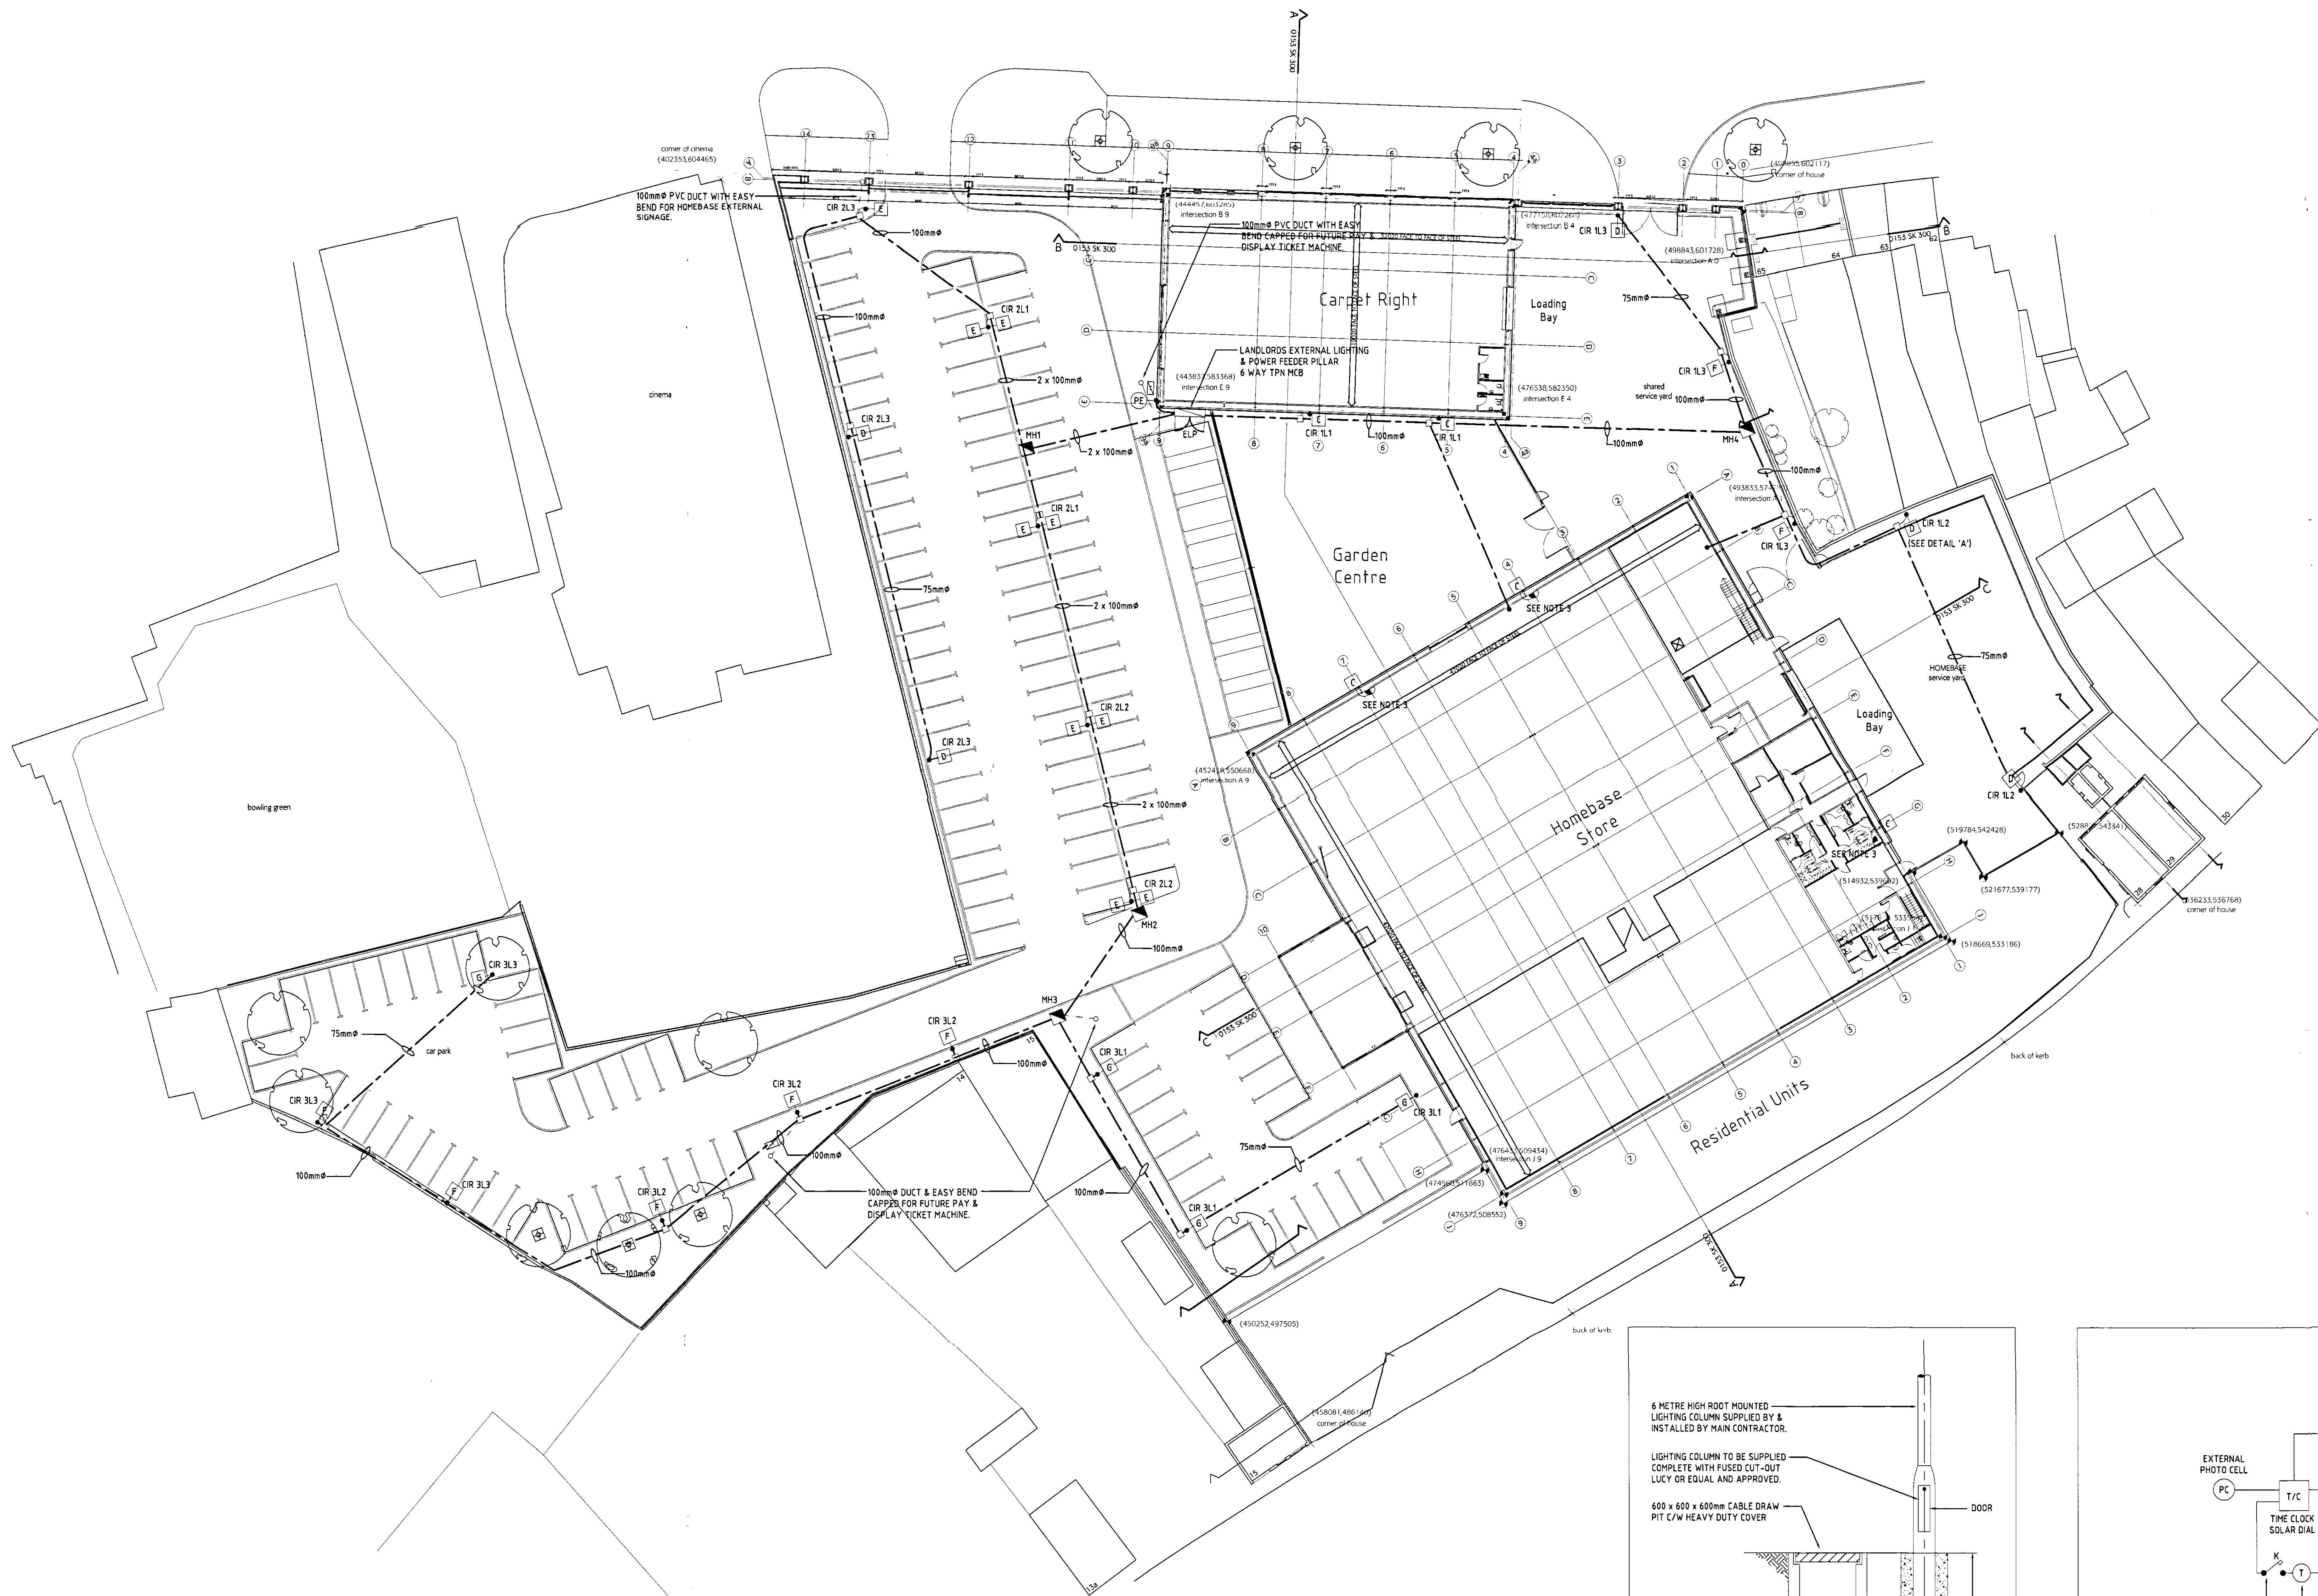

LUMINAIRE SCHEDULE				
SYMBOL	QUANTITY	HOLOPHANE CATALOGUE No.	DESCRIPTION	LAMP
C	5	SLF250HTEP AY60	SEATTLE MOUNTED OFF THE BUILDING @ 6M	250W CLEAR 4000K POSITIONED METAL HALIDE
D	5	ASL250HTEP FWC	AERIS LARGE FORWARD THROW CUTOFF MOUNTED ON A COLUMN @ 6M	250W MH EURO 4000K (POSITIONED ORIENTED)
E	4	ASMS150MTF3 AY	AERIS MEDIUM ASYMMETRIC MOUNTED ON A COLUMN @ 6M	150W CLEAR CDM-T 3000K METAL HALIDE (IG12)
F	8	ASMS150MTF3 FWC	AERIS MEDIUM FORWARD THROW CUTOFF MOUNTED ON A COLUMN @ 6M	150W CLEAR CDM-T 3000K METAL HALIDE (IG12)
G	4	ASMS150MTF3 AY	AERIS MEDIUM ASYMMETRIC MOUNTED ON A COLUMN @ 6M	150W CLEAR CDM-T 3000K METAL HALIDE (IG12)

General Notes

This drawing to be read in conjunction with all standard details and specifications.
All dimensions to be verified on site.
All works to comply with current building regulations.

NOTES

- ALL CIVIL WORKS TO BE CARRIED OUT BY MAIN CONTRACTOR.
- ALL DUCTS TO BE PVC BURIED TO A DEPTH IF 450mm TOP.
- WALL MOUNTED HOMEBASE LIGHTING TO BE CONNECTED TO AN INTERNAL ESA SPUR AND CONNECTED TO EXTERNAL LIGHTING CIRCUITS BY FIT OUT ELECTRICAL CONTRACTOR.
- ALL EXTERNAL LIGHTING COLUMNS TO BE SUPPLIED AND INSTALLED BY MAIN CONTRACTOR (SEE DETAIL 'A').

LEGEND

INDICATES PVC DUCTS. DIAMETER AS NOTED.

TENDER

Cudd Bentley Consulting Ltd
8 The Courtyard,
707 Westlode Road,
Spalding, Lincolnshire
PE34 5DA
Tel: +44 (0) 1544 828821
Fax: +44 (0) 1544 828848
Email: asoon@cuddbentley.co.uk

**C U D D
B E N T L E Y
CONSULTING**
www.cuddbentley.co.uk

**Building Services
Consultants**

Client: **BRIDE HALL DEVELOPMENTS LTD**

Project/Site Location: **70 WESTLODE STREET
SPALDING**

Drawing Title: **EXTERNAL LIGHTING LAYOUT**

Scale: 1:250
CAD: S.P.B.
Engineer: B.D.
Approved: A.P.T.
Date: Oct '05

CAD Reference: O:\Autocad Projects\2009_Bridehall - Spalding\Electrical\EO3

Project No: **2009**
Drawing No: **E03**
Revision: **A**