
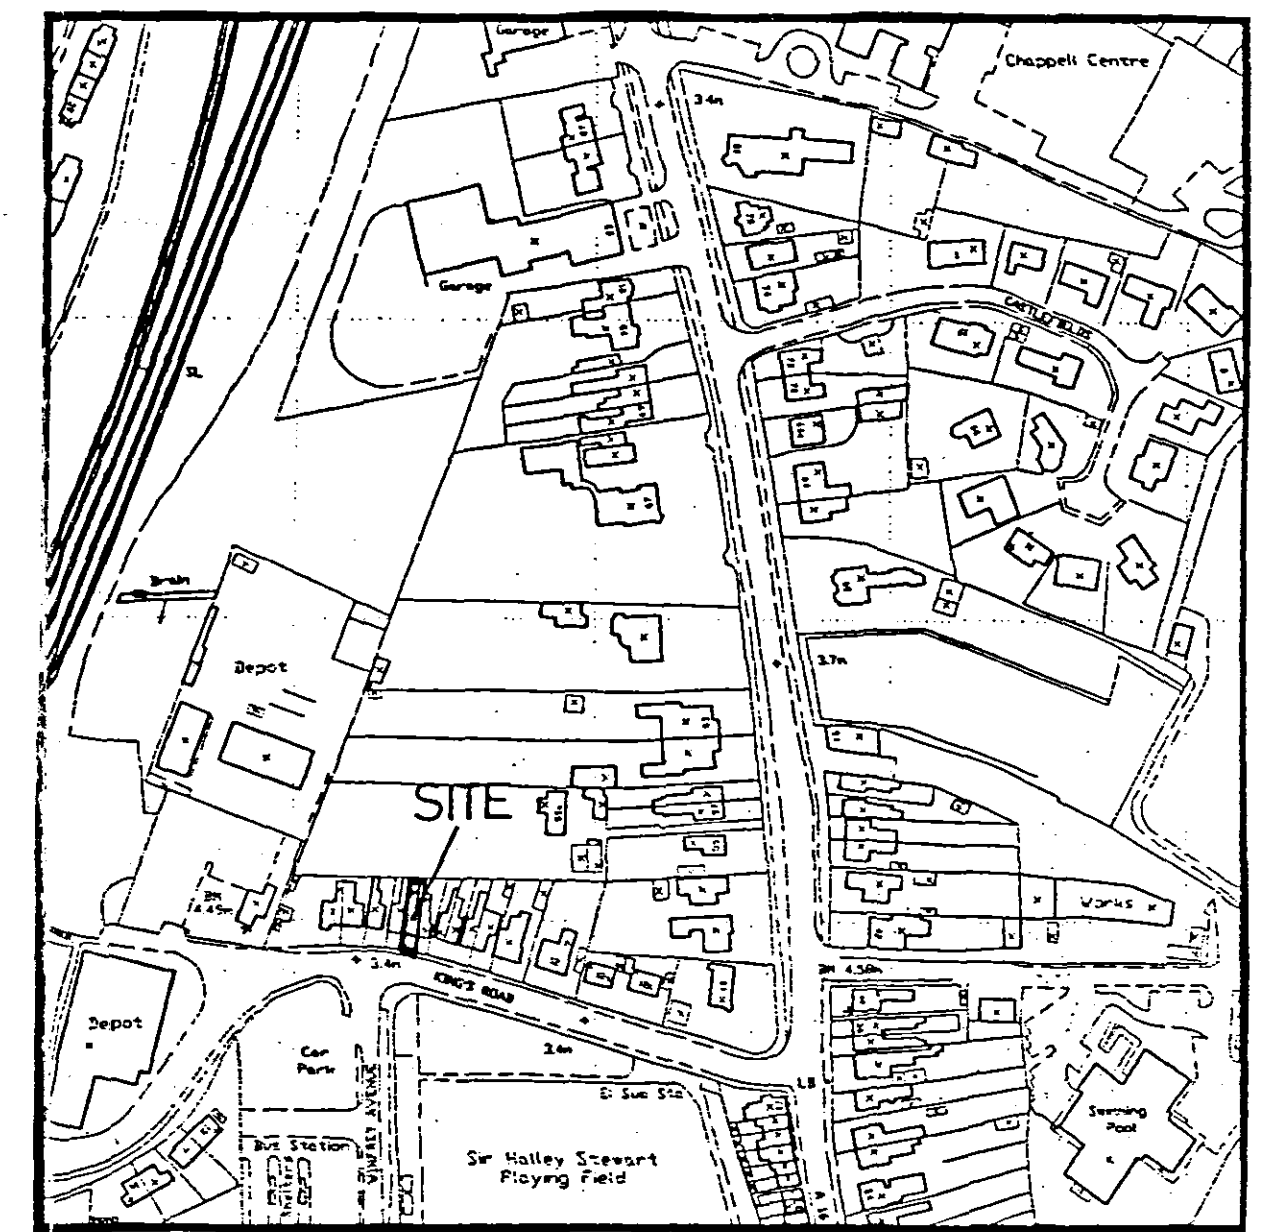


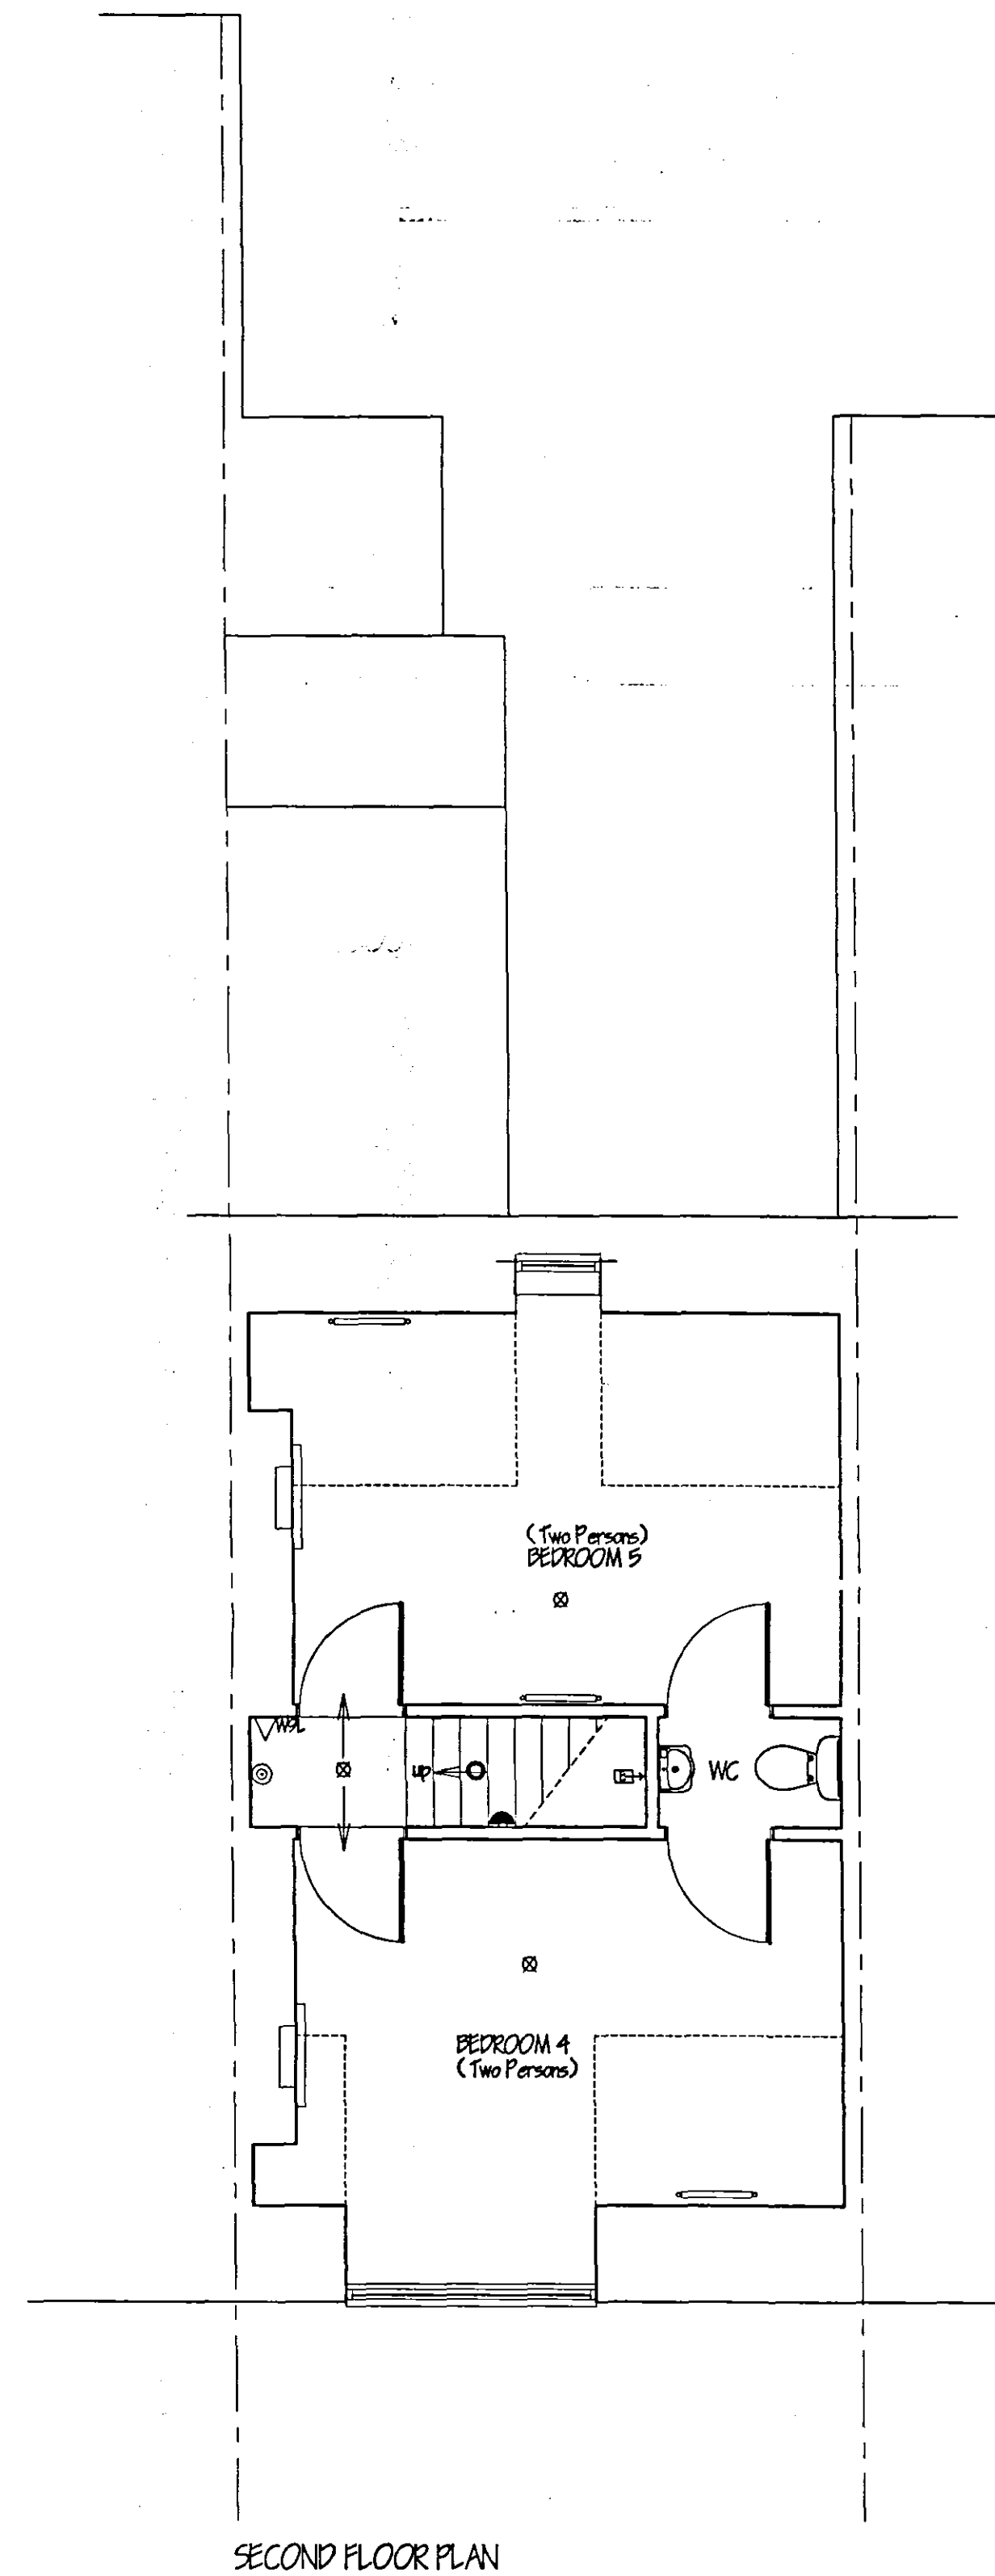

LEGEND

	WATER EXTINGUISHER
	CARBON DIOXIDE EXTINGUISHER
	HEAT DETECTOR
	SMOKE DETECTOR
	EMERGENCY LIGHTING
	FIRE BLANKET
	BREAK GLASS CALL POINT
	ALARM SOUNDER
	FIRE EXIT DIRECTION SIGN
	FIRE DOOR FITTED WITH SELF CLOSING DEVICE

A	AMEND ROOM DESIGNATION - PLANNING	AUGUST '06.

G. R. MERCHANT LTD.

I.ENG AMICE FIWO

**ARCHITECTURAL, STRUCTURAL
AND LAND DRAINAGE
CONSULTANTS**

**4 Wrights Mews
12A Park Road, Holbeach,
Spalding, Lincs. PE12 7ZE**

**Tel: 01406 490600
Fax: 01406 425744**

E-Mail: g.merchant@btconnect.com

Project

CHANGE OF USE TO H.M.O
5 KINGS ROAD
SPALDING
Lincs

Client
G&S PROPERTIES

Drawing

FLOOR PLANS
SITE & LOCATION PLANS

Job Ref. 1403-06	Drawing No. 01A.
---------------------	---------------------

DATE APRIL '06	Drawn CRM
-------------------	--------------

Scales
1/50 (unless otherwise stated)

[illegible]