
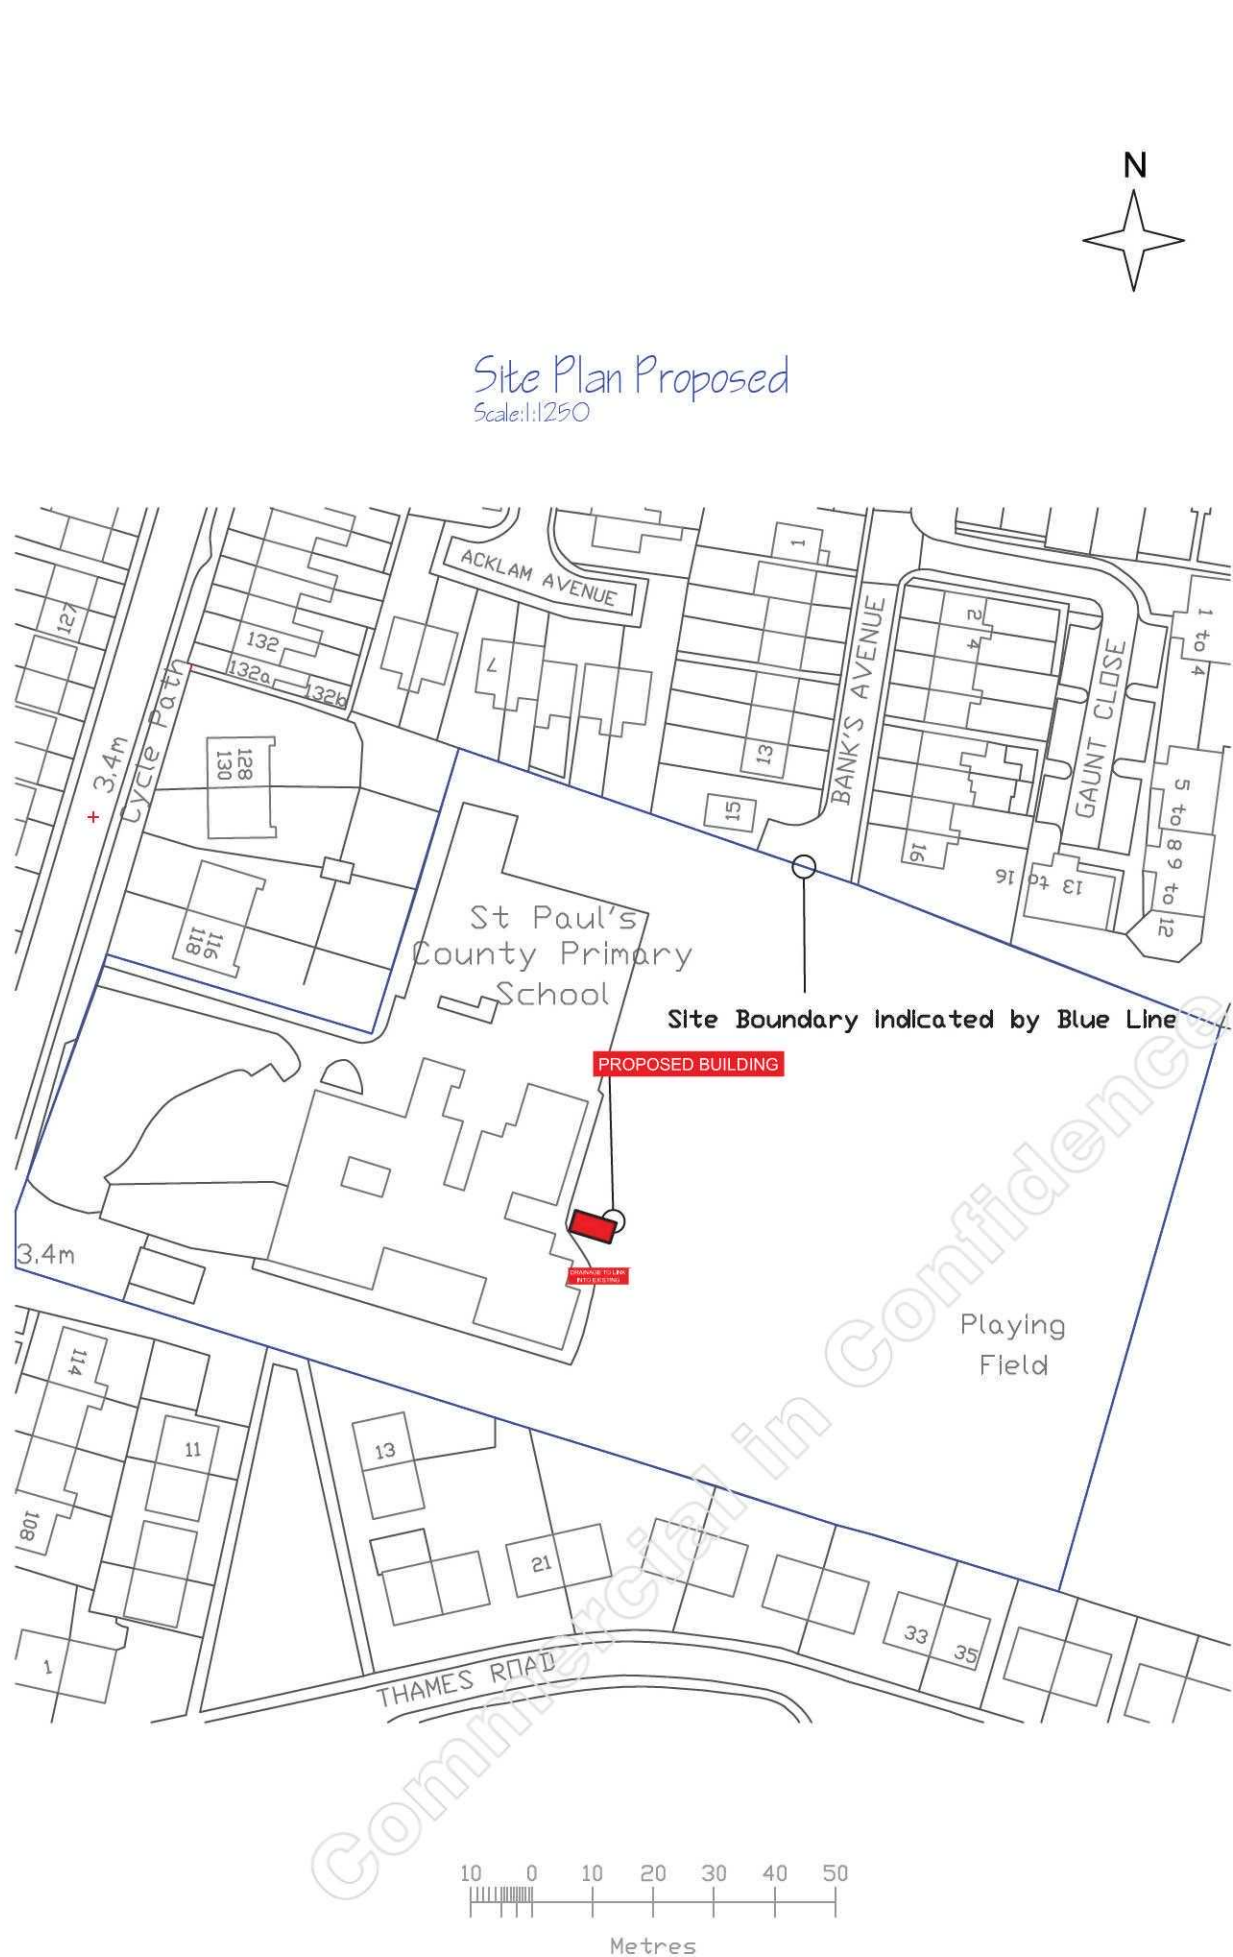


THE PURPOSE OF THIS PRELIMINARY DESIGN IS TO PROVIDE INFORMATION FOR FURTHER TECHNICAL AND OPERATIONAL EVALUATION. THIS DOCUMENT SHOULD NOT AT ALL BE CONSIDERED AS AN INSTRUCTION FOR CONSTRUCTION PURPOSES.

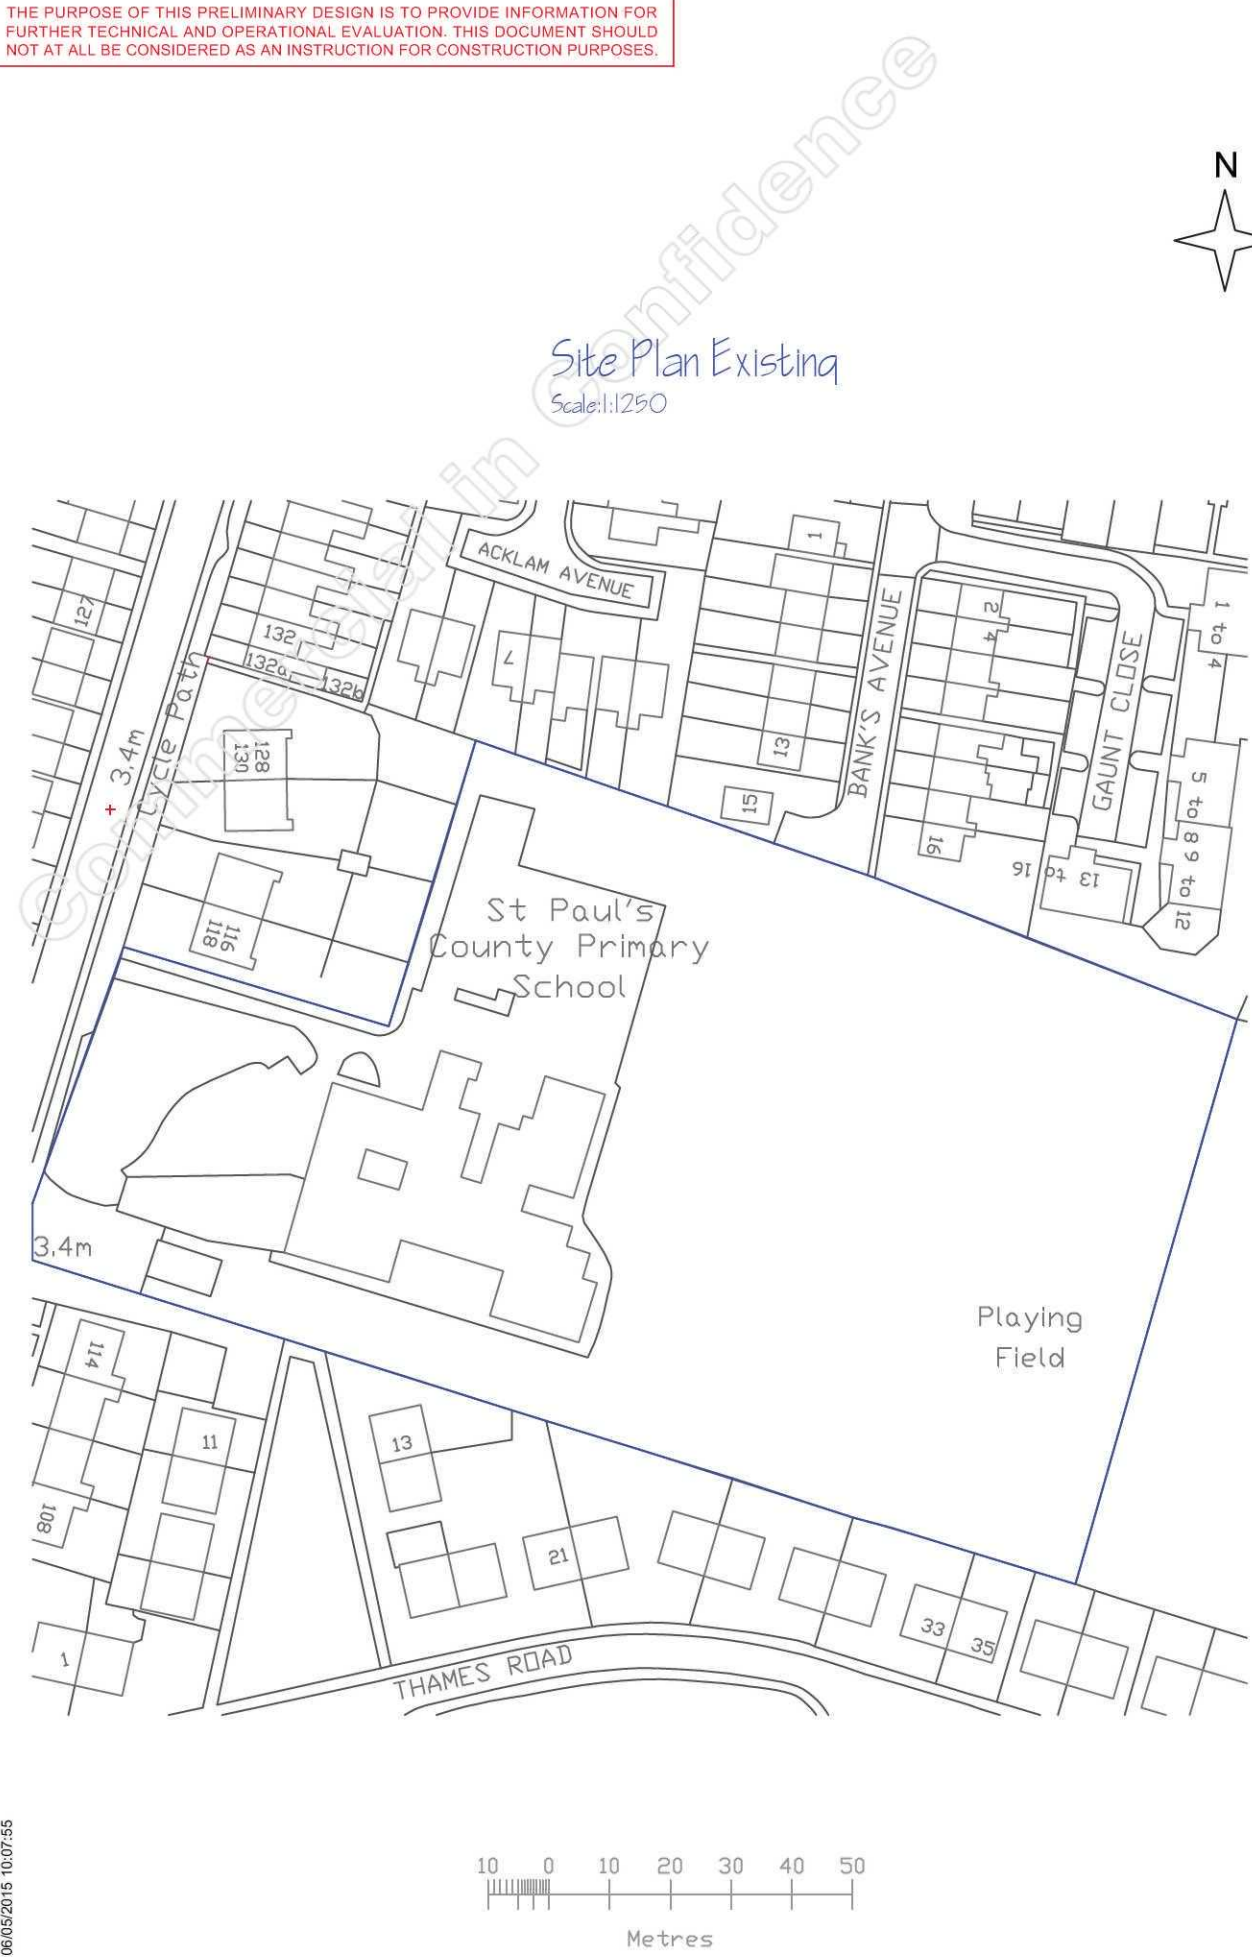

NOTES **A3 SHEET SIZE**

DRAINAGE:
All Foul drainage will be connected to St Paul's existing drainage.
Surface water connection to take rainwater that runs off hard areas in this case the roof into existing St Paul's School guttering.

Roofs generally in profiled metal and not visible behind fascia.
Down piping complimentary colour to adjacent areas alike the external render.

00	REV	DATE	DESCRIPTION	DR'N/CH'D
			FIRST ISSUE	

CLIENT	ST. PAUL'S CP SCHOOL & NURSERY		
PROJECT	KPO/192500		
TITLE	SITE PLAN EXISTING & SITE PLAN PROPOSED		
STATUS	DESIGN DEVELOPMENT		
ORIGINATOR	AG	SCALE (ON A3)	1:1250
DRAWN BY	AS	CREATED ON	18.02.2015
APPROVED BY	AG		

KP14383-EP-SP

00

DRAWING N°

REVISION

PKL Group (UK) Ltd

Malvern View Business Park

Stella Way

Bishops Cleeve

Cheltenham

Gloucestershire GL52 7DQ

United Kingdom

Tel: +44 (0) 1242 663000

Fax: +44 (0) 1242 677819

postbox@pkil.co.uk

www.pkil.co.uk

© 2011 PKL Group (UK) Ltd

This document and all information herein is confidential and the intellectual property of PKL Group (UK) Ltd. It is classified in accordance with terms that it will not be disclosed in any form, orally, written, or otherwise, without the prior written consent of PKL Group (UK) Ltd. The copyright is reserved by PKL Group (UK) Ltd. © 2011 PKL Group (UK) Ltd.