


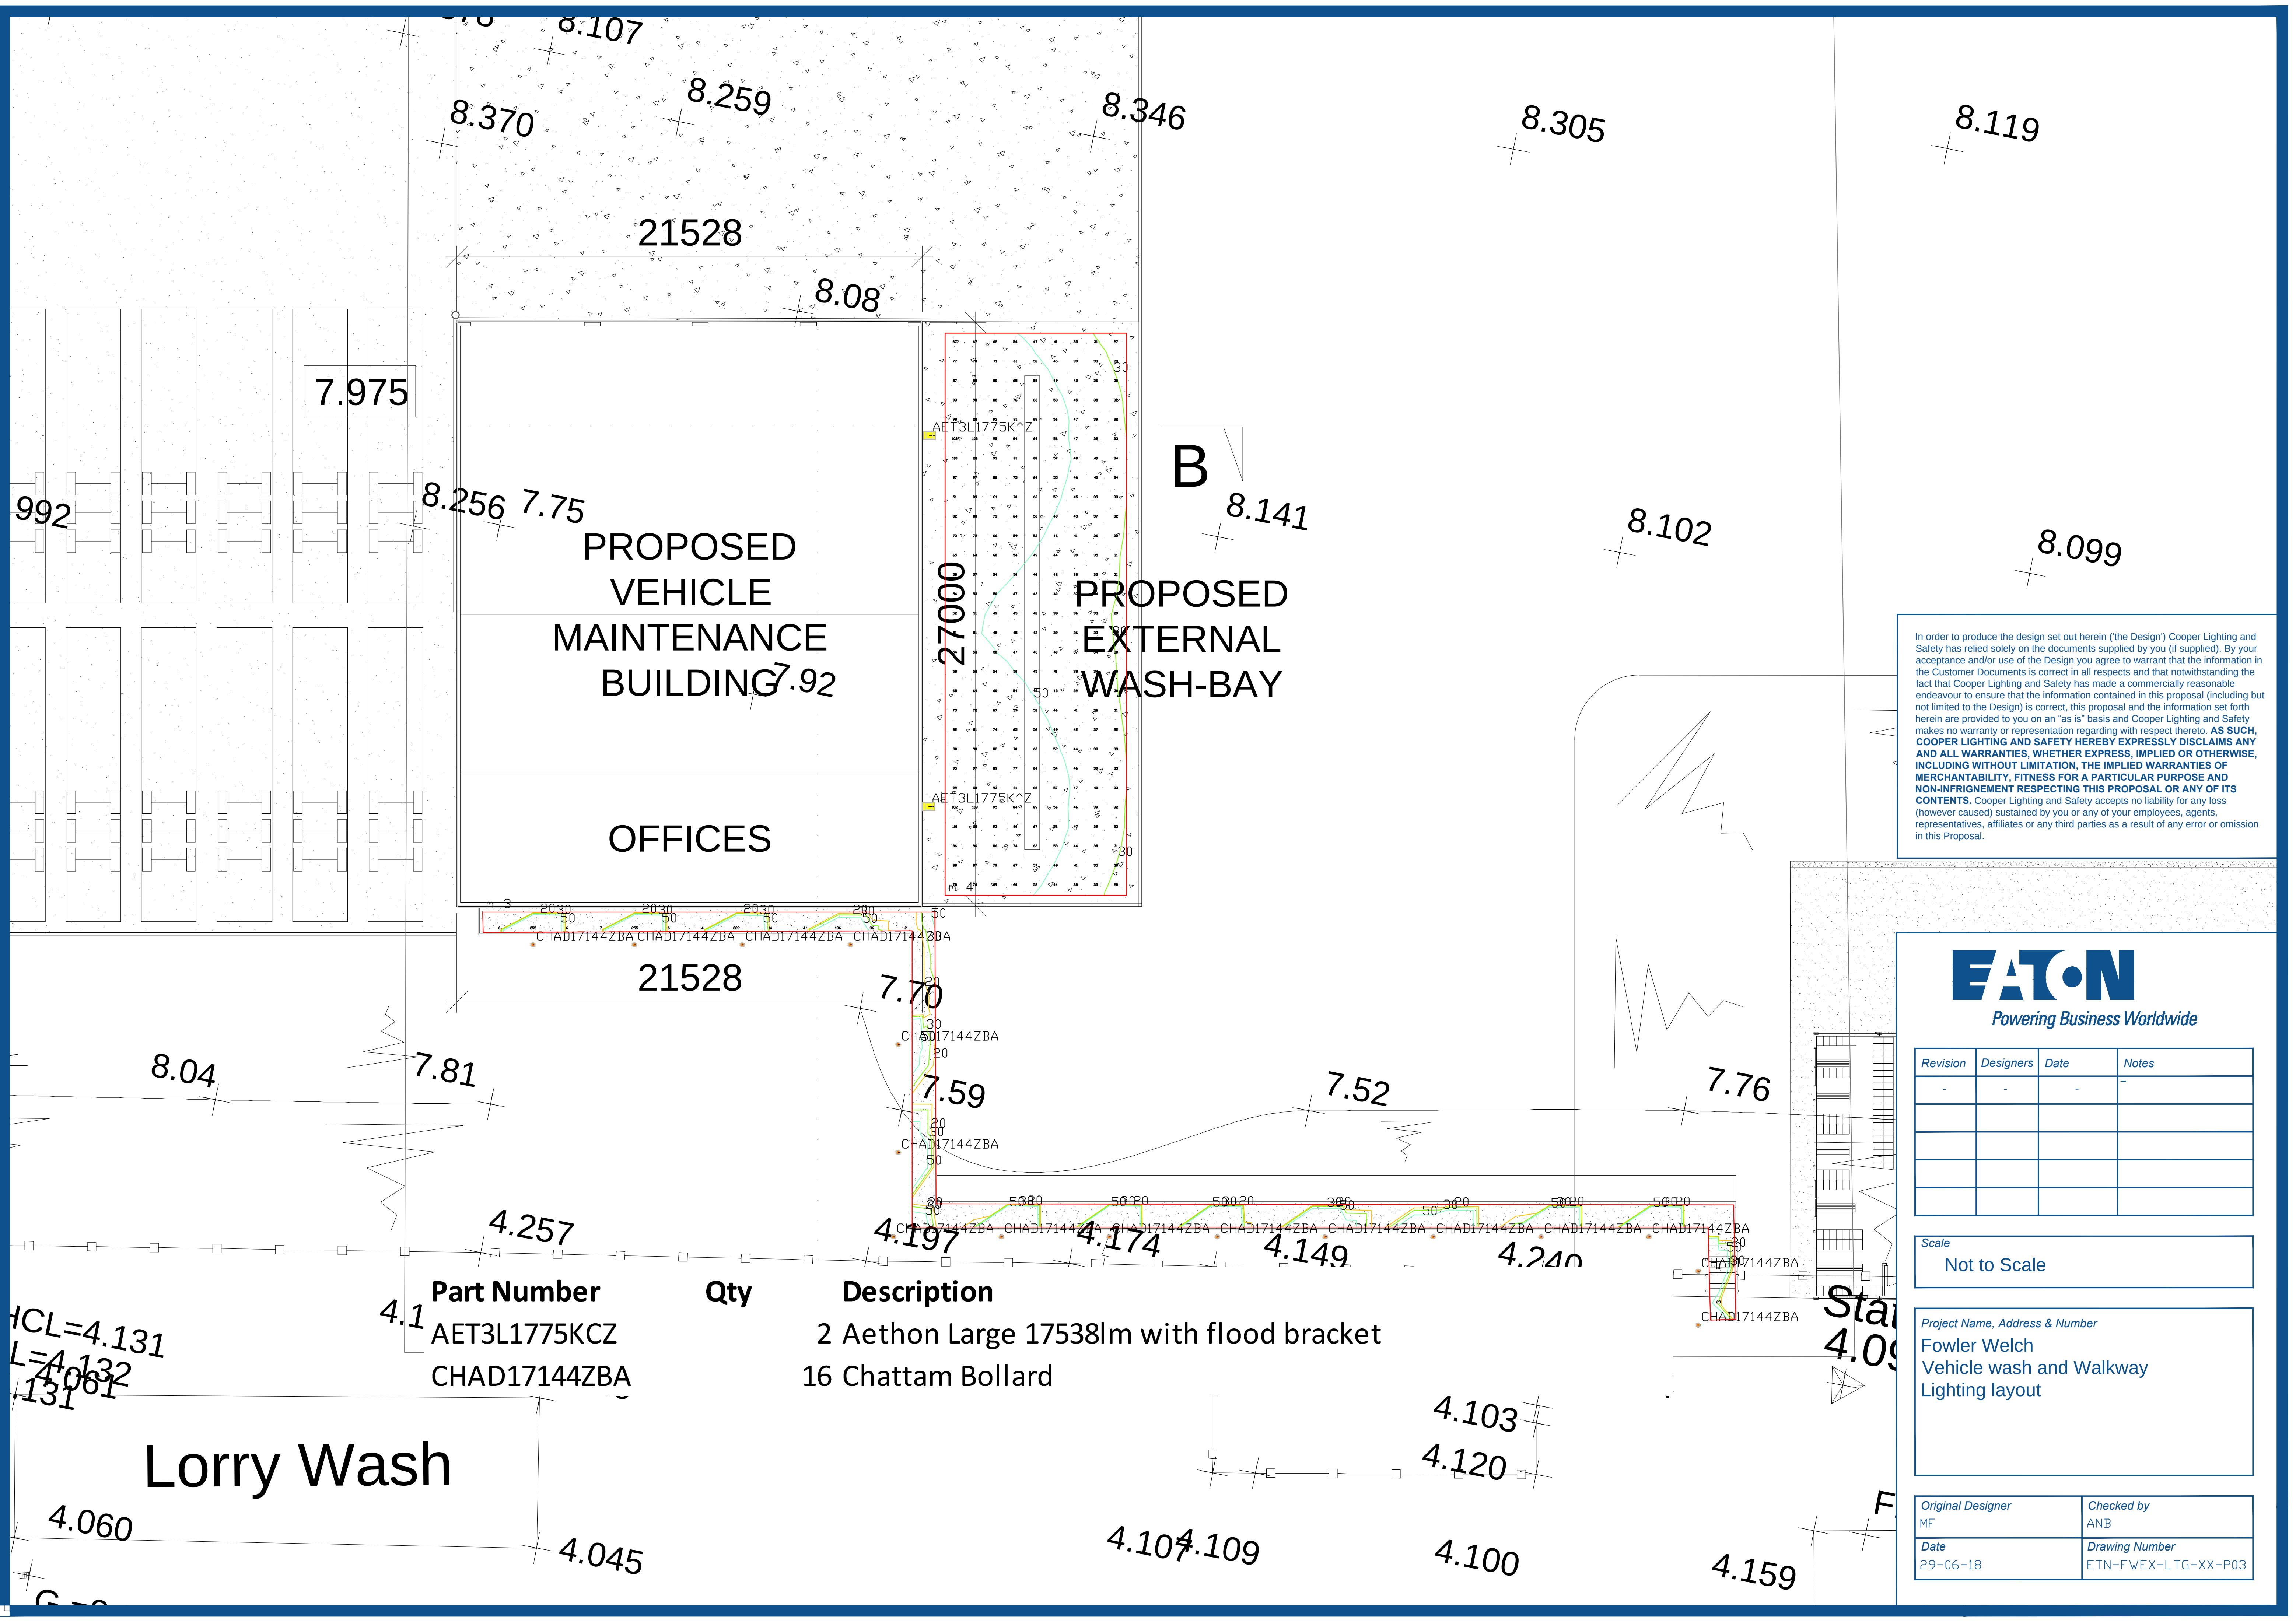

In order to produce the design set out herein ('the Design') Cooper Lighting and Safety has relied solely on the documents supplied by you (if supplied). By your acceptance and/or use of the Design you agree to warrant that the information in the Customer Documents is correct in all respects and that notwithstanding the fact that Cooper Lighting and Safety has made a commercially reasonable endeavour to ensure that the information contained in this proposal (including but not limited to the Design) is correct, this proposal and the information set forth herein are provided to you on an "as is" basis and Cooper Lighting and Safety makes no warranty or representation regarding with respect thereto. **AS SUCH, COOPER LIGHTING AND SAFETY HEREBY EXPRESSLY DISCLAIMS ANY AND ALL WARRANTIES, WHETHER EXPRESS, IMPLIED OR OTHERWISE, INCLUDING WITHOUT LIMITATION, THE IMPLIED WARRANTIES OF MERCHANTABILITY, FITNESS FOR A PARTICULAR PURPOSE AND NON-INFRINGEMENT RESPECTING THIS PROPOSAL OR ANY OF ITS CONTENTS.** Cooper Lighting and Safety accepts no liability for any loss (however caused) sustained by you or any of your employees, agents, representatives, affiliates or any third parties as a result of any error or omission in this Proposal.



Powering Business Worldwide

Revision	Designers	Date	Notes
-	-	-	-

Scale
Not to Scale

Project Name, Address & Number
Fowler Welch
Vehicle wash and Walkway
Lighting layout

Original Designer MF	Checked by ANB
Date 29-06-18	Drawing Number ETN-FWEX-LTG-XX-P03