



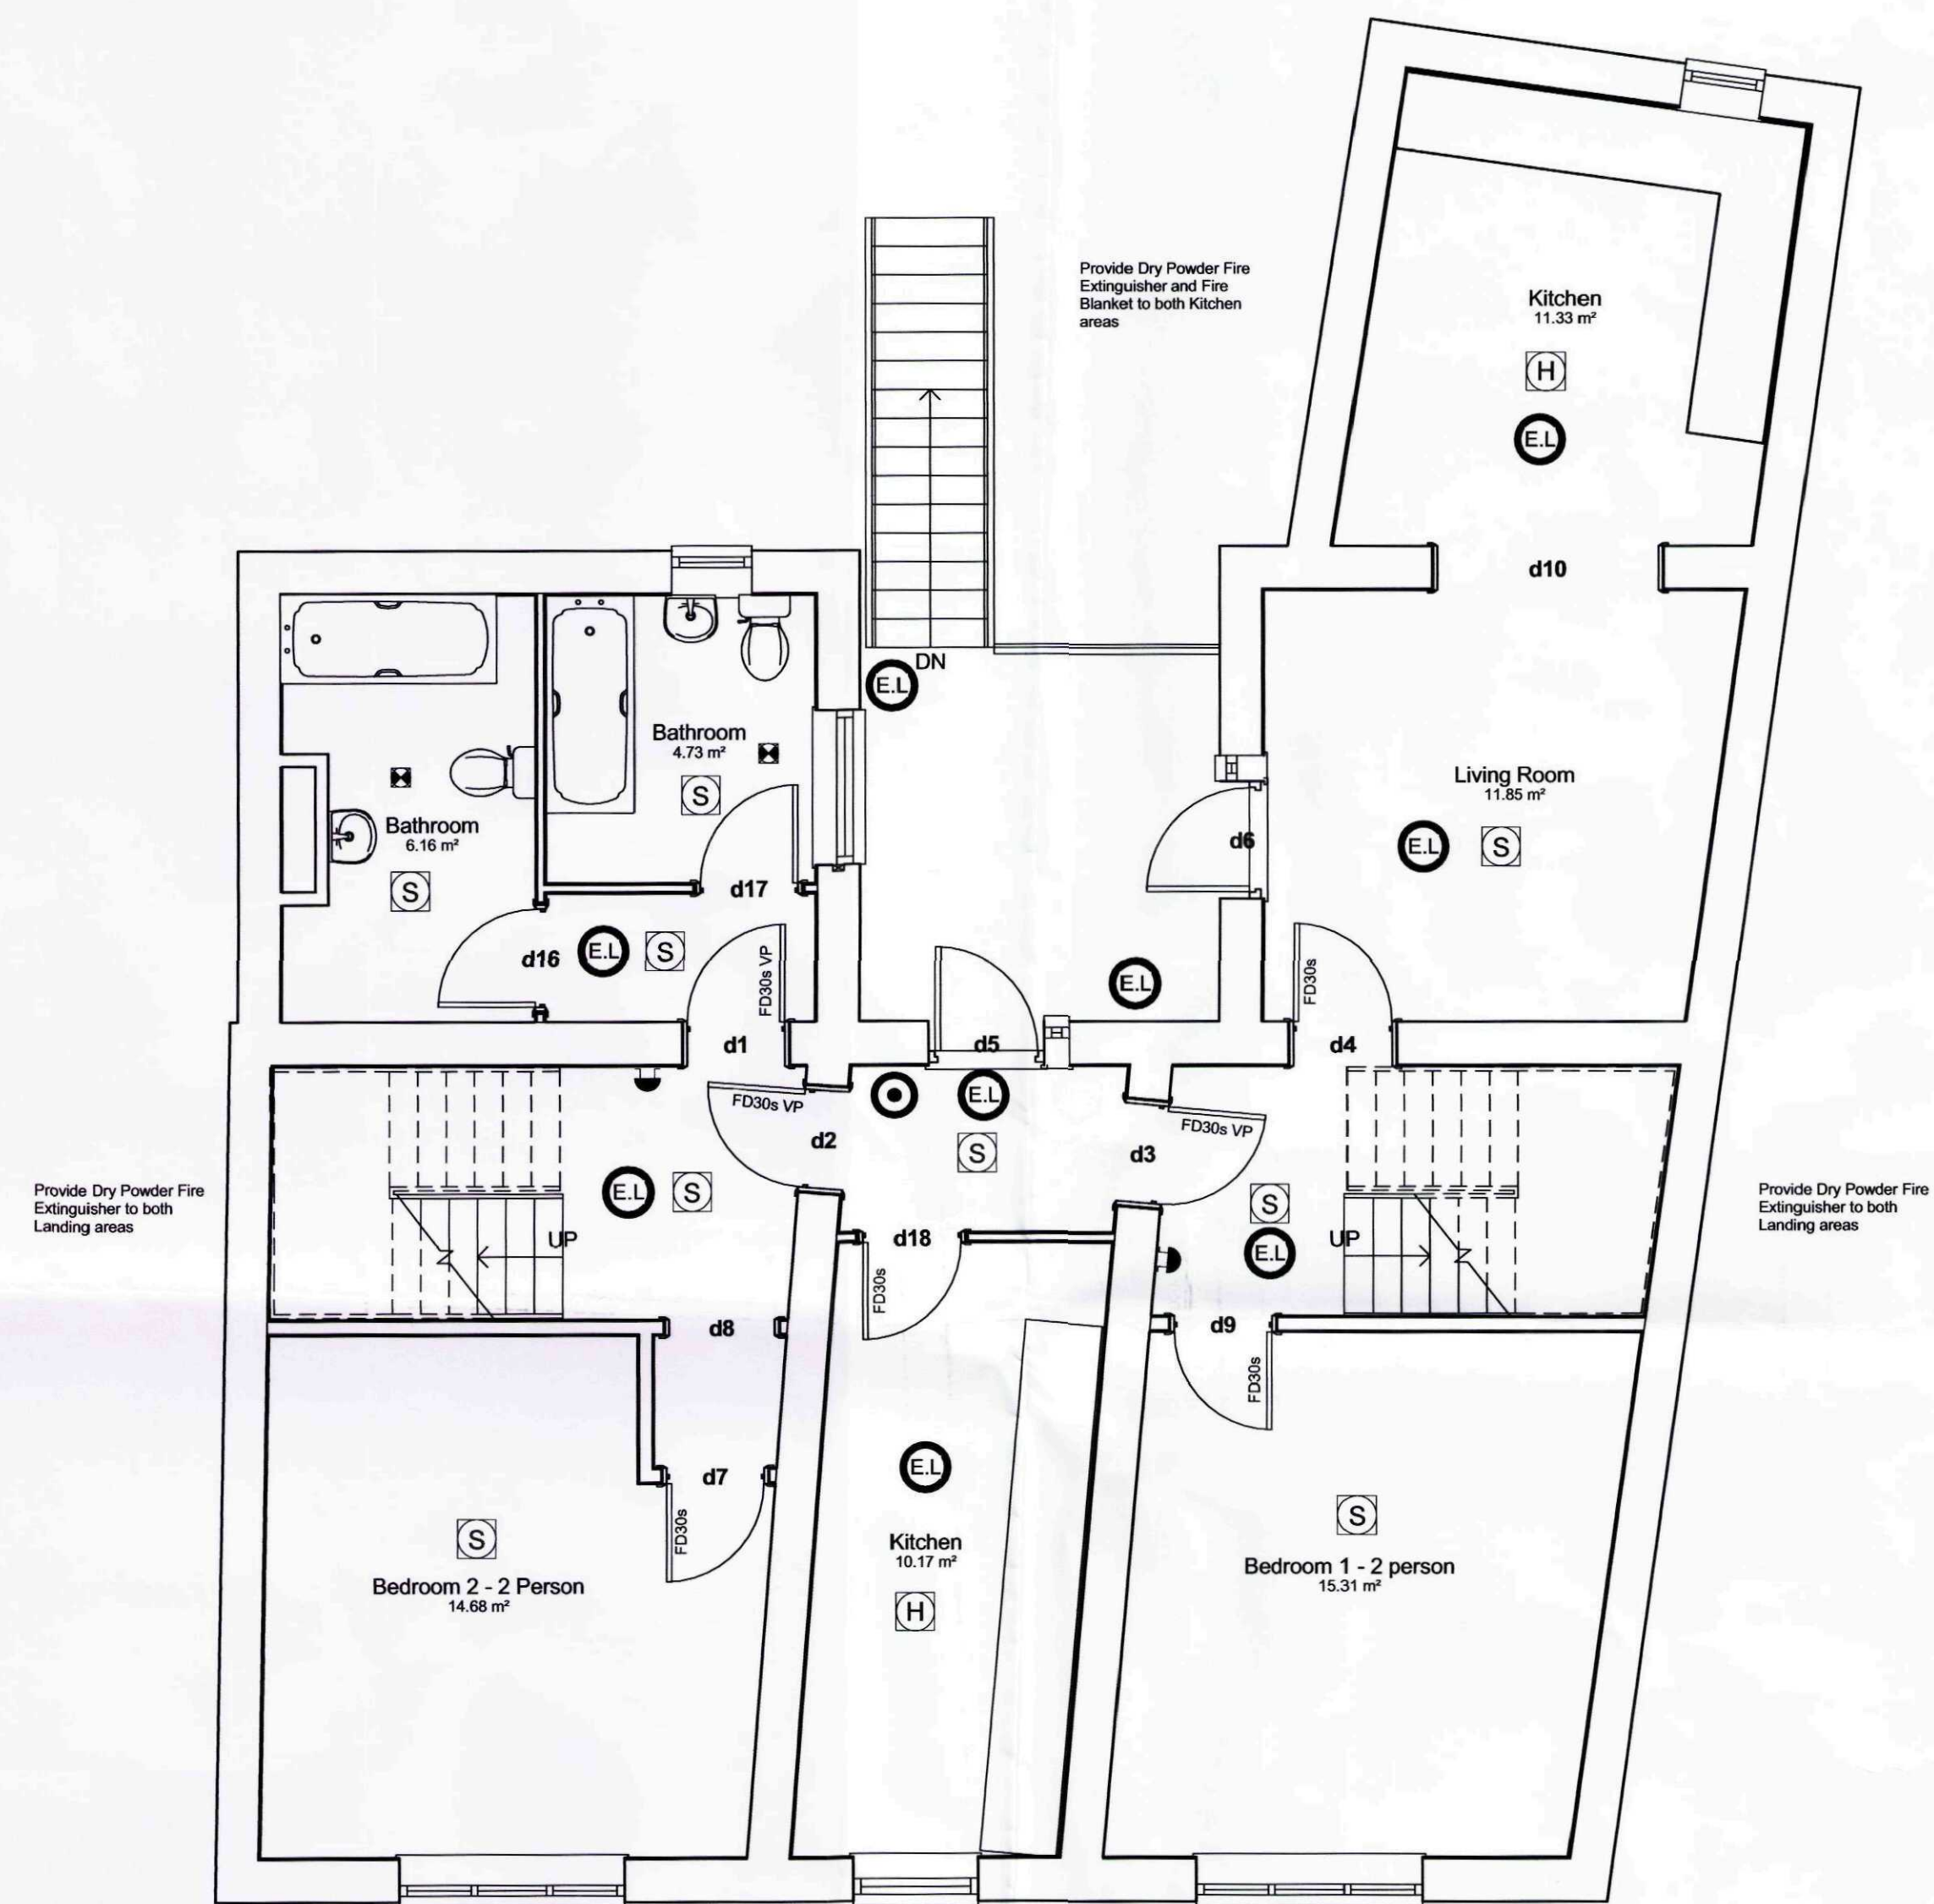

1 1st Floor
1 : 50

- EL Emergency Lighting
- S Smoke Detector
- H Heat Detector
- B.G.U. Fire Alarm B.G.U.
- Fire Alarm Sounder

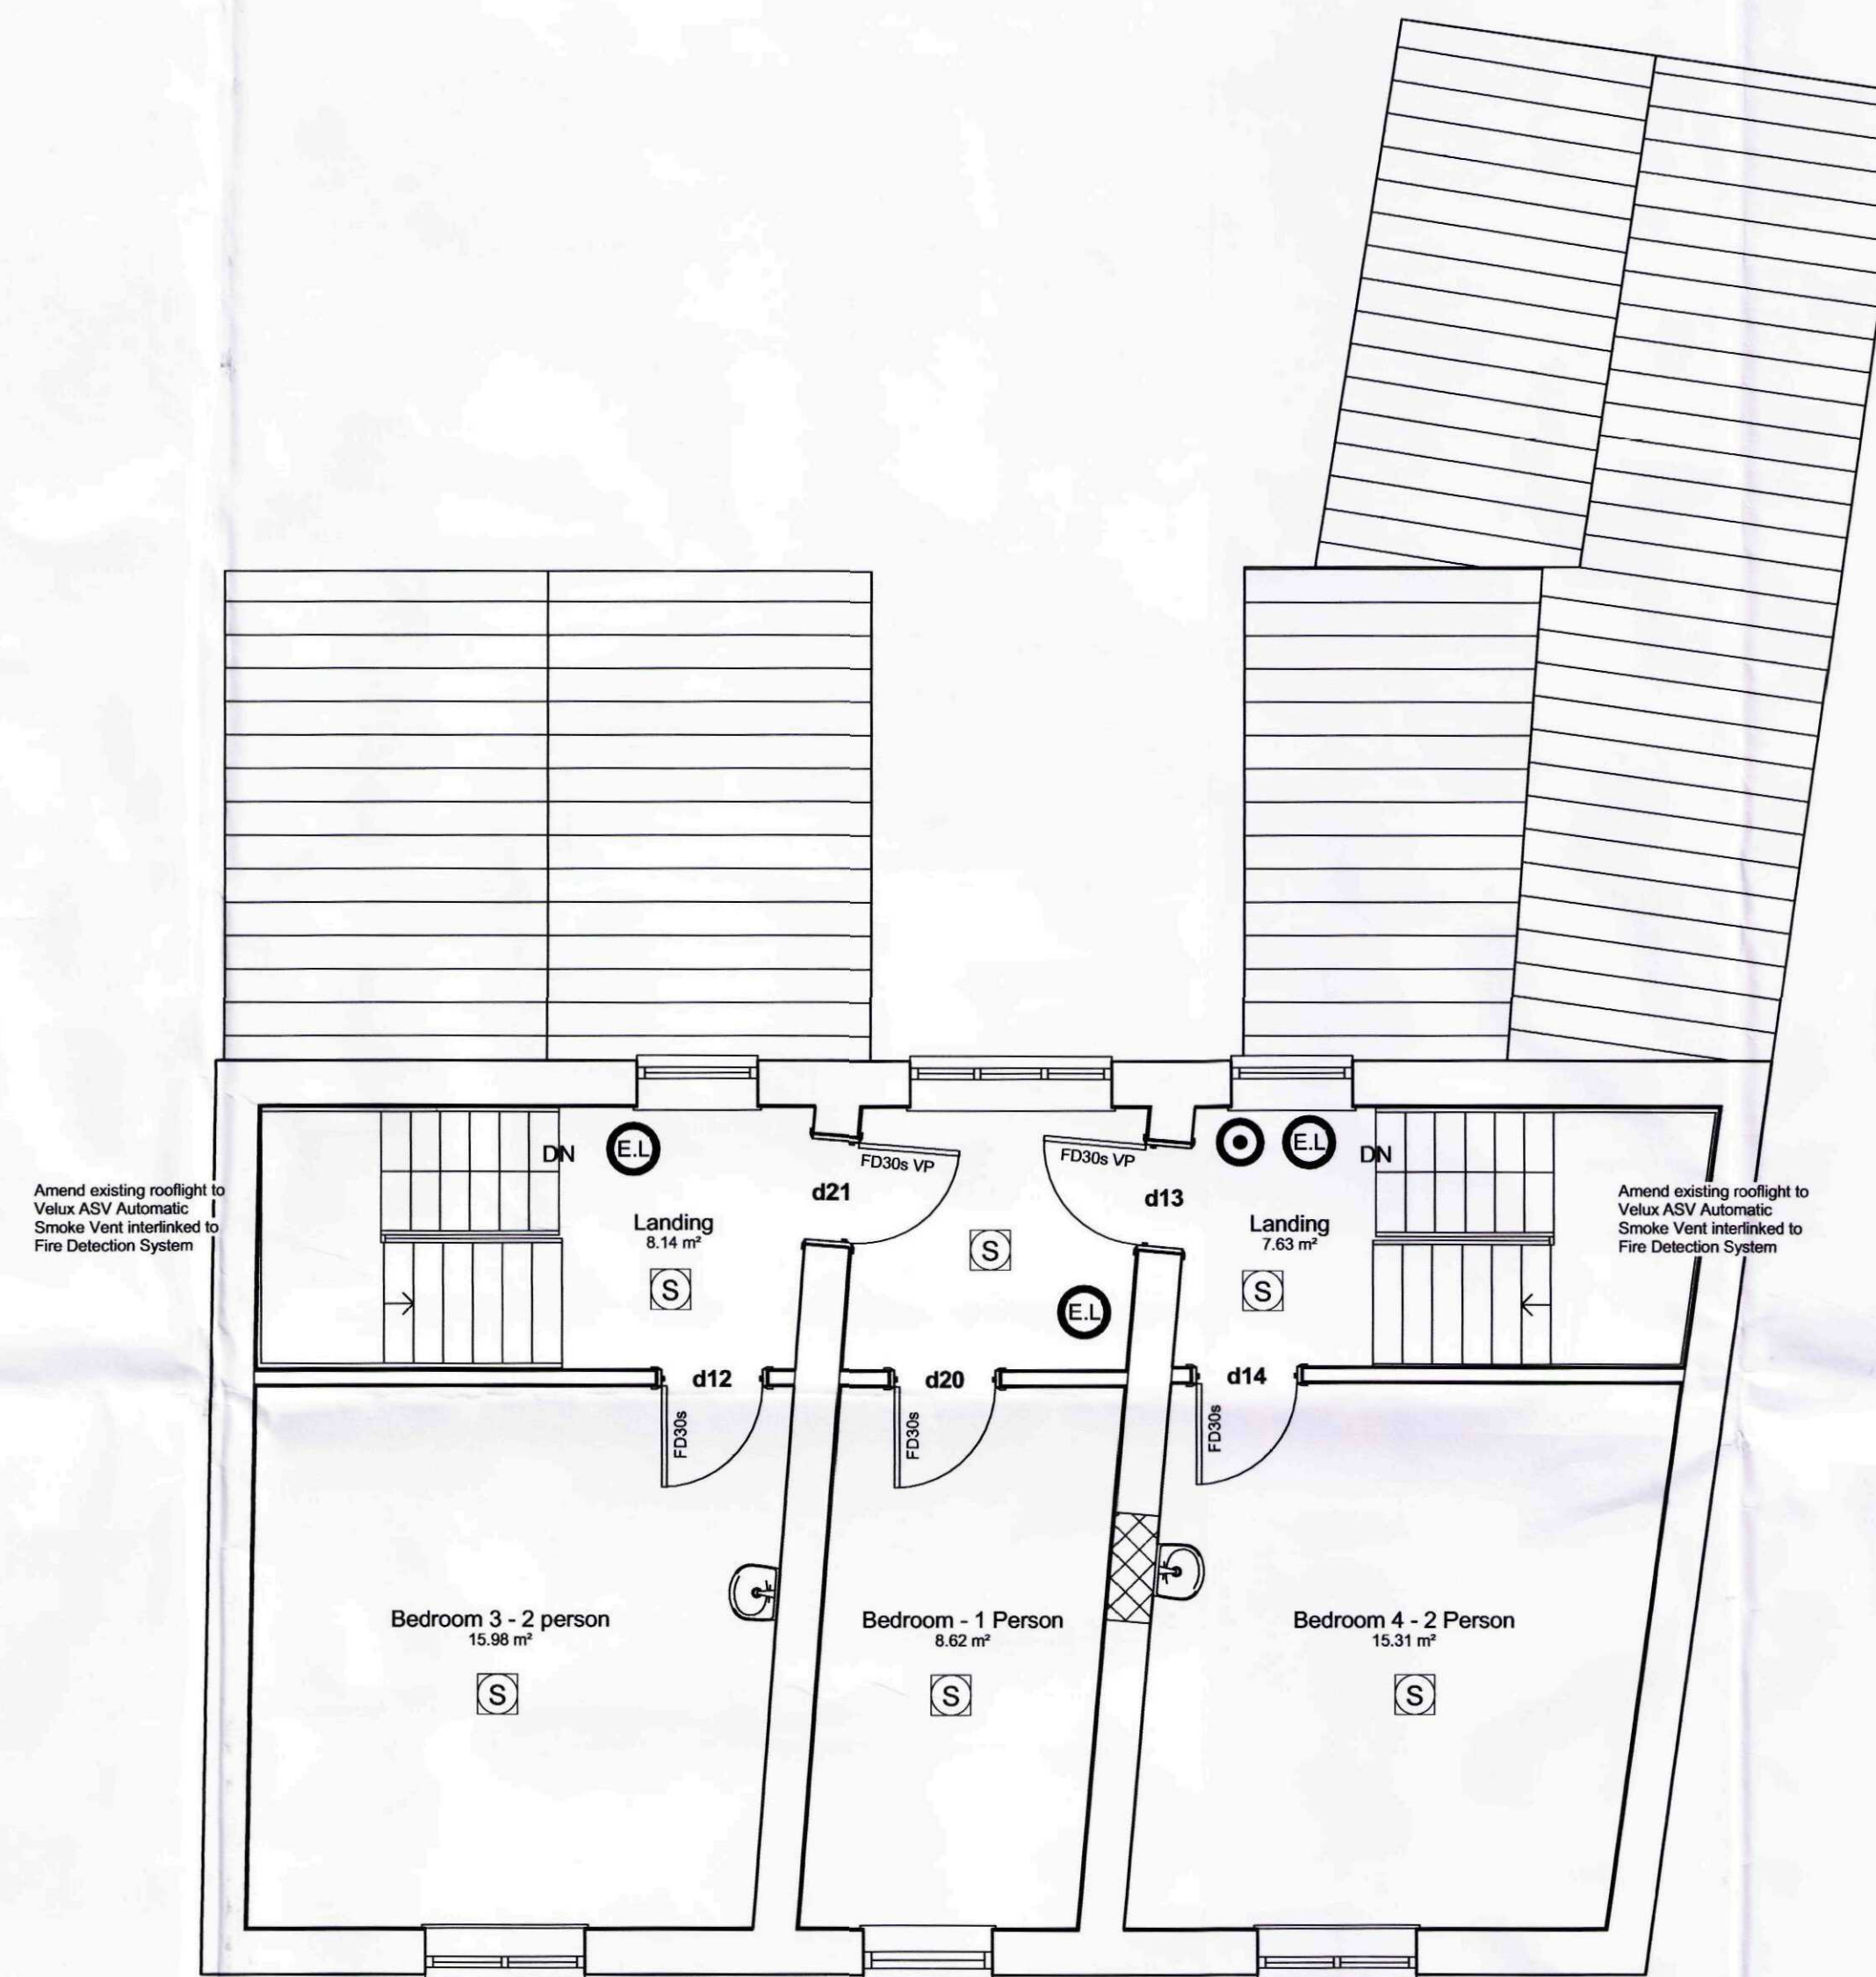

2 2nd Floor
1 : 50

Fire Alarm system should be designed & installed in accordance with BS 5839 Part 1 2002 + A2:2008 Fire Detection & Alarm Systems for Buildings - L2 Category

Emergency Lighting System should be designed & installed in accordance with BS 5266 Part 1 2005

Fire Safety Signage should comply with BS 5499 Part 1 2002

Installation and commissioning certificates will be required for the emergency lighting, fire alarm, and detection system.

FD30s = 30mins Fire Resistant Door with Perimeter Seals.

FD30sVP = 30mins Fire Resistant Door with Vision Panels and Perimeter Seals.

GENERAL CONDITIONS
Contractors are responsible for checking all dimensions on site when work commences and before ordering any materials. Any discrepancies should be brought to the attention of the Client for remedial action before commencing further.
All materials not specified to be of a standard suitable for the work proposed and be fit for purpose. All work to be in accordance with good building practice and all necessary BS codes for Workmanship on Building Sites.

Planning Issue Only

Revisions

Client: Mr J Ferreira

Site: Proposed 9 Person HMO
at 15 New Road, Spalding

Dwg Title: Proposed Plans



2nd Floor - 5B Sheepmarket
Spalding
PE11 1BH
Tel : 01775 768 921
e-mail: enquiries@remwaydesign.co.uk

Drawing Number: a1 2074-02
Revision: