




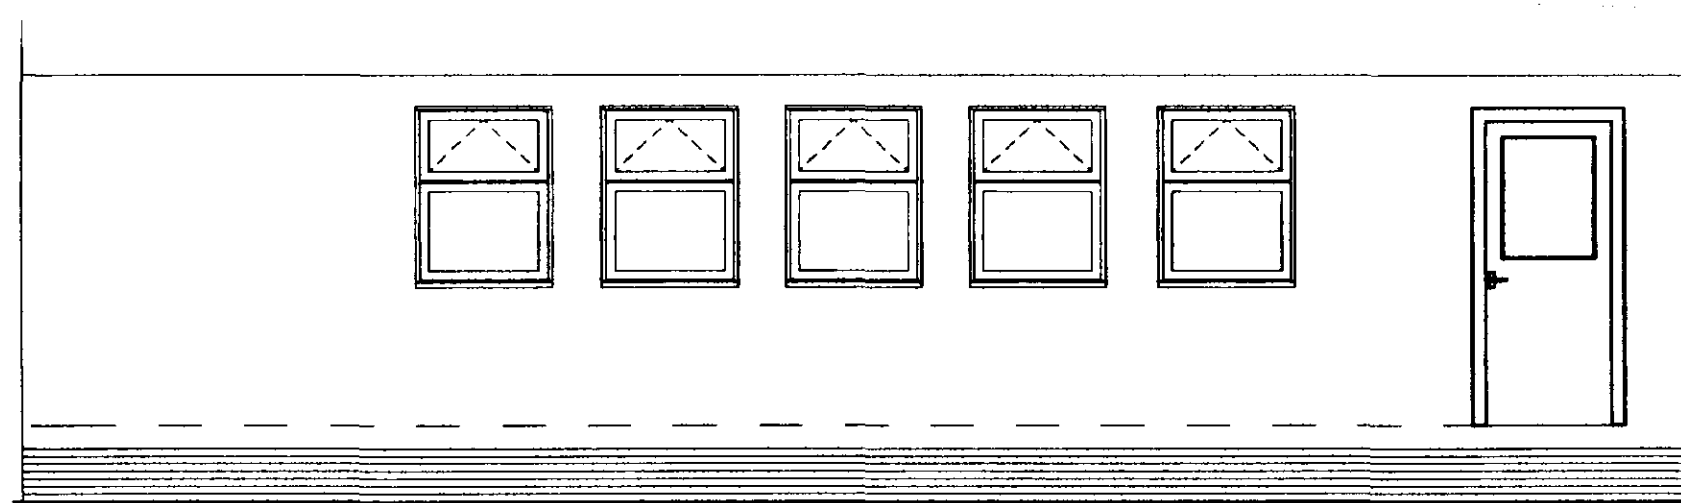


Front Elevation

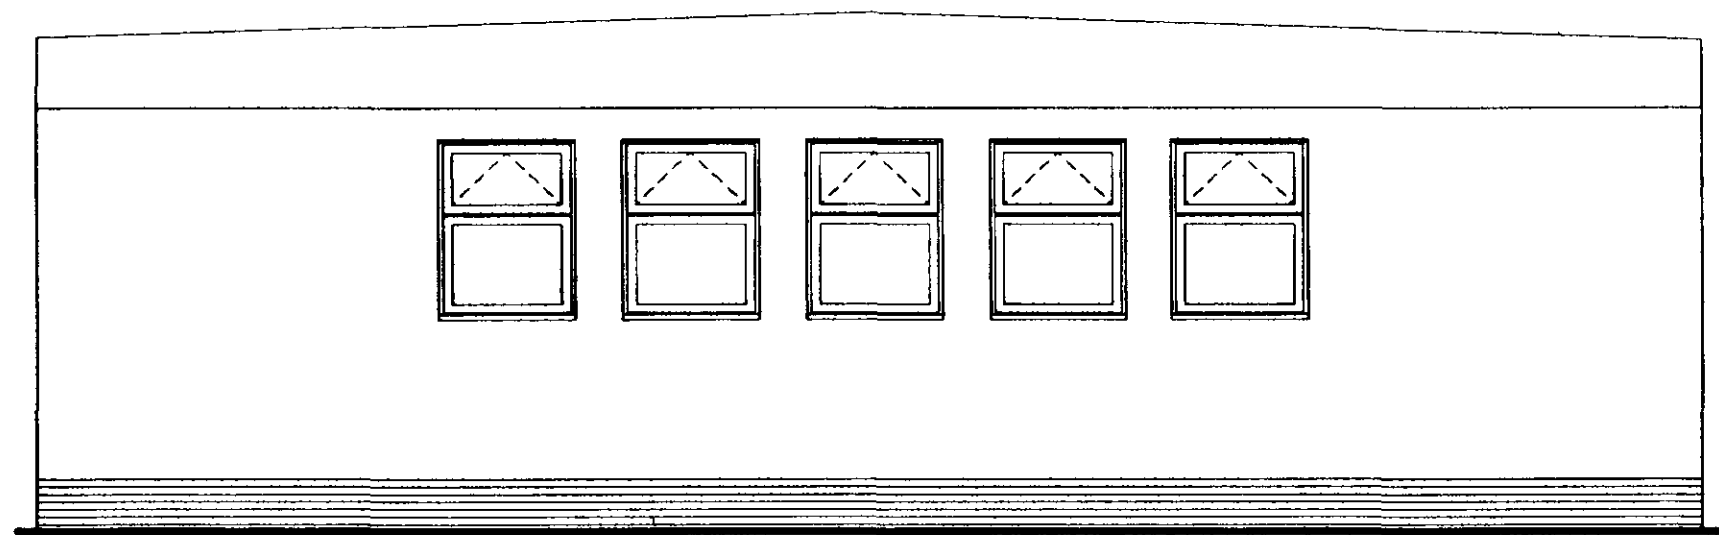

Rear Elevation

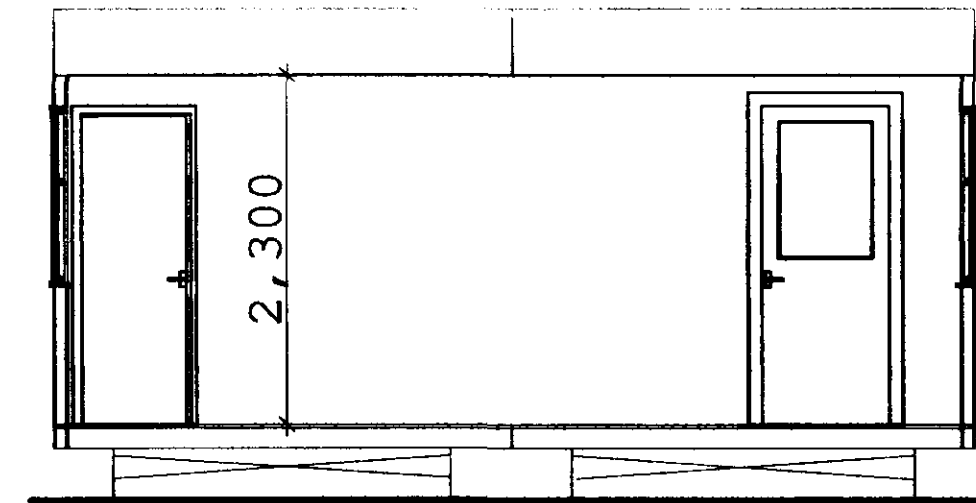

Section

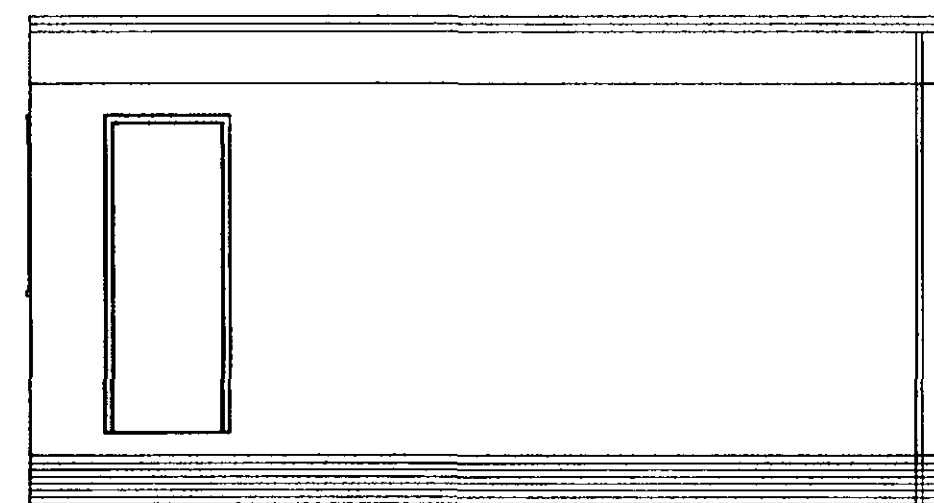

Side Elevation


- AL-Automatic Light Sensor
- SP-Spur Point(For optional extra water heater)
- RB-Wall mounted roller board supplied by LCC
- H-Heater with guard
- PB-Pinboard
- ES-Double switched power socket(4no)
- TV-TV aerial socket
- FE-Fire extinguisher supplied by LCC
- D-Distribution board & programmer
- WH-Water heater
- VB-Vertical blinds to all classroom windows
- FT-Frost stat
- TH-Tubular heater at high level
- T-Room stat
- HD-Hand Dryer

BASE UNIT HEIGHTS


- Infants-700mm
- Junior-775mm
- Secondary-850mm

CLOAKROOM FIXTURE HEIGHTS

- | | Infant | Junior | Secondary |
|-------|--------|--------|-----------|
| Seat | 290mm | 340mm | 390mm |
| Pegs | 1090mm | 1250mm | 1540mm |
| Shelf | 1200mm | 1380mm | 1690mm |

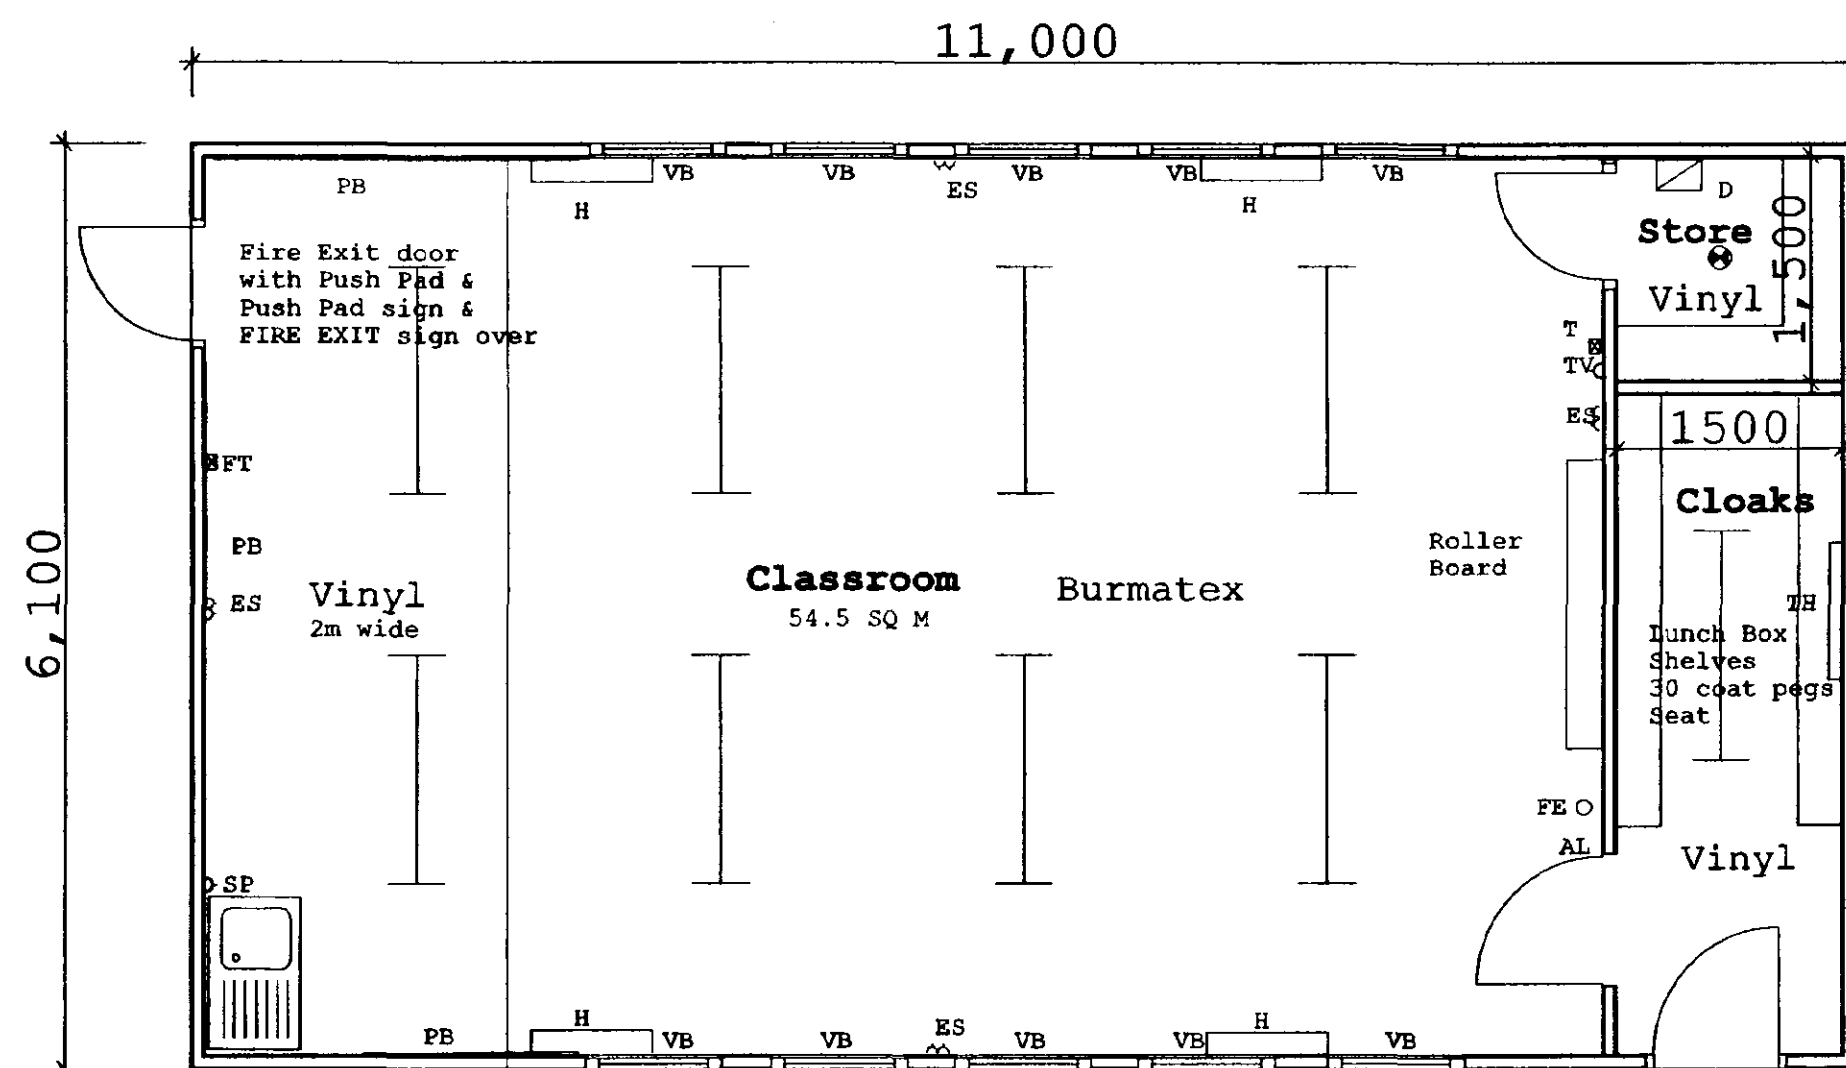

Plan Type A
Type B as Type A but handed

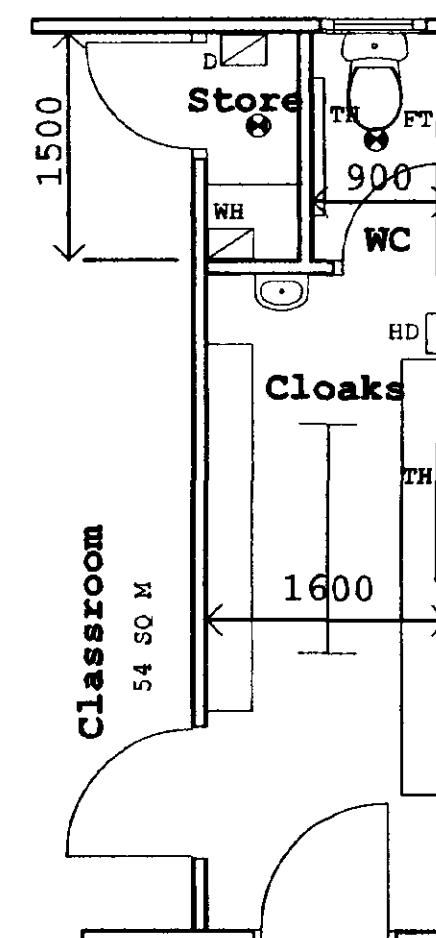

Plan Type C as Type A but with
a toilet and smaller store
Type D as Type C but handed

- Painted plywood fascia
- Black PVCu gutters
- PVCu double glazed windows
- Plywood cladding with a green textured finish
- Slatted stained skirting

SOUTH HOLLAND DC
HOUSING & PLANNING
22 JUN 2000
Ref: 788/00

**RELOCATABLE
CLASSROOM UNIT**

**STANDARD SINGLE
CLASSROOM UNIT**
PROPERTY DIVISION

County Offices, Newland
Lincoln LN1 1ZA
Telephone 01522 552701 fax 01522 552611

drawing no. **PD/S/1** revision

scale **1:50** date **January 2000**



LINCOLNSHIRE COUNTY COUNCIL
Finance & Resources Directorate

L.C.C.
20 JUN 2000
HIGHWAYS & PLANNING
DIRECTORATE