



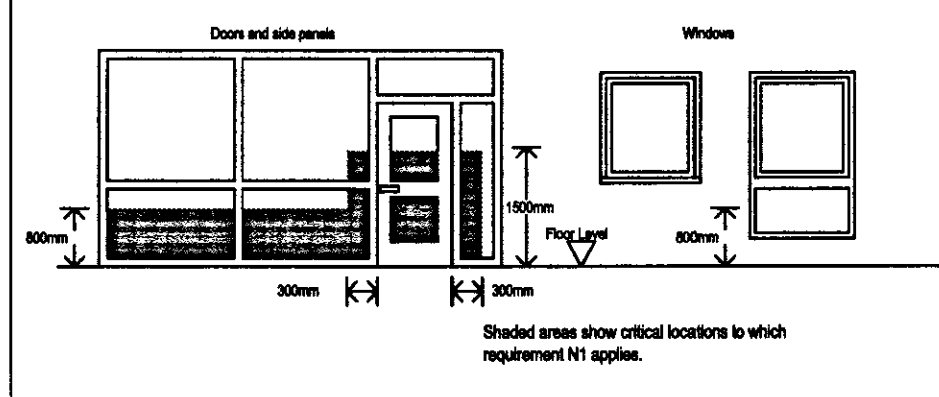



Contractor to check all Dimensions on site prior to ordering materials / commencing work. Do Not Scale from this Drawing - If in doubt then please ask

Fire Alarm system should be designed & installed in accordance with BS 5839 Fire Detection & Alarm Systems for Buildings - Grade C - A system of fire detectors and alarm sounders (which may be combined in the form of smoke alarms) connected to a common power supply, comprising the normal mains and a standby supply, with central control equipment.

Installation and commissioning certificates will be required for the emergency lighting, fire alarm, and detection system.

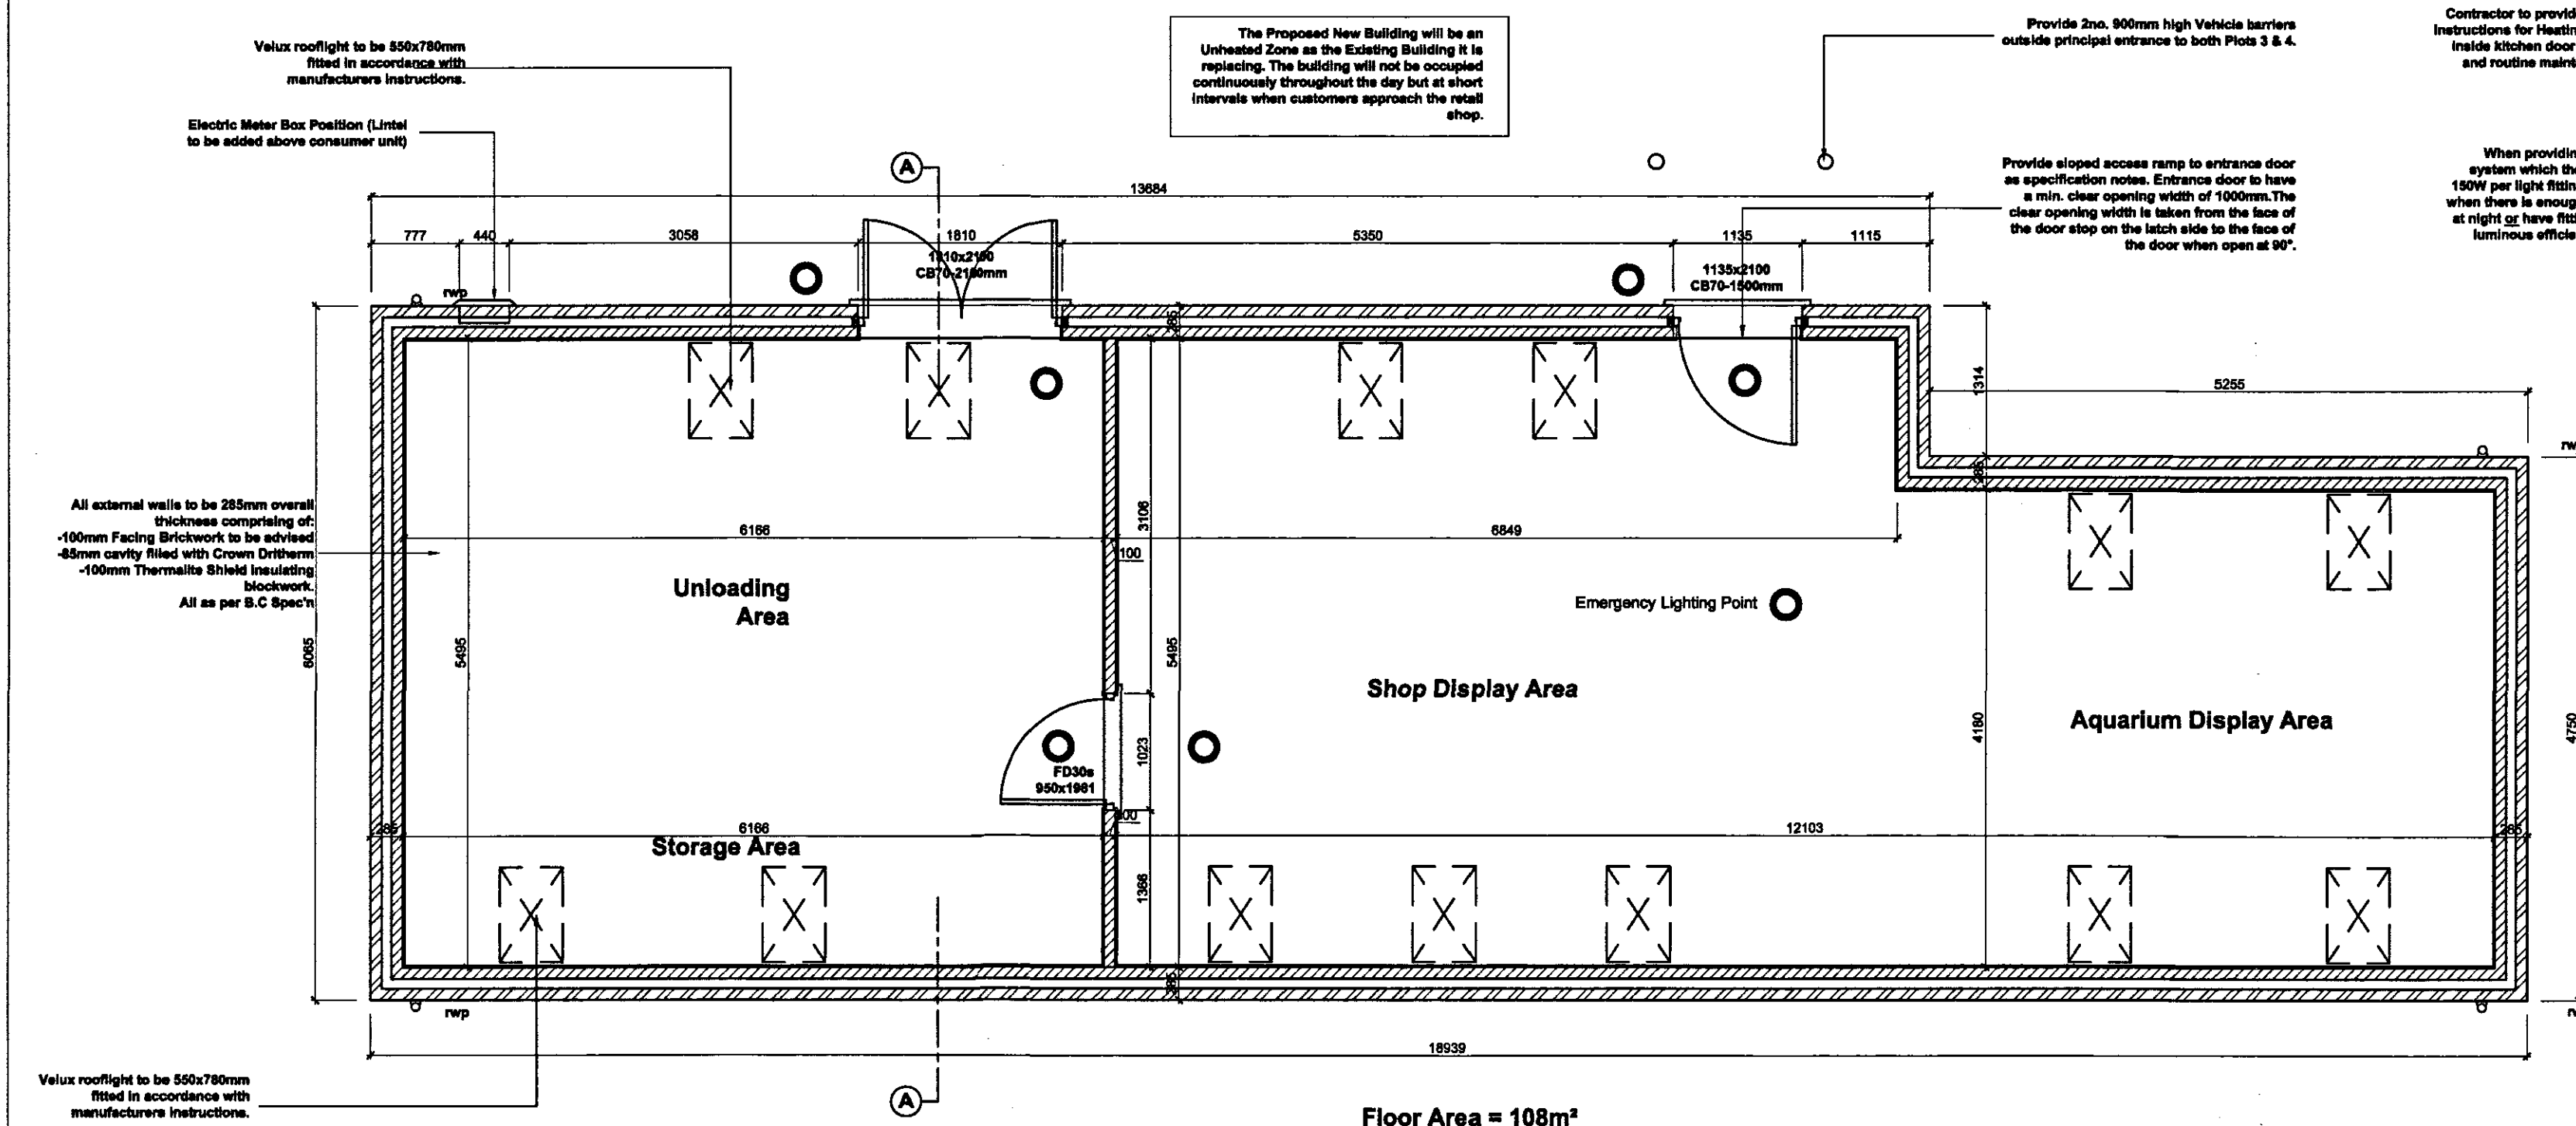

Ground Floor Plan
Scale 1:50

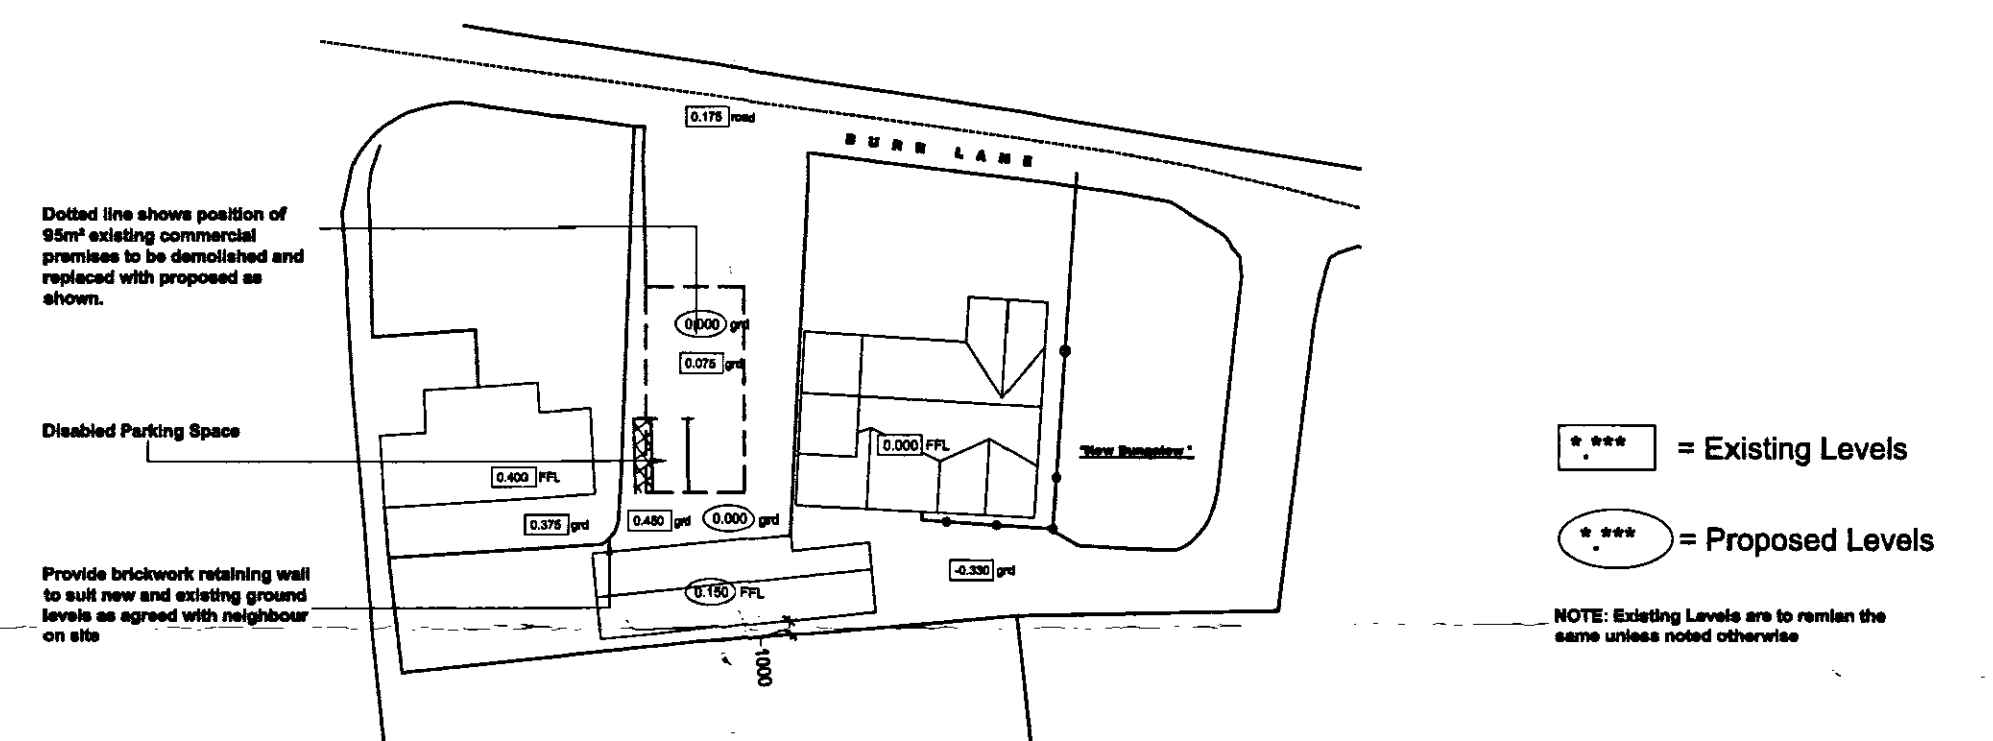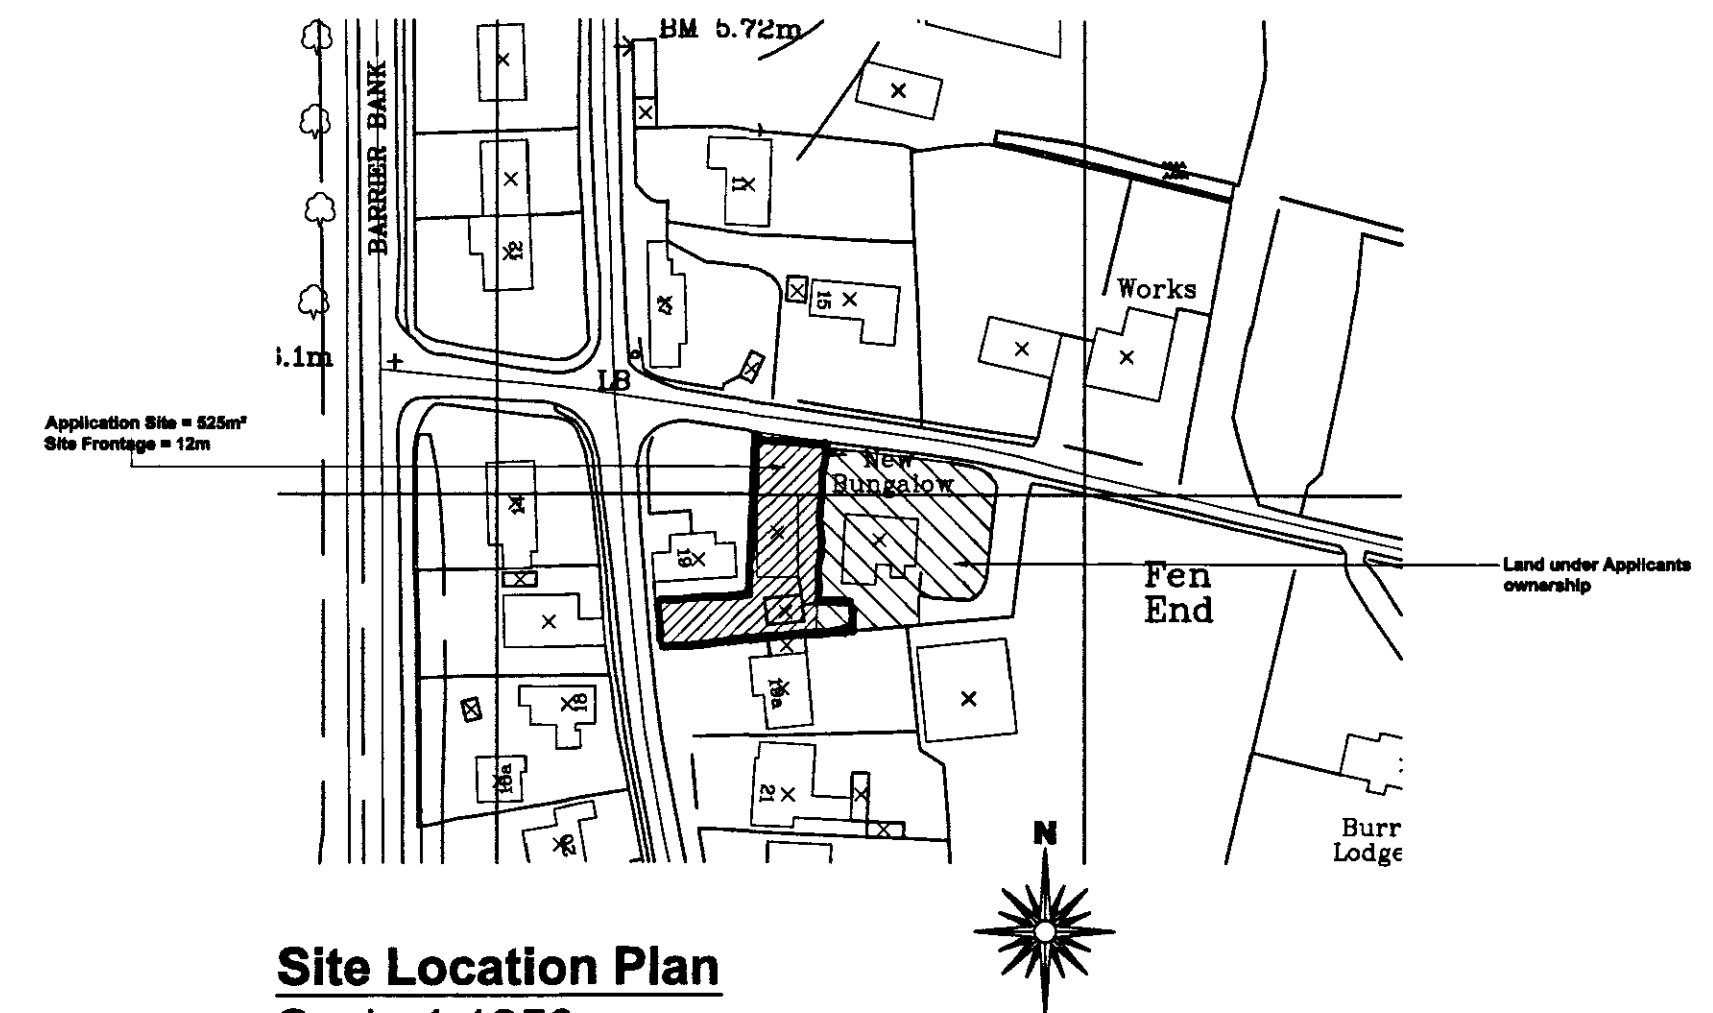

SHDC
Planning & Development
19 SEP 2008
Ref: 1612108

"D" - 18.09.08 - Building Mirrored to suit site conditions

"C" - 12.06.08 - Building Control Amendments

"B" - 08.05.08 - Building Control Specification added

rev "A" - 14.11.07 - Amended to suit Clients comments

Client:
Mr J Wilson
Tidwell Tackle
Burr Lane
Spalding
PE12 6AZ

Site:
Proposed Replacement
Commercial Premises

remway
Design Ltd
2nd Floor - 58 Sheepmarket
Spalding
PE11 1BH
Tel: 01775 768 921
e-mail: enquiries@remwaydesign.co.uk

Date: Oct07 Scale: As Noted

Drawing No:
1400 - 01 "D"

DETERMINED
PLAN

