




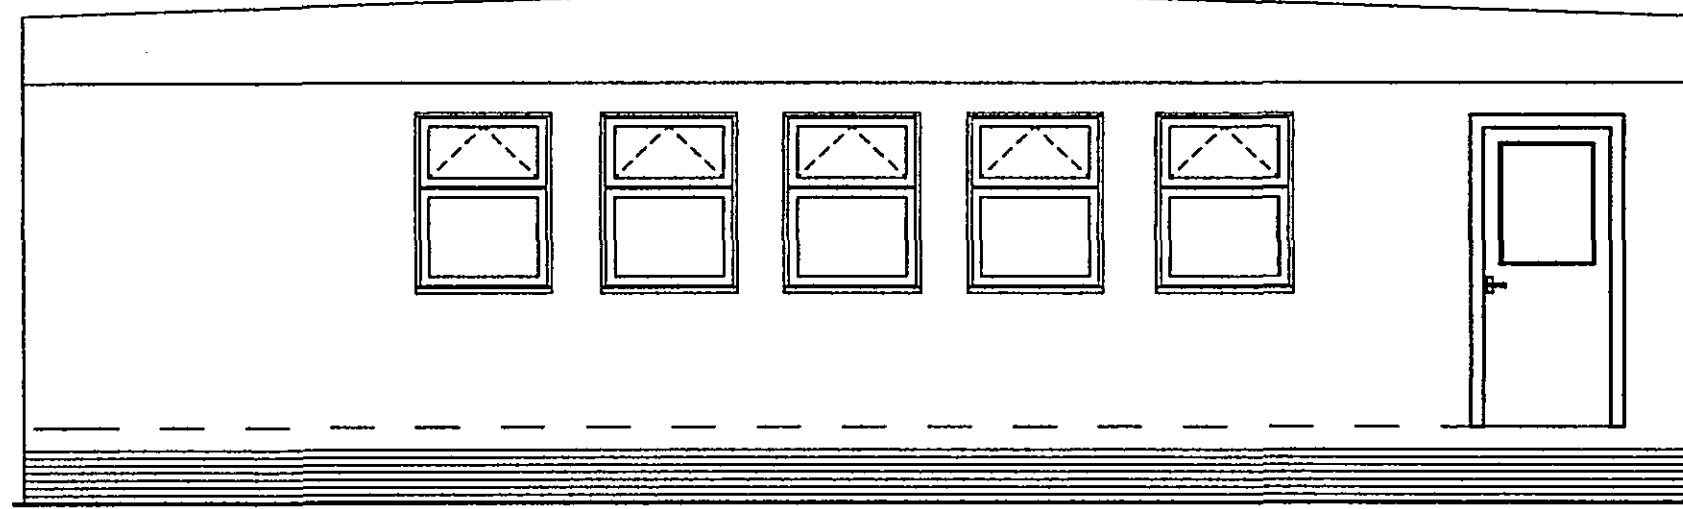


Front Elevation

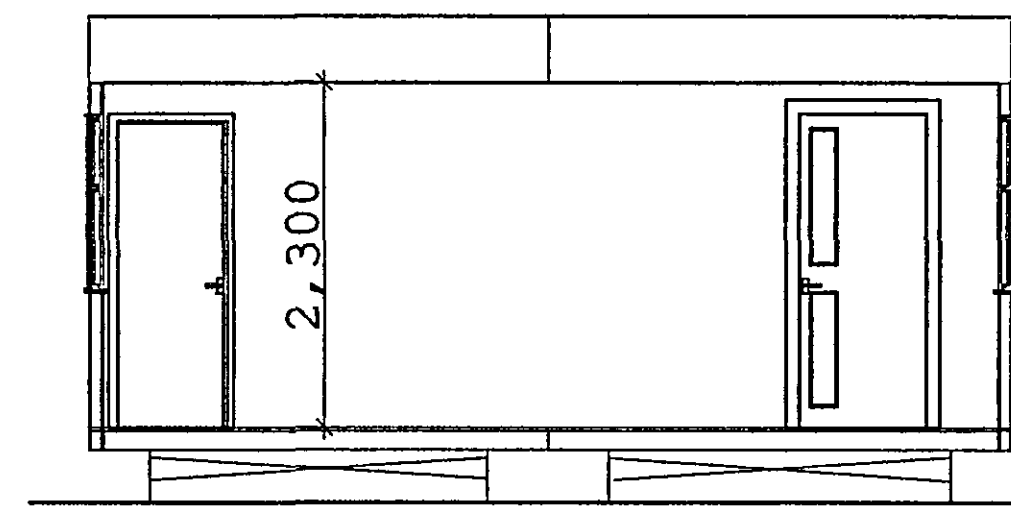

Section

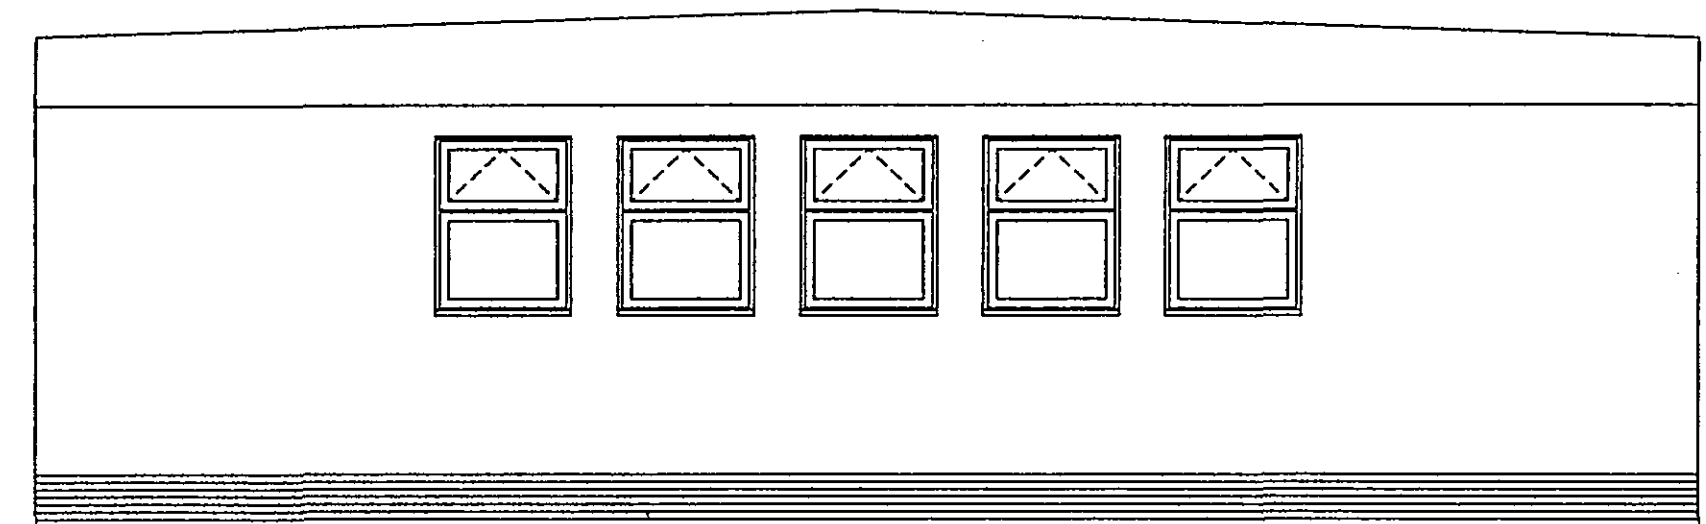

Rear Elevation

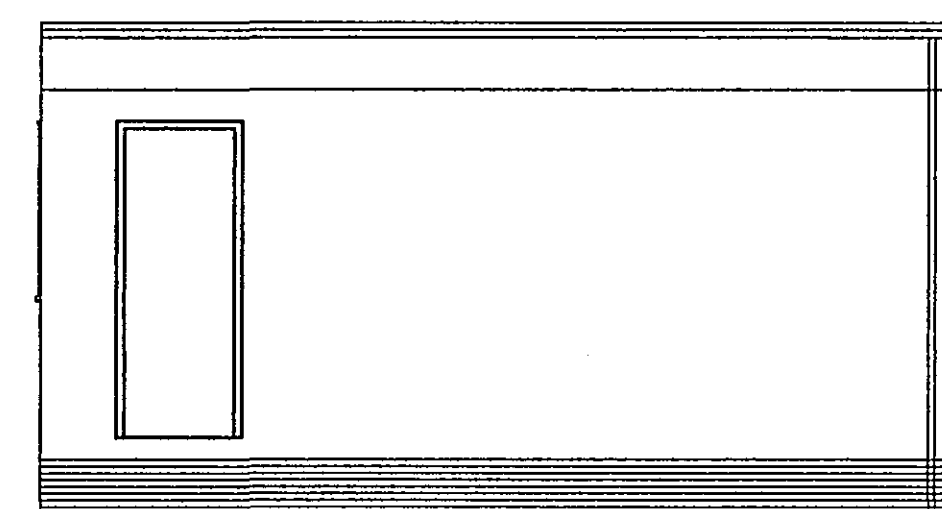

Side Elevation


Highways & Planning
 Directorate
 - 0 JUL 2004
 Planning & Conservation

All Dimensions and Levels to be verified on site.
 Only Figured Dimensions to be used.
 Do not scale this drawing.
 Any discrepancies to be notified to the originator of this drawing immediately.
 If in doubt, ask.
 Copyright is reserved by them and the drawing is issued on the condition that it is not copied, reproduced, retained, or disclosed to any unauthorised person, either wholly or in part without consent.


- AL-Automatic Light Sensor
- SP-Spur Point(For optional extra water heater)
- RB-Wall mounted roller or fixed white board
- H-Heater with guard
- PB-Pinboard
- ES-Double switched power socket(4no)
- TV-TV aerial socket
- FE-Fire extinguisher supplied by LCC
- D-Distribution board & programmer
- WH-Water heater
- VB-Vertical blinds to all classroom windows
- FT-Frost stat
- TH-Tubular heater at high level
- T-Room stat
- HD-Hand Dryer

BASE UNIT HEIGHTS
 Infants-700mm
 Junior-775mm
 Secondary-850mm

CLOAKROOM FIXTURE HEIGHTS
 Infant Junior Secondary
 Seat 290mm 340mm 390mm
 Pegs 1090mm 1250mm 1540mm
 Shelf 1200mm 1380mm 1690mm

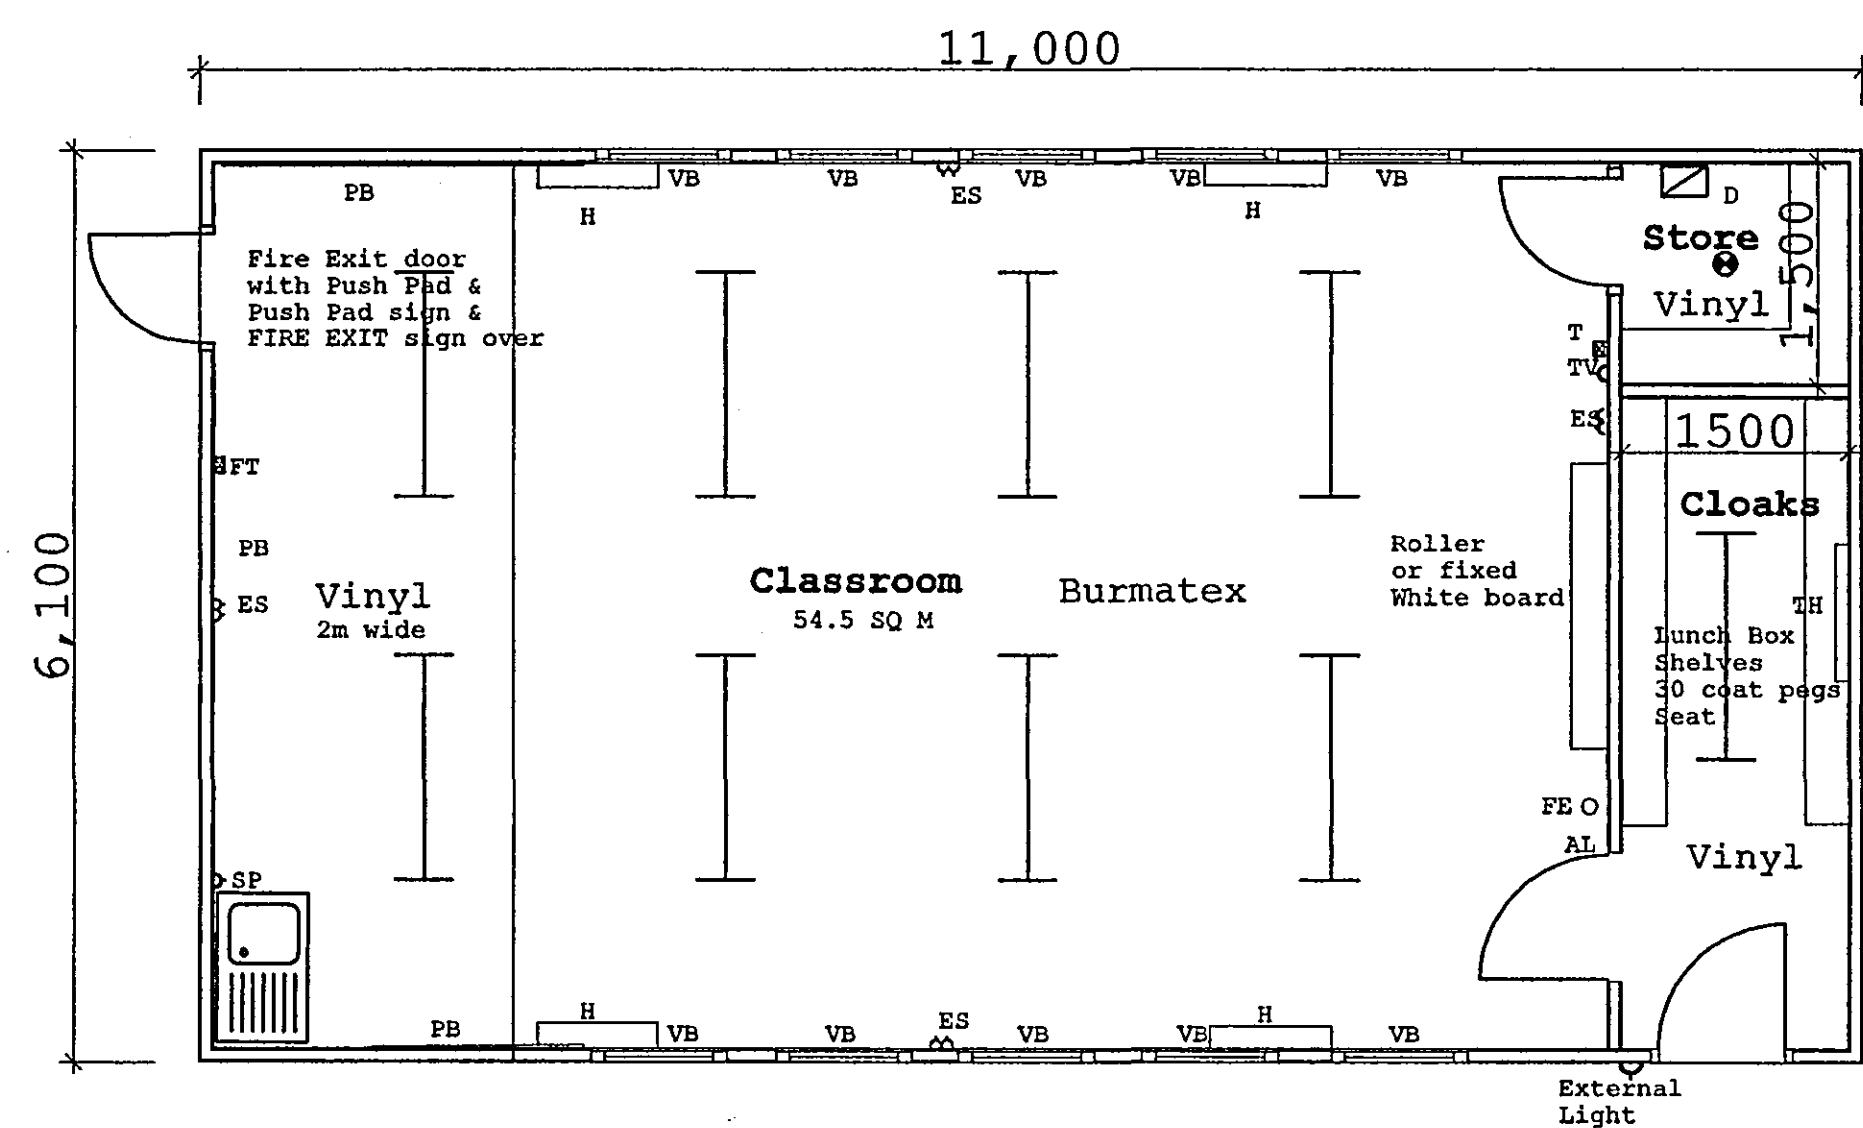

Plan Type A
 Type B as Type A but handed

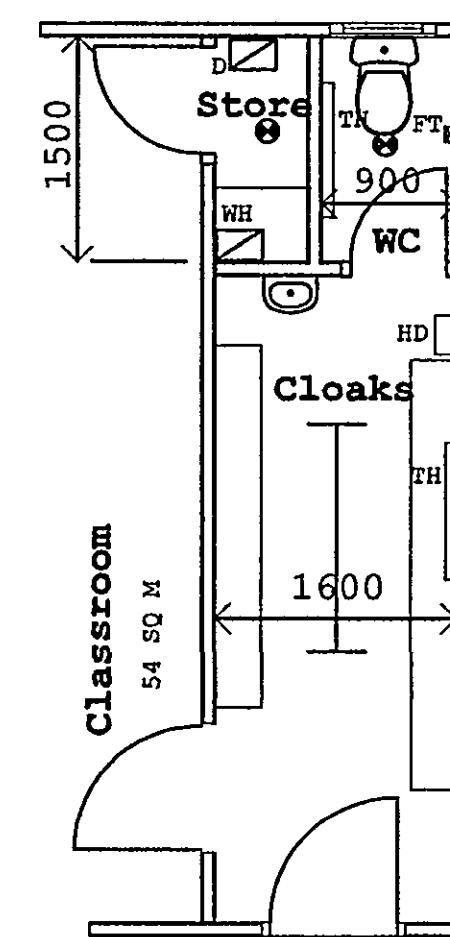

Plan Type C as Type A but with a toilet and smaller store
 Type D as Type C but handed

- Painted plywood fascia
- Black PVCu gutters
- PVCu double glazed windows
- Plywood cladding with a green textured finish
- Slatted stained skirting

SHDC
 Planning & Development
 29 JUL 2004
 Ref: 1036/04

Rev.	Date	Description	By	Chk'd

HBS
 HBS Business Services
 Mill House
 Brayford Wharf North
 Lincoln, LN1 1YT
 Tel: 01522 836836
 Fax: 01522 516050
 Web: www.hbs.uk.com

Client
Lincolnshire County Council

Project
RELOCATABLE CLASSROOM UNIT

Drawing Title
STANDARD SINGLE CLASSROOM UNIT

Drawn By **PNP** Checked By **GM**

Scale **1:50** Date **Jan 03**

Project No. Drawing No. **PD/S/1** Revision

DETERMINED
 PLAN