
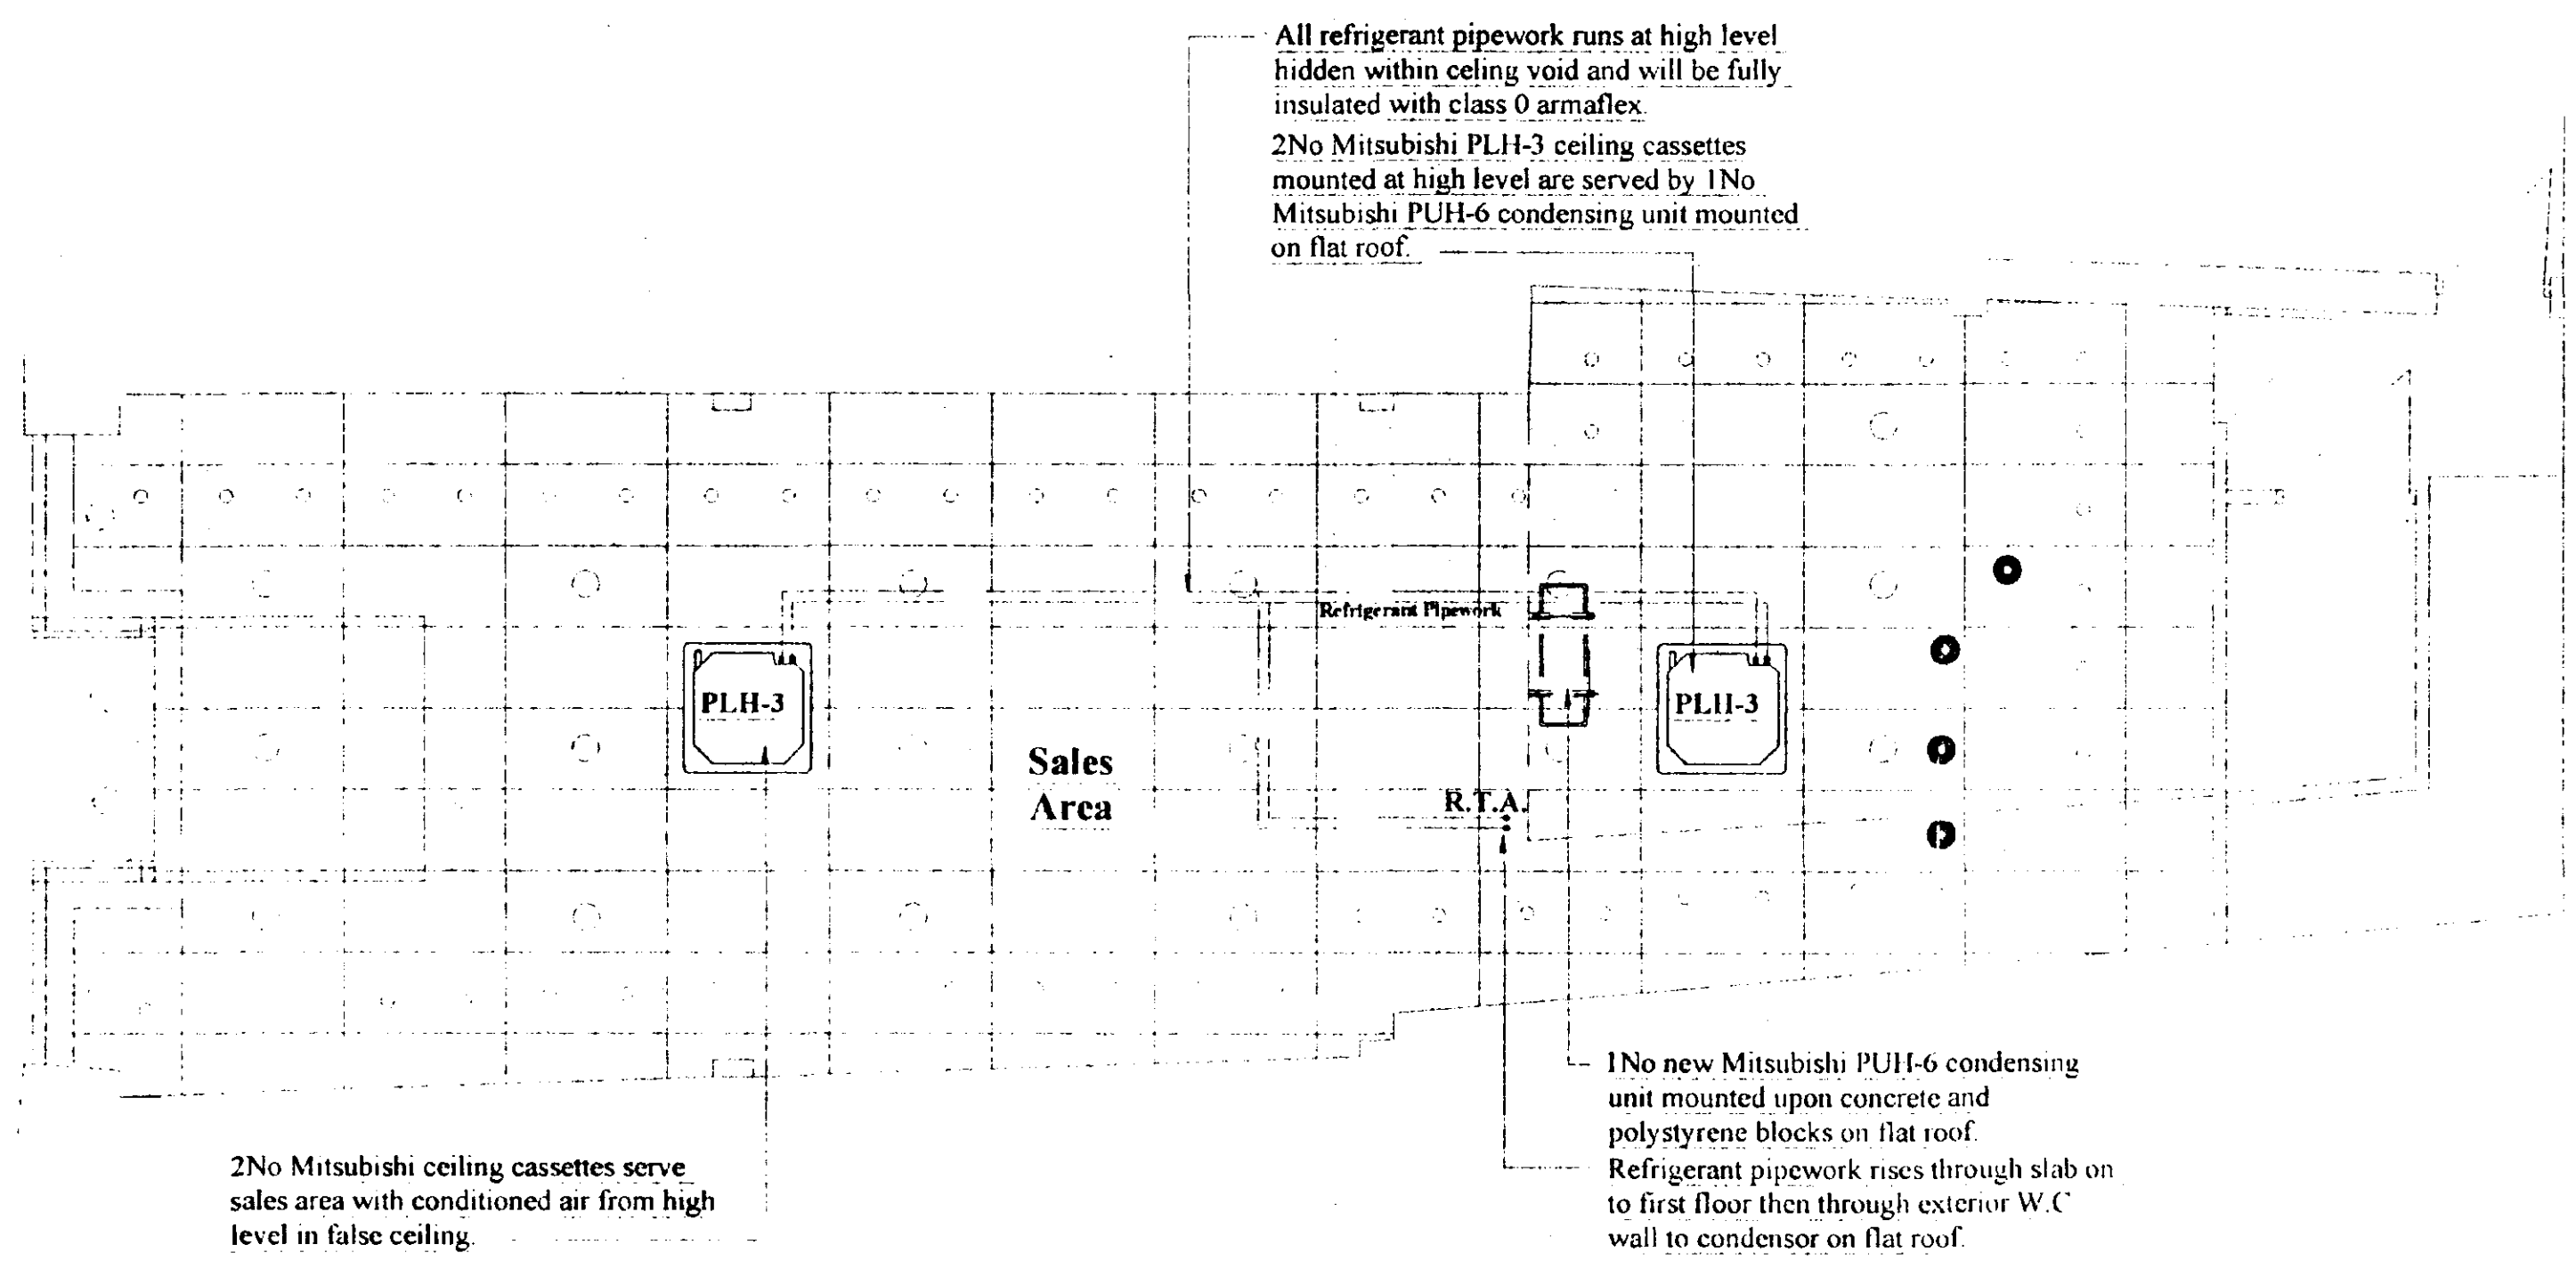


DO NOT SCALE

COPYRIGHT:

THIS DRAWING AND INFORMATION DISPLAYED IS THE CONFIDENTIAL PROPERTY OF AIR CONDITIONING DESIGN LTD. AND SHALL NOT BE COPIED OR USED FOR ANY OTHER PURPOSE WITHOUT THE WRITTEN PERMISSION OF THE COMPANY.

REV	DESCRIPTION	DATE
-----	-------------	------

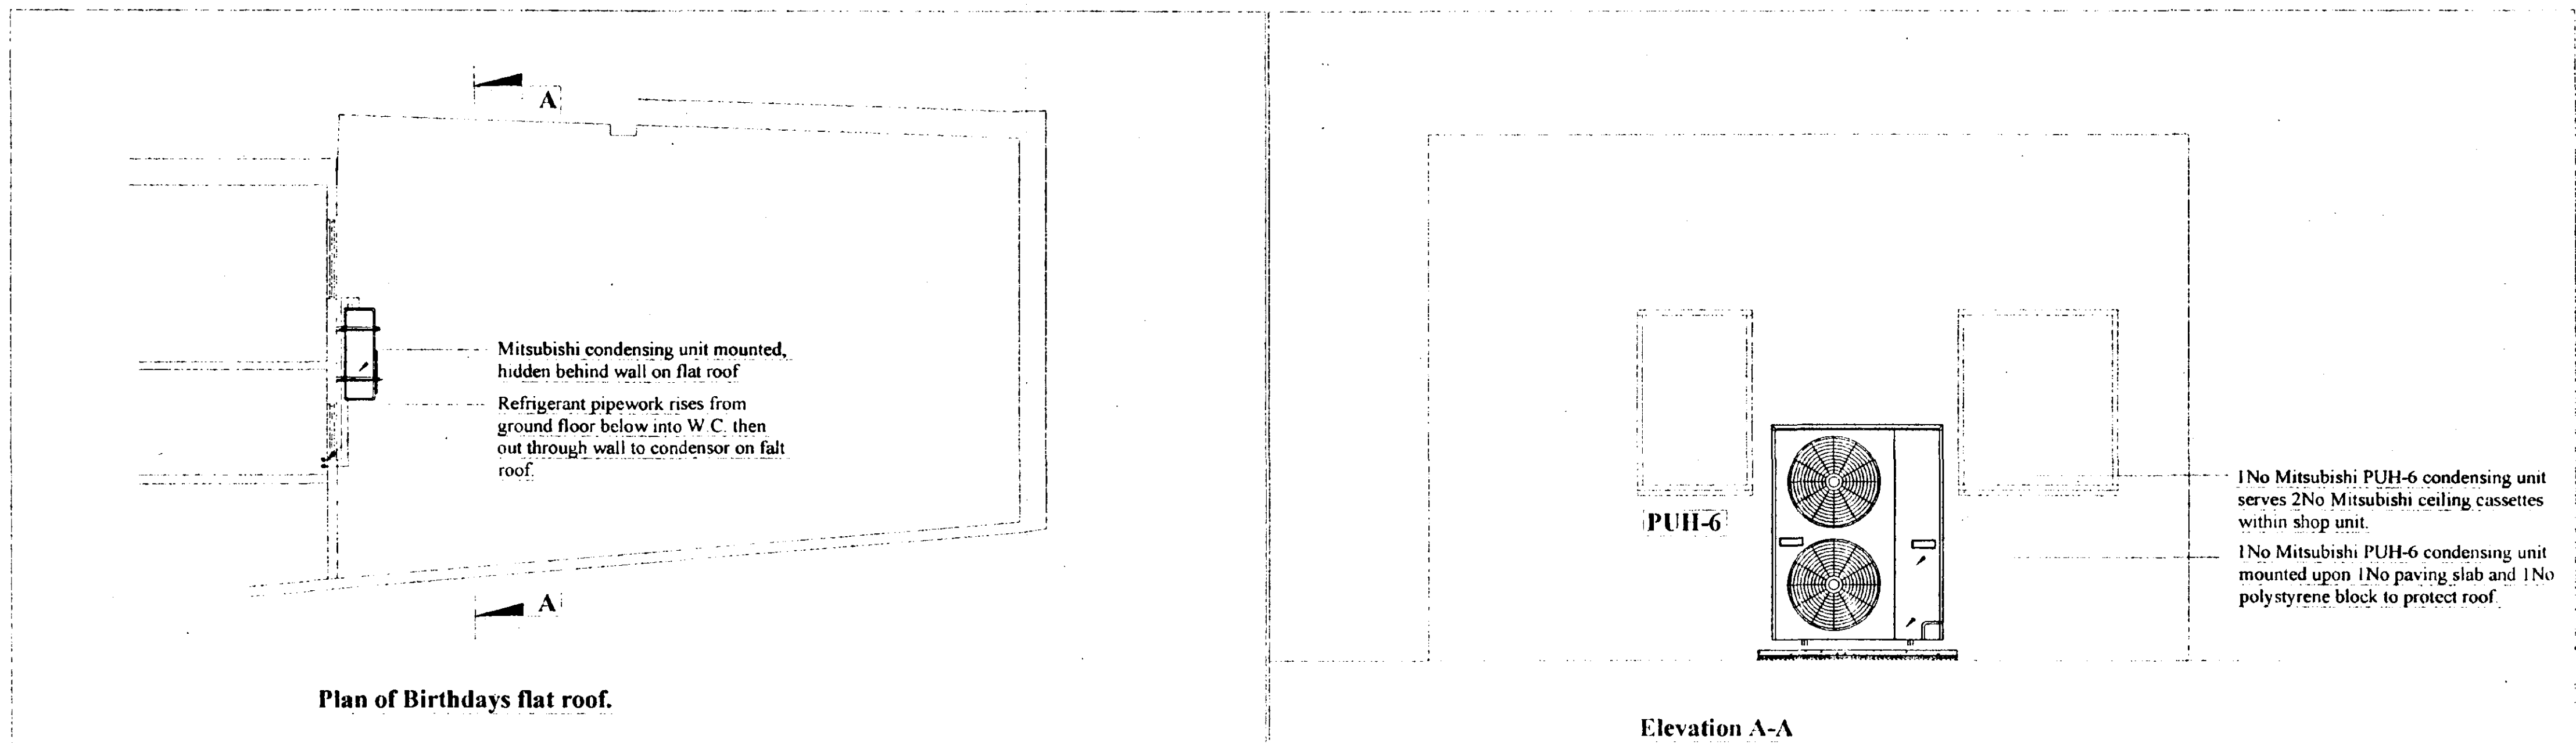

Ground Floor Plan

air conditioning
DESIGN
LIMITED

CLIENT
Birthdays.
PROJECT
**Birthdays shop.
5 Hall place,
Spalding.**

SOUTH HOLLAND DC
HOUSING & PLANNING
30 AUG 2000
Ref: 10-12/00

DRAWING TITLE
**Air conditioning to sales
area.**

DATE	SCALE
Aug 00	1:50

DRAWN BY
A.H.

DRAWING NO
E.2248

DETERMINED
F M

UNIT 6, EWOOD BRIDGE MILL
MANCHESTER ROAD
HASLINGDEN, HORSFORDDALE
LANCASHIRE BB4 6LD
TEL: (01706) 219101
FAX: (01706) 219190



NEW CONCEPT SPEC

ELECTRIC & FITTINGS KEY

- | | | | |
|---|--|---|-----------------------------------|
|  | SINGLE SOCKET |  | EMERGENCY EXIT |
|  | DOUBLE SOCKET |  | BREAK GLASS LINT |
|  | UNSWITCHED SPUR | | |
|  | 1200MM FLUORESCENT LIGHT FITTING | | |
|  | DUPLEX WALL HEATER |  | ALARM SOUNDER |
|  | MODERN CHANDLE |  | FOAM SPRAY EXTINGUISHER |
|  | SANITISER AT WATER HEATER |  | CO ₂ EXTINGUISHER |
|  | SPEAKER |  | FIRE BLANKET |
|  | 150W HALOGEN DOWNLIGHTER |  | SMOKE DETECTOR |
|  | 90W Low voltage spotlight |  | HEAT DETECTOR |
|  | 42w M Downlighter | | |
|  | 42w P Downlighter |  | VISION PANEL |
|  | INTERCOM |  | PUSH BAR PANIC BOLT |
|  | LIGHT FITTING |  | 1/25C HALF HOUR SELF CLOSING DOOR |
|  | EMERGENCY LIGHT FITTING | | |
|  | BY POINT | | |
|  | DUPLEX AC 45 CEILING FAN WITH DROUGHT HEATER | | |
|  | BELL PUSH | | |
|  | BELL | | |
|  | SWITCH | | |
|  | P / OUTLET - SWITCHED SPUR | | |
|  | MAIN BOARD | | |
|  | FIRE ALARM PANEL | | |
|  | BURGLAR ALARM PANEL | | |

CEILING

Armstrong Prima Dune
Solid Tiles
Class I surface spread of flame rating to shop
Class O surface spread of flame rating to ceiling void

WALL PANELS

Sprayed MDF panels to give Class I surface spread of flame rating Cream

LIGHT FIXTURES

50w Dichroic low voltage spotlights to perimeter
42w PI Downlighters to mains area

FIRE DOORS

All fire doors to be FD30S with smoke seals unless otherwise stated.

FLOOR COVERING

Karndean vinyl tiles Copper JB4
BARRIER MAT
3M

SOUTH HOLLAND DC
 HOUSING & PLANNING
 30 AUG 2000
 Ref: 1072/00

PLAN

1. Only the units, goods and materials which are specifically detailed and described in the specifications and which are also shown on the drawings will be accepted for sale.
2. This drawing remains at all times the sole property of Birthdays and disclosure to a third party without the prior written authority of Birthdays is prohibited and must be kept in the possession of the salesperson or any person otherwise authorised by head office.
3. The copyright of the design depicted in this drawing is the property of Birthdays and the reproduction of the whole or part of this drawing will constitute an infringement of that copyright.
4. All dimensions to be checked on site.
5. No dimensions to be scaled from this drawing.

[illegible][illegible]

BIRTHDAYS LTD A BIRTHDAY GROUP COMPANY
DUMFRIES LANE
Gt. Manchester, B19 9UR, England
Telephone: 0161-763-7353
Fax: 0161-763-7354, 0161-763-8375

SCALES	DATE
1150	17.4.00

JOB NO.	DRAWN BY
BIR 3061	PJB

CHECKED	REVISION

PROJECT
PROPOSED LAYOUT

TITLE
BIRTHDAYS

CLIENT
BIRTHDAYS LTD

SITE
S HALL PLACE

1	2	3	100
---	---	---	---	---	---	---	---	---	----	----	-----