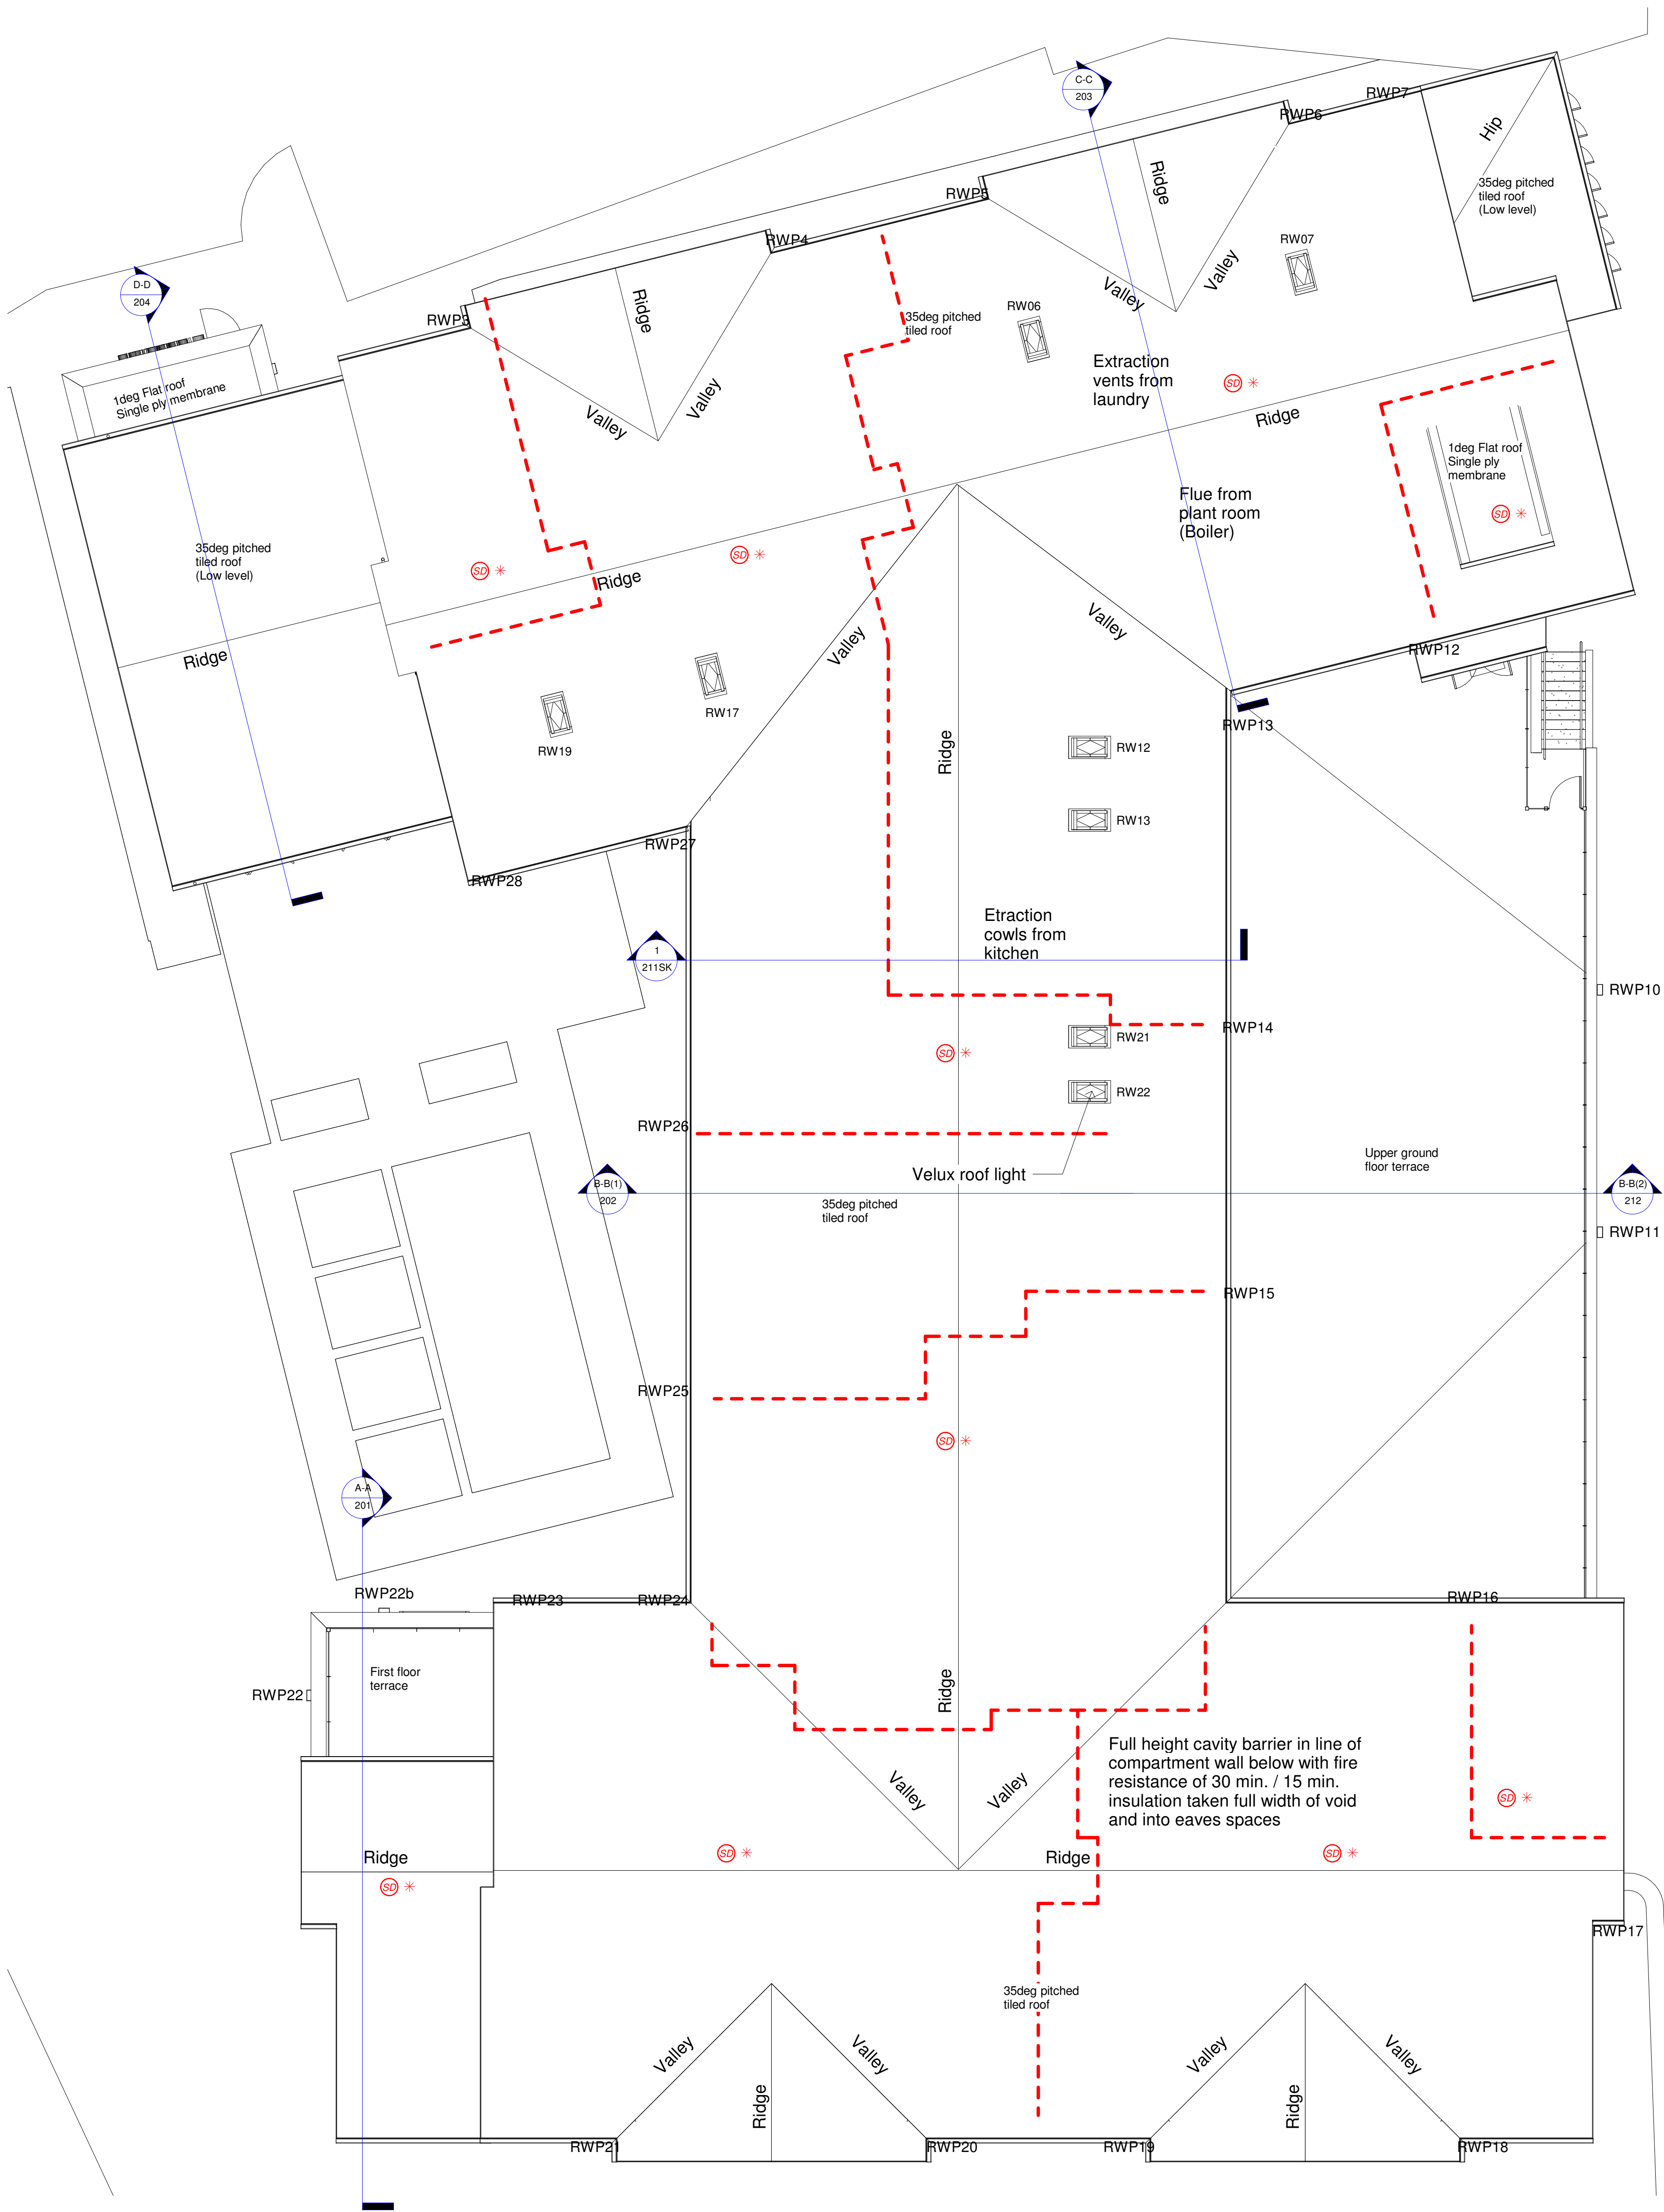


Fire installation Legend

- Fire Alarm Actuation Point
- Fire Alarm Audible Warning Device
- Automatic Heat Detector
- Automatic Smoke Detector
- Non-maintained illuminated Exit Sign
- Non-maintained illuminated Exit Sign with Direction indicator
- Dry Powder Fire Extinguisher (3 Litre)
- Foam spray Fire Extinguisher (9 Litre)
- Carbon Dioxide Fire Extinguisher (2Kg)
- Fire Blanket
- Emergency Lighting
- Emergency Lighting (External)
- Digital Keypad Locking Device
- Indicates position of push button release on opposite side
- Green 'Break Glass' emergency release
- Location of wall mounted electro-magnetic hold open unit
- Swing-free hold open closer

Rev	Date	Description	By	Chk
A	19/06/2019	Layout amended. Lift moved.	TE	JS
B	01/07/2019	Fire strategy notes added	TE	JS
C	28/01/2020	Co-ordination amendments. Roof lights omitted.	TE	JS
D	06/12/2020	Generally co-ordinated for re-issue	TE	JS

NOTES

DO NOT SCALE, USE FIGURED DIMENSIONS ONLY.

ALL DIMENSIONS TO BE VERIFIED ON SITE PRIOR TO THE COMMENCEMENT OF ANY WORK OR THE PRODUCTION OF ANY SHOP DRAWING. ALL DISCREPANCIES TO BE REPORTED TO THE ARCHITECT.

THIS DRAWING IS TO BE READ IN CONJUNCTION WITH ALL RELATED ARCHITECT'S AND ENGINEER'S DRAWINGS AND ANY OTHER RELEVANT INFORMATION.

THIS DRAWING IS © COPYRIGHT OF DWA ARCHITECTS (LONDON) LTD.

DWA Architects (London) Ltd
Cyclops House
Link Business Park
York
United Kingdom
YO10 3JB

01904 544 400
dwa@dwa-architects.co.uk
www.dwa-architects.co.uk

Client
Glenholme Senior Living (Spalding) Limited

Project
Proposed 61 Bedroom Care Home on the Former Birds PH Site

Drawing Title
Roof plan - Proposed GA and Fire Strategy

Drawing Status
CONSTRUCTION

Scale @ A1
As indicated

Date
12/14/18

Drawn By
TE

Checked By
JS

Job no.
G5105

Drawing no.
105

Rev
D

Roof plan
1 : 100

