


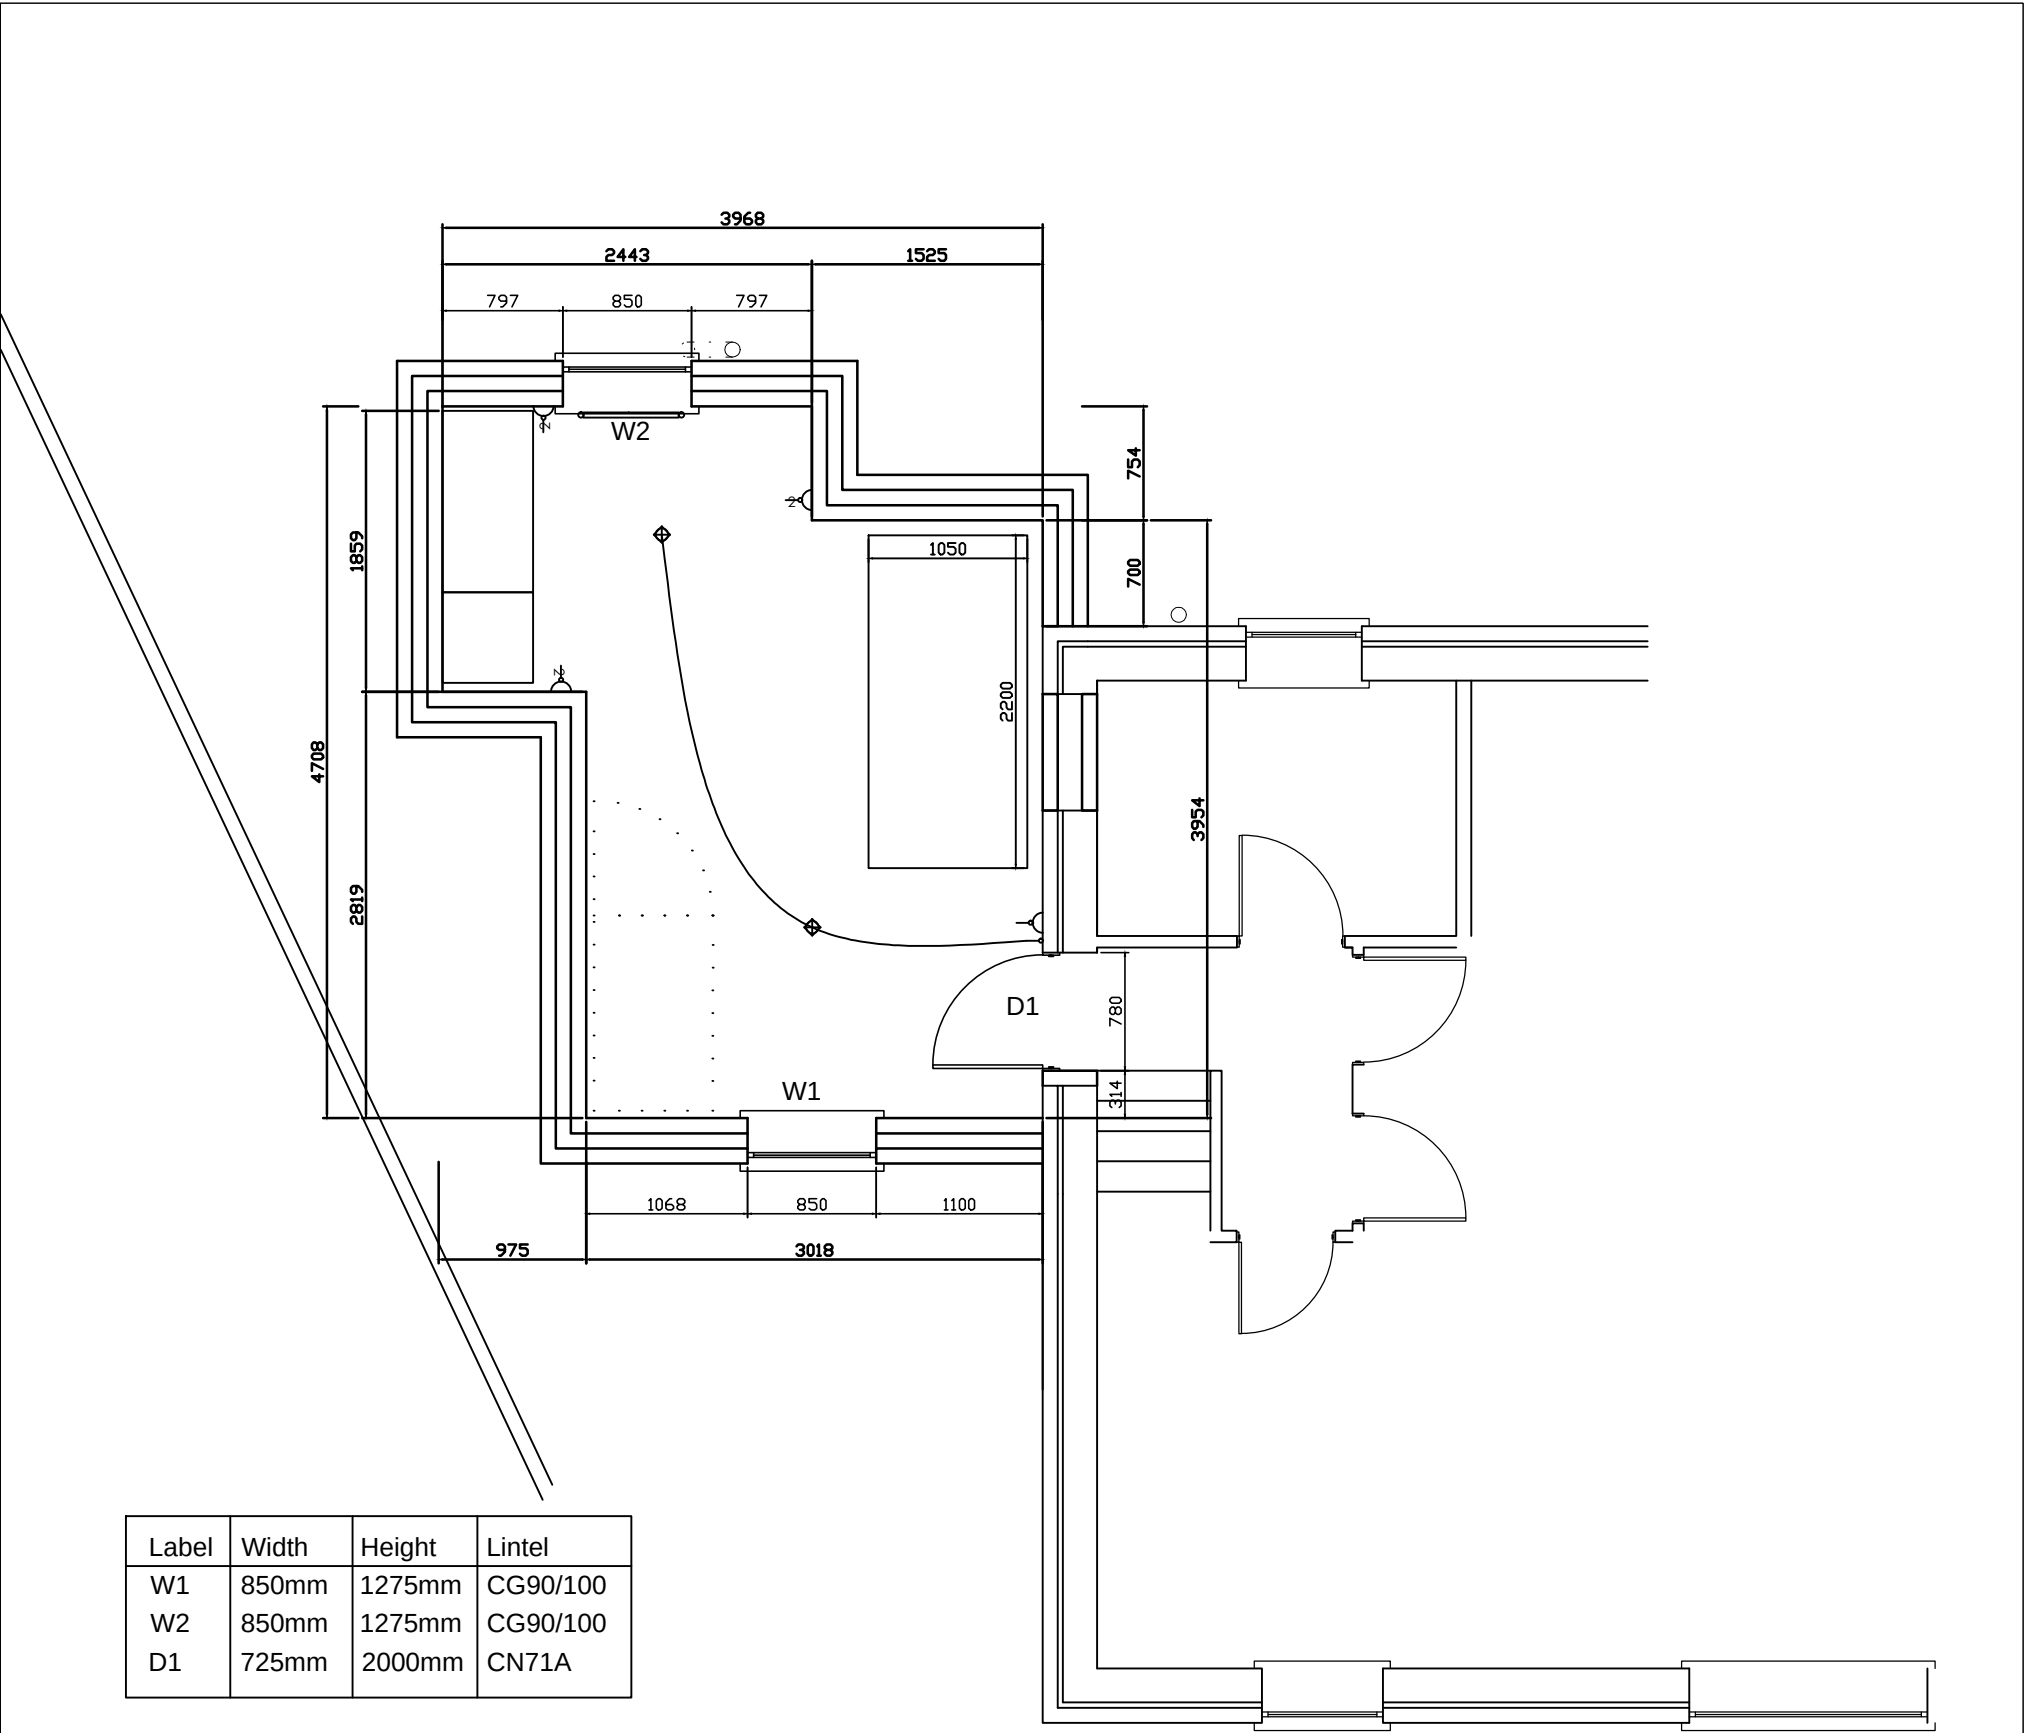

ELECTRICAL SYMBOLS KEY

- SINGLE SWITCHED WALL SOCKET
- DOUBLE SWITCHED WALL SOCKET
- 1 GANG LIGHT SWITCH
- LIGHT POINT - PENDANT HOLDER (4 INCH)

Rev A - SG - 04.12.15 - Electrics added.

Do Not Scale From This Drawing
This drawing is copyright and may not be altered , traced, photographed or copied without prior written consent from South Holland Building Consultancy.
The contractor should check all dimensions on site prior to commencement and report any discrepancies to the Architect.



South Holland Building Consultancy
Council Offices
Priory Road
Spalding
Lincs
PE11 2XE
01775 764447

Project : Bedroom extension
Address 18 Clarence Gardens, Spalding.
Client : Master R Creamer
Scale : 1 : 50
Date : 30th June 2015
Title: Proposed First Floor Plan
Dwg No : 625/Grant/04 A Drawn : SG