




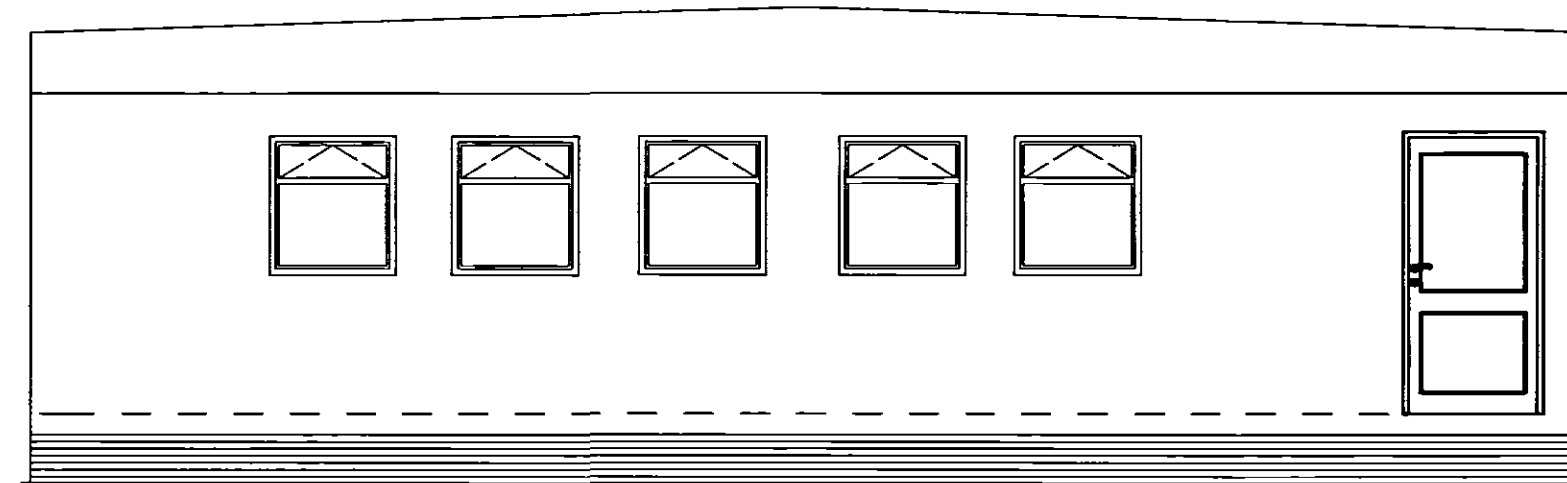


Front Elevation

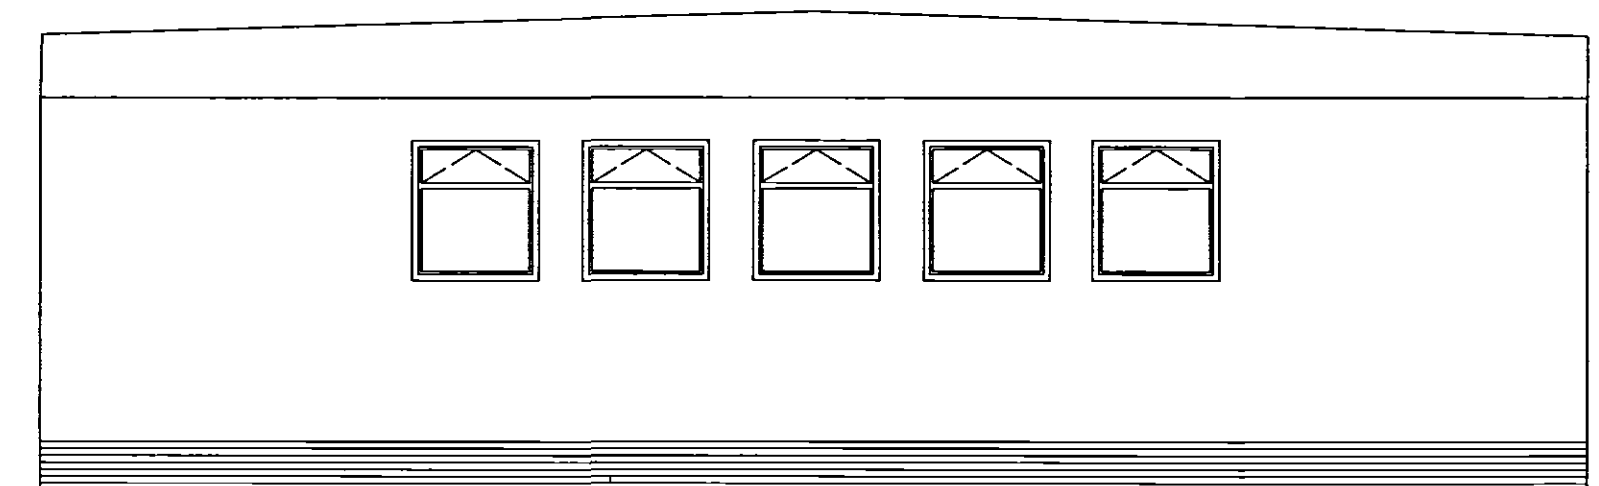

Rear Elevation

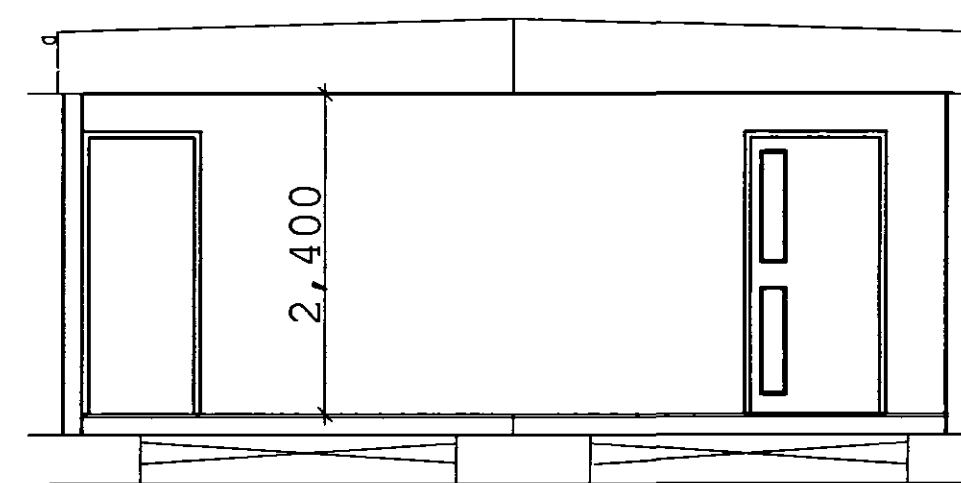

Section

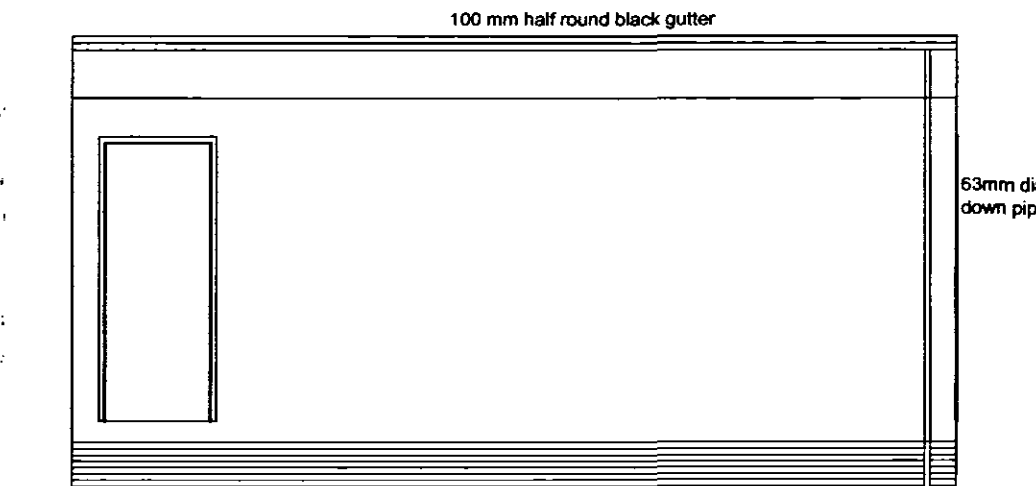


End Elevation

All Dimensions and Levels to be verified on site.
Only Figured Dimensions to be used.
Do not scale this drawing.
Any discrepancies to be notified to the originator of this drawing immediately.
If in doubt, ask.
Copyright is reserved by them and the drawing is issued on the condition that it is not copied, reproduced, retained, or disclosed to any unauthorised person, either wholly or in part without consent.

AL-Automatic Light Sensor
SP-Spur Point(For optional extra water heater)
RB-Wall mounted roller or fixed white board
H-Heater with guard
PB-Pinboard
ES-Double switched power socket(4no)
TV-TV aerial socket
FE-Fire extinguisher supplied by LCC
D-Distribution board & programmer
WH-Water heater
VB-Vertical blinds to all classroom windows
FT-Frost stat
TH-Tubular heater at high level
T-Room stat
HD-Hand Dryer

BASE UNIT HEIGHTS
Infants-700mm
Junior-775mm
Secondary-850mm

CLOAKROOM FIXTURE HEIGHTS
Infant Junior Secondary
Seat 290mm 340mm 390mm
Pegs 1090mm 1250mm 1540mm
Shelf 1200mm 1380mm 1690mm

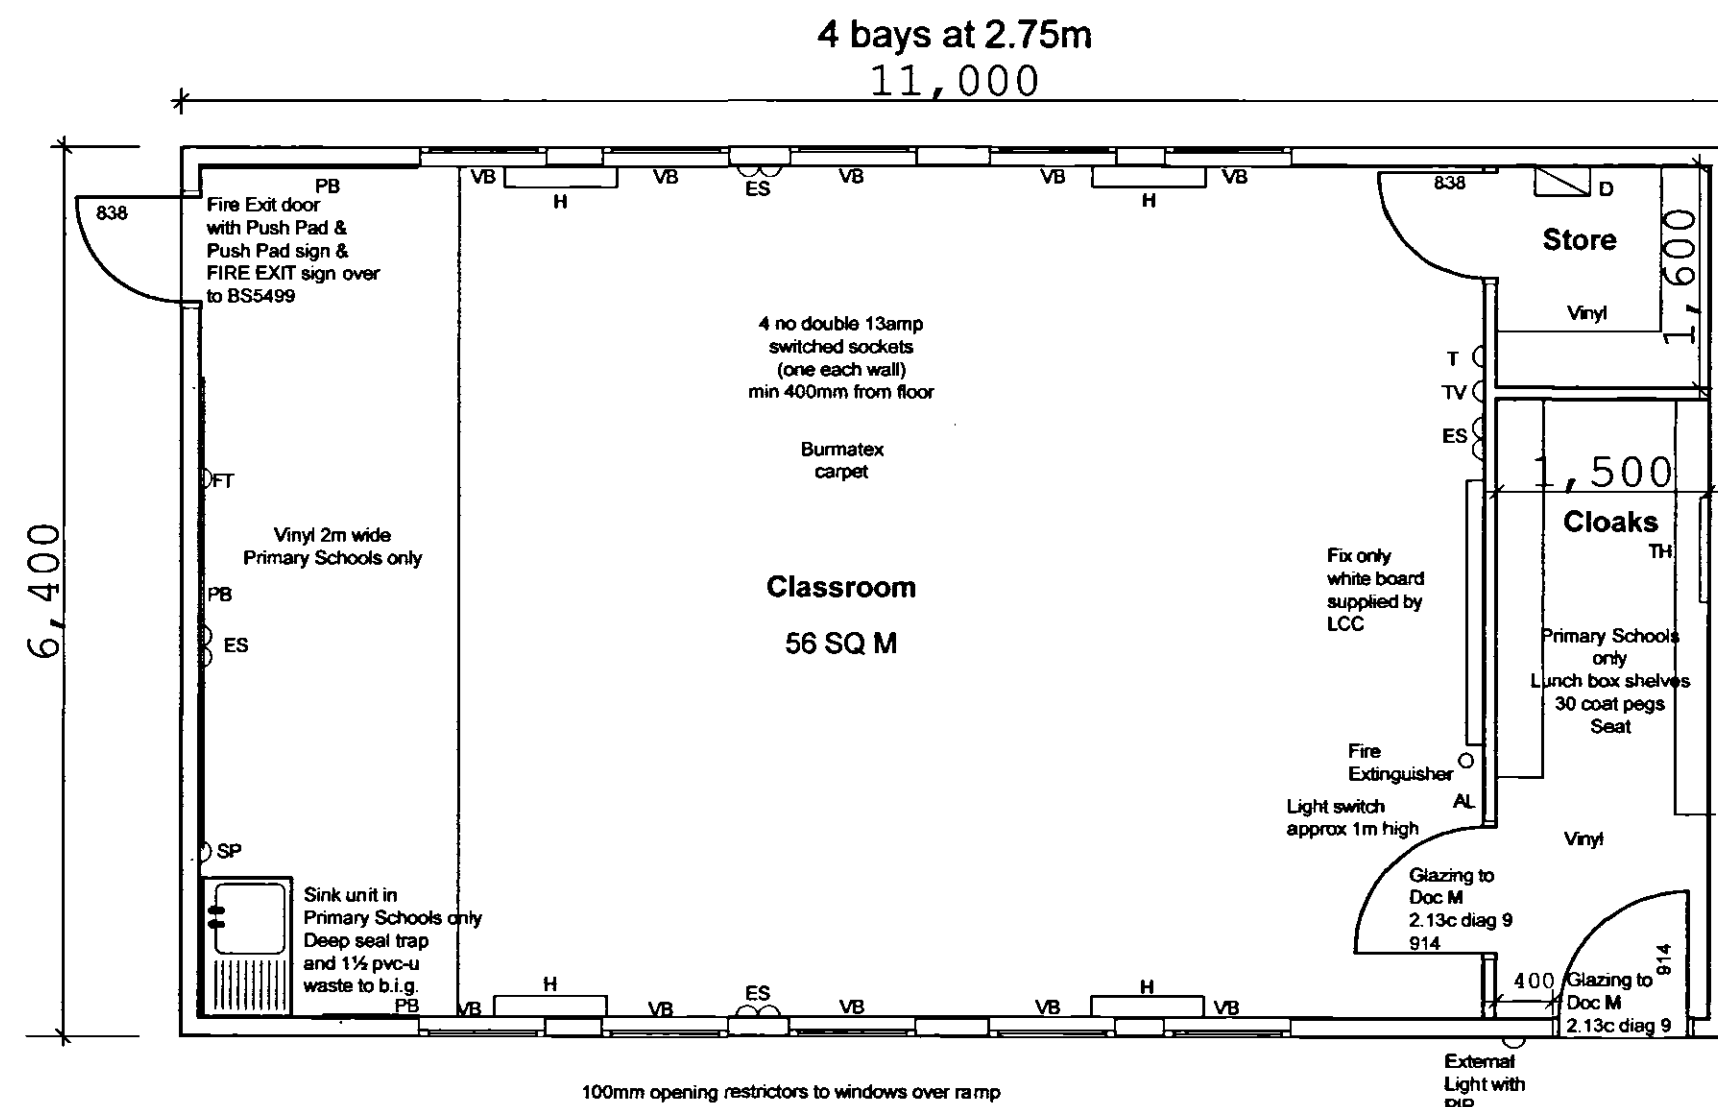

Plan - Right Hand Entry (Mirror for Left Hand Entry)

Highways & Planning Directorate
- 5 SEP 2006
Planning & Conservation

SHDC
PLANNING & DEVELOPMENT
2 7 SEP 2006
Ref. 1354106

DETERMINED
PLAN

Rev.	Date	Description	By	Chk'd
------	------	-------------	----	-------

HBS
HBS Business Services
Mill House
Brayford Wharf North
Lincoln, LN1 1YT
Tel: 01522 836836
Fax: 01522 516050
Web: www.hbs.uk.com

Client
Lincolnshire County Council

Project
Relocatable Classroom Unit

Drawing Title
Standard Single
56sq m Classroom Unit

Drawn By
PNP
Checked By
DG

Scale
1:50
Date
Sep 06

Drawing No.
PD/S/1/56
Revision

Drawing Status