


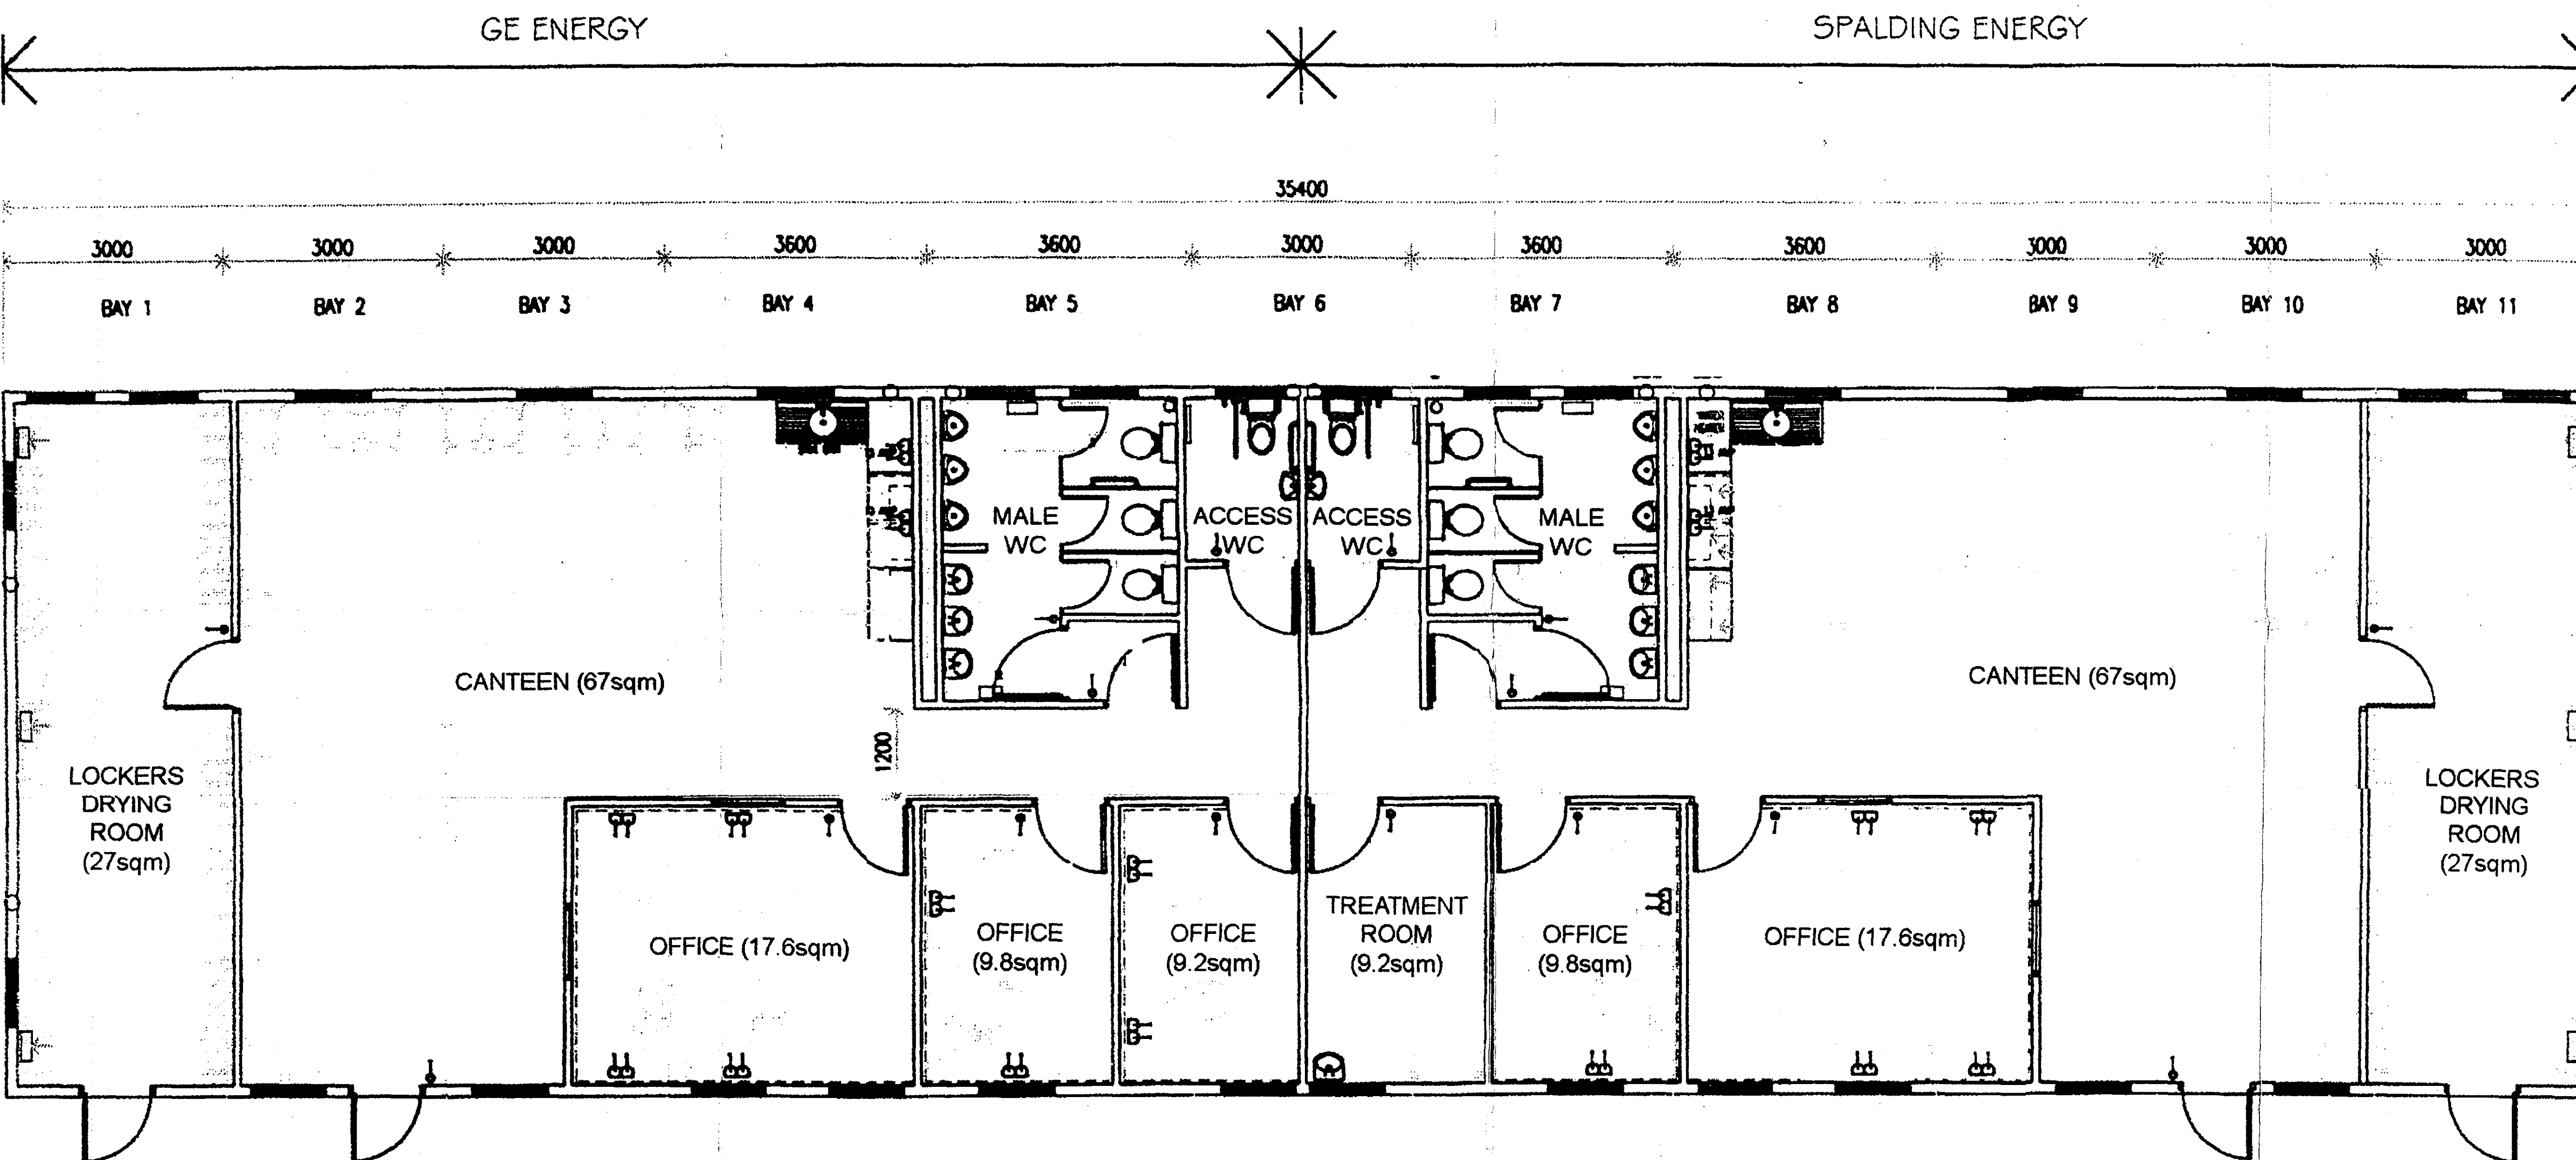

PROPOSED FLOOR PLAN

DRAWING
18 DEC 2006
ISSUED

ORIGINAL
IF
RED

GE EQUIPMENT SERVICES
MODULAR SPACE

Project
SPALDING ENERGY COMPANY
SPALDING POWER STATION

PROPOSED FLOOR PLAN

Drawn **allan watson**

Date **August 2006**

Scale **1:50**

Job No **O: AMB 02414**

Drawing No
02414 / 01

**DETERMINED
PLAN**

SHDC
PLANNING & DEVELOPMENT
22 DEC 2006
Ref. 176306