
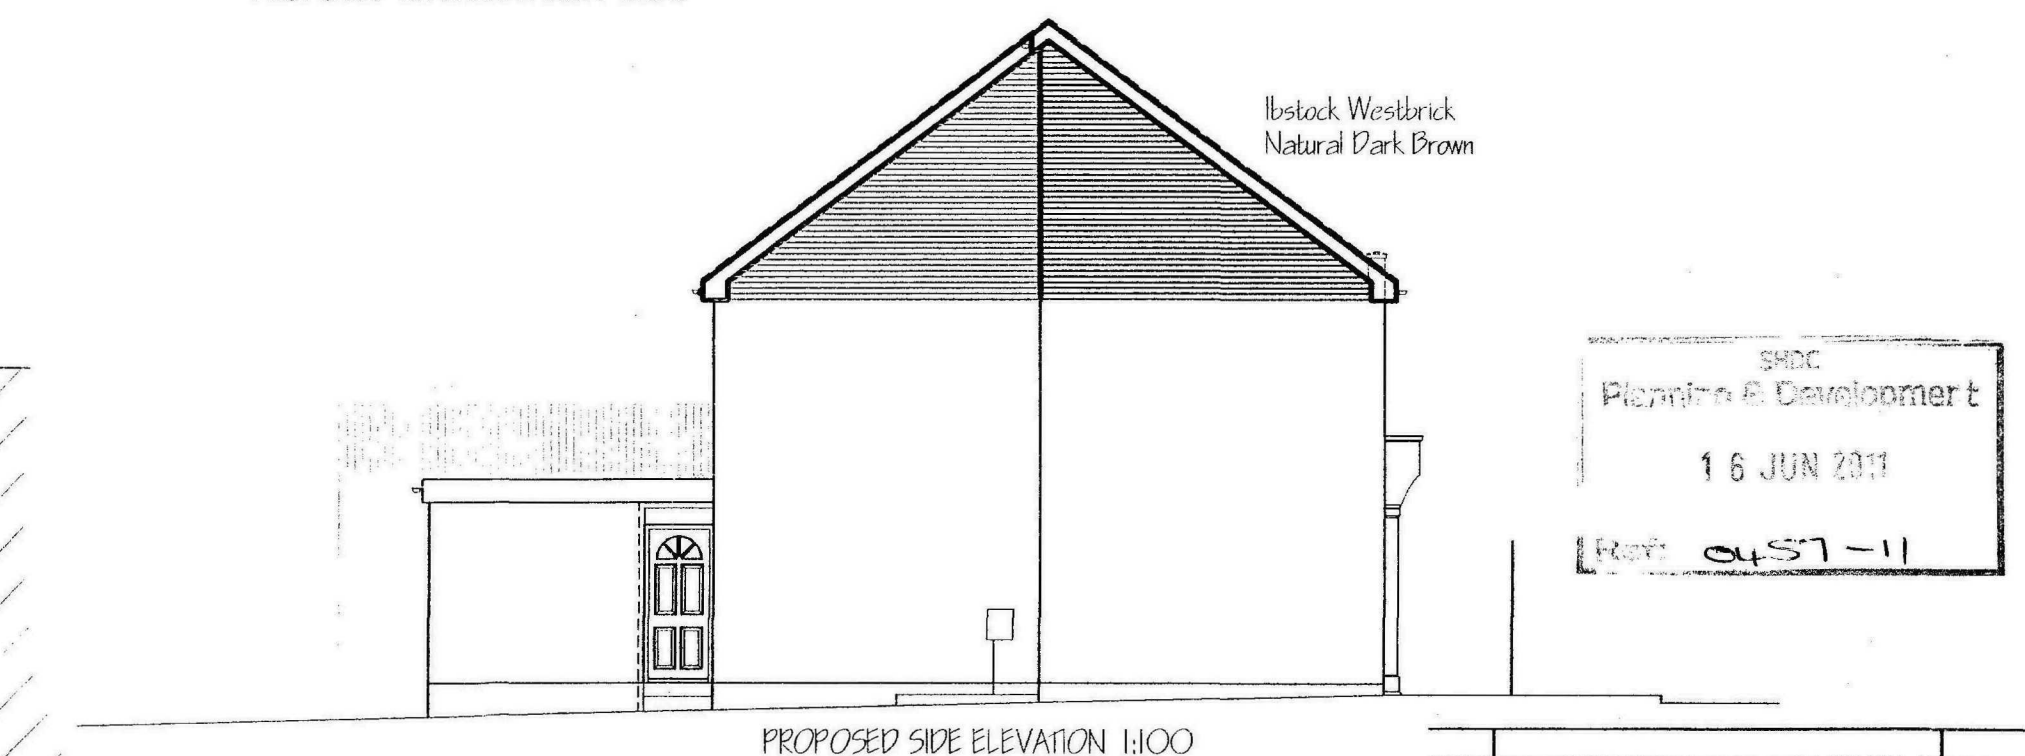
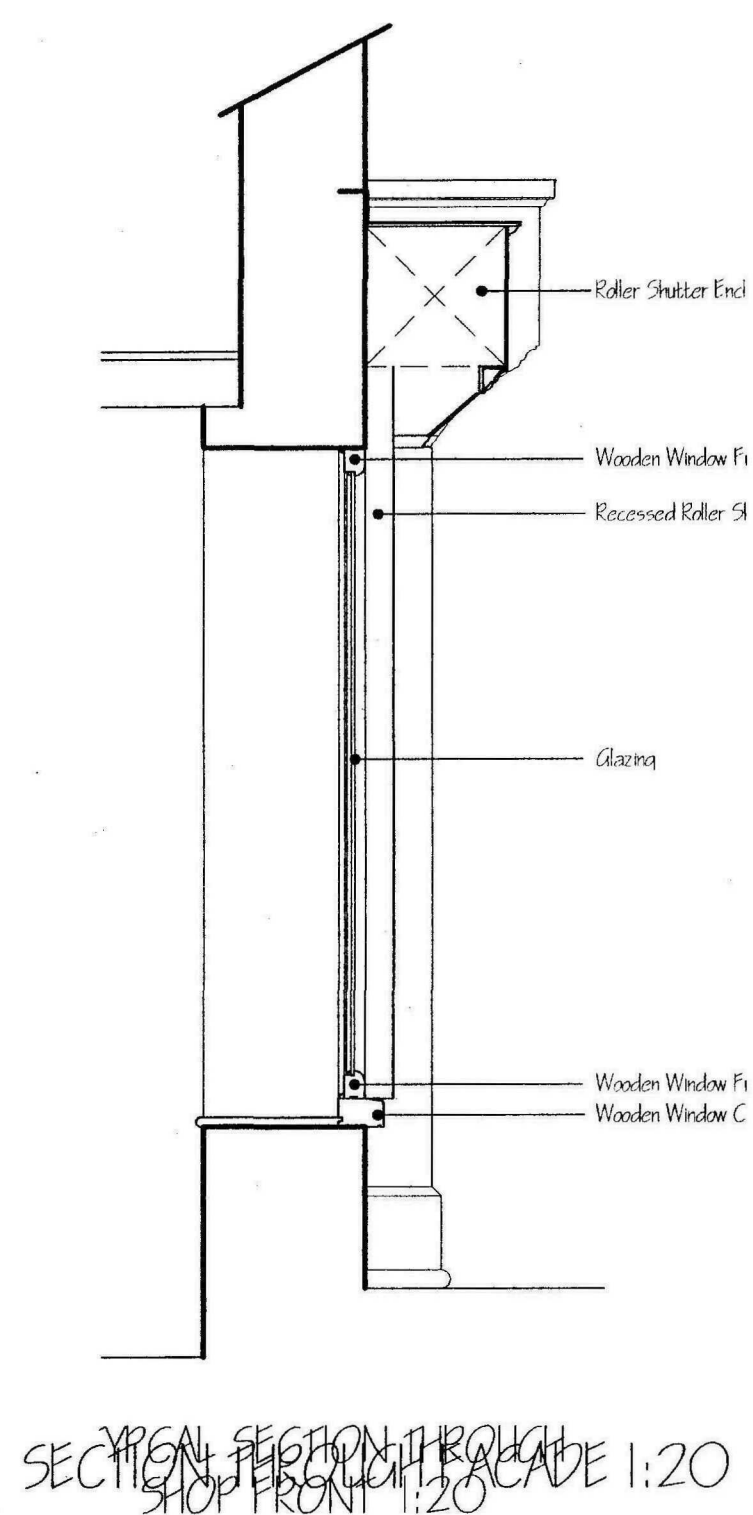


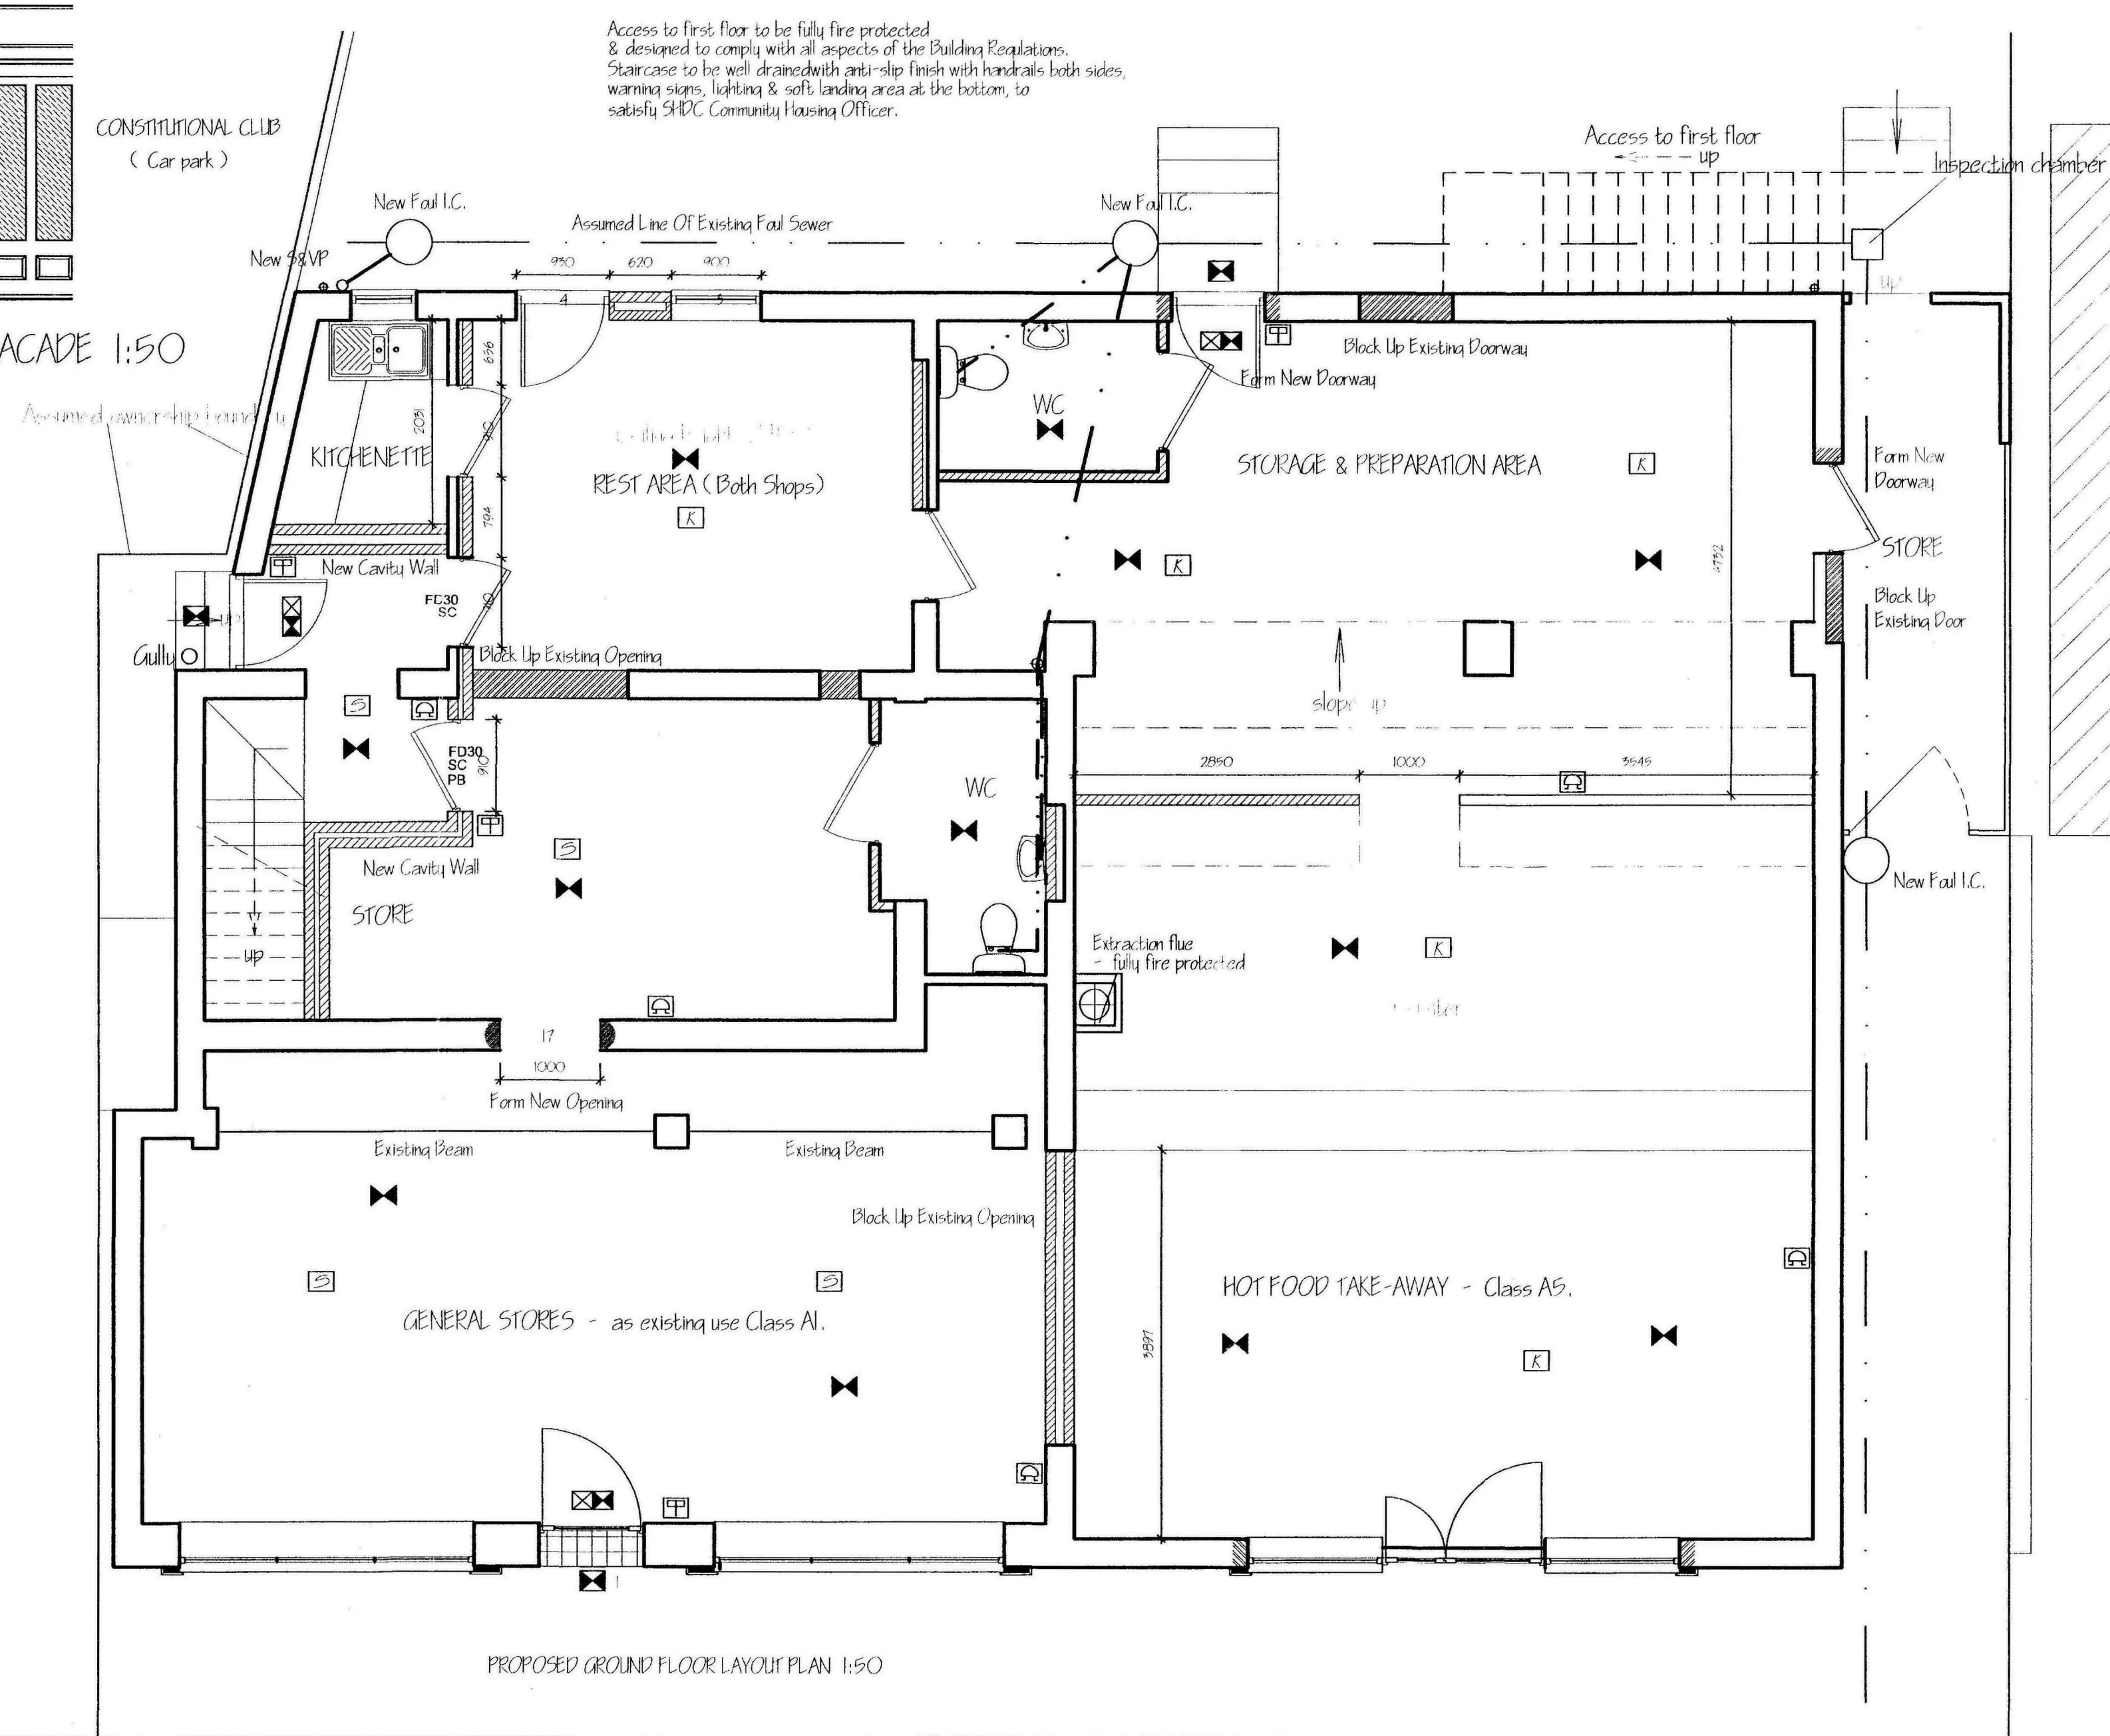

E	CONDITION COMPLIANCE DETAILS	JUNE '20
D	SIDE DOOR ADDED TO SIDE ELEVATION	MAY '20
C	PLANNING AMENDMENTS	APR '11
B	FACADE REDESIGN	MAR '20
A	CLIENT'S REDESIGN	MAR '20
ref:	revision	date

G. R. MERCHANT LTD.
I. ENG AMICE FIMO
**ARCHITECTURAL, STRUCTURAL
AND LAND DRAINAGE
CONSULTANTS**
4 Wrights Mews
12A Park Road, Weymouth, Dorset,
Spalding, Lincoln. NN12 7EE
Tel: 01406 455220
Fax: 01406 455244
E-Mail: gr.merchant@btconnect.com

Project
RENOVATION & CHANGE OF USE OF SHOP
MAIN ROAD
SUTTON BRIDGE
SPALDING LINGS.

Client G SANGHA

Drawing

PROPOSED GROUND FLOOR PLAN
PROPOSED ELEVATIONS

Job Ref.	Drawing No.
2152-10	OSE
Date	Drawn
JULY 2010	ARM/SLB

Scales
AS NOTED

DO NOT SCALE THESE DRAWINGS

DRAWING TO BE READ IN
CONJUNCTION WITH SEPARATE
SPECIFICATION

Legend to Fire Symbols:

- | | |
|---|--|
| FD30 | 1/2 Hour Fire Door to BS476 |
| FD60 | 1 Hour Fire Door to BS476 |
| F30 | 1/2 Hour Fire Resistance |
|  S12 | Notice - Fire Action |
|  S13 | Notice - Fire Door Keep Shut |
|  S14 | Notice - Fire Door Keep Locked |
|  S20 | Notice - Fire Escape Keep Clear |
|  S22 | Notice - Fire Exit |
|  S25 | Notice - Push Bar to Open |
|  S26 | Notice - Directional Arrow (Green) |
| VP | Vision Panel (Not more than 25% of the door area or less than 0.1m ²) |
| SC | Self Closing Device |
| PB | Push Bar Ironmongery |
| PP | Push Pad Ironmongery |
| RS | Roller Shutter Door |
| RR | Rapid Roll Door |
| SD | Sliding Door |
| FRG | Fire Resisting Glazing |
| FL | Fusible Link |
| MC | Magnetic Catches |
| STO | Slide To Open Signage |
| VL | Vertical Ladder |
| BG | Break Glass To Open |
|  | Control Panel Sounders |
|  | Sounders |
|  | Sounder with Flashing light |
|  | Fire Alarm Call Point - Manual |
|  | Smoke Detector |
|  | Heat Detector |
|  | Beam Detector |
|  | External Xenon Light |
|  | Fire Exit Sign Internally Illuminated |
|  | Emergency Lighting Point |
|  | Emergency Spot light |
|  | Luminaires, Emergency/Safety Emergency Lighting (locations are INDICATIVE only.) |
| | All Emergency Lighting to be installed to BS5266 Part 1 2005 |
|  | Fire Extinguisher - Water |
|  | Fire Extinguisher - Carbon Dioxide |
|  | Fire Extinguisher - Dry Powder |
|  | Fire Extinguisher - Fire Blanket |
|  | Fire Extinguisher - Aqueous Film Forming Foam |
|  | Hose Reel |
|  | Fire Alarm Indicator Panel. (Fire Detector and Alarm System to be installed in accordance with BS5839 Part 1 2002) |
- Note: All signage to be in accordance with BS 5499 2004 and Health & Safety (Safety Signs and Signals) Regulations 2002

Note: All signage to be in accordance with BS 5499 2004 and Health & Safety (Safety Signs and Signals) Regulations 2005