
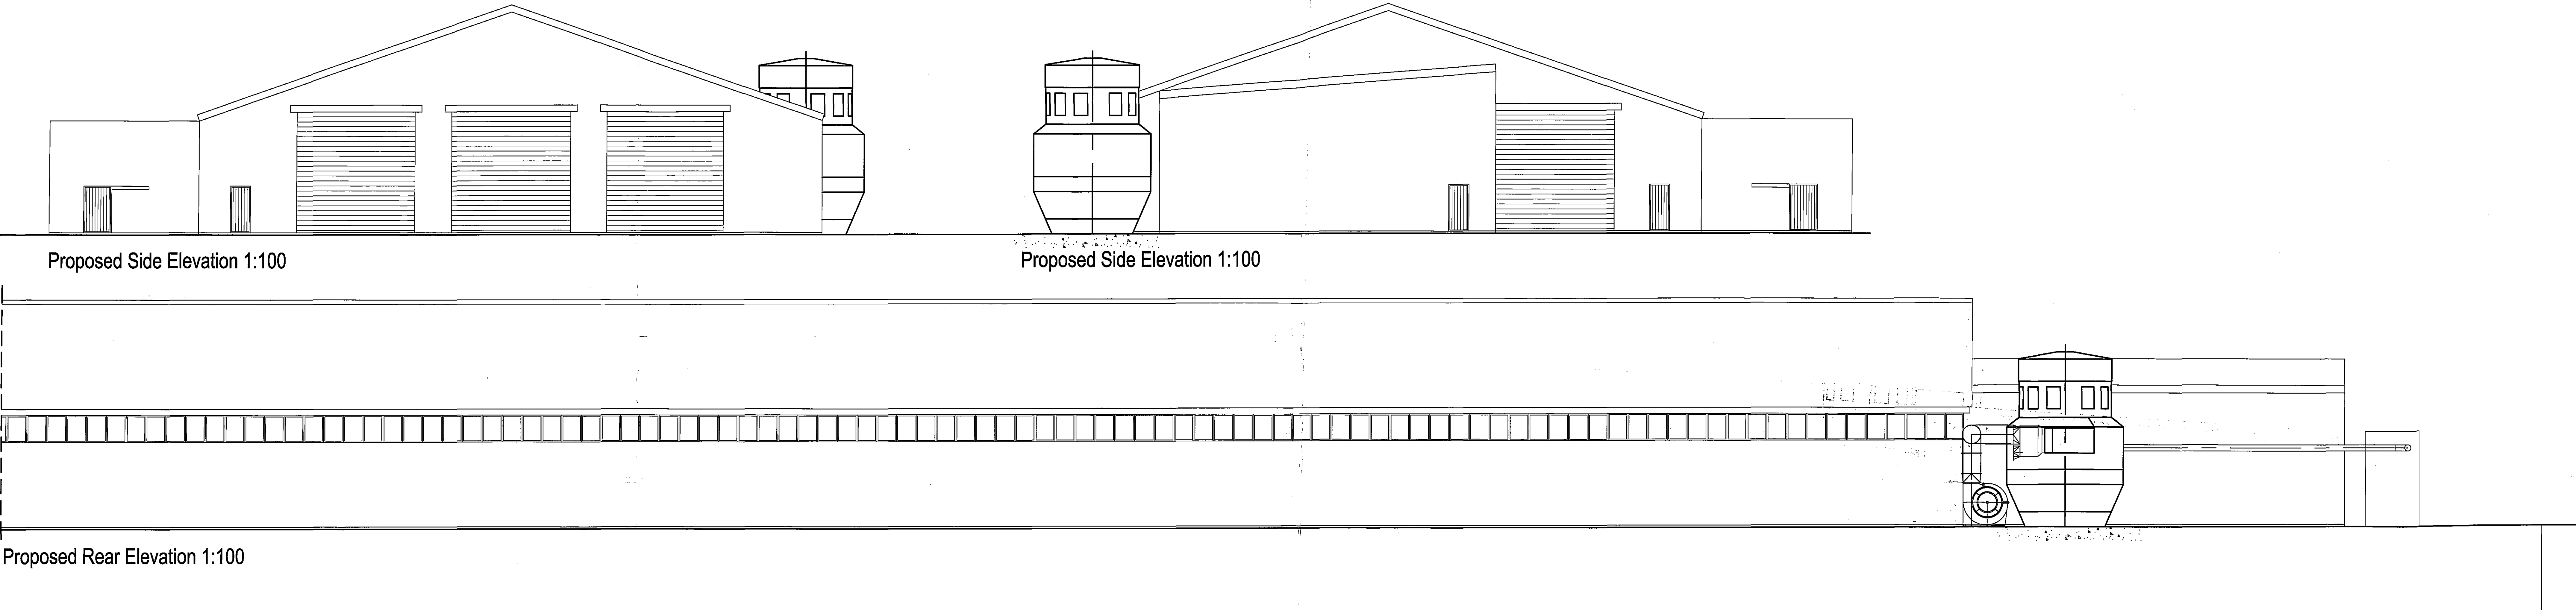


Proposed Layout

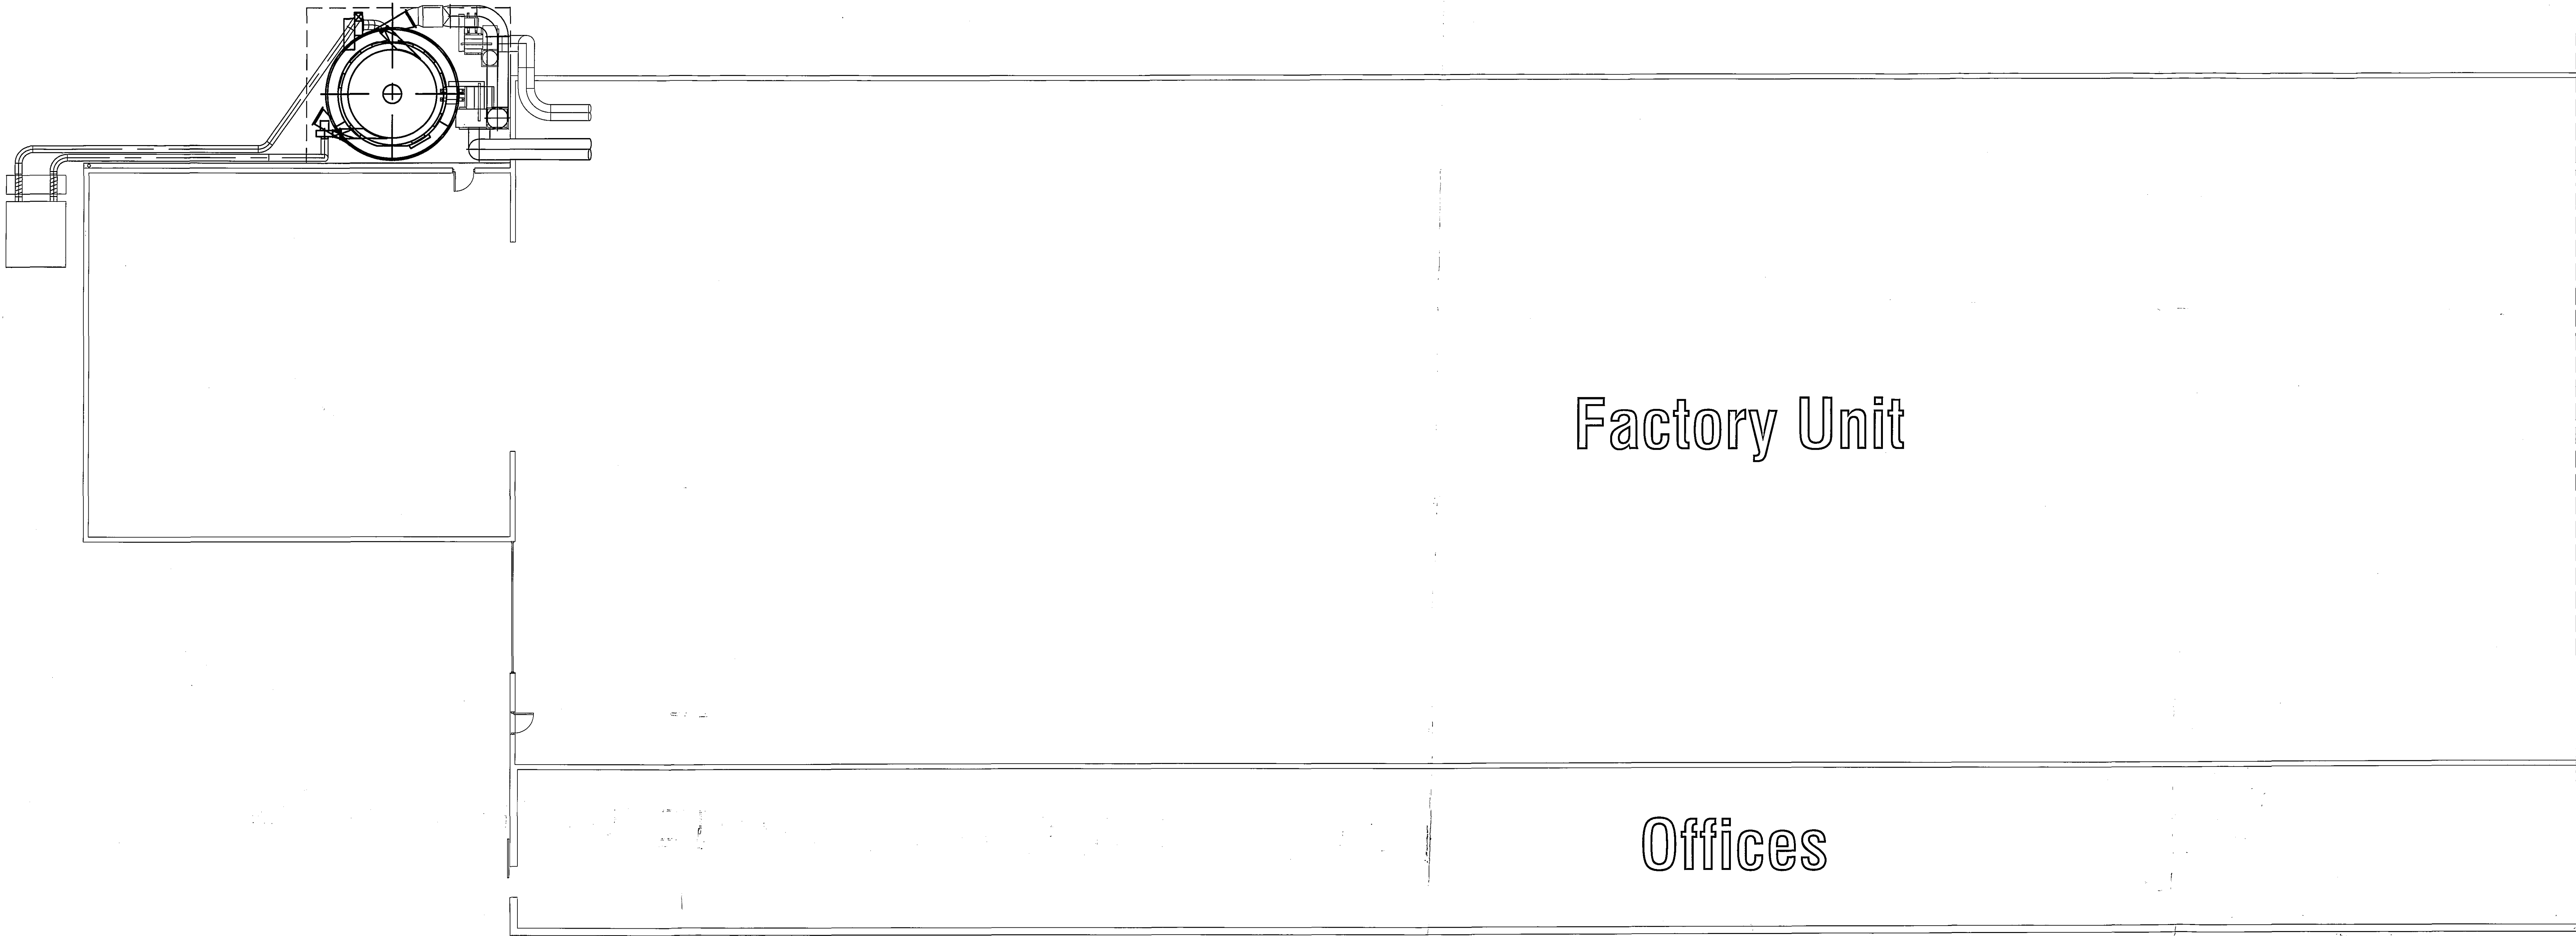

Proposed Floor Plan 1:100

Peter Humphrey Associates Ltd
ARCHITECTURAL DESIGN AND BUILDING

PROJECT
PROPOSED DUST EXTRACTOR TO FACTORY UNIT
A17 / BRIDGE ROAD ROUNDABOUT
SUTTON BRIDGE
LINGS

CLIENT
Mr S Smeeth
DATE: Dec 2005 SCALE: As Shown JOB NO: 4014/03

DO NOT SCALE FROM THIS DRAWING
COPYING, THE DRAWING OR ANY PART THEREOF, IS STRICTLY PROHIBITED
WITHOUT THE CONSENT OF PETER HUMPHREY ASSOCIATES

Peter Humphrey Associates Ltd
ARCHITECTURAL DESIGN AND BUILDING
TELEPHONE 01454 488 888
FAX 01454 488 888
E-MAIL: p.h.a@btinternet.com
REGISTERED MEMBERS: RIBA, RIBA 2005

DETERMINED
PLAN

SHDC
PLANNING & DEVELOPMENT
27 JUL 2006
Ref: 1778/06