


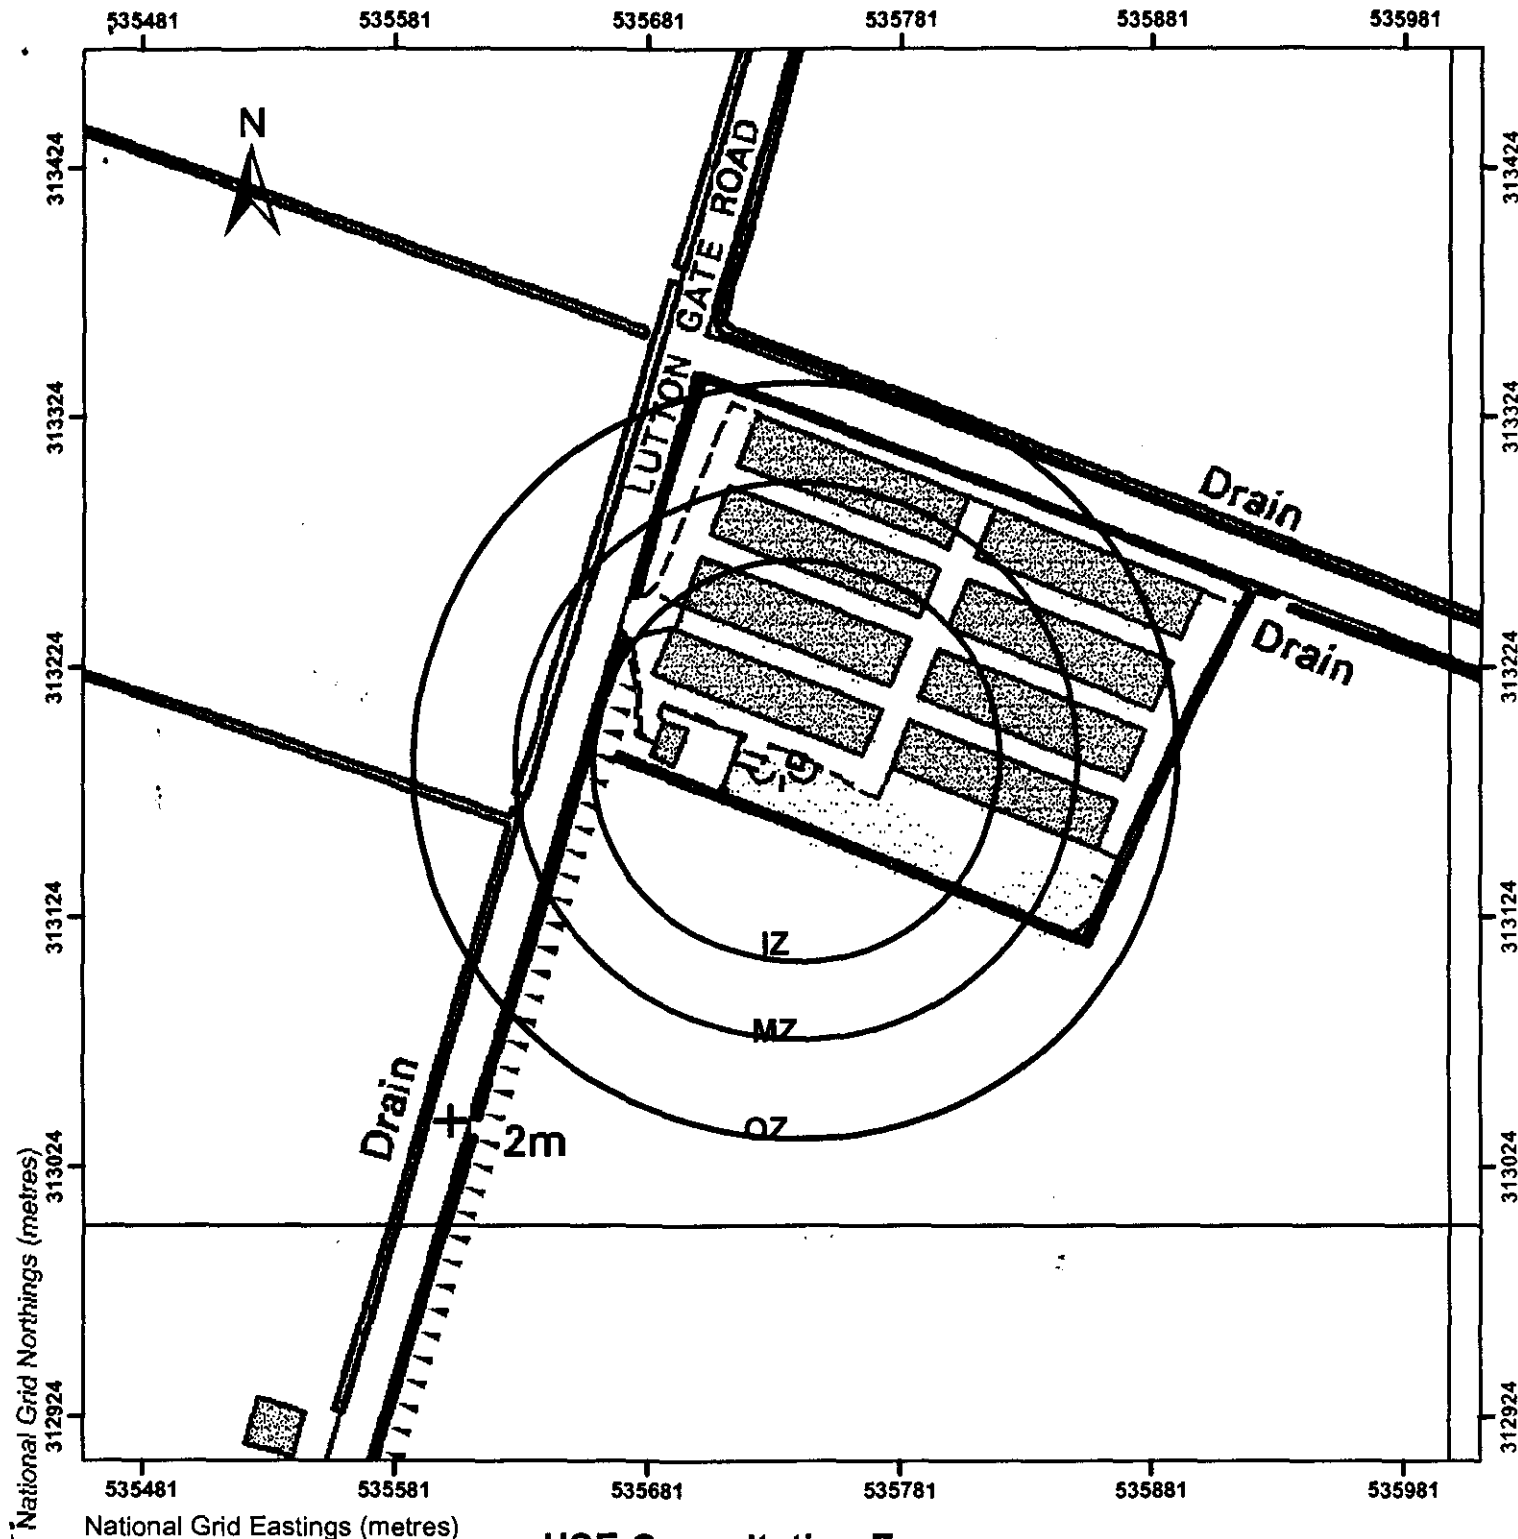

HSE Consultation Zones


Turners Turkeys Ltd, Luttongate Rd, Sutton St Edmunds, Spalding,
Lincs, PE12 0LJ

CIS Location 4148
HSE Ref: HL/3539
Grid Ref: TF 357 131

Prepared - October 2002

This map supersedes all previous or undated maps

IZ = Inner Zone
MZ= Middle Zone
OZ= Outer Zone

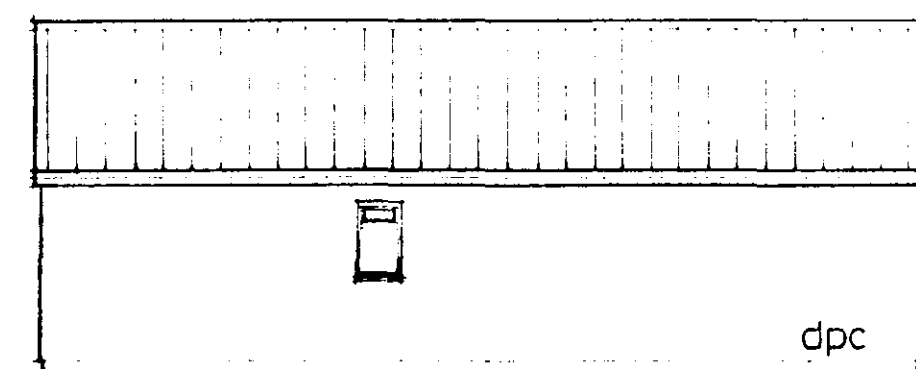


side elevation

055g aluzinc
roofing:
juniper green

sandtex painted
blockwork
colour: beige

dpc

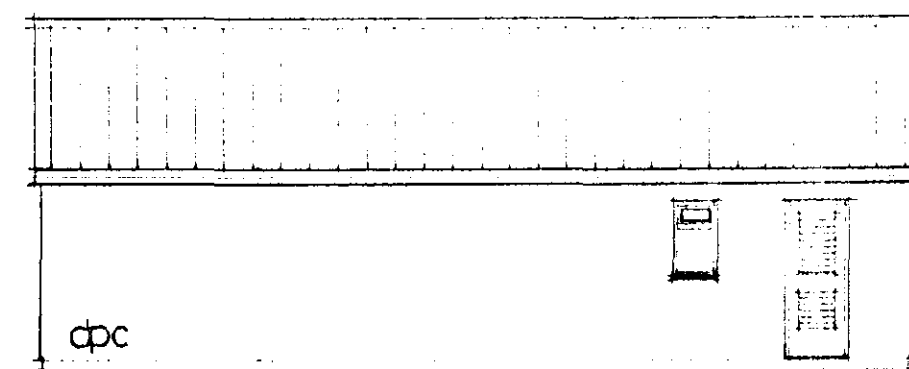

side elevation


obscure glazing
louvred door

roof: aluzinc profiled metal
sheeting on 50x50 treated
sw battens at 1m centres
over gangnailed trussed rafters
at 600mm centres to specialist
design on 100x50 sw plate
m.s. bat anchor straps at
max 2m max centres

sw stained fascia and
soffit with continuous
ventilation strip
i.g LI S50 insulated lintel

double glazed window
with trickle vent
rockclose cavity closer

hyload dpc

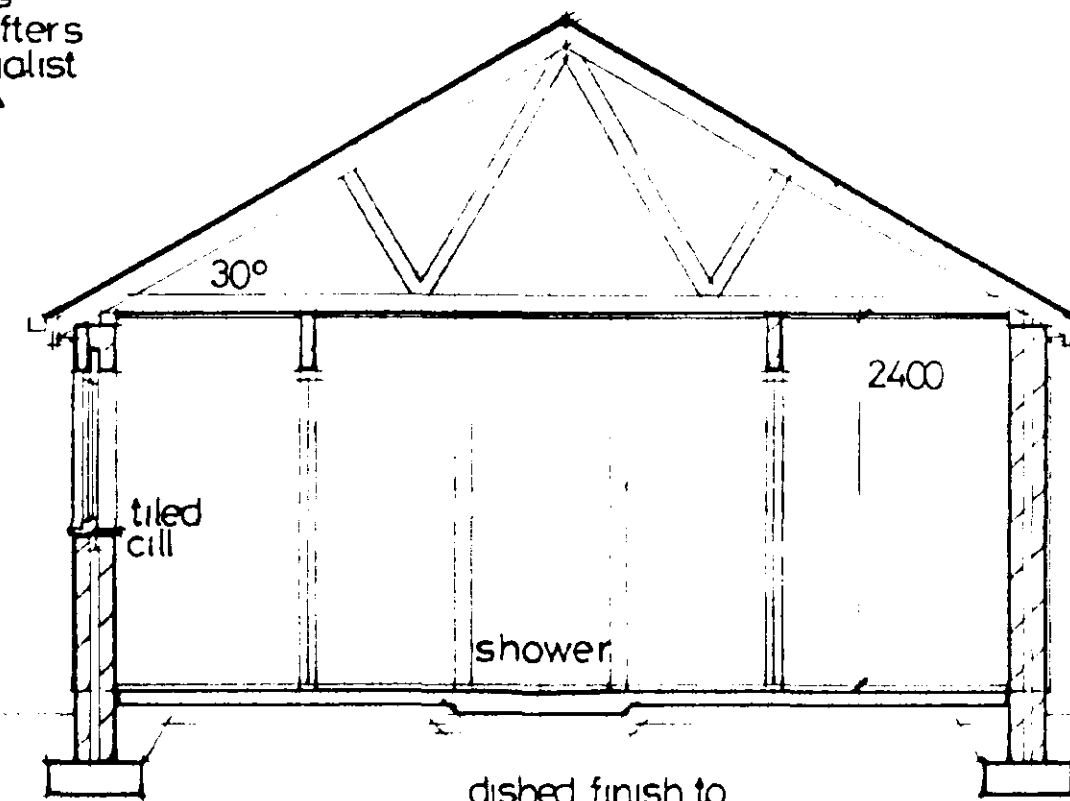

cross section

floor: quarry tile finish
bedded on 100 mm min
concrete oversite on
1200g polythene dpm on
sand blinding on min
100 mm well consolidated
sub base


dished finish to
to shower area

12.5 plasterboard ceiling
scim finish: painted
150mm rockwool insulation
squareflo gutters
closed cavity

external walls: 7.5 mm paint grade
lignacite cavity block wall with
50 mm rockwool insulated cavity
internal lintels: standard lignacrite
beam type


150

675x225 concrete strip footings
depth to suit ground conditions
(min 1m in clay) and to
Building Inspectors approval

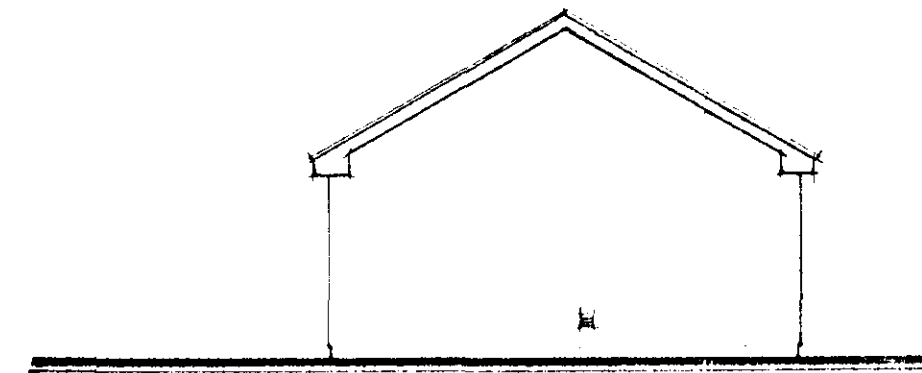

rear elevation

drier vent

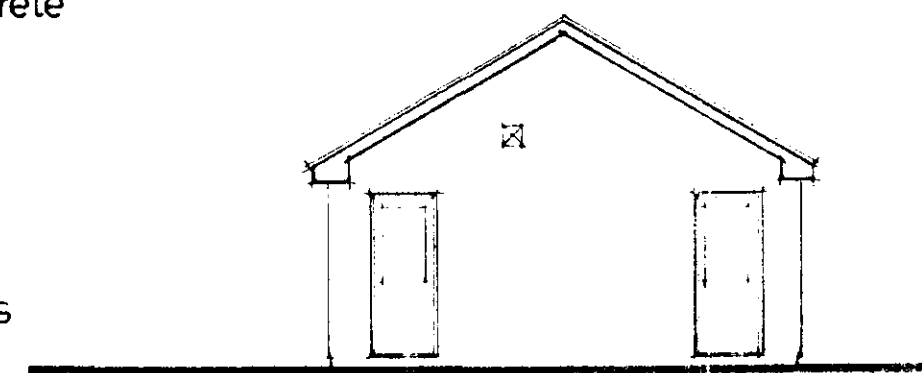

front elevation

extract vent

obscure laminated
glazing

ramped access

Heating: Ariston LPG Dia System 27 Model C
Boiler: Heatrae Sadia Megaflo Indirect CL250
Cylinder: Kermi Classic type
Radiators: F control pneumatic switch
comm wall plate
comm valve 1/4" CGV chrome
flow restrictors
comm in line strainer

Shower Equipment:

Aqualisa F control pneumatic switch
comm wall plate
comm valve 1/4" CGV chrome
flow restrictors
comm in line strainer

Electrical:
Breaker board MEM BM61 3ph c/w isolator
Hair Dryers Worldwind Model HD2 1200w
Light Fittings Fluorescent
Thorn vapourproof LUGS 158

Light Fittings Thorn FUO 2D 16W

External Floodlight
SON 70W

Electrical Fitting
MK K Range (surface)


Cable Type 6242Y Twin and earth
Room Stat Pegler TLM 2257

Emergency Light Menvier
Time Clock Smith TS 204

Conduit Drops
EGA 20 mm white

- ⊙ self activating hair driers
- D triton redring shower unit
- ⌒ twin 13 amp s.socket
- ⊙ low wattage ceiling light
- ⌒ pull chord switch
- ⊙ ext bulkhead light
- ⊙ extract fans operating at 15 lit/sec
- ⊙ extinguisher
- ⌒ curtain + rail

- s fold down seat 320 sq with radiator under 820 w x 460 h
- l lockers 910w x 460 d
- internal doors 760 wide
- m.j. blockwork movement joints

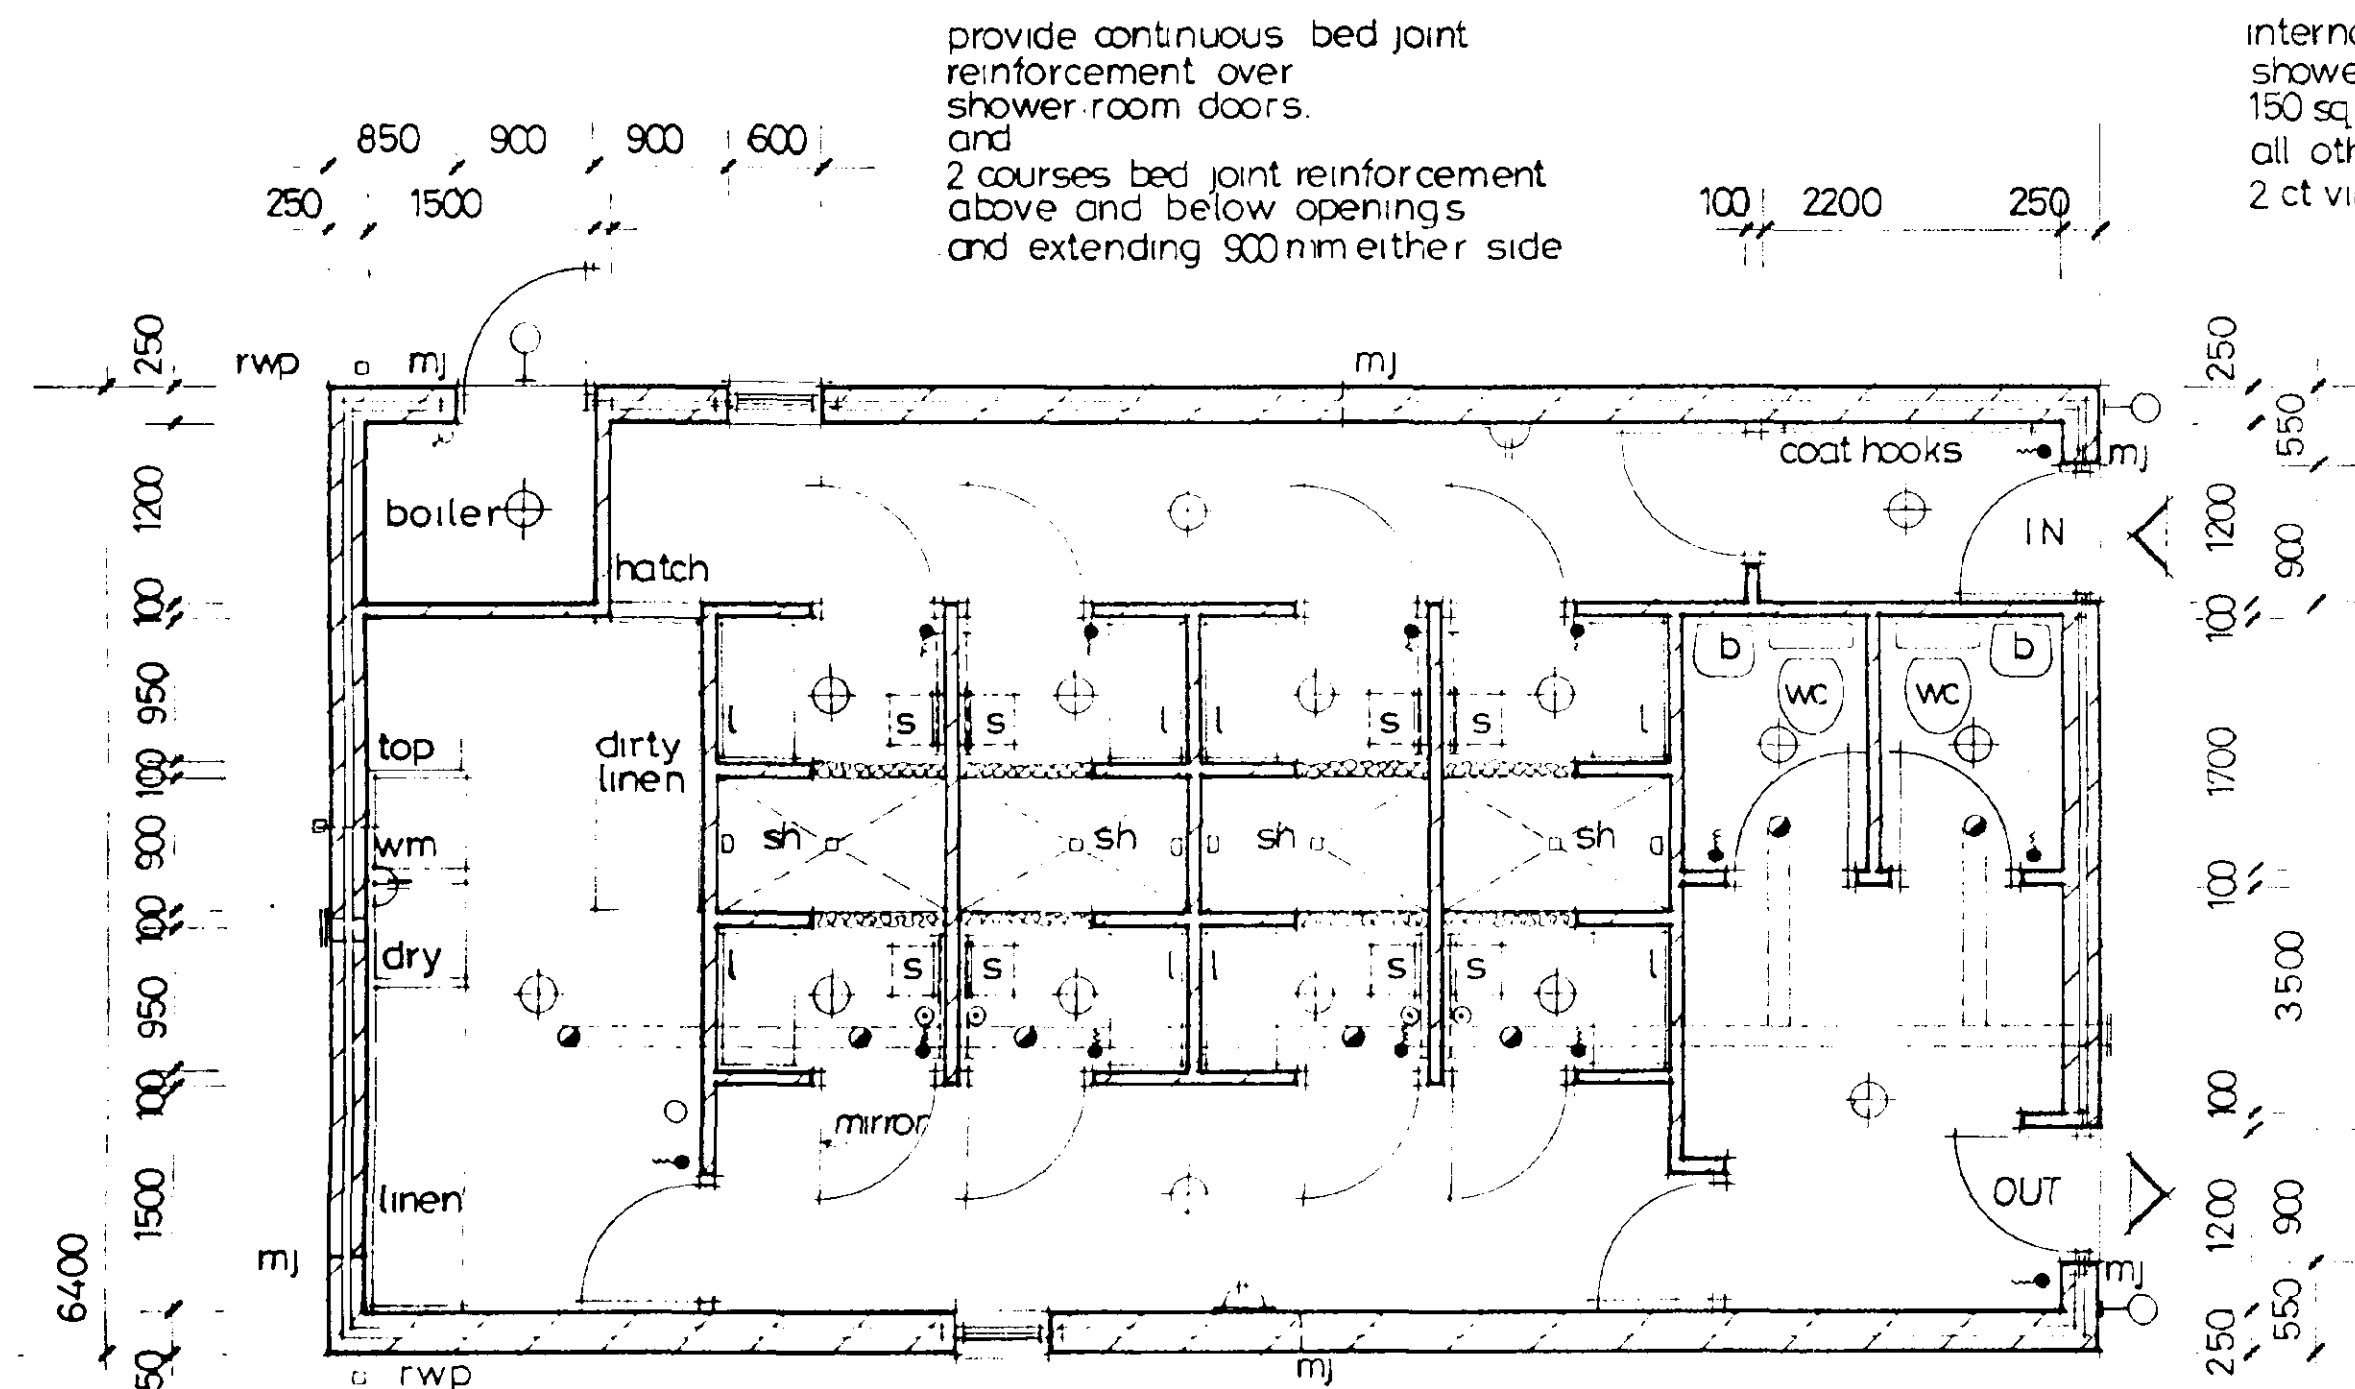

250 2200 100 1500 100 1500 100 1500 100 1500 100 1200 100 1200 250
4150
11.700

plan

SOUTH HOLLAND DC
HOUSING & PLANNING
16 NOV 1998
Ref: 1130/98

Les
Brown
associates
planning & development
consultancy

4 Church Street Old Catton
Norwich NR6 7DS.
TEL - FAX 01603 403186

PROJECT
BERNARD MATTHEWS
PLC
SHOWER BLOCK

DRAWING
PLAN / ELEVATIONS &
SECTION

SCALE DATE DRAWN
1:50 1:100 8-98
REF DRAWING NUMBER
229 BMGEN 01

DETERMINED
PLAN