


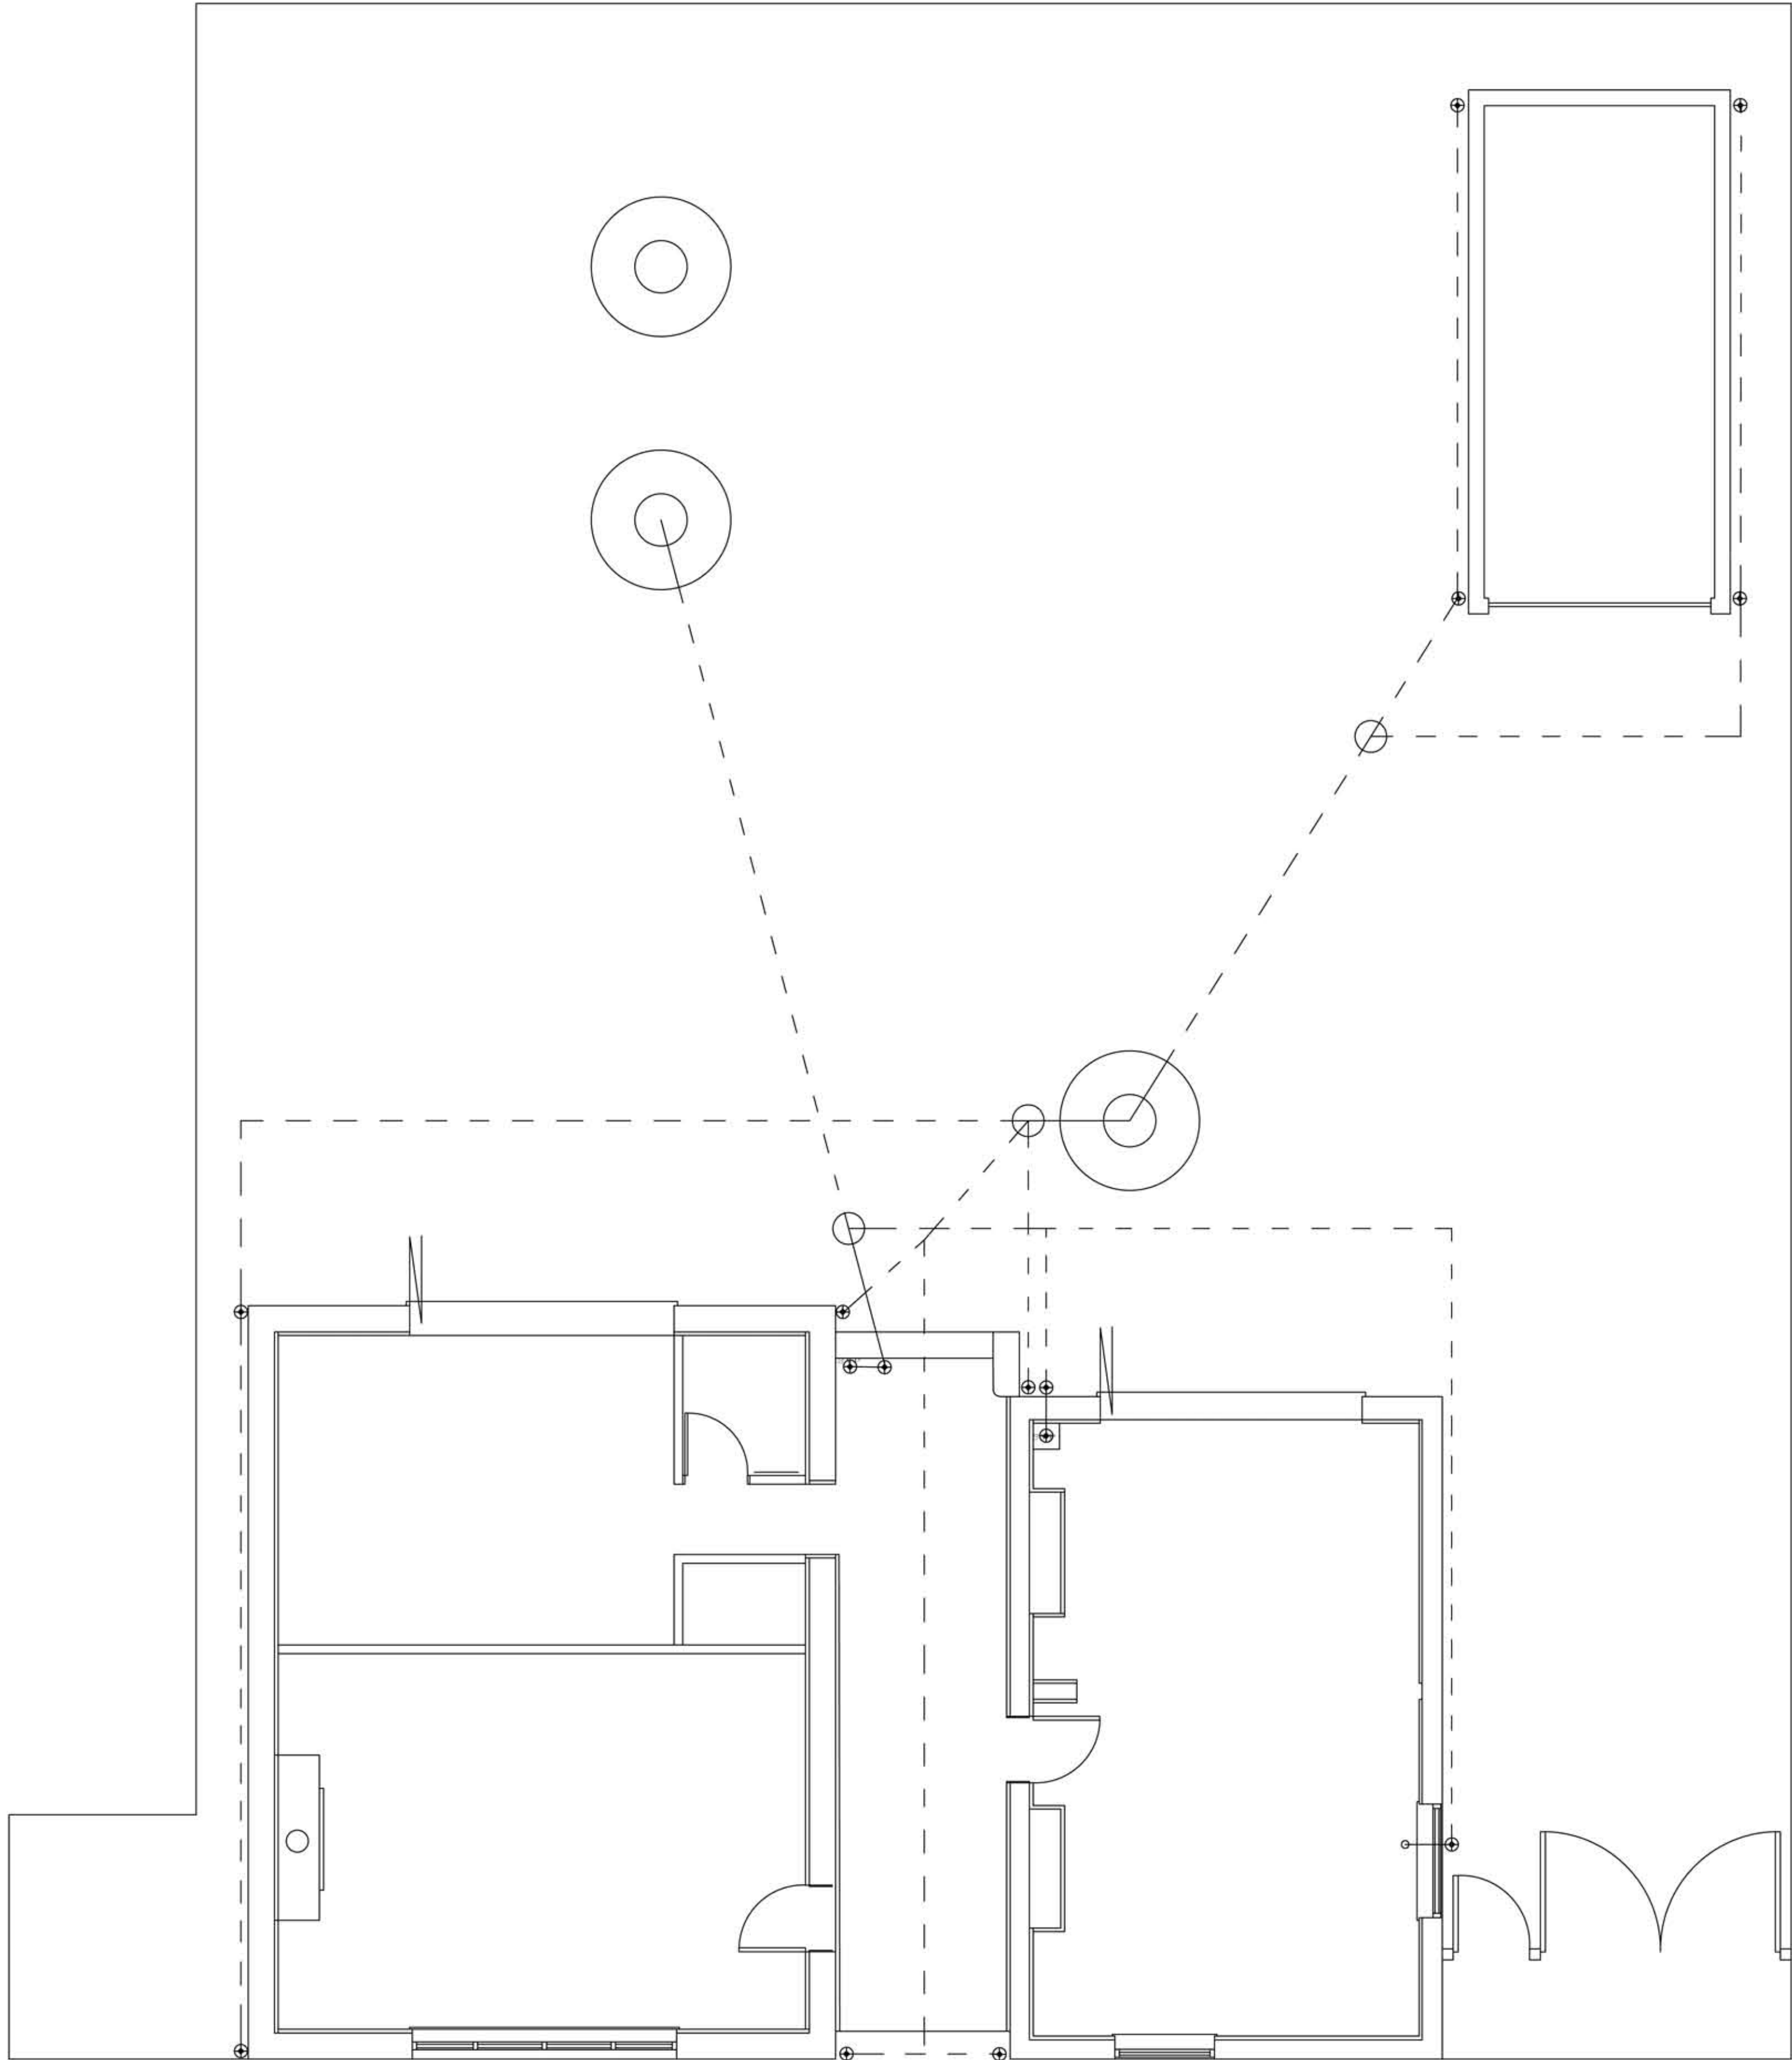

DRAWING TITLE - PROPOSED DRAINAGE PLAN
DRAWING REFERENCE NUMBER - 004
SCALE - 1:50
PAPER SIZE - A1
DATE - 29.03.2017

67 CHAPELGATE - SUTTON ST. JAMES - SPALDING - LINCOLNSHIRE

