


PLEASE DO NOT SCALE FROM THIS DRAWING

Drainage Legend:


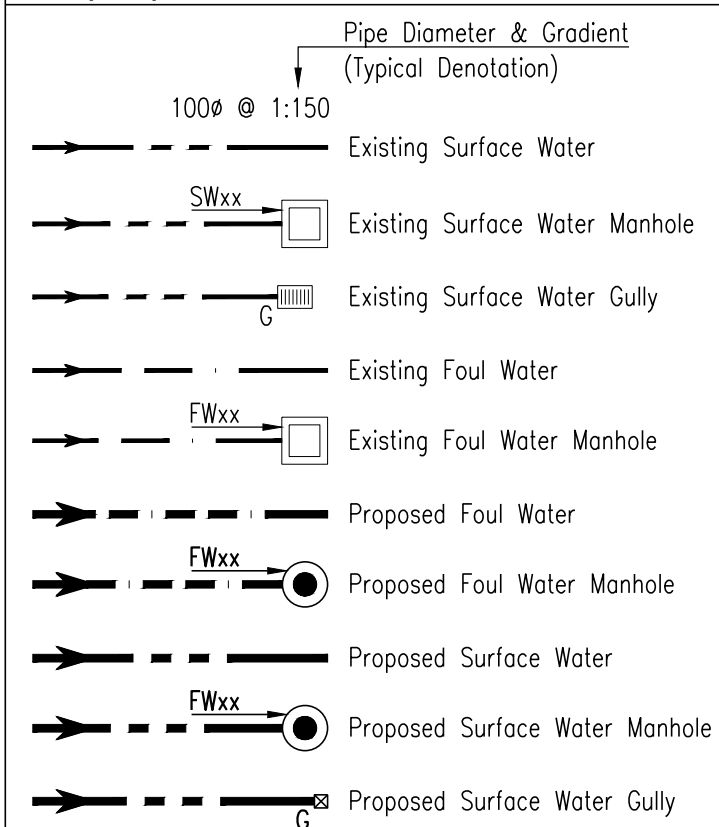


Hoofmark D-Raintank Storage
Tanks Required For Soakaway
All To Be Installed As Recommended
By Manufacturer For A Soakaway
Installation. (Tank Size 0.84x0.81x0.40m)

Hoofmark D-Raintank Storage
Tanks Required For Soakaway
All To Be Installed As Recommended
By Manufacturer For A Soakaway
Installation. (Tank Size 0.84x0.81x0.40m)

Hoofmark D-Raintank Storage
Tanks Required For Soakaway
All To Be Installed As Recommended
By Manufacturer For A Soakaway
Installation. (Tank Size 0.84x0.81x0.40m)

Hoofmark D-Raintank Storage
Tanks Required For Soakaway
All To Be Installed As Recommended
By Manufacturer For A Soakaway
Installation. (Tank Size 0.84x0.81x0.40m)

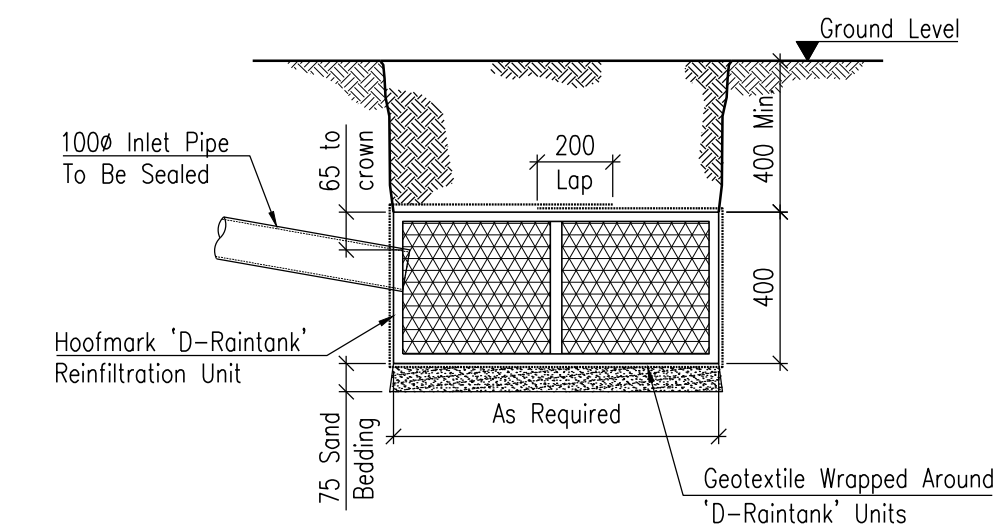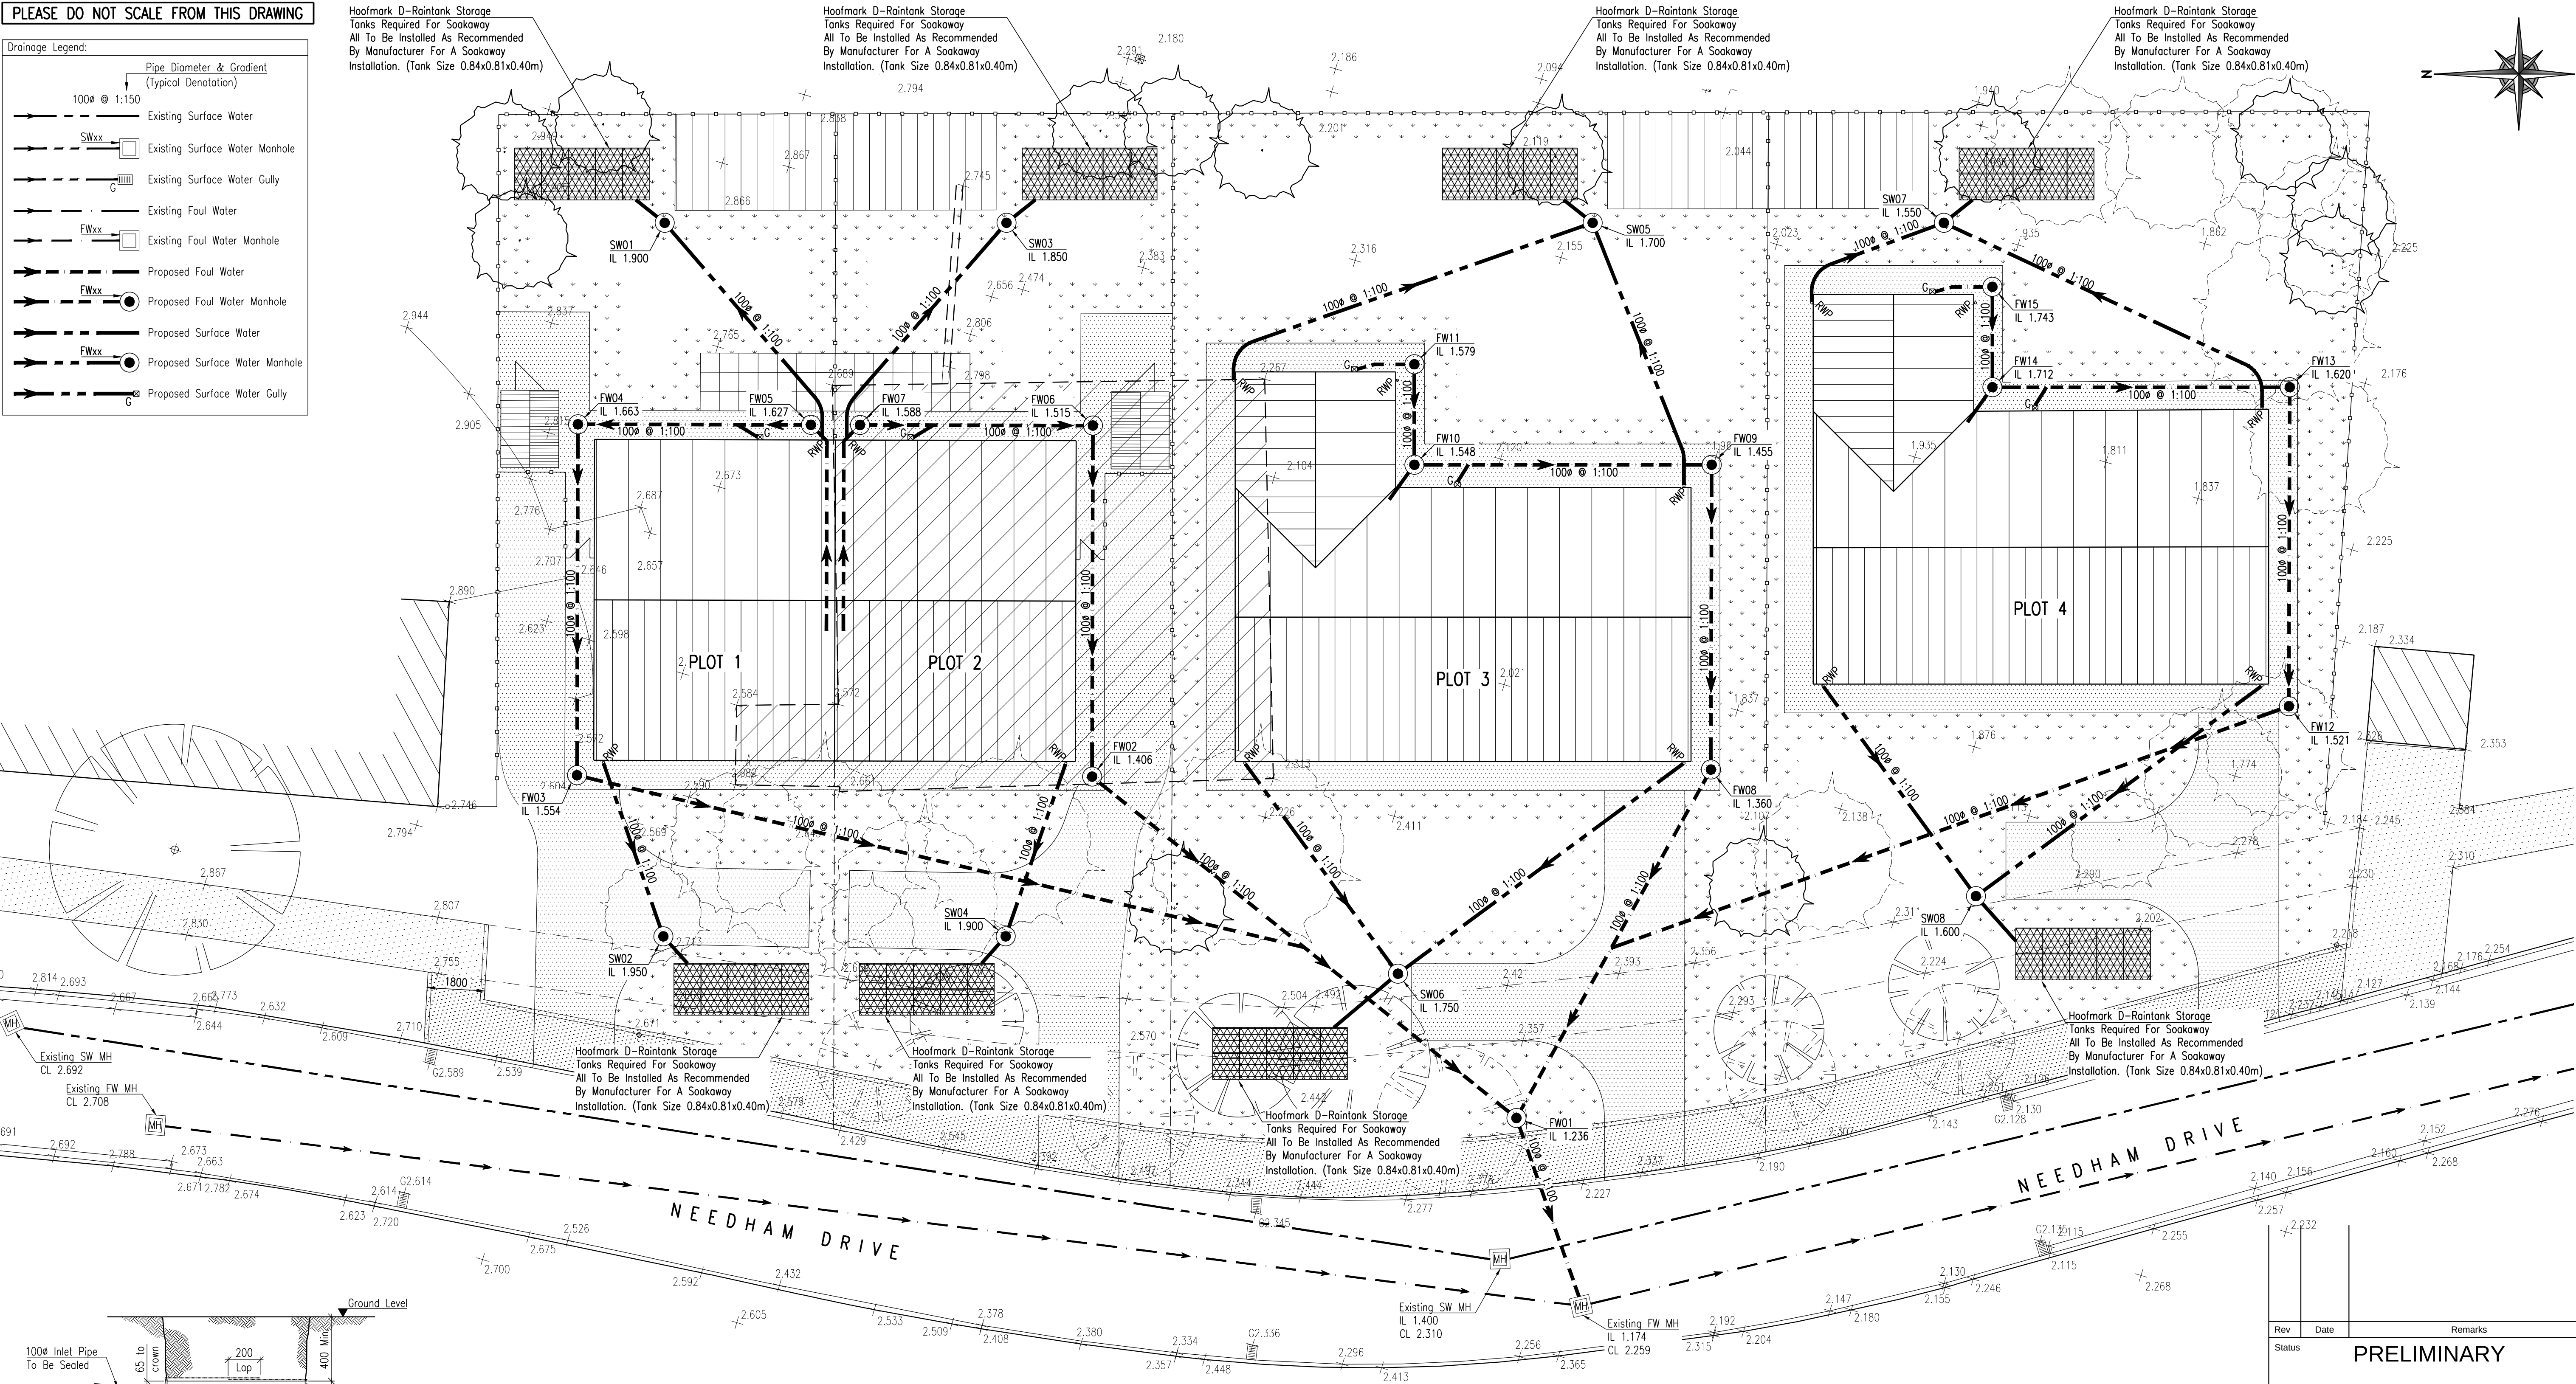

Soakaway Trench Detail

Scale 1:20

Rev	Date	Remarks
Status		PRELIMINARY



Project
**Housing Development
at Needham Drive
Sutton St. James, Lincs.
For D.Brown Builders**

Title
Proposed Drainage Layout

Date	June 14	Scale	1:200	@A1
Drawn	AS	Checked	SRC	
Design	-	File Name	23113-05	

DRG No. 23113/05