




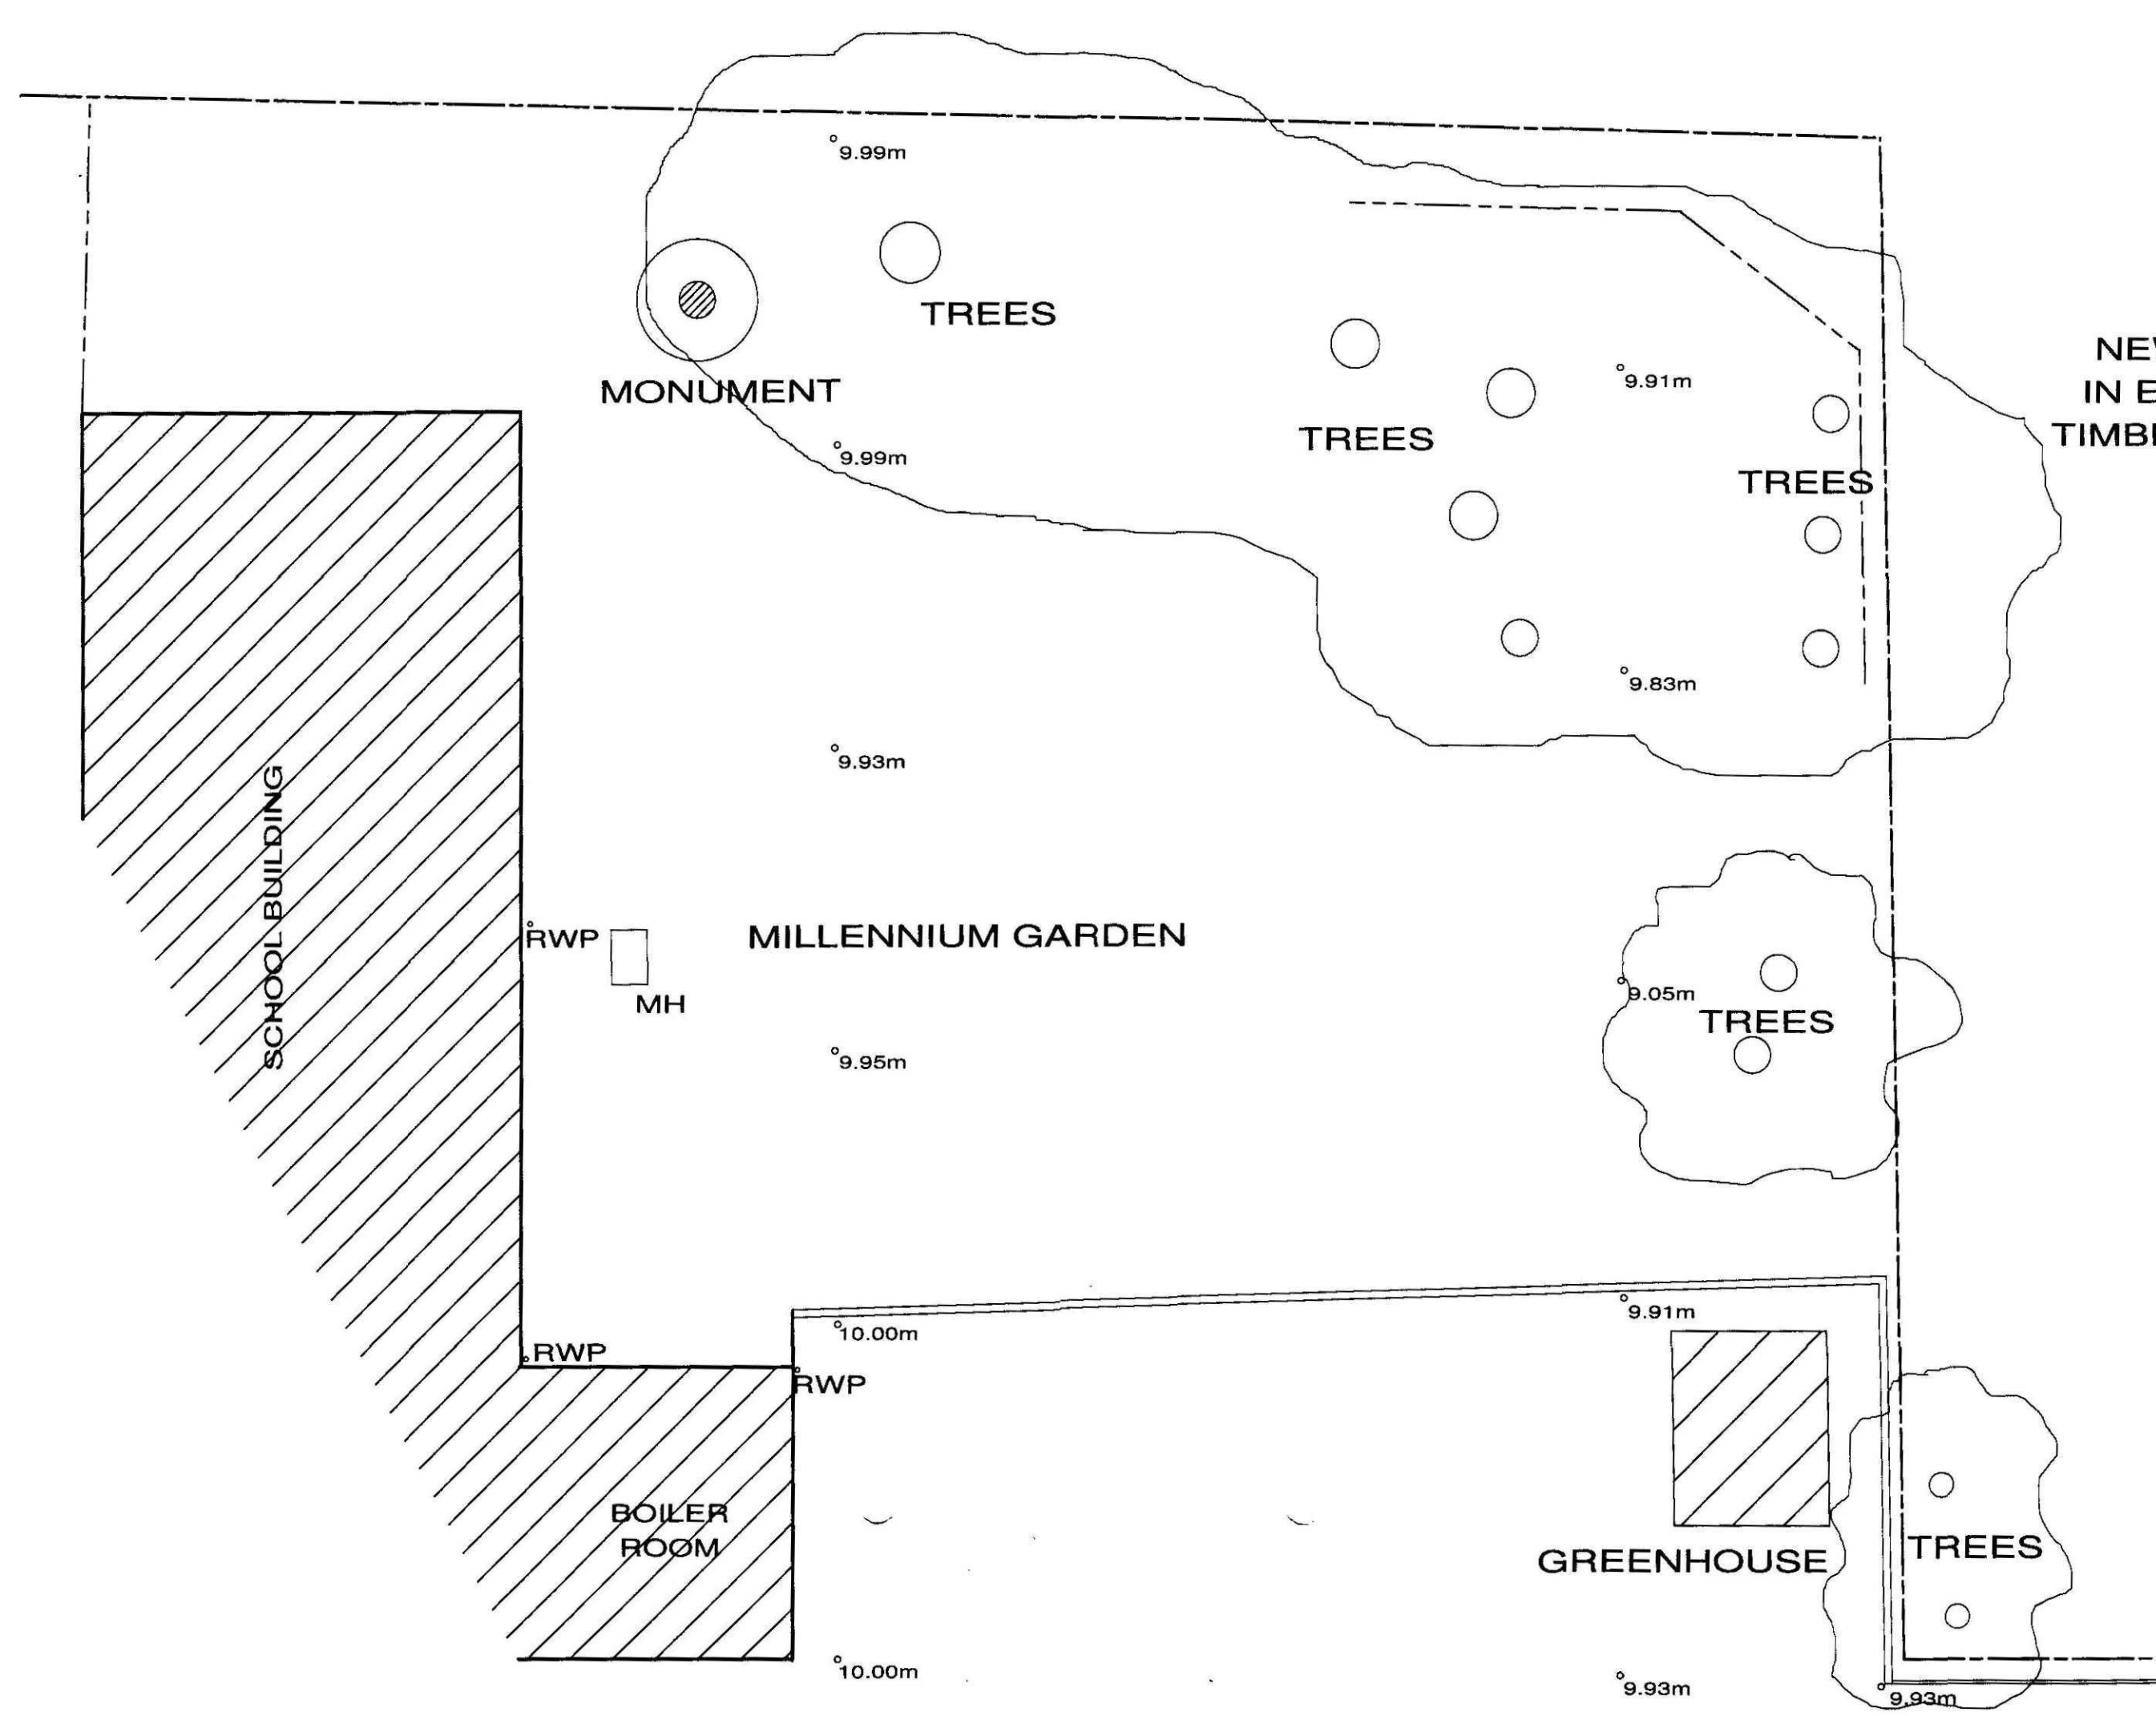


EXISTING PLAN

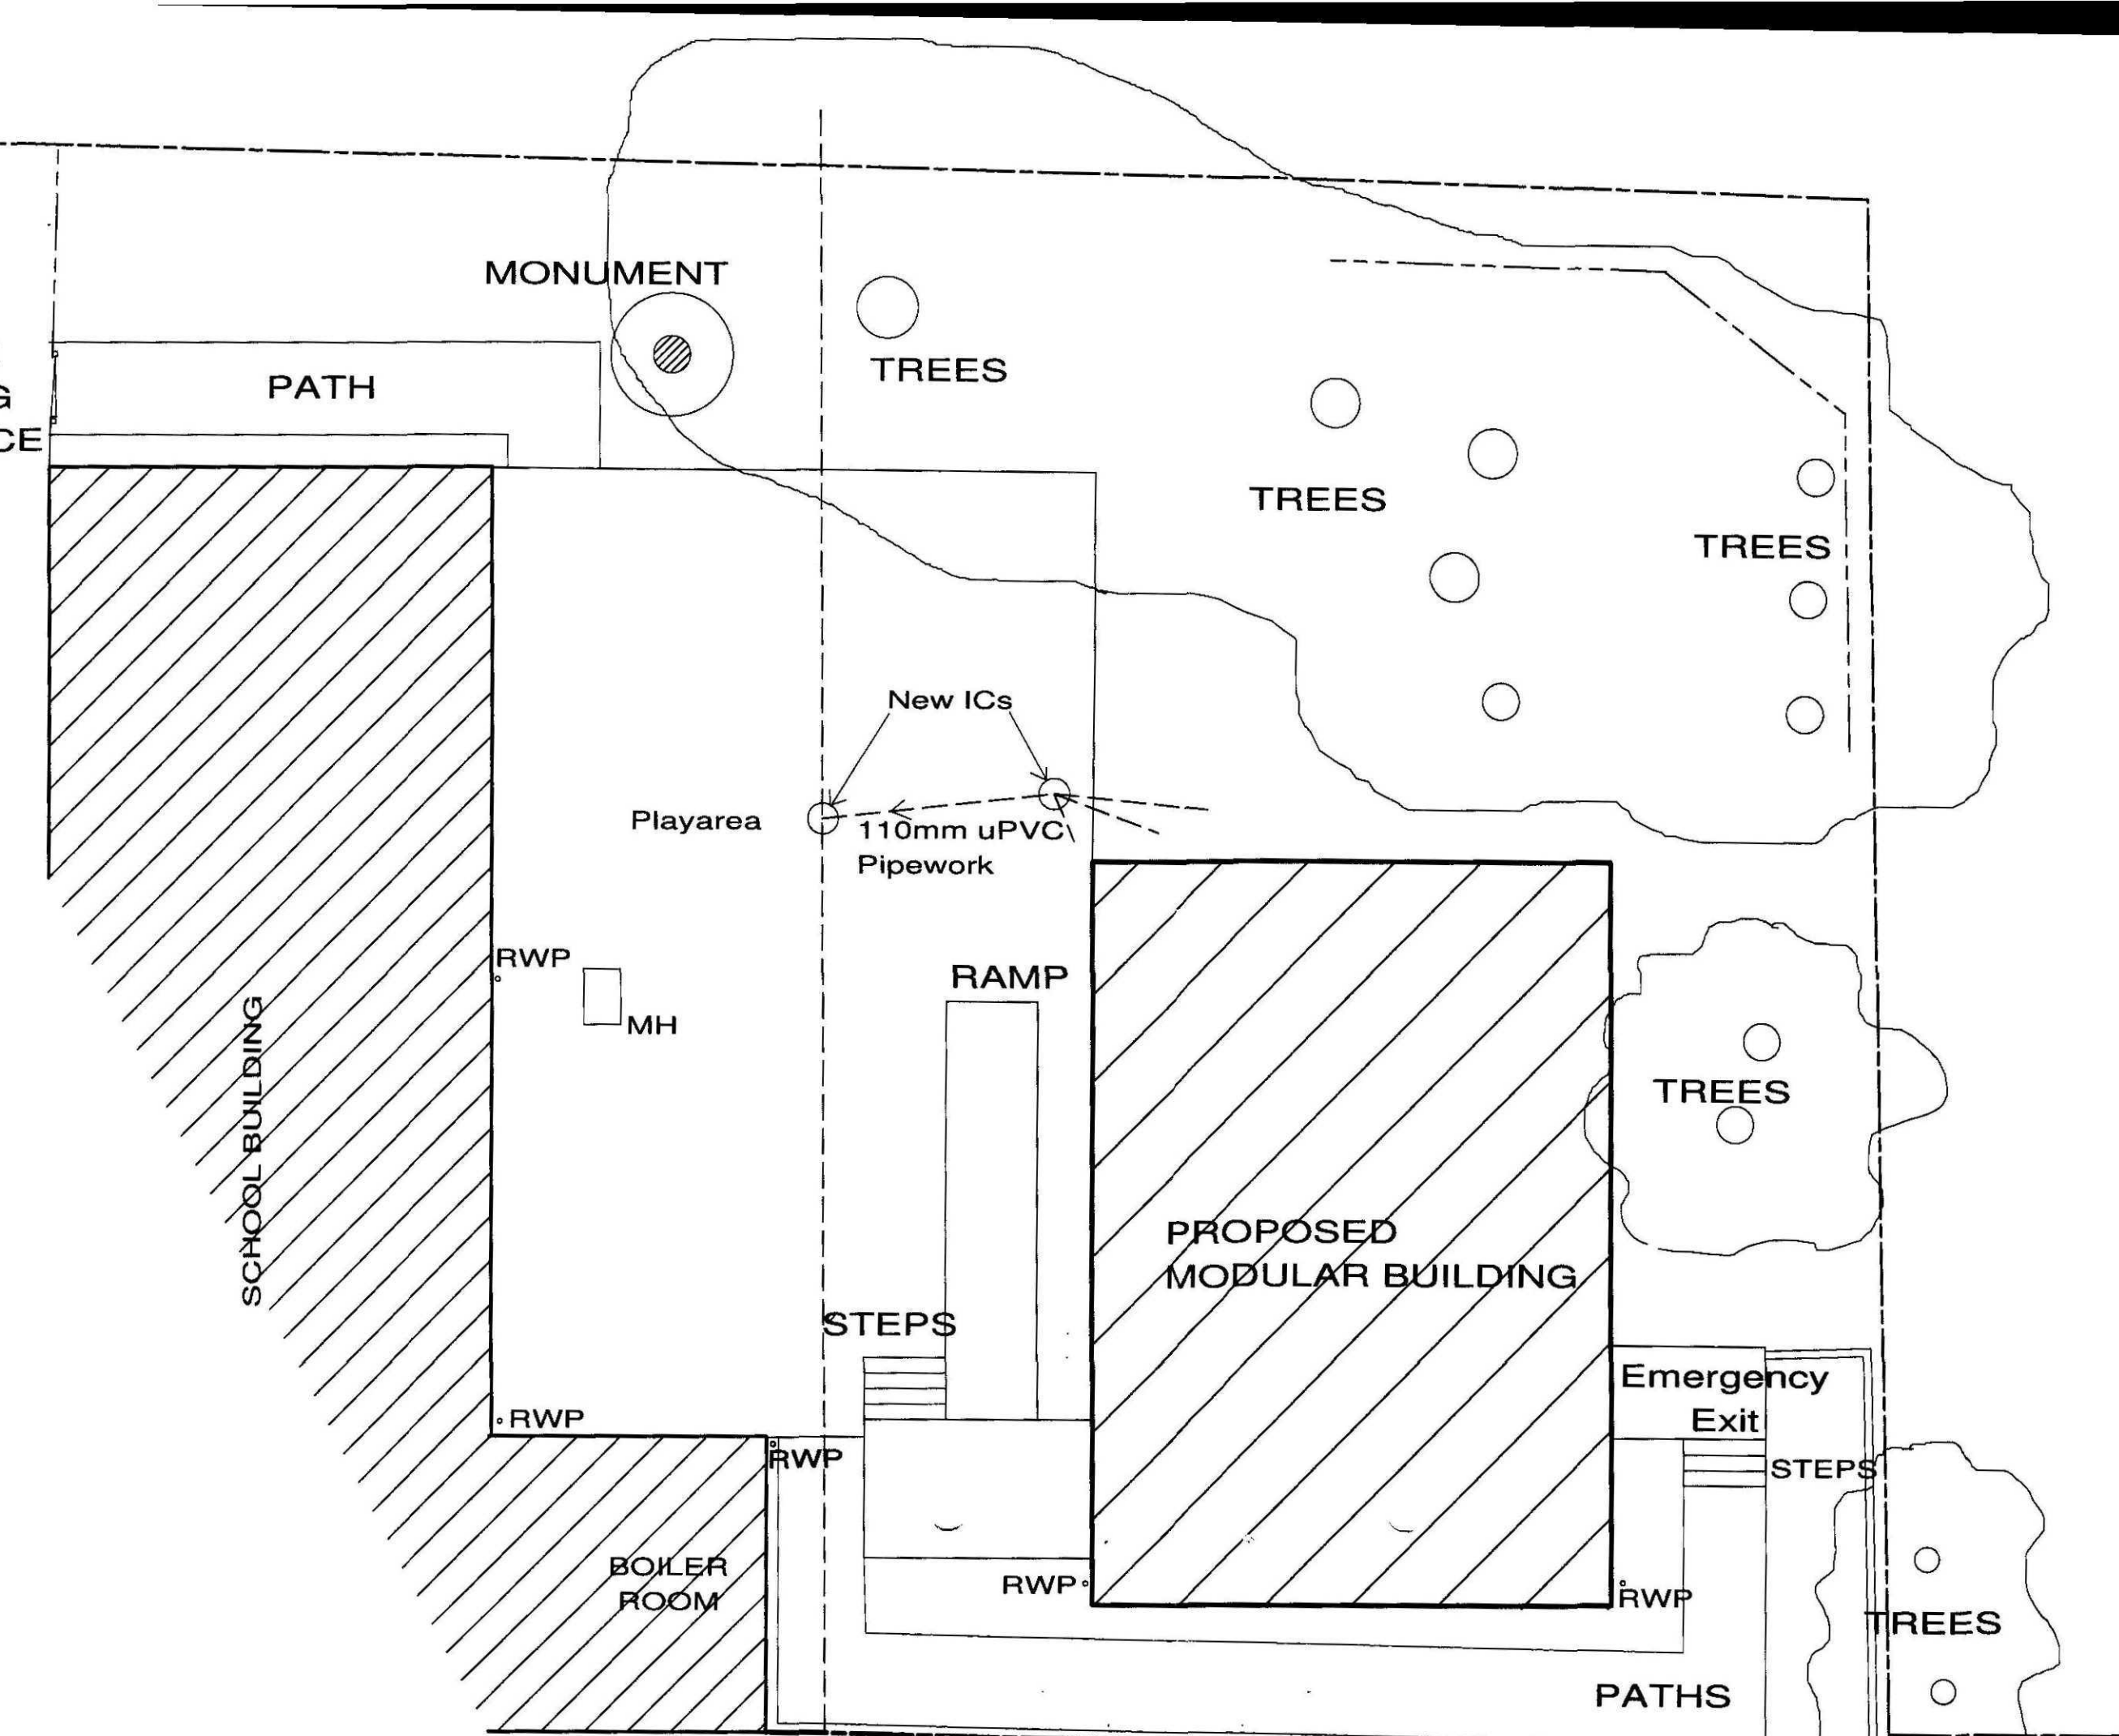


PROPOSED PLAN

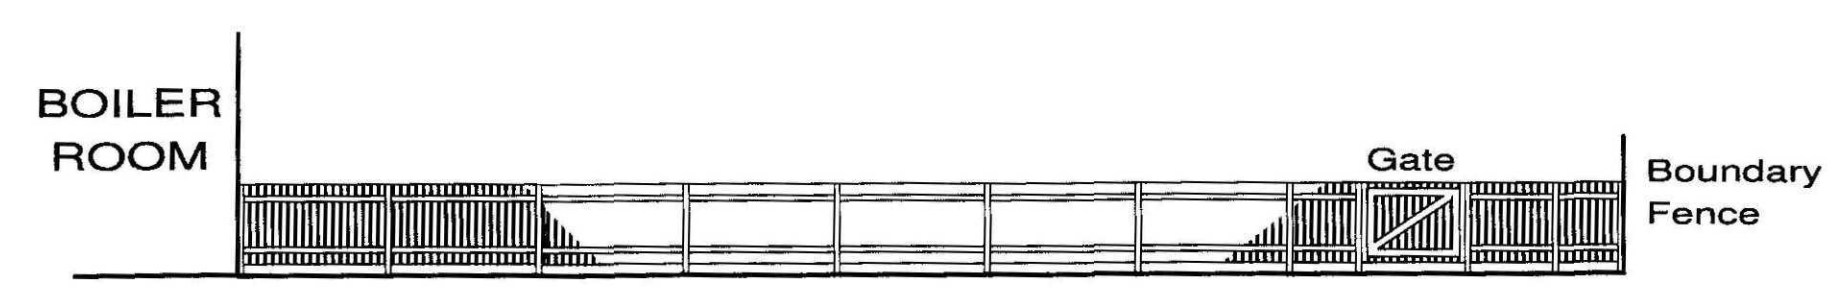

FRONT ELEVATION OF TIMBER FENCE

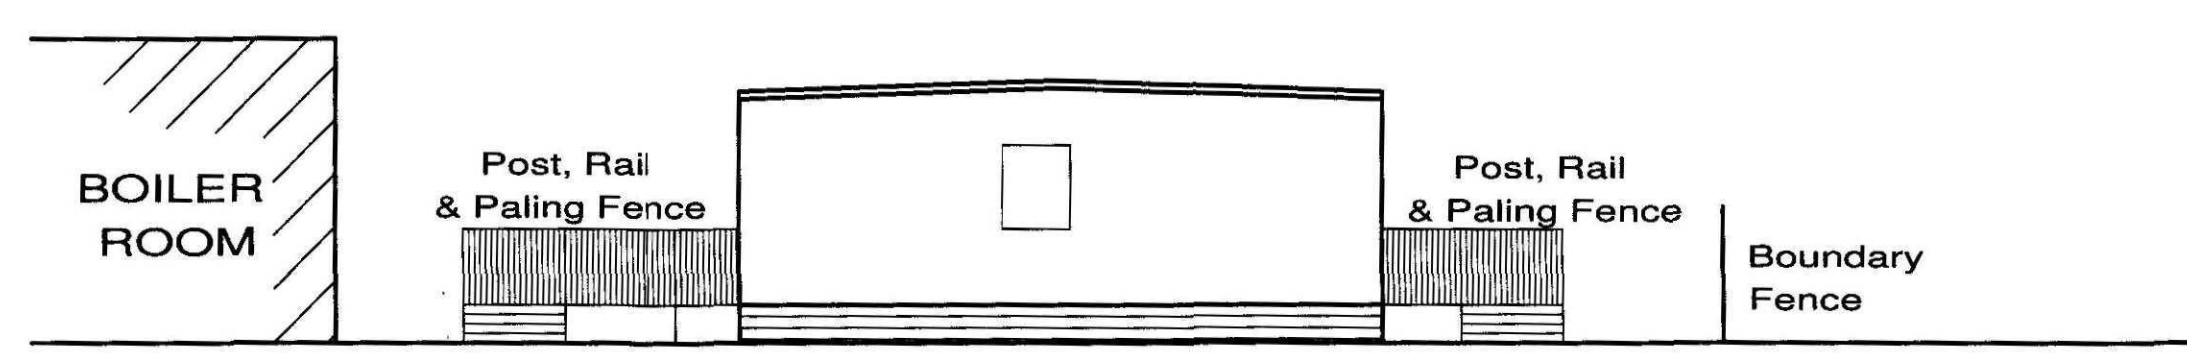

 PROPOSED END ELEVATION FROM ROAD
Omitting fence for clarity



For details of the proposed modular building see drawing EG06602-101 C
No trees to be removed as part of this scheme but lower limbs may be trimmed

Diocese of Lincoln Board of Education


**Diocesan Education Centre
Diocesan Offices
The Old Palace
Minster Yard
LINCOLN
LN2 1PU**

Tydd St Mary Church of England Primary School


Proposed Modular Building

Drawing No: TYD.14 / 04

Date: 29/10/2008 Drawn: MJP Scale: 1/50

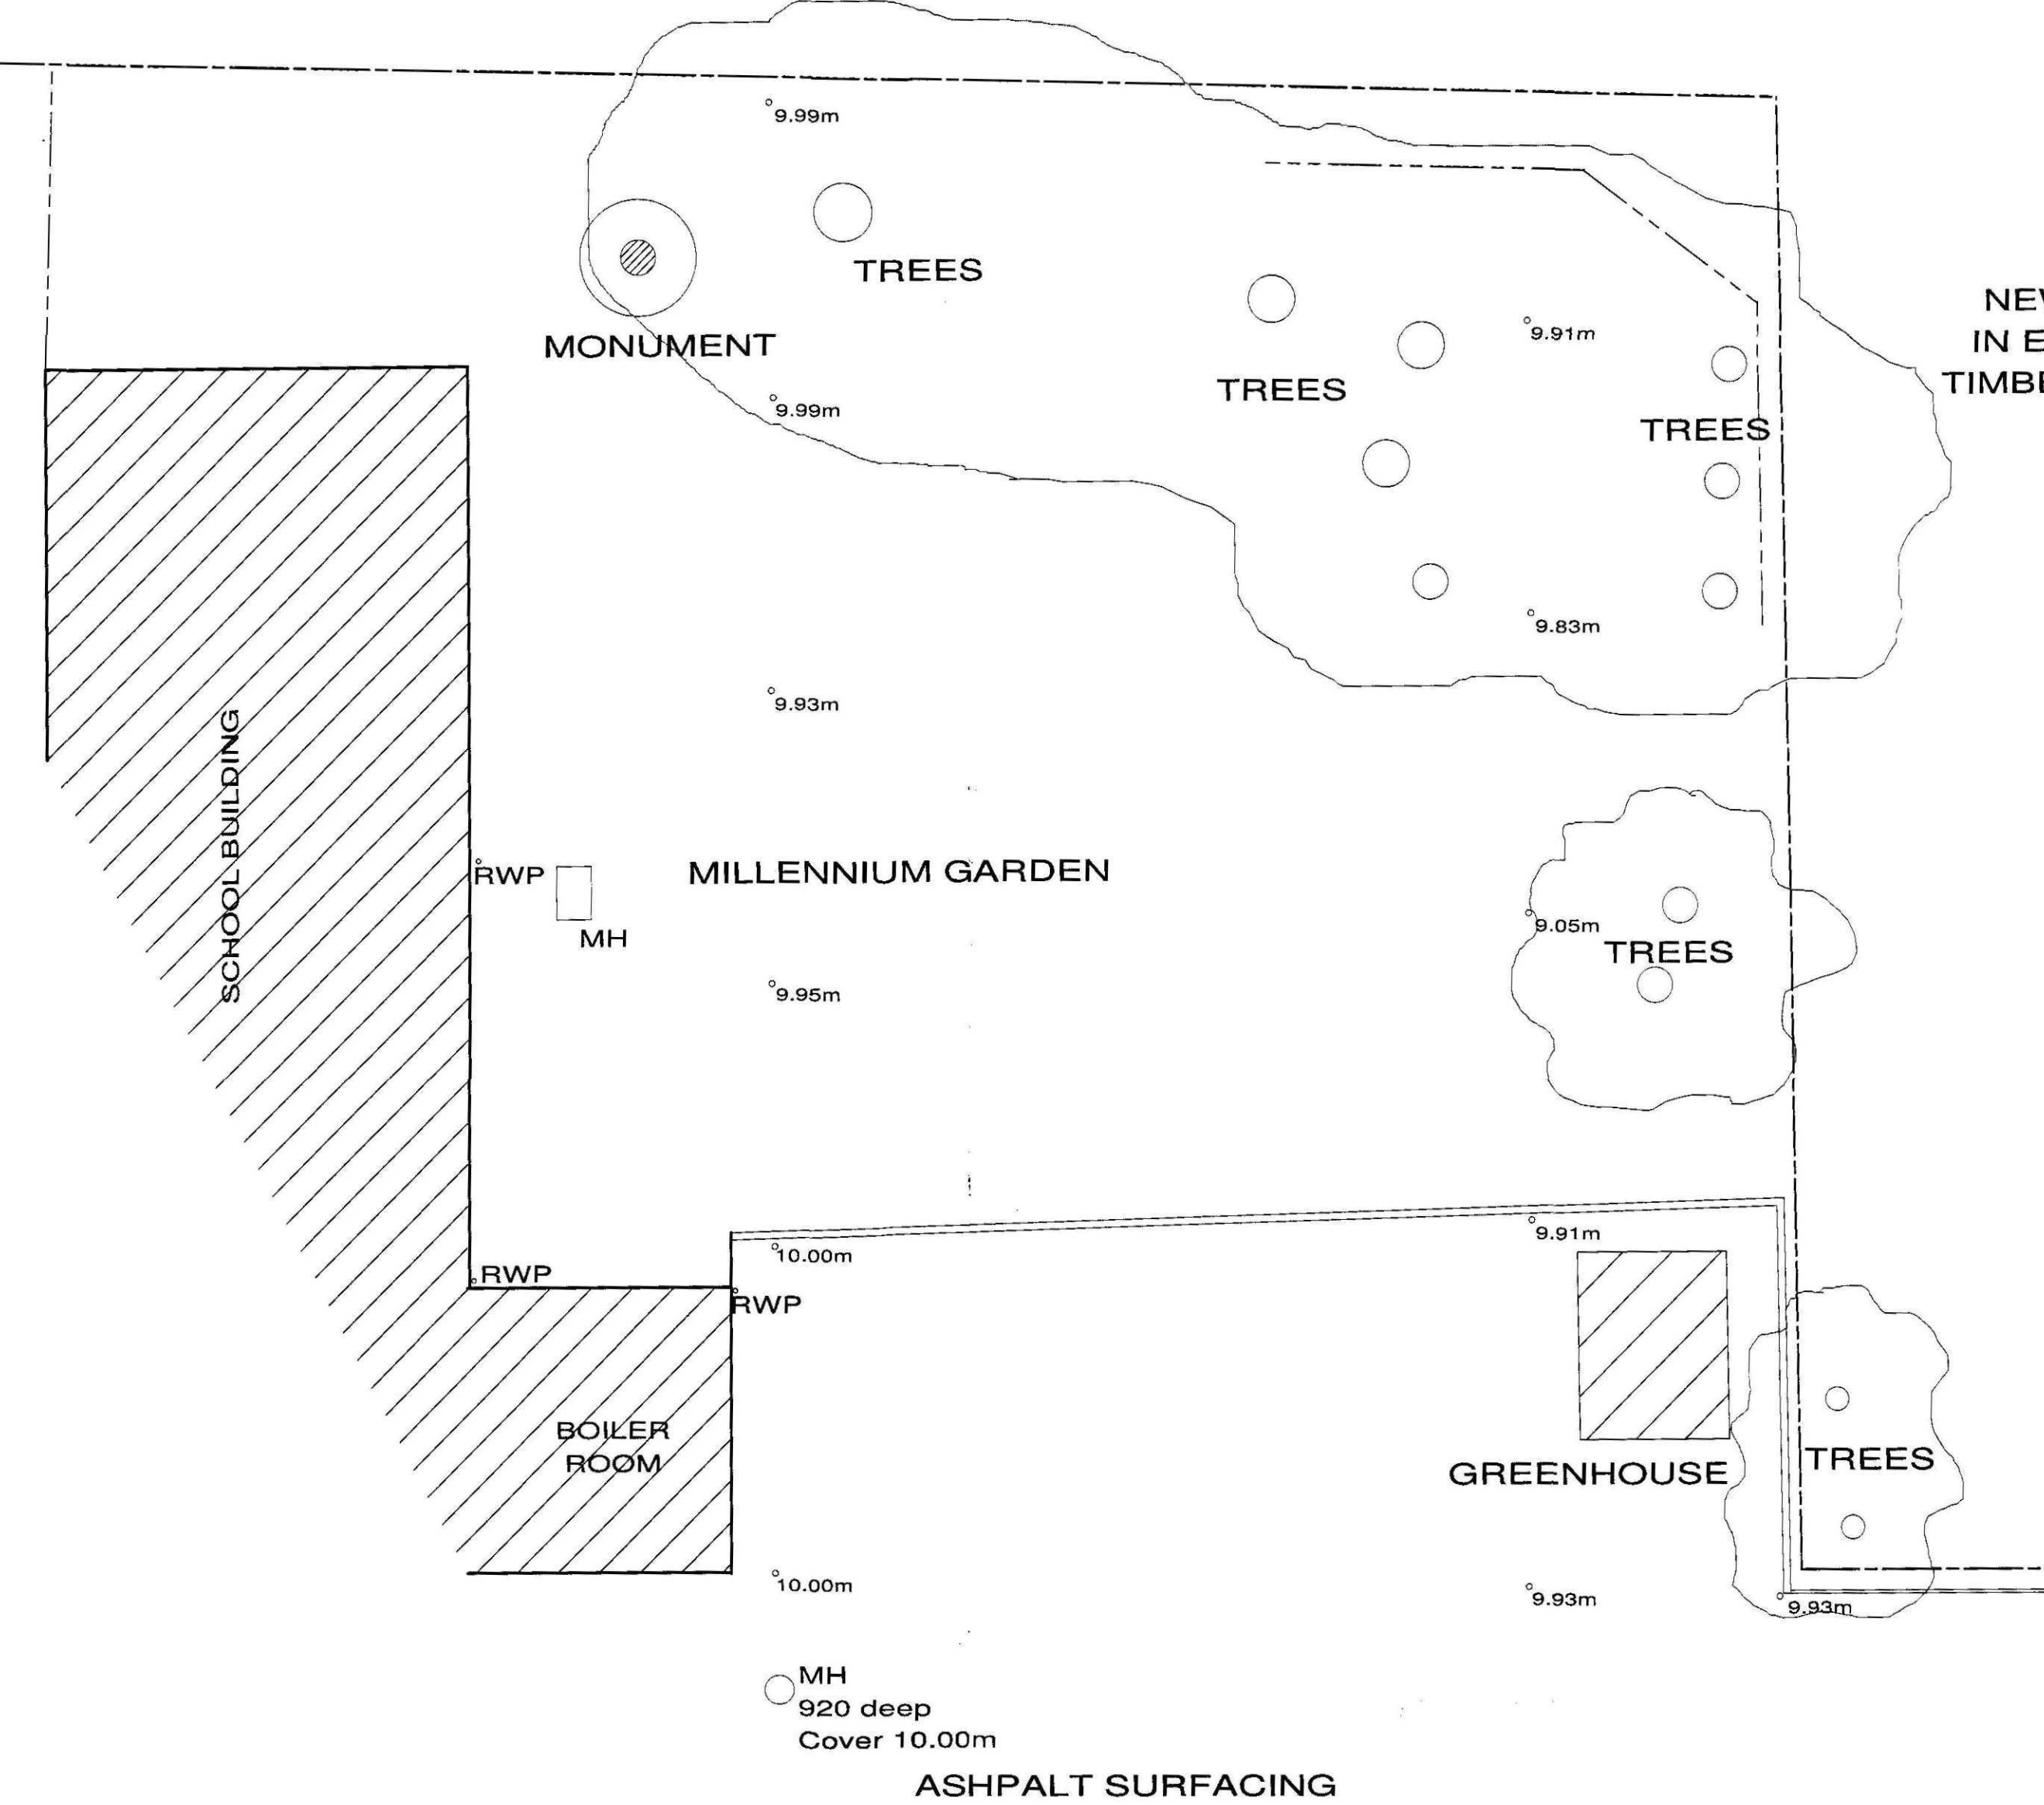


EXISTING PLAN

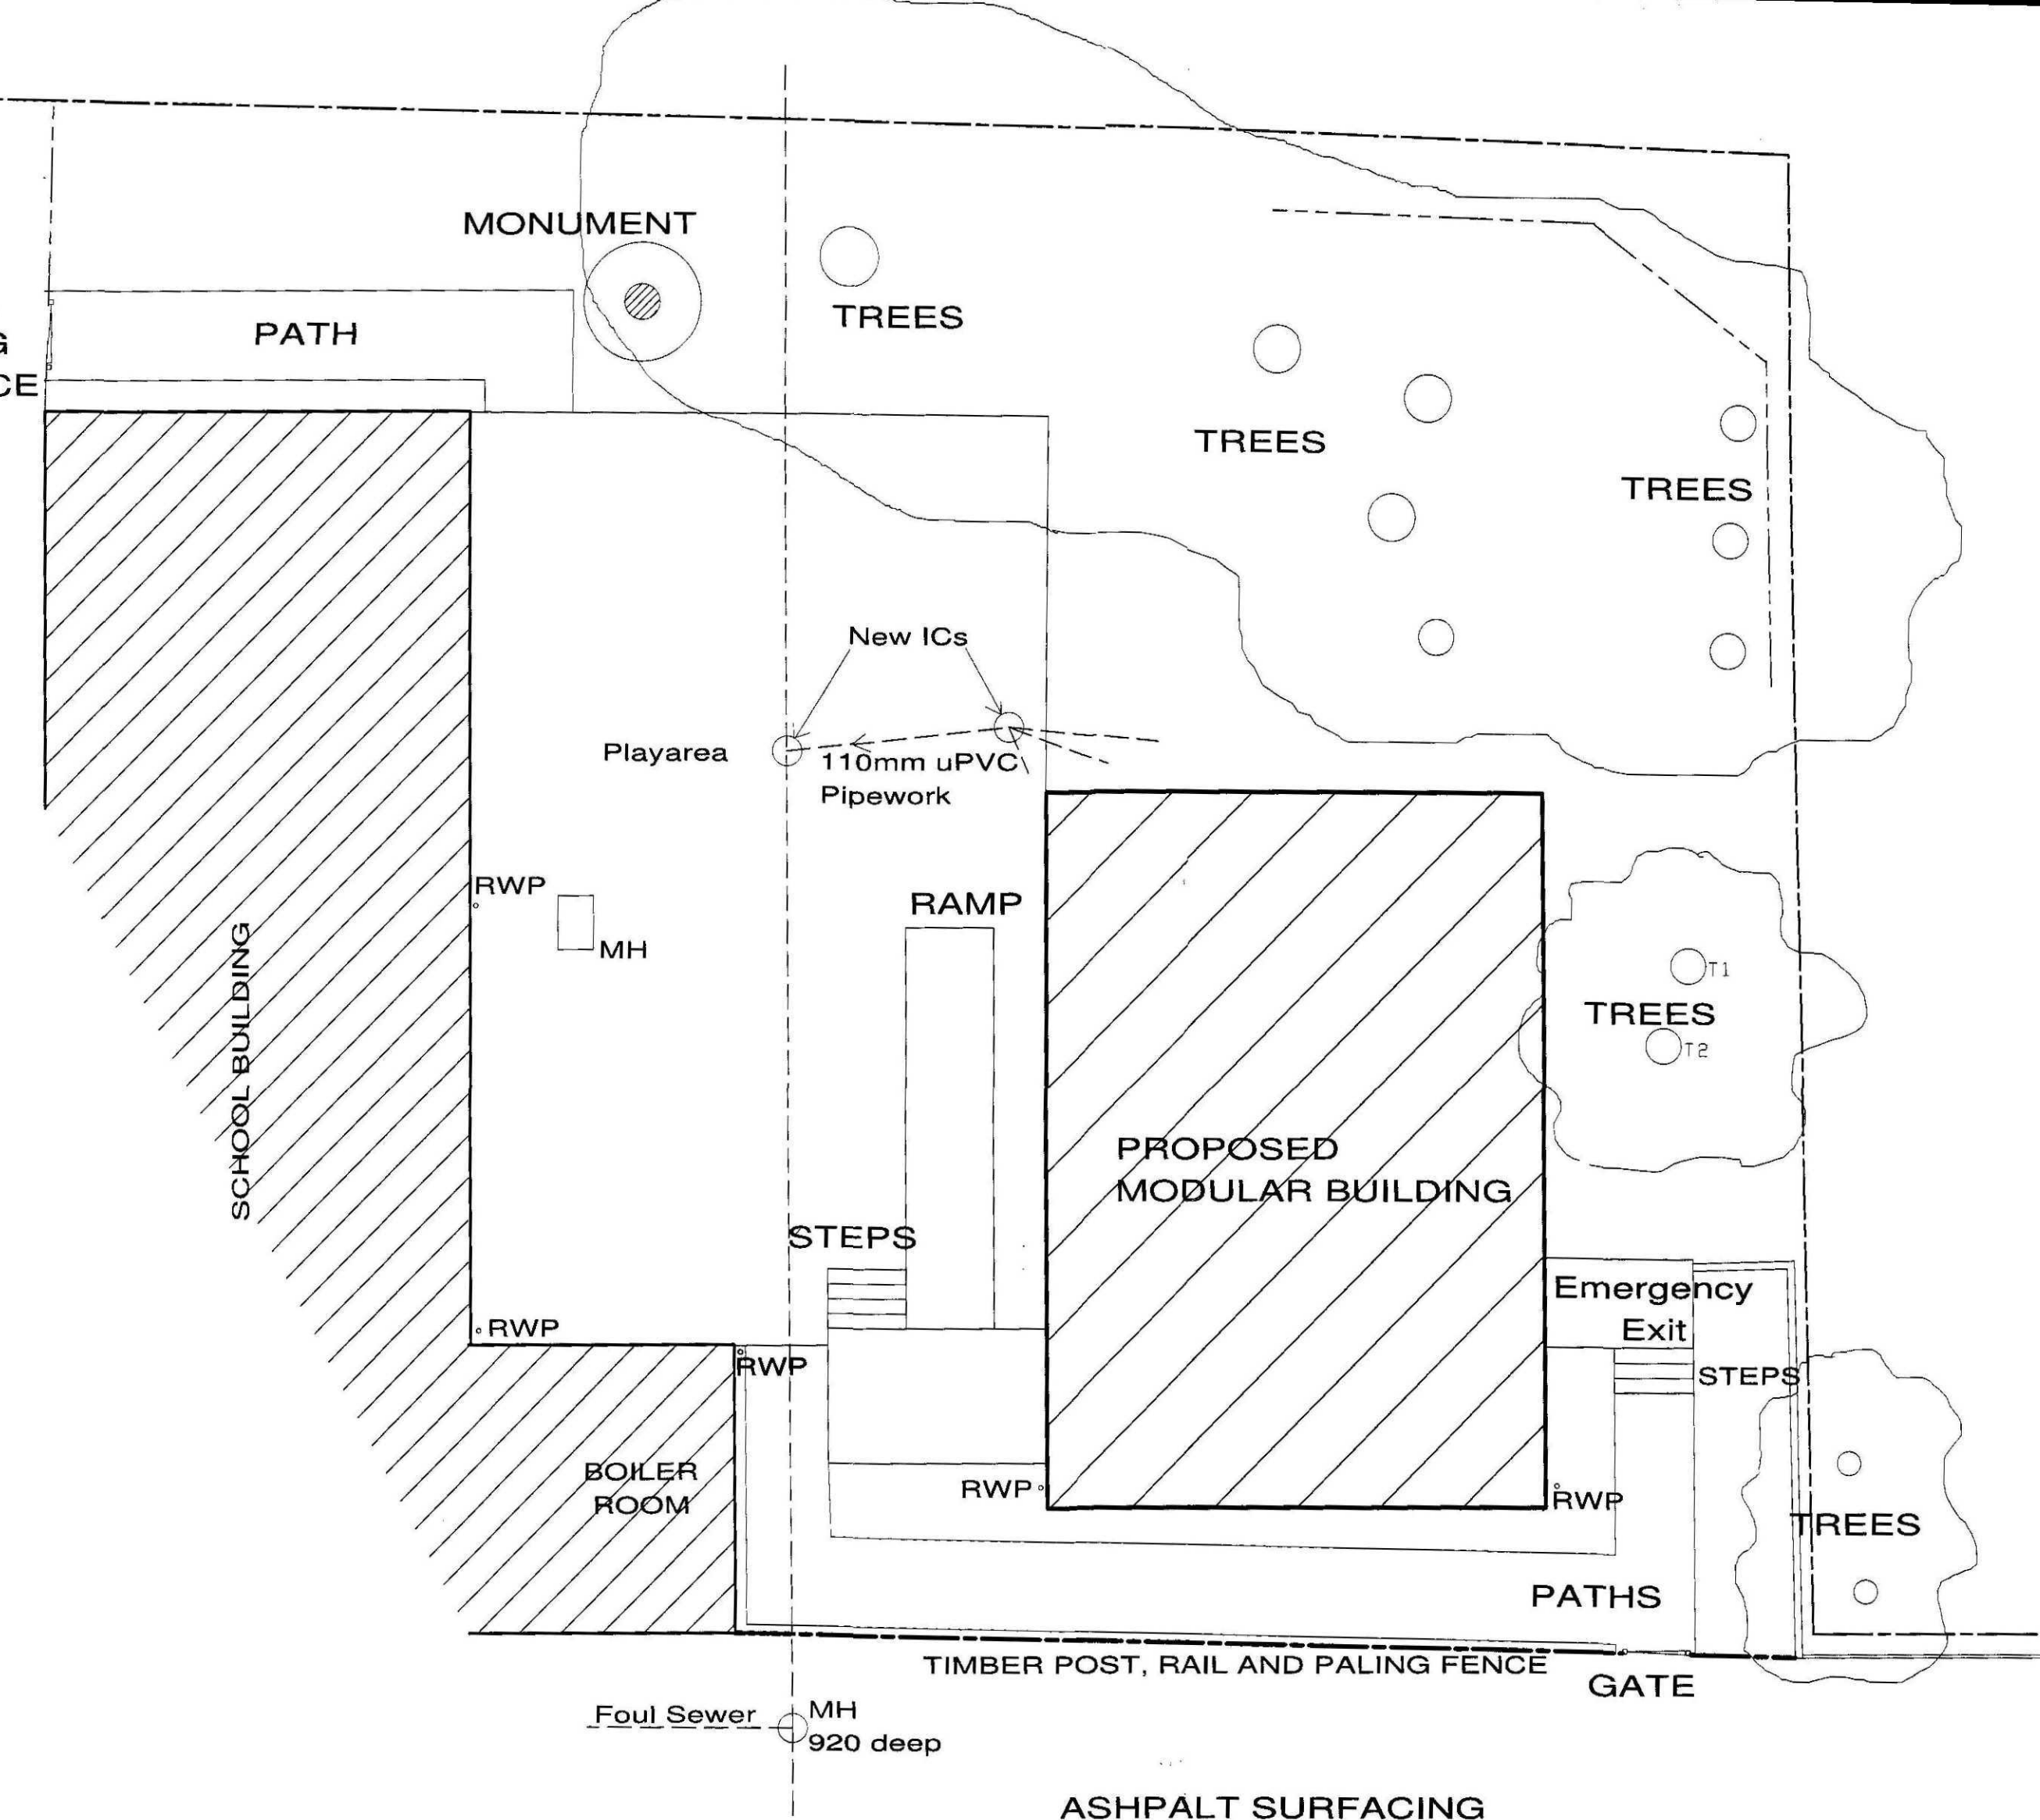

PROPOSED PLAN



FRONT ELEVATION OF TIMBER FENCE

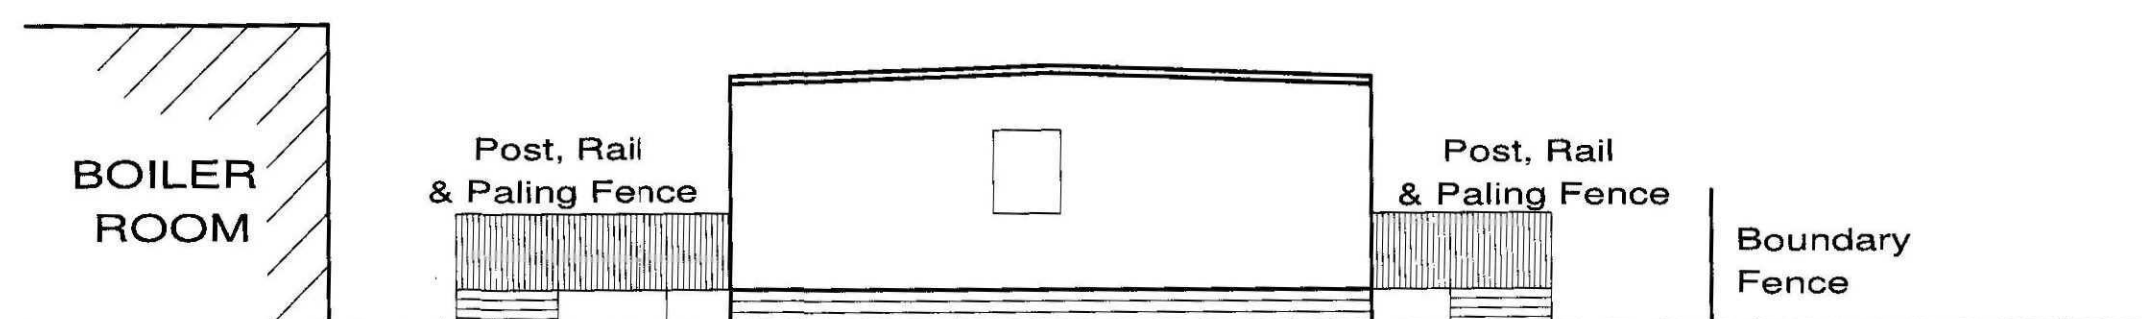

PROPOSED END ELEVATION FROM ROAD
Omitting fence for clarity

**DETERMINED
PLAN**

For details of the proposed modular building
see drawing EG06602-101 C

No trees to be removed as part of this scheme
but lower limbs may be trimmed

Diocese of Lincoln Board of Education

**Diocesan Education Centre
Diocesan Offices
The Old Palace
Minster Yard
LINCOLN
LN2 1PU**



Tydd St Mary Church of England Primary School


Proposed Modular Building

Drawing No: TYD.14 / 04


Date: 29/10/2008 Drawn: MJP Scale: 1/50

At A1 size

SHDC
Planning & Development
27 FEB 2009
Ref: 0144/09

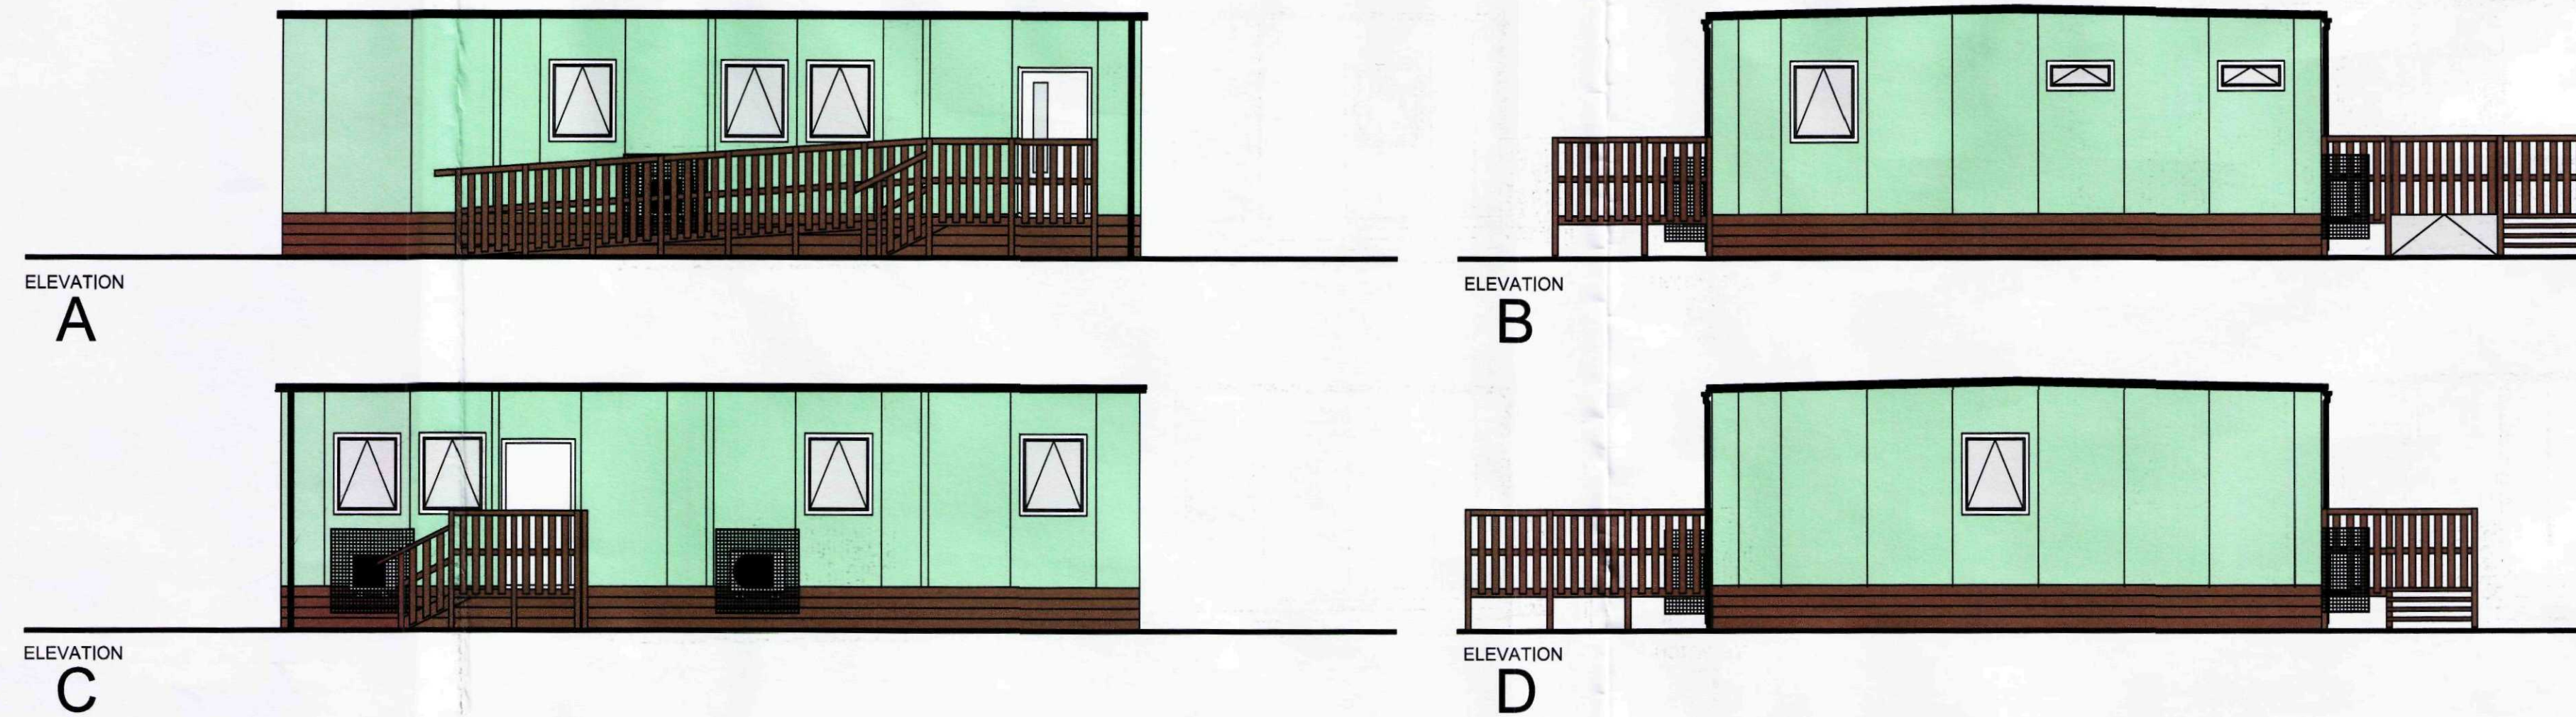

DRAWING SYMBOL KEY

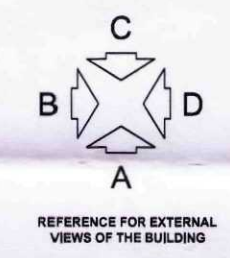

- NOTES**
- This drawing and any information or descriptive matter set hereon is the confidential property of Elliott Modular; and must not be disclosed, loaned, copied or used for manufacturing, tendering or any other purpose without the prior consent in writing of Elliott Modular.
 - All dimensions are to be checked on site.
 - Do not scale from this drawing, work to figured dimensions only.
- REVISION**
- | NO. | REVISION | DATE |
|-----|--|----------|
| 1 | First Issue | |
| 2 | Steps added in lieu of ramp to exit, EL 20/08/08 | 20/08/08 |
| 3 | Building weights & electrical chart added, EL 20/08/08 | 20/08/08 |

CLIENT
Diocese Of Lincoln Board Of Education
Tydd St. Mary C.E. Infant School

PROJECT
Elliott Steelplan Single (ELV)
4 No. Units 3.000 x 8.400m
20 Place Nursery Accommodation

DRAWING TITLE
Plan & Elevation Layout

DRAWN BY/DATE DC 05/08/08
CHECKED BY/DATE BJP 07/08/08

SCALE
1:50 1:75 @ A1
DRAWING NUMBER EG06602-101
REVISION C

Elliott Modular
Building Solutions
Tel 01733 298700 • Fax 01733 573543
www.elliottmodular.co.uk

DETERMINED PLAN



SHDC
Planning & Development
27 FEB 2009
Ref: 0144/09

Client:	Diocese of Lincoln	
	Tydd St Mary CE School	
Building No.	Ex-Works Mass, in kg's	Basic Mass, in kg's
M080345/01	4600	3400
M080345/02	2900	2800
M080345/03	2900	2800
M080345/04	2900	2400

Note 1: The estimated calculated weight does not include any additional items i.e. site trims, etc.

Note 2: Lifting limit on Steelplan Single is 6400kg

Module Details		Qty	Designation									
Time Clock		1										
Sumac 204												
Conductors		3										
Geyer EPCO 3P			(L2-5) (L2-2, L1-4) (L2-3, L2-4)									
Cable Size	MCB Type	Current Rating	Circuit Identification	Circuit Number	Phase	Circuit Number	Circuit Identification	Current Rating	MCB Type	Cable Size		
mm ²		Amps						Amps		mm ²		
1.5	C30mA	10	Lighting Kitchen, Store, V.C.'s	1 (1)	(13)	5	Sockets Kitchen	16	C30mA	2.5		
2.5	C30mA	10	New Downflow Heater Des/AVC, Infant WC	1 (2)	(14)	6	Time Clock Supply	6	C30mA	1.5		
1.5	C30mA	10	Lighting Play, Quiet Areas, Staff Cloaks	1 (3)	(15)	5	Sockets Play Area	16	C30mA	2.5		
2.5	C30mA	10	New Downflow Heater Kitchen	2 (4)	(16)	6	Sockets Kitchen	16	C30mA	2.5		
1.5	C30mA	8	Des V.C. Alarm	2 (5)	(17)	6	Sockets Quiet Area, Staff Room	16	C30mA	2.5		
2.5	C30mA	10	Air Con Unit 1 Play Area	2 (6)	(18)	6	Sockets Quiet Area, Staff Room	16	C30mA	2.5		
6	C30mA	32	Cooker	3 (7)	(19)	7	Sockets Quiet Area, Staff Room	16	C30mA	2.5		
2.5	C30mA	16	Water Heater Store	3 (8)	(20)	7	Sockets Quiet Area, Staff Room	16	C30mA	2.5		
2.5	C30mA	10	Air Con Unit 2 Play Area	3 (9)	(21)	7	Sockets Quiet Area, Staff Room	16	C30mA	2.5		
1.5	C30mA	8	Fire Alarm Supply	4 (10)	(22)	8	Sockets Quiet Area, Staff Room	16	C30mA	2.5		
2.5	C30mA	16	Water Heater Kitchen	4 (11)	(23)	8	Sockets Quiet Area, Staff Room	16	C30mA	2.5		
2.5	C30mA	10	Air Con Unit 3 Staff Room	4 (12)	(24)	8	Sockets Quiet Area, Staff Room	16	C30mA	2.5		
125A Isolator												
Job Title: TYSM& Mary C/E Infant School.												
Job No: 1488454												
Date: 15-Sep-88												
Specifier: Simon												
Loading: 33 Amps Three Phase												
Cable Type: 62428 62423												
Notes: This Circuit is spare is not open to modification unless authorised to do so by Space Electrical Design Department												
Used Effort split: plus client details To Client Spec.												

Job Title: Tydd St. Mary C.E. Infant School
Job No: 1888245
Date: 18-Sep-08
Specifier: Simon
Loading: 33 Amps Three Phase
Cable Type: 024B 02433
Notes: This Circuit is not open to modification unless authorised to do so by Space Electrical Design Department
Used Elliott spec, plus client additions To Client Spec.
Downflow Heaters - Set to 10w & pull cord removed

